

GR-RS-SC JOINT POWERS WATER BOARD

CROSSROADS PUMP STATION

GR-RS-SC JOINT POWERS WATER BOARD

ROB YOUNG CHAIRMAN
JASON PALMER VICE CHAIRMAN
TERRY LEIGH SECRETARY/TREASURER
AARON REICHI BOARD MEMBER
RICK LEE BOARD MEMBER
BRYAN SEPPIE, P.E. GENERAL MANAGER
JAMES TARDONI, P.E. ENGINEER
DAVE LATORRE PRODUCTION MANAGER

ENGINEERING CONSULTANTS

DAVE KENNINGTON, P.E. PROJECT ENGINEER
KIM P. HARRIS, P.E. MECHANICAL ENGINEER
BURNS & MCDONNELL ELECTRICAL ENGINEER



RELEASED FOR BID



JOINT POWERS
WATER BOARD


GREEN RIVER - ROCK SPRINGS - SWEETWATER COUNTY



47 EAST 4TH AVENUE
AFTON, WYOMING 83110
TEL 307.885.8500 • FAX 307.885.8501
www.sunrise-eng.com

VICINITY MAP

NOT TO SCALE

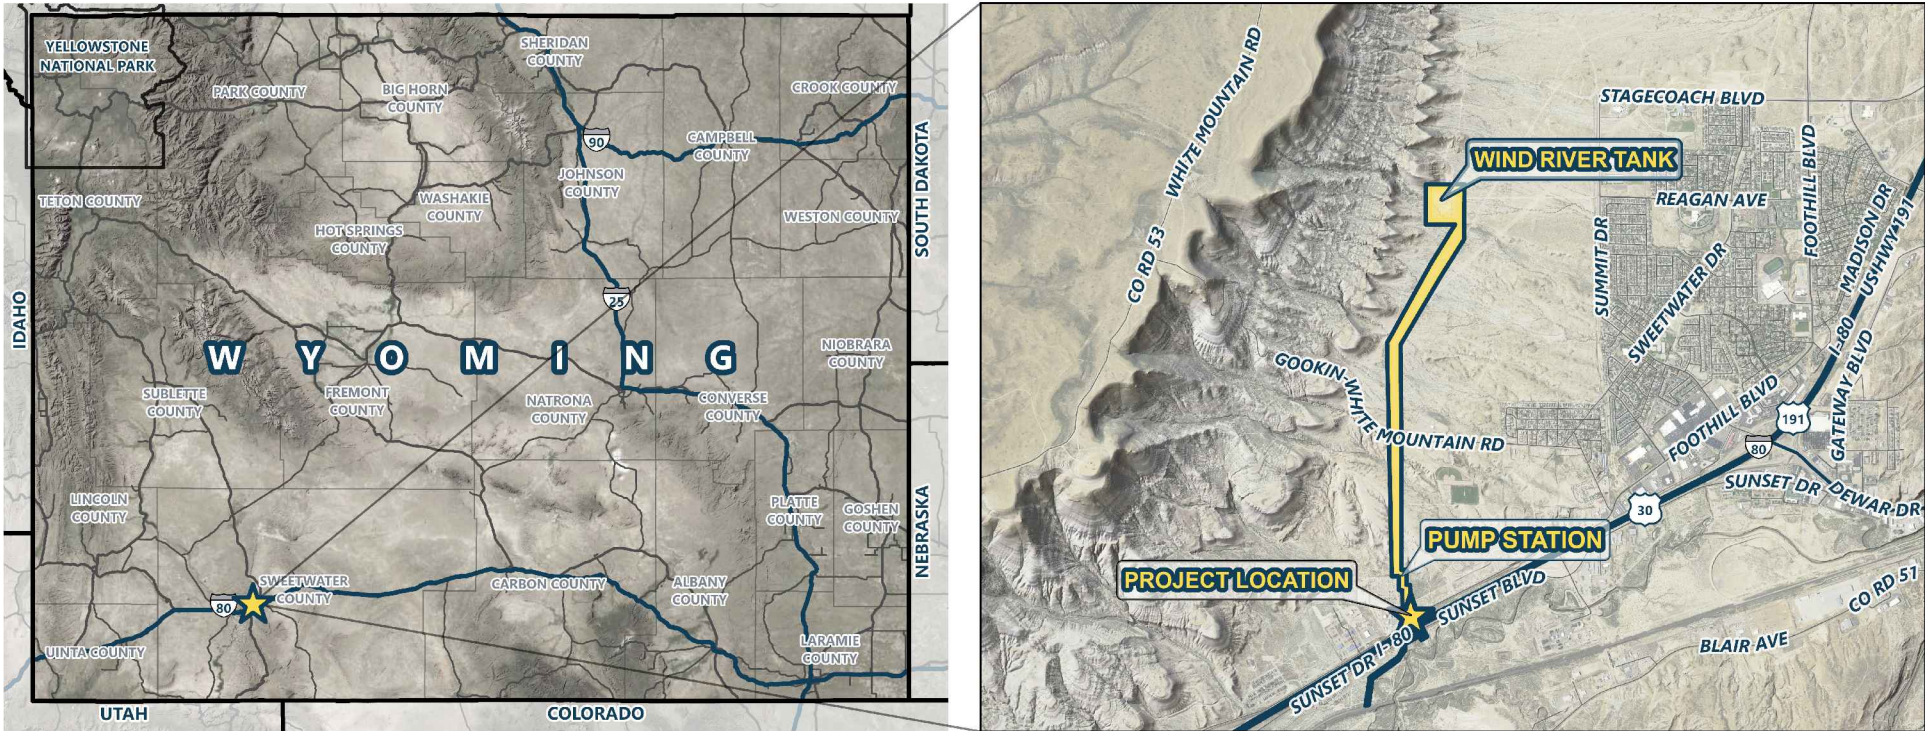

SHEET INDEX

1 - GENERAL:

COVER SHEET	DWG. NO	SHEET NO.
AREA MAP, LOCATION MAP, AND SHEET INDEX	G1	1
ABBREVIATIONS AND LEGEND	G2	2
DESIGN CRITERIA AND SYSTEM CURVE	G3	3
HYDRAULIC GRADE PROFILE	G4	4
SOIL TYPES	HP	5
	SOIL	6

2 - PUMP STATION SITE PLANS:

OVERALL SITE PLAN	DWG. NO	SHEET NO.
SITE PLAN	SP1	7
GRADING PLAN	SP2	8
FENCE DETAILS	GP	9
ACCESS ROAD PLAN AND PROFILE	F1	10
ACCESS ROAD TYPICAL SECTIONS	PR1	11
	RS1-RS3	12-14

3 - WATERLINE PLAN & PROFILE SHEETS:

30" WATER PIPELINE PLAN AND PROFILES	DWG. NO	SHEET NO.
	PP1-PP15	15-29

4 - PUMP STATION ARCHITECTURAL SHEETS:

FLOOR PLAN	DWG. NO	SHEET NO.
ELEVATION VIEWS	A1	30
TYPICAL WALL SECTIONS	A2-A4	31-33
	A5	34

5 - PUMP STATION STRUCTURAL SHEETS:

FOOTING AND FOUNDATION PLAN	DWG. NO	SHEET NO.
MASON WALL LAYOUT & REINFORCEMENT	S1-S2	35-36
ROOF FRAMING	S3	37
MASONRY DETAILS	S4	38
	S5-S9	39-43

6 - MECHANICAL PIPING SHEETS:

MECHANICAL PIPING PLAN	DWG. NO	SHEET NO.
MECHANICAL PIPING ELEVATION	MP1	44
MECHANICAL PIPING SECTIONS	MP2	45
	MP3-MP4	46-47

7 - ELECTRICAL SHEETS:

ELECTRICAL GENERAL NOTES, SYMBOLS AND ABBREIAVTIONS	DWG. NO	SHEET NO.
ELECTRICAL MATERIALS, DESIGNATION, AND HAZARDOUS CLASSIFICATION	00E-001	48
AREA CLASSIFICATION, MATERIALS AND CONDUIT SCHEDULES	00E-002	49
LUMINAIRE SCHEDULE	00E-003	50
LOAD SCHEDULE	00E-010	51
GENERAL ONE-LINE DIAGRAMS	00E-100	52
GENERAL PANEL SCHEDULES	00E-110	53
MAIN CONNECTION DIAGRAM	00E-120	54
CONTROL SCHEMATICS	00E-150	55
ELECTRICAL DETAILS	00E-200	56
NETWORK ARCHITECTURE	00E-300 - 00E-303	57-60
ELECTRICAL SITE PLAN	00E-400	61
ELECTRICAL POWER AND GROUNDING PLAN	00ES-100	62
ELECTRIC INSTRUMENTATION AND CONTROLS PLAN	01EP-101	63
ELECTRICAL LIGHTING AND RECEPTACLES	01EL-101	64
PROCESS AND INSTRUMENTATION LEGENDS AND ABBREVIATIONS	01EI-101	65
BOOSTER PUMP P&ID	00DI-001 - 00DI-002	66-67
	01DI-101 - 01DI-103	68-70

8 - MECHANICAL SHEET:

MECHANICAL SYMBOLS, LEGEND & SCHEDULES	DWG. NO	SHEET NO.
MECHANICAL DETAILS	M1	71
MECHANICAL SPECIFICATIONS	M2	72
MECHANICAL PLAN	M3-M4	73-74
MECHANICAL SECTIONS	M5	75
	M6-M8	76-78


9 - DETAILS

PIPING DETAILS	DWG. NO	SHEET NO.
I-80 PIPELINE CROSSING PLAN AND PROFILE	D1-D5	79-83
BRIDGER PIPELINE CROSSING	D6	84
WATERLINE CONNECTIONS	D7	85
MANWAY / AIR VAC DETAILS	D8	86
CATHODIC PROTECTION DETAILS	D9-D13	87-91
PUMP STATION HOIST DETAILS	D14-D16	92-94
EROSION CONTROL DETAILS	D17	95
PUMP STATION WARNING SIGNS	D18	96
PIPELINE DETAILS	D19	97
	D20-D21	98-99

REV. NO.	COMMENT	DATE
SUNRISE ENGINEERING 770 S WASHINGTON ST. AFTON, WYOMING 83110 TEL 307.885.8500 • FAX 307.885.8501 www.sunrise-eng.com		
GR-RS-SC JPWB		
CROSSROADS PUMP STATION AREA MAP, LOCATION MAP, AND INDEX SHEET		
SEI NO. 07265	DESIGNED FDK	DRAWN BJ
CHECKED JUL	SHEET NO. 2 of 99	G2


GENERAL LEGEND

 CROSS REFERENCING



NEW CONTOURS	—————
EXIST. CONTOURS	— — — — —
EXIST. FEATURES	— — — — —
NEW WATER	— 8" W —
EXIST. WATER	— 8" w —
EXIST. GAS	— — — — — g —
EXIST. TELEPHONE	— — — — — t —
NEW SEWER	— 8" S —
EXIST. SEWER	— — — — — 8" s —
EXIST. FIBER OPTIC	— — — — — fo —
EXIST. IRRIGATION	— — — — — irr —
EXIST. BURIED POWER	— — — — — uge —
EXIST. OVERHEAD POWER	— — — — — ohe —
EASMENT	— — — — —
PROPERTY LINE	— — — — —
NEW GATE VALVE	
EXIST. GATE VALVE	
NEW PRESSURE REDUCING VALVE	
EXIST. PRESSURE REDUCING VALVE	
NEW BLOWOFF VALVE	
EXIST. BLOWOFF VALVE	
NEW BUTTERFLY VALVE	
EXIST. BUTTERFLY VALVE	
NEW CHECK VALVE	
EXISTING CHECK VALVE	
NEW FROSTLESS YARD HYDRANT	
EXIST. FROSTLESS YARD HYDRANT	
NEW AIR RELEASE VALVE	
EXIST. AIR RELEASE VALVE	
NEW PUMP	
EXIST. PUMP	
NEW REDUCER	
EXIST. REDUCER	
NEW CROSS	
EXIST. CROSS	
NEW TEE	
EXIST. TEE	
NEW ELBOW	
EXIST. ELBOW	
NEW BEND	

 EXIST. BEND
NEW WYE
EXIST. WYE
NEW PLUG
EXIST. PLUG
NEW FLEX. COUPLING
EXIST FLEX. COUPLING
NEW FIRE HYDRANT
NEW FIRE HYDRANT STUB
EXIST. FIRE HYDRANT
CONNECT EXIST. FIRE HYDRANT
TO NEW MAIN PER
NEW SERVICE LATERAL
EXIST. WATER SERVICE CONN.
NEW METER
NEW RV WATER SERVICE
EXIST. RV WATER SERVICE
NEW SPRING BOX
EXIST. SPRING BOX
NEW GAS SERVICE CONN.
EXIST. GAS SERVICE CONN.
BENCH MARK
NEW STOCK FENCE
EXIST. CHAINLINK FENCE
SURFACE WATER FLOW
POWER POLE
NEW MANHOLE
EXIST. MANHOLE
SEWER MANHOLE NO.
NEW CLEANOUT
EXIST. CLEANOUT
SEWER CLEANOUT NO.
NEW CAP
NEW SEWER SERVICE LATERAL
NEW RV SEWER SERVICE
EXIST. RV SEWER SERVICE
THRESHOLD ELEV.
BASEMENT FLOOR ELEV.
SLOPE (PLAN VIEW)



GENERAL NOTES

1. THE CONTRACTOR SHALL KEEP PUBLIC ROADS CLEAR OF MUD AND DEBRIS. DUST SHALL BE CONTROLLED BY WATERING.
2. ALL WORK AND ANY CHANGES TO THE WORK ARE SUBJECT TO APPROVAL BY THE JOINT POWERS WATER BOARD, AND CITY OF ROCK SPRINGS
3. ALL CONSTRUCTION WORK SHALL BE PERFORMED WITHIN EXISTING RIGHTS-OF-WAY.
4. ALL DEBRIS AND ROCK RESULTING FROM THE WORK SHALL BE DISPOSED OF BY THE CONTRACTOR. MATERIAL MUST BE DISPOSED OF AT A LOCATION ARRANGED BY THE CONTRACTOR.
5. THE PROJECT AREA HAS WATER PIPELINES, SEWER COLLECTION PIPELINES, OIL AND GAS PIPELINES, TELEPHONE LINES, STORM DRAINAGE PIPELINES, AND UNDERGROUND POWER LINES, UNDERGROUND UTILITIES, AS WELL AS SOME OVERHEAD POWER AND TELEPHONE LINES. SOME OF THESE UTILITIES HAVE BEEN SHOWN ON THIS PLAN-SET. THE CONTRACTOR HAS THE ULTIMATE RESPONSIBILITY OF LOCATING ALL UNDERGROUND AND OVERHEAD UTILITIES AND PROTECTING THEM FROM DAMAGE. ONE CALL OF WYOMING CAN BE REACHED AT 811.
6. ALL DRIVES AND ACCESSSES SHALL REMAIN OPEN TO INGRESS AND EGRESS DURING CONSTRUCTION.
7. ALL PRIVATE PROPERTY SHALL BE PROTECTED FROM STORMWATER DISCHARGE DURING CONSTRUCTION.
8. FINAL GRADE OF DISTURBED AREAS IS SUBJECT TO THE ENGINEER'S APPROVAL AND IS TO BE DONE WITH NEAT WORKMANSHIP.
9. THE CONTRACTOR SHALL PREPARE AND IMPLEMENT A STORM WATER POLLUTION PREVENTION PLAN (SWPPP) IN ACCORDANCE WITH DEQ REQUIREMENTS.
10. ALL PIPELINES SHALL BE INSTALLED AT THE LOCATION AND DEPTHS REQUIRED OF THE PLANS OR AS OTHERWISE DIRECTED BY THE ENGINEER.
11. ALL EXCAVATIONS, TRENCHING, AND SHORING SHALL MEET THE REQUIREMENTS OF THE WYOMING OCCUPATIONAL HEALTH AND SAFETY COMMISSION.
12. THE CONTRACTOR SHALL PROVIDE AND MAINTAIN, AT ALL TIMES DURING CONSTRUCTION, AMPLE MEANS AND DEVICES TO PROMPTLY

ABBREVIATIONS

AB	ANCHOR BOLT	GSP	GALVANIZED STEEL PIPE
ALUM.	ALUMINUM	GV	GATE VALVE
APPROX.	APPROXIMATELY	HORIZ.	HORIZONTAL
ASSY.	ASSEMBLY	HV	HOSE VALVE
∠	ANGEL	ID	INSIDE DIAMETER
@	AT (MEASUREMENTS)	IN or "	INCH
B.F.	BLIND FLANGE	INSUL.	INSULATION
BLDG.	BUILDING	INV.	INVERT
B.M.	BENCH MARK	LB. or #	POUND LINEAL FEET
BSC	BITUMINOUS SURFACE COURSE	LF	LINEAL FEET
B.W.	BOTH WAYS	LN.	LINEAL
C	CHANNEL (STRUCTURAL)	MAX.	MAXIMUM
CI	CAST IRON	MECH.	MECHANICAL
CFM	CUBIC FEET PER MINUTE	MFR.	MANUFACTURER
CFS	CUBIC FEET PER SECOND	MIN.	MINIMUM
¢	CENTER LINE	MJ	MECHANICAL JOINT
CMP	CORRUGATED METAL PIPE	NO. or #	NUMBER
CO	CLEAN OUT	O.C.	ON CENTER
CONC.	CONCRETE	OD	OUTSIDE DIAMETER
CONT.	CONTINUOUS	PE	POLYETHYLENE
CPLG.	COUPLING	PE. PIPE	POLYETHYLENE PIPE
CU. FT.	CUBIC FEET	PL.	PLATE
CU. YD.	CUBIC YARD	¢	PROPERTY LINE
DEG. or °	DEGREE	PSI	POUNDS per SQUARE INCH
DET.	DETAIL	PVC	POLYVINYL-CHLORIDE PIPE
DIA. or Ø	DIAMETER	R	RADIUS
DIAG.	DIAGONAL	REM.	REMOVE
DIM	DIMENSION	REQ'D	REQUIRED
DIP	DUCTILE IRON PIPE	REV.	REVISION
DIST.	DISTRIBUTION	R/W	RIGHT-OF-WAY
DWG.	DRAWING	RV	RECREATION VEHICLE
EA.	EACH	S	SLOPE
E.F.	EACH FACE	SPEC.	SPECIFICATION
ELB.	ELBOW	SQ.	SQUARE
ELEV.	ELEVATION	SQ. FT.	SQUARE FEET
E.W.	EACH WAY	SQ. IN.	SQUARE INCHES
EXIST.	EXISTING	STA.	STATION
F.G.	FINISH GRADE	STD.	STANDARD
FLEX.	FLEXIBLE	STL.	STEEL
FLG.	FLANGE	ST. STL	STAINLESS STEEL
FT or '	FEET	TYP.	TYPICAL
GA.	GAUGE	W/	WITH
GALV.	GALVANIZED	W/O	WITHOUT
GPM	GALLONS per MINUTE	W/REQ'D.	WHERE REQUIRED

CLEARANCE SURVEY NOTES

THE CONTRACTOR SHALL CONDUCT A PRE CONSTRUCTION CLEARANCE SURVEY FOR MIGRATORY BIRDS DURING THE AVIAN BREEDING SEASON (APRIL 15 TO JULY 31). SURVEY SHALL BE CONDUCTED BY A QUALIFIED BIOLOGIST WITH NEST SEARCHING EXPERIENCE. CONDUCT NEST SEARCHES WITHIN 72 HOURS OF DISTURBANCE FROM APRIL 10TH TO JULY 15TH. A MIGRATORY BIRD NEST CLEARANCE SURVEY IN LATE FEBRUARY AS SUGGESTED IN THE PROVIDED DOCUMENTATION WILL NOT BE EFFECTIVE AT MINIMIZING IMPACTS TO MIGRATORY BIRDS. IF A MIGRATORY BIRD NEST IS FOUND, CEASE OPERATIONS UNTIL THE BIRDS HAVE FLEDGED AND CAN LEAVE THE AREA. DEVELOPMENT OF AN APPROVED MITIGATION PLAN IN COORDINATION WITH THE U.S. FISH AND WILDLIFE SERVICE MAY ALLOW FOR SOONER INITIATION OF OPERATIONS. THE COST OF CLEARANCE SURVEYS SHALL BE BORNE BY THE CONTRACTOR.



THE WASATCH FORMATION PRESENT IN THE PROJECT AREA CAN PRODUCE SIGNIFICANT FOSSILS. ALTHOUGH MINIMAL FOSSILS WERE FOUND DURING THE PALEONTOLOGICAL CLEARANCE SURVEY, OPERATORS AND WORKERS SHOULD BE MADE AWARE OF THE POTENTIAL FOR FOSSILS. IF, AFTER THE COMMENCEMENT OF SURFACE-DISTURBING ACTIVITIES, THE BLM OR THE OPERATOR DISCOVER RESOURCES THAT WERE NOT NOTED IN THE EARLIER SURVEYS, THE OPERATOR MUST IMMEDIATELY CEASE SURFACE DISTURBING ACTIVITIES NEAR THE FIND AND NOTIFY THE BLM DISTRICT/FIELD MANAGER OF ANY POTENTIAL CULTURAL AND/OR PALEONTOLOGICAL RESOURCES ON FEDERAL LANDS THAT MIGHT BE ALTERED OR DESTROYED BY CONTINUED OPERATIONS. THE OPERATOR MUST LEAVE SUCH DISCOVERY INTACT UNTIL RECEIVING WRITTEN NOTICE TO PROCEED FROM THE DISTRICT/FIELD OFFICE. THE DISTRICT/FIELD MANAGER WILL EVALUATE THE DISCOVERIES BROUGHT TO HIS OR HER ATTENTION, TAKE ACTION TO PROTECT OR REMOVE THE RESOURCE, AND ALLOW OPERATIONS TO PROCEED WITHIN 10 WORKING DAYS AFTER NOTIFICATION TO THE DISTRICT/FIELD OFFICE OF SUCH DISCOVERY, UNLESS ALTERNATIVE ARRANGEMENTS ARE NEGOTIATED WITH THE OPERATOR. IF THE RESOURCES DISCOVERED ARE OBJECTS SUBJECT TO THE NATIVE AMERICAN GRAVES PROTECTION AND REPATRIATION ACT OF 1990 (NAGPRA), THEN OPERATIONS CAN BE SUSPENDED FOR 30 DAYS. THE ABOVE SUSPENSIONS OR DELAYS SHALL NOT CONSTITUTE CAUSE FOR ADDITIONAL CHARGES TO THE OWNER.

KINDER MORGAN OPERATES PIPELINES IN THE PROJECT AREA AND HAS ENCROACHMENT REQUIREMENTS OUTLINED IN THE BIDDING DOCUMENTS. THE CONTRACTOR SHALL COMPLY WITH THE GUIDELINES FOR DESIGN AND CONSTRUCTION NEAR KINDER MORGAN OPERATED FACILITIES INCLUDING INSURANCE REQUIREMENTS.

- REMOVE ALL WATER ENTERING THE WORK, WHETHER THE WATER IS SURFACE OR GROUND WATER.
- NOT EVERY CONDITION OR ELEMENT IS SHOWN ON THE PLANS. IT IS UNDERSTOOD THAT THE CONTRACTOR WILL USE INDUSTRY ACCEPTED STANDARD GOOD PRACTICE FOR ALL MISCELLANEOUS WORK NOT EXPLICITLY SHOWN.
- THE CONTRACTOR SHALL BE RESPONSIBLE FOR VERIFICATION OF ALL DIMENSIONS, ELEVATIONS AND CONDITIONS THAT COULD IMPACT THE WORK. IN THE EVENT OF A DISCREPANCY OR QUESTION, THE CONTRACTOR SHALL FORWARD SAID QUESTION TO THE ENGINEER FOR CLARIFICATION.
- THE CONTRACTOR SHALL FIELD VERIFY THE LOCATION OF THE EXISTING CONNECTING WATER LINES PRIOR TO COMMENCING ANY WATER CONSTRUCTION. SHOULD THE LOCATION DIFFER FROM THAT SHOWN ON THE PLANS, THE CONTRACTOR IS TO CONTACT THE ENGINEER FOR DIRECTION.
- THE CONTRACTOR SHALL COMPLY WITH THE WYDOT LICENSE FOUND IN THE SPECIFICATIONS INCLUDING THE REQUIREMENTS TO FOLLOW MUTCD STANDARDS AND THE WYDOT TRAFFIC CONTROL FOR ROADWAY WORK OPERATIONS MANUAL (AVAILABLE AT: [HTTPS://WWW.DOT.STATE.WY.US/HOME/ENGINEERING TECHNICAL PROGRAMS/MANUALS PUBLICATIONS.HTML](https://www.dot.state.wy.us/home/engineering_technical_programs/manuals_publications.html))
- THERE ARE SEVERAL LOCATIONS WHERE THE PIPELINE CROSSES FENCES. FENCES SHALL BE REPLACED OR REPAIRED IN EQUAL OR BETTER CONDITION. FENCE WORK SHALL NOT BE PAID SEPARATELY AND IS CONSIDERED INCIDENTAL TO THE COST OF PIPELINE INSTALLATION. THE CONTRACTOR SHALL CONTROL AND PREVENT ESCAPE OF ANY LIVESTOCK IN THE WORK AREA AND PROTECT OPEN TRENCHES FROM ENTRY BY LIVESTOCK.
- BUILDING CONSTRUCTION TO BE PERMITTED AND INSPECTED BY CITY OF ROCK SPRINGS BUILDING OFFICIAL.

SNOW LOAD = 30PSF.
WIND = 115 MPH EXPOSURE C
UBC ZONE 1
SEISMIC CATEGORY B.
28-DAY CONCRETE STRENGTH 4,000 PSI (TYPE V CEMENT)
- THE CONTRACTOR SHALL VERIFY THE ELEVATION OF CROSSING UTILITIES AHEAD OF PIPELINE PROGRESS BY HYDRO VAC EXCAVATION AND ADJUST GRADE OF PIPELINE TO ALLOW CLEARANCE TO PASS UNDER THE INTERSECTING UTILITY.

REV. NO.	COMMENT	DATE
 770 S WASHINGTON ST. AFTON, WYOMING 83110 TEL 307.885.8500 · FAX 307.885.8501 www.sunrise-eng.com		
GR-RS-SC JPWB		
CROSSROADS PUMP STATION		
ABBREVIATIONS AND LEGEND		
SEI NO. 07265	DESIGNED FDK	DRAWN BJ
CHECKED JUL	SHEET NO. 3 of 99	G3

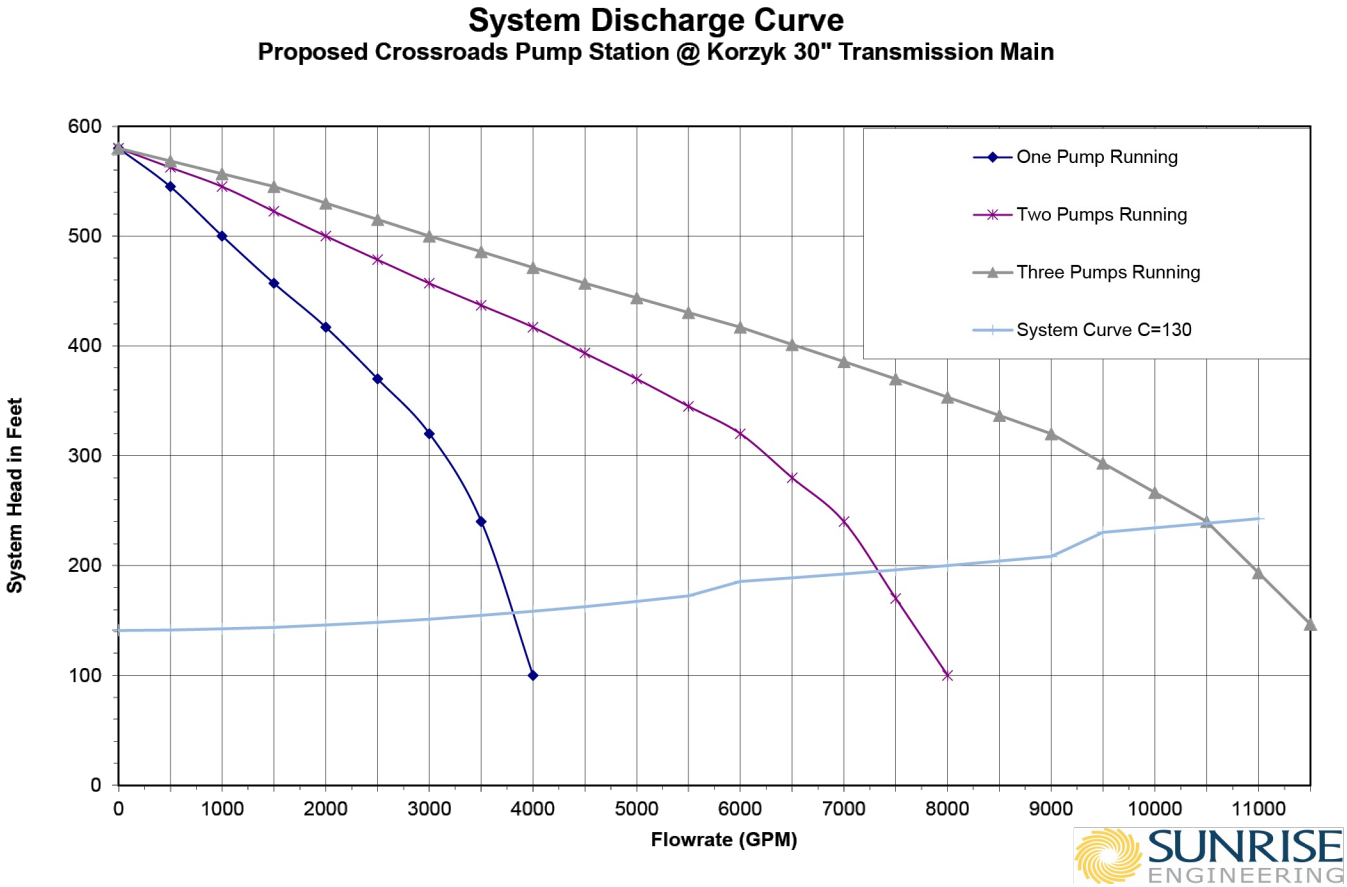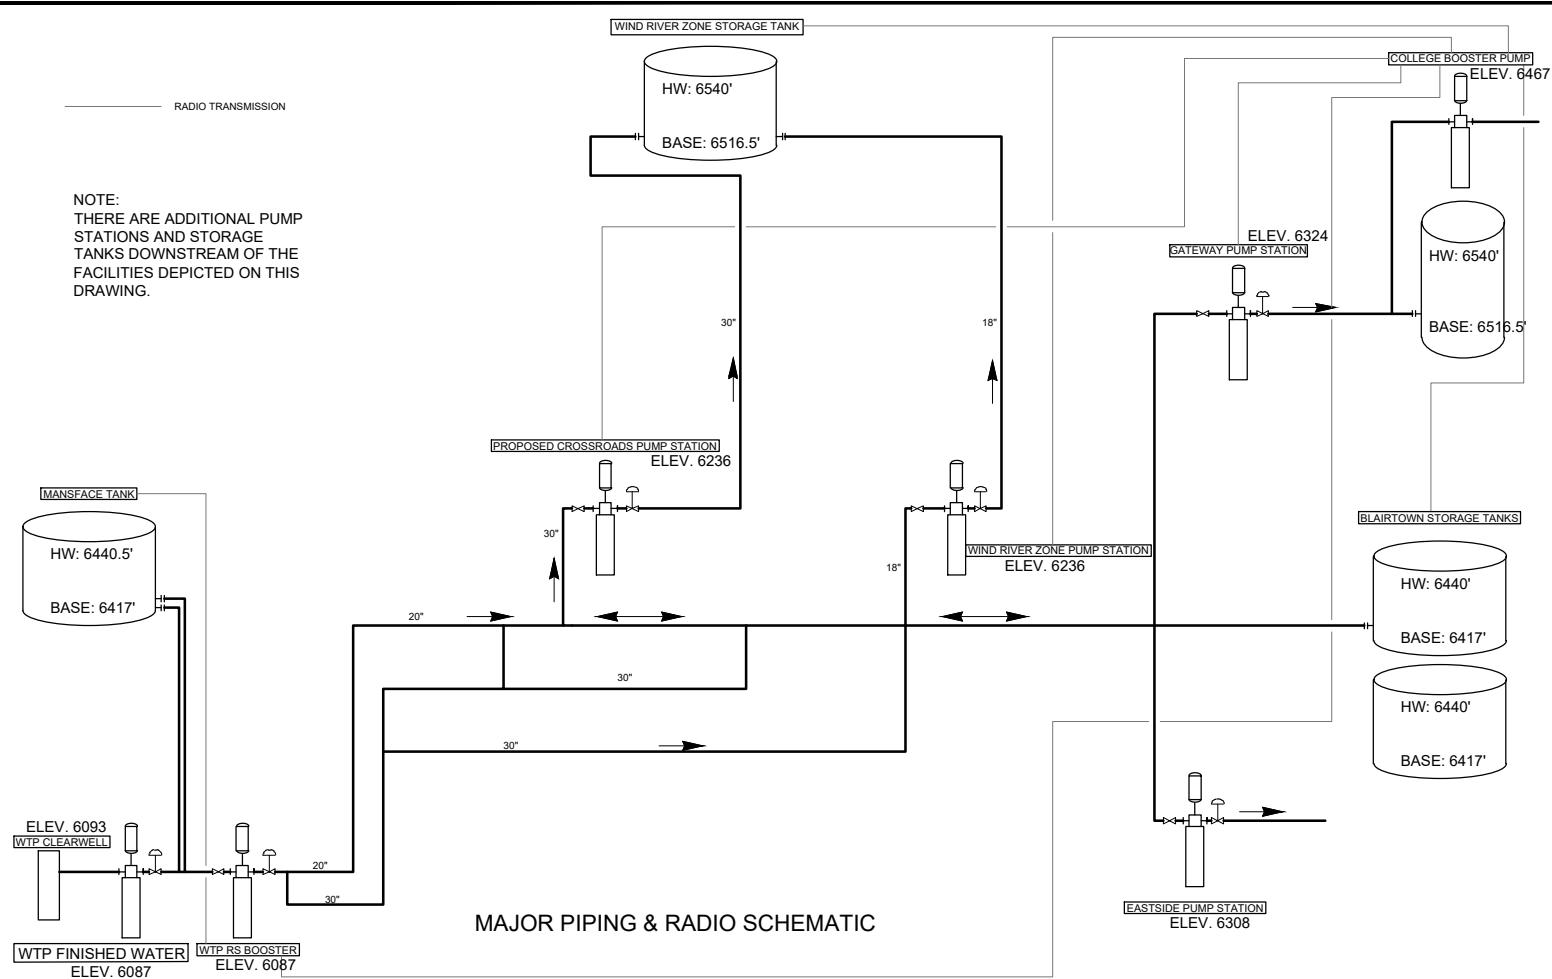

Crossroads Pump Station Level III - Detail Design

Design Criteria*

2020 Conditions

Average Day Station Flow	5,376,000	Million Gallons
Peak Day Station Flow	7,527,000	Million Gallons
Peak Day Flow Rate	5,230	Gallons Per Minute

2060 Conditions




Average Day Station Flow	10,433,000	Million Gallons
Peak Day Station Flow	14,606,000	Million Gallons
Peak Flow Rate	10,150	Gallons Per Minute

Pump Station Floor Elevation	6,236	Number of Pumps	4
Pump Volute Elevation	6,231	Stages Per Pump	5
Discharge Elevation (Wind River Tank High Water)	6,540 Max 6,517 Min	Max HP Per Pump	270

Static Discharge Pressure At Pump	309 Feet Max	285.5 Feet Min	Pump Capacity (5 Stages Per Pump)	
Static Suction Pressure at Pump	210 Feet Max	188 Feet Min	One Pump Running	3,700gpm
Discharge Pipe Length	13,450 Feet		Two Pumps Running	7,300gpm
Discharge Pipe Diameter	30 Inches		Three Pumps Running	10,500gpm


Net Dynamic Discharge Head (ft)	Dynamic Suction Head (ft)	NPSH Required (ft)
156	162	40
195	138	32
239	113	25

REV. NO.	COMMENT	DATE
SUNRISE ENGINEERING 770 S WASHINGTON ST. AFTON, WYOMING 83110 TEL 307.885.8500 • FAX 307.885.8501 www.sunrise-eng.com		
GR-RS-SC JPWB		
CROSSROADS PUMP STATION		
DESIGN CRITERIA & PUMP CURVE		
SEI NO. 07265	DESIGNED FDK	DRAWN BJ
CHECKED JUL	SHEET NO. 4 of 99	G4

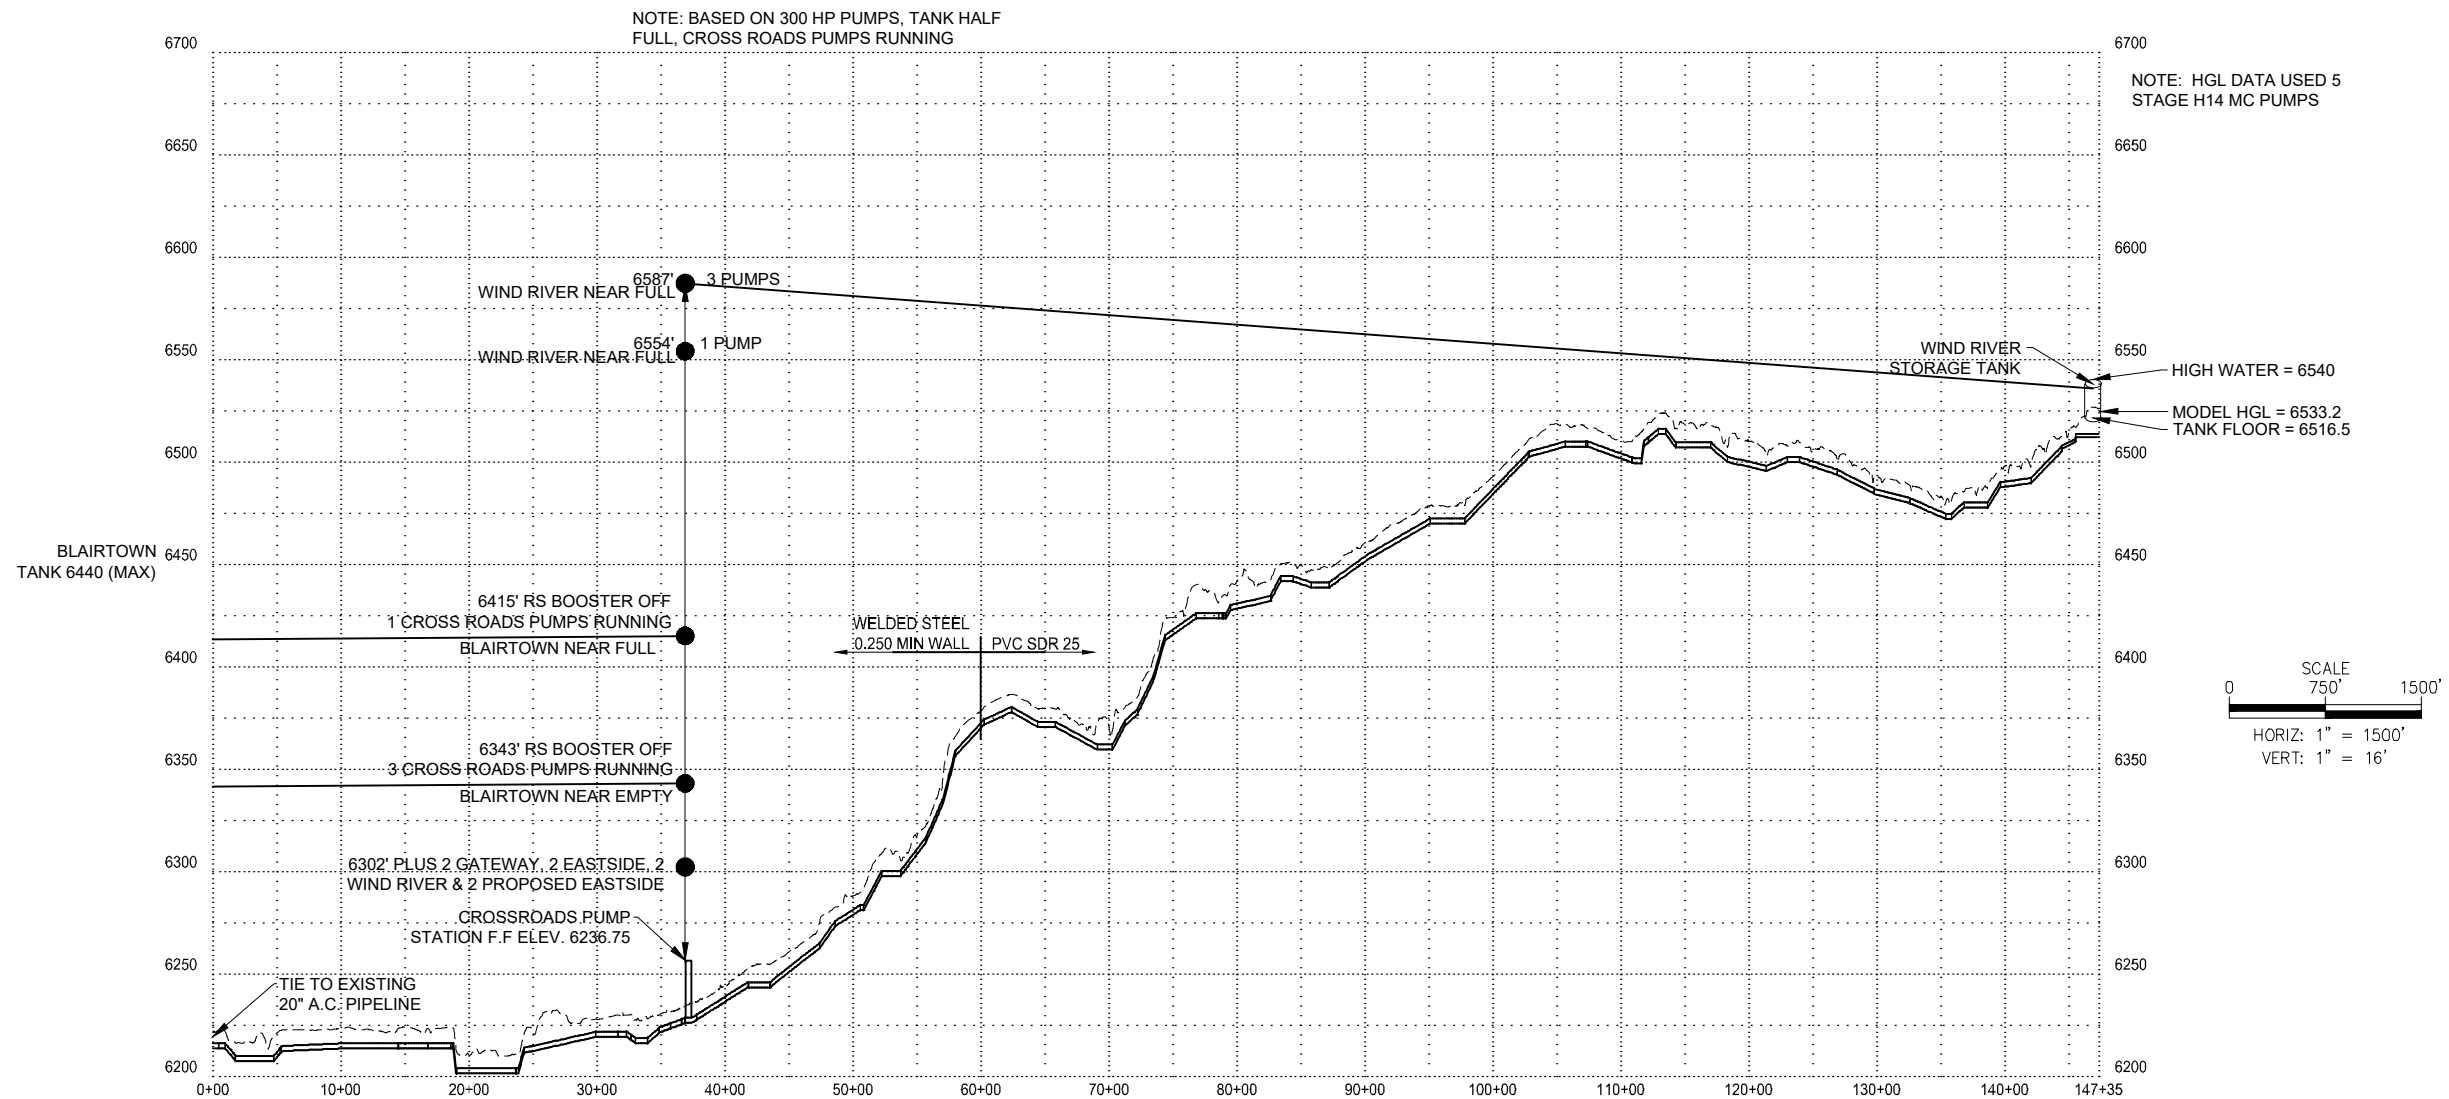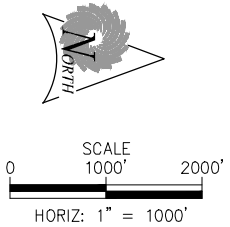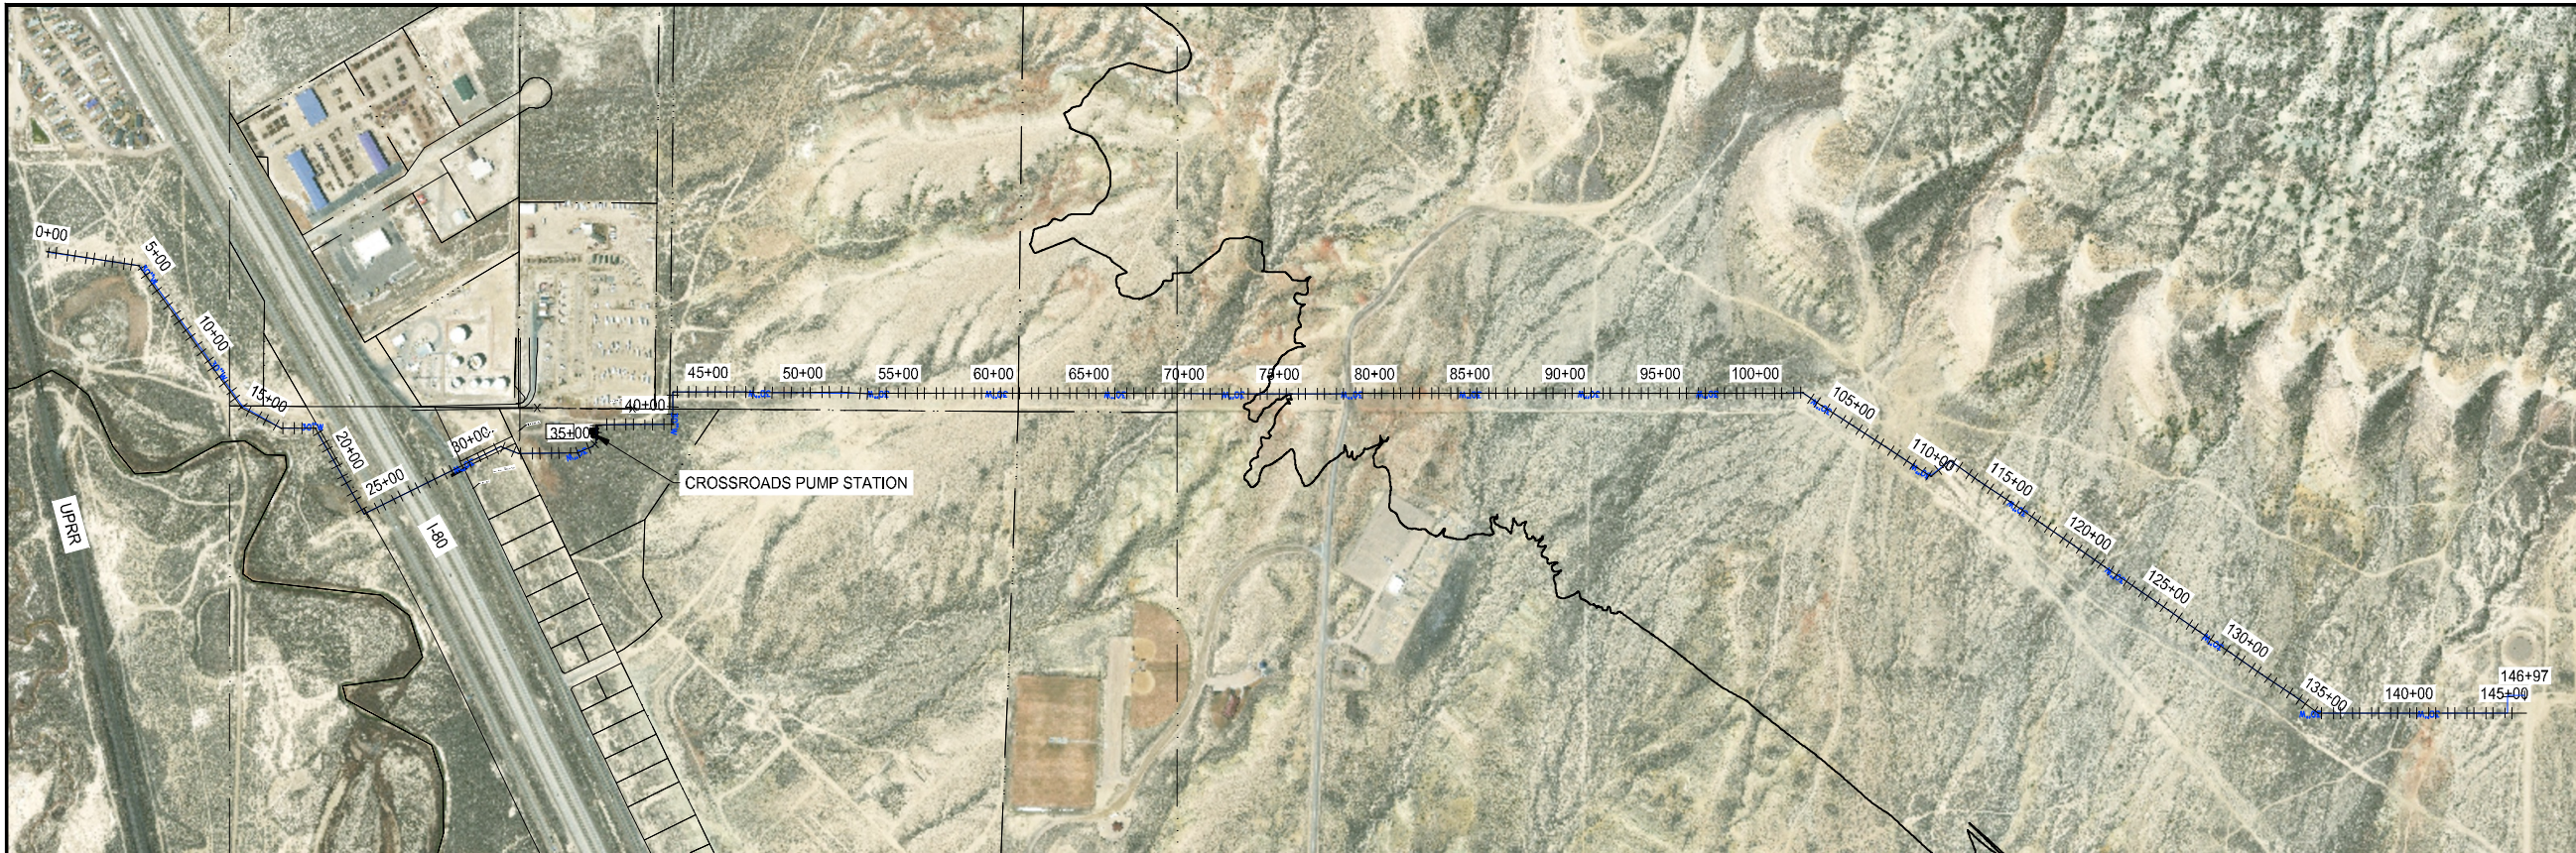

REV. NO.	COMMENT	DATE
SUNRISE ENGINEERING 770 S WASHINGTON ST. AFTON, WYOMING 83110 TEL 307.885.8500 • FAX 307.885.8501 www.sunrise-eng.com		
GR-RS-SC JPWB		
CROSSROADS PUMP STATION		
HYDRAULIC GRADE PROFILE		
SEI NO. 07265	DESIGNED FDK	DRAWN BJ
CHECKED JUL	SHEET NO. 5 of 99	HP

P:\WDOC GR-RS-SC JPWB Cross Roads Pump Station Level III (S07265).dwg C:\Civil\Waterline\Plan & Profile\Complete Profile.dwg Feb 13, 2026 9:35am Jenkins

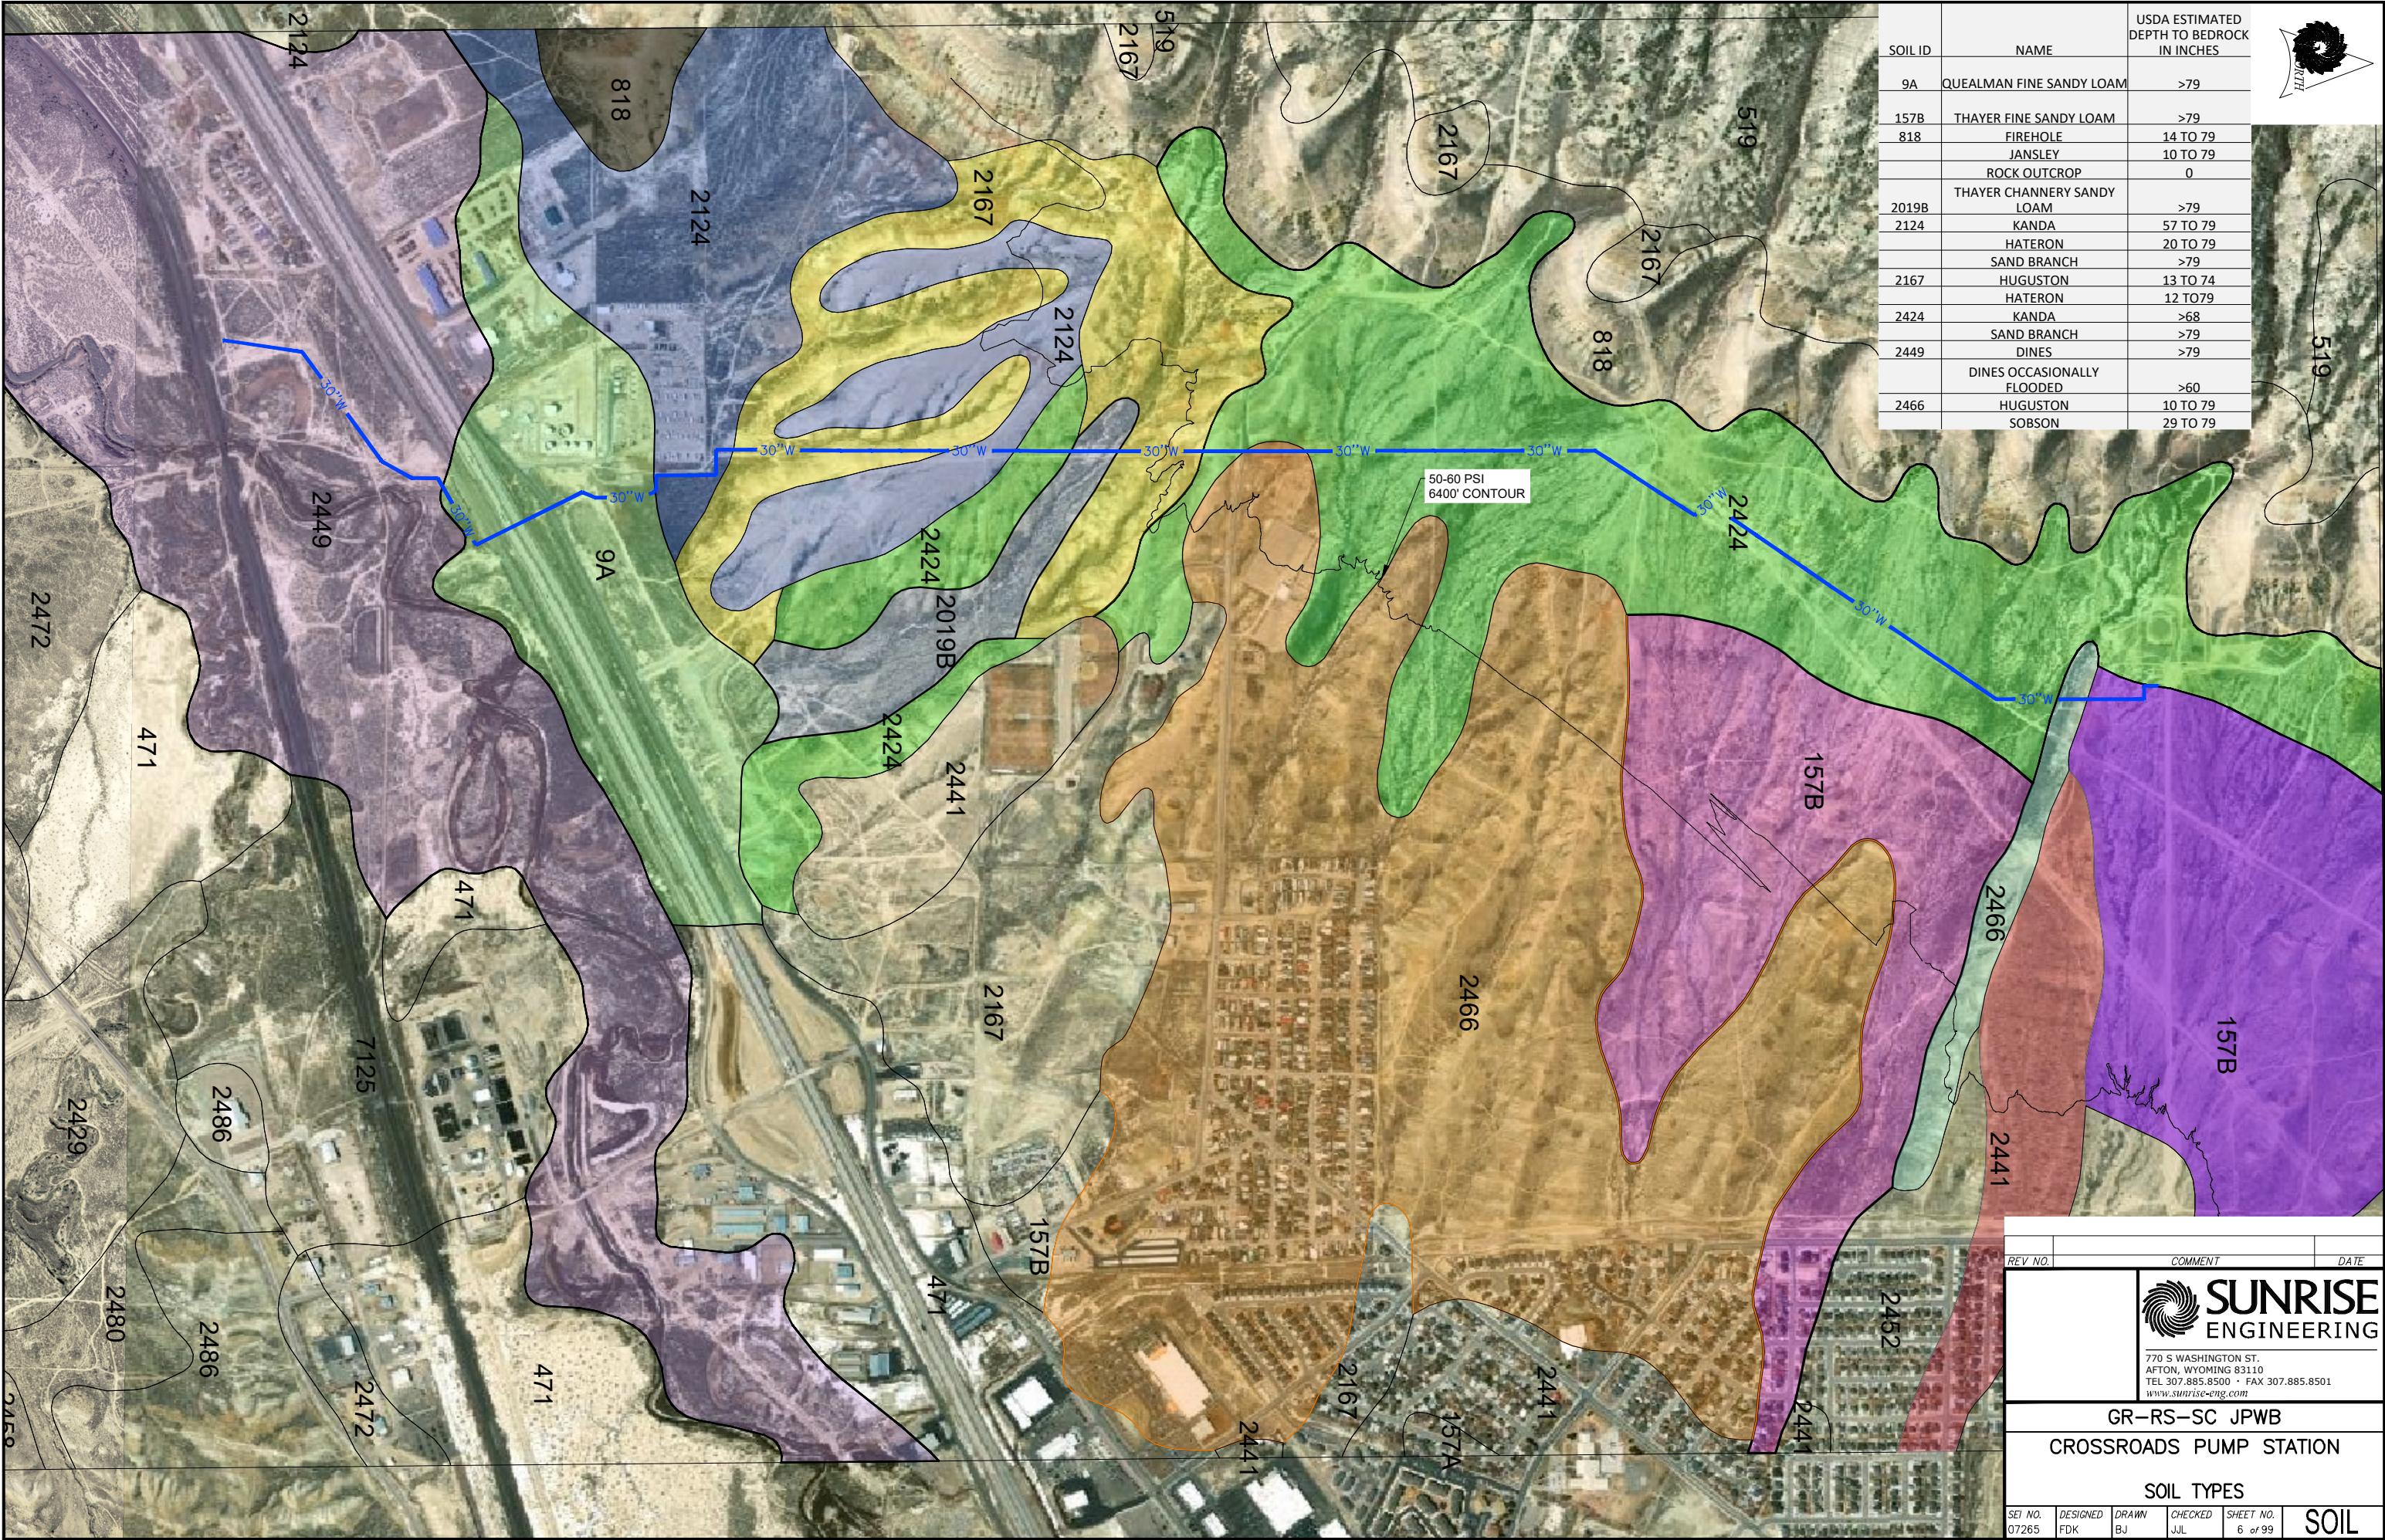

SOIL ID	NAME	USDA ESTIMATED DEPTH TO BEDROCK IN INCHES
9A	QUEALMAN FINE SANDY LOAM	>79
157B	THAYER FINE SANDY LOAM	>79
818	FIREHOLE JANSLEY	14 TO 79
	ROCK OUTCROP	10 TO 79
		0
2019B	THAYER CHANNERY SANDY LOAM	>79
2124	KANDA	57 TO 79
	HATERON	20 TO 79
	SAND BRANCH	>79
2167	HUGUSTON	13 TO 74
	HATERON	12 TO 79
2424	KANDA	>68
	SAND BRANCH	>79
2449	DINES	>79
	DINES OCCASIONALLY FLOODED	>60
2466	HUGUSTON	10 TO 79
	SOBSON	29 TO 79

REV NO.

COMMENT

DATE

**SUNRISE**
ENGINEERING

770 S WASHINGTON ST.
AFTON, WYOMING 83110
TEL 307.885.8500 • FAX 307.885.8501
www.sunrise-eng.com

GR-RS-SC JPWB

CROSSROADS PUMP STATION

SOIL TYPES

SEI NO.
07265

DESIGNED
FDK



DRAWN
BJ

CHECKED
JLL

SHEET NO.
6 of 99

SOIL

sunrise-eng.com 13 Feb 2026 9:33am \\server\projects\2026\07265\GR-RS-SC JPWB.dwg

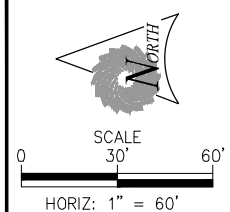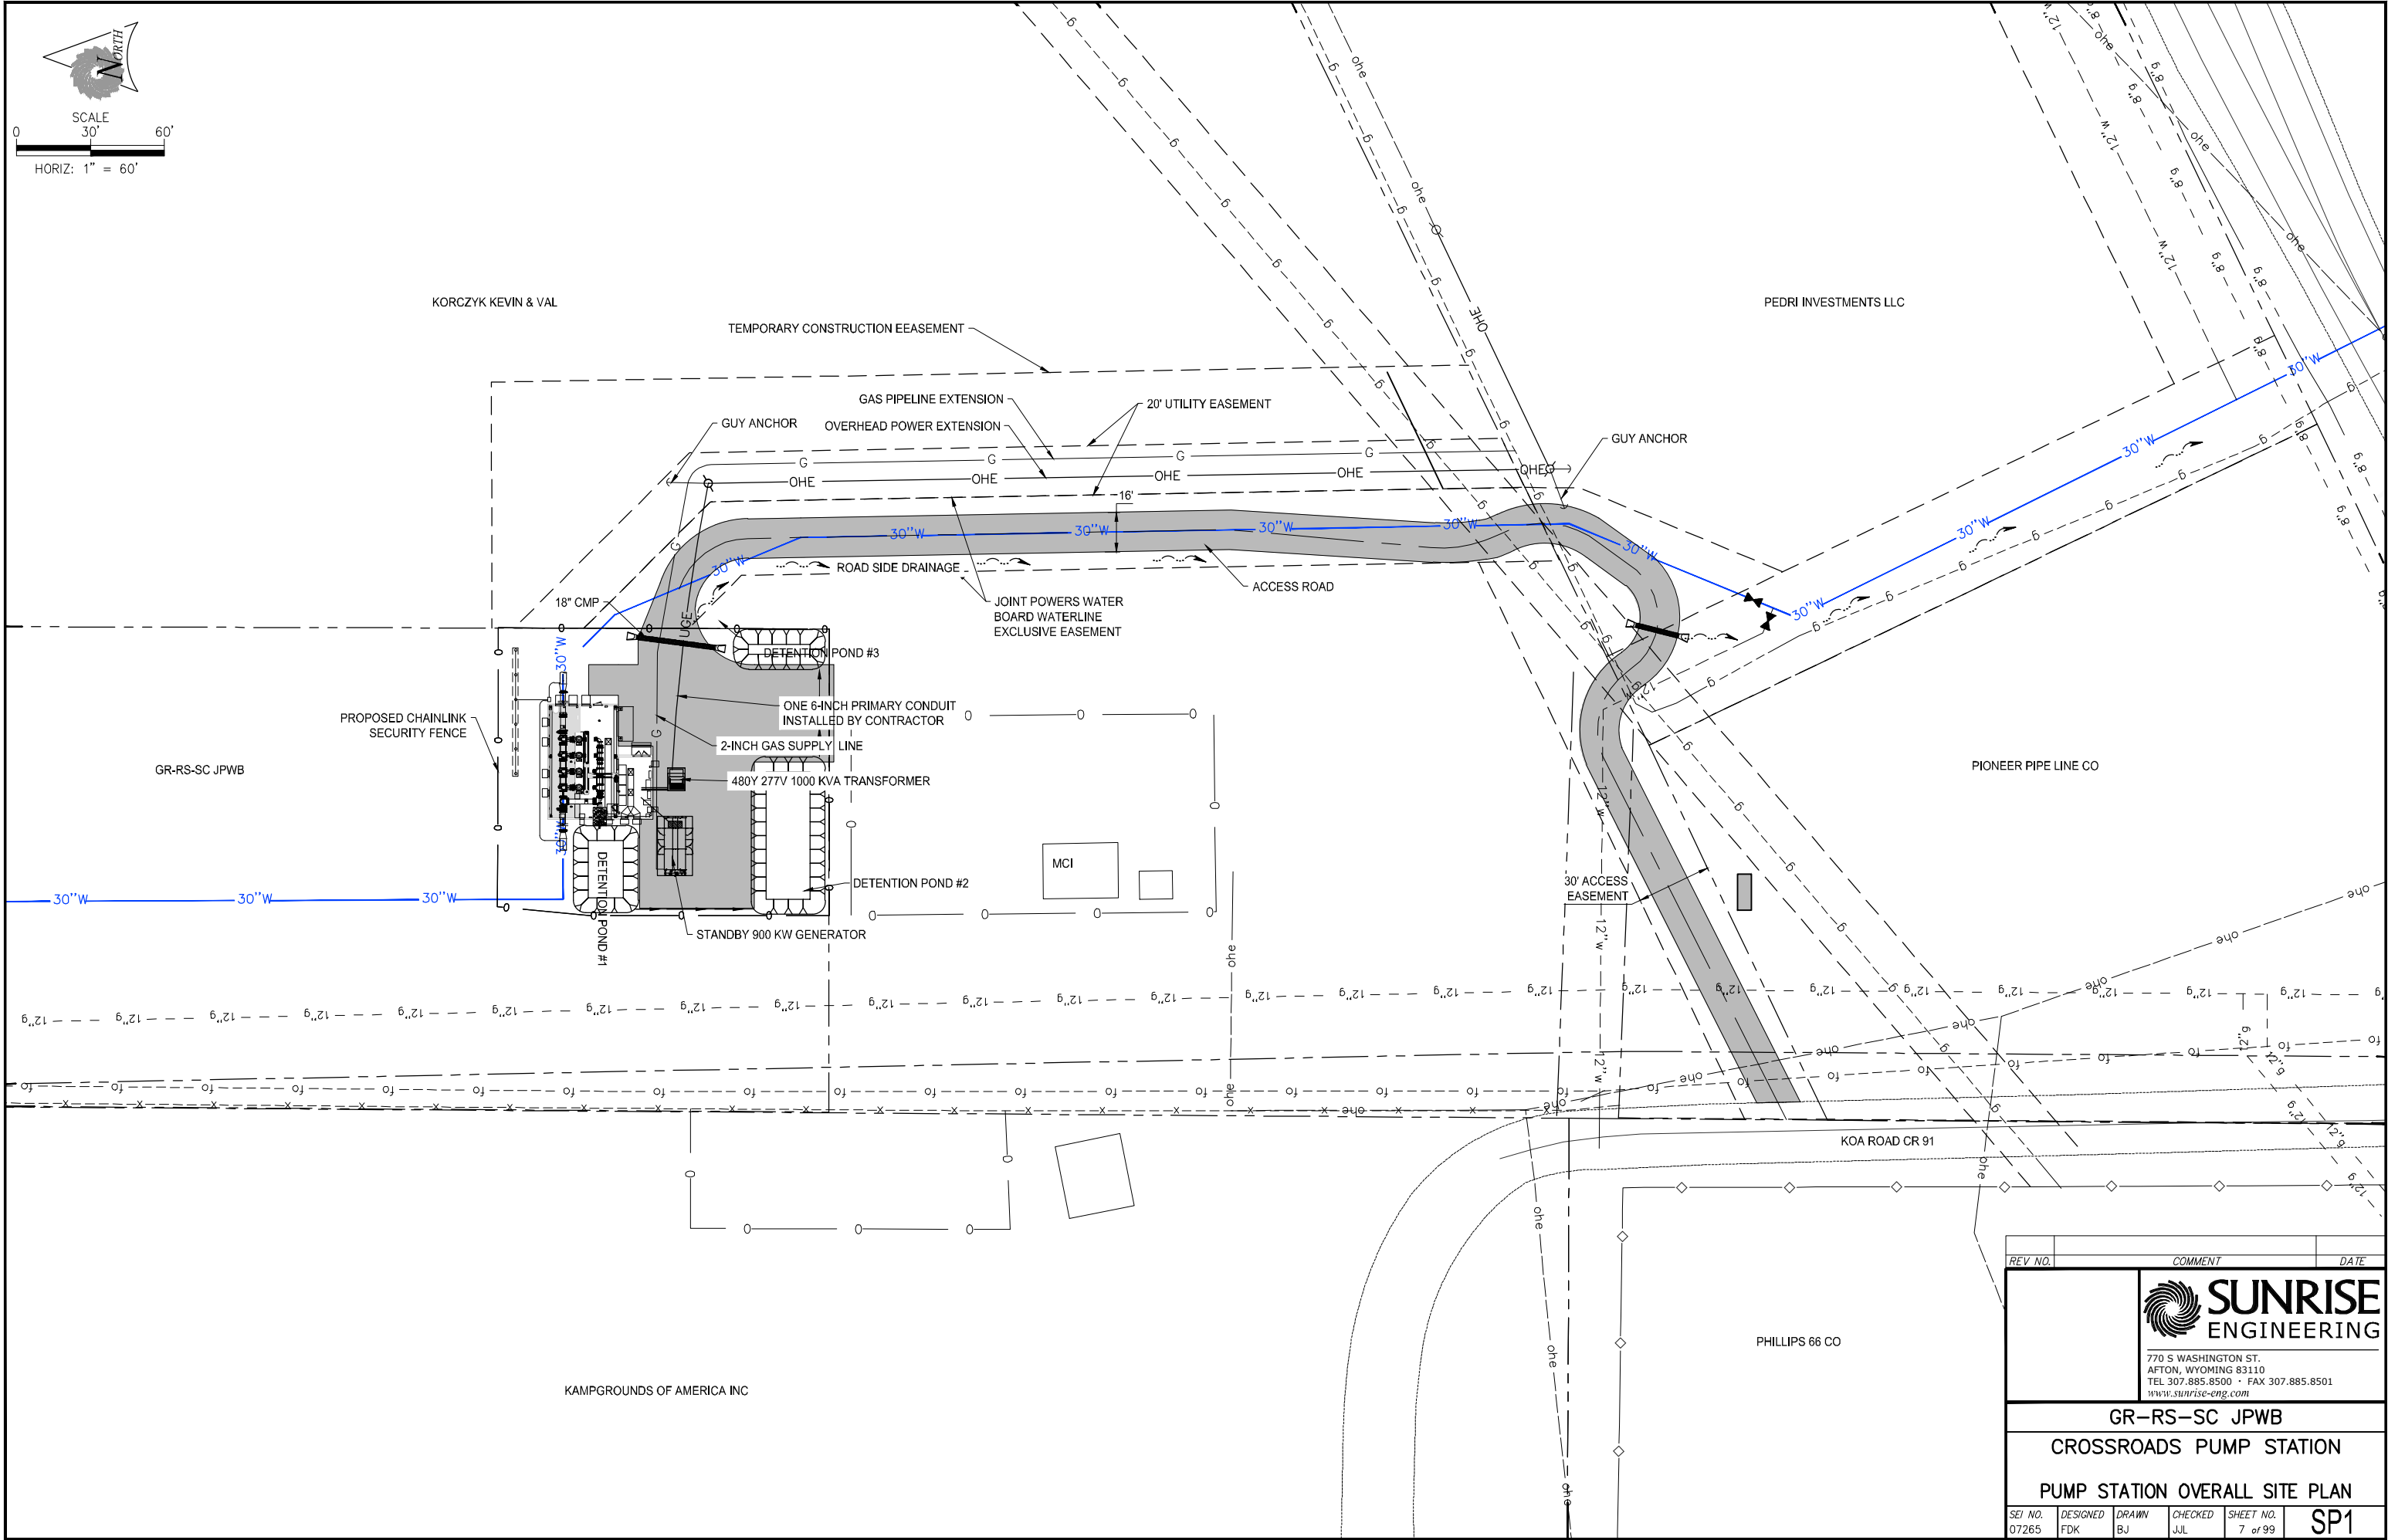

REV. NO.	COMMENT	DATE


SUNRISE
ENGINEERING

770 S WASHINGTON ST.
AFTON, WYOMING 83110
TEL 307.885.8500 • FAX 307.885.8501
www.sunrise-eng.com

GR-RS-SC JPWB
CROSSROADS PUMP STATION
PUMP STATION OVERALL SITE PLAN


REV. NO.	DESIGNED	DRAWN	CHECKED	SHEET NO.	
07265	FDK	BJ	JUL	7 of 99	SP1

P:\WDOC GR-RS-SC JPWB Cross Roads Pump Station Level III (307265)\Dwg CSD\Civil\Site Plan\Pump Station Site Plan.dwg Feb 13, 2026 9:33am bjenkins

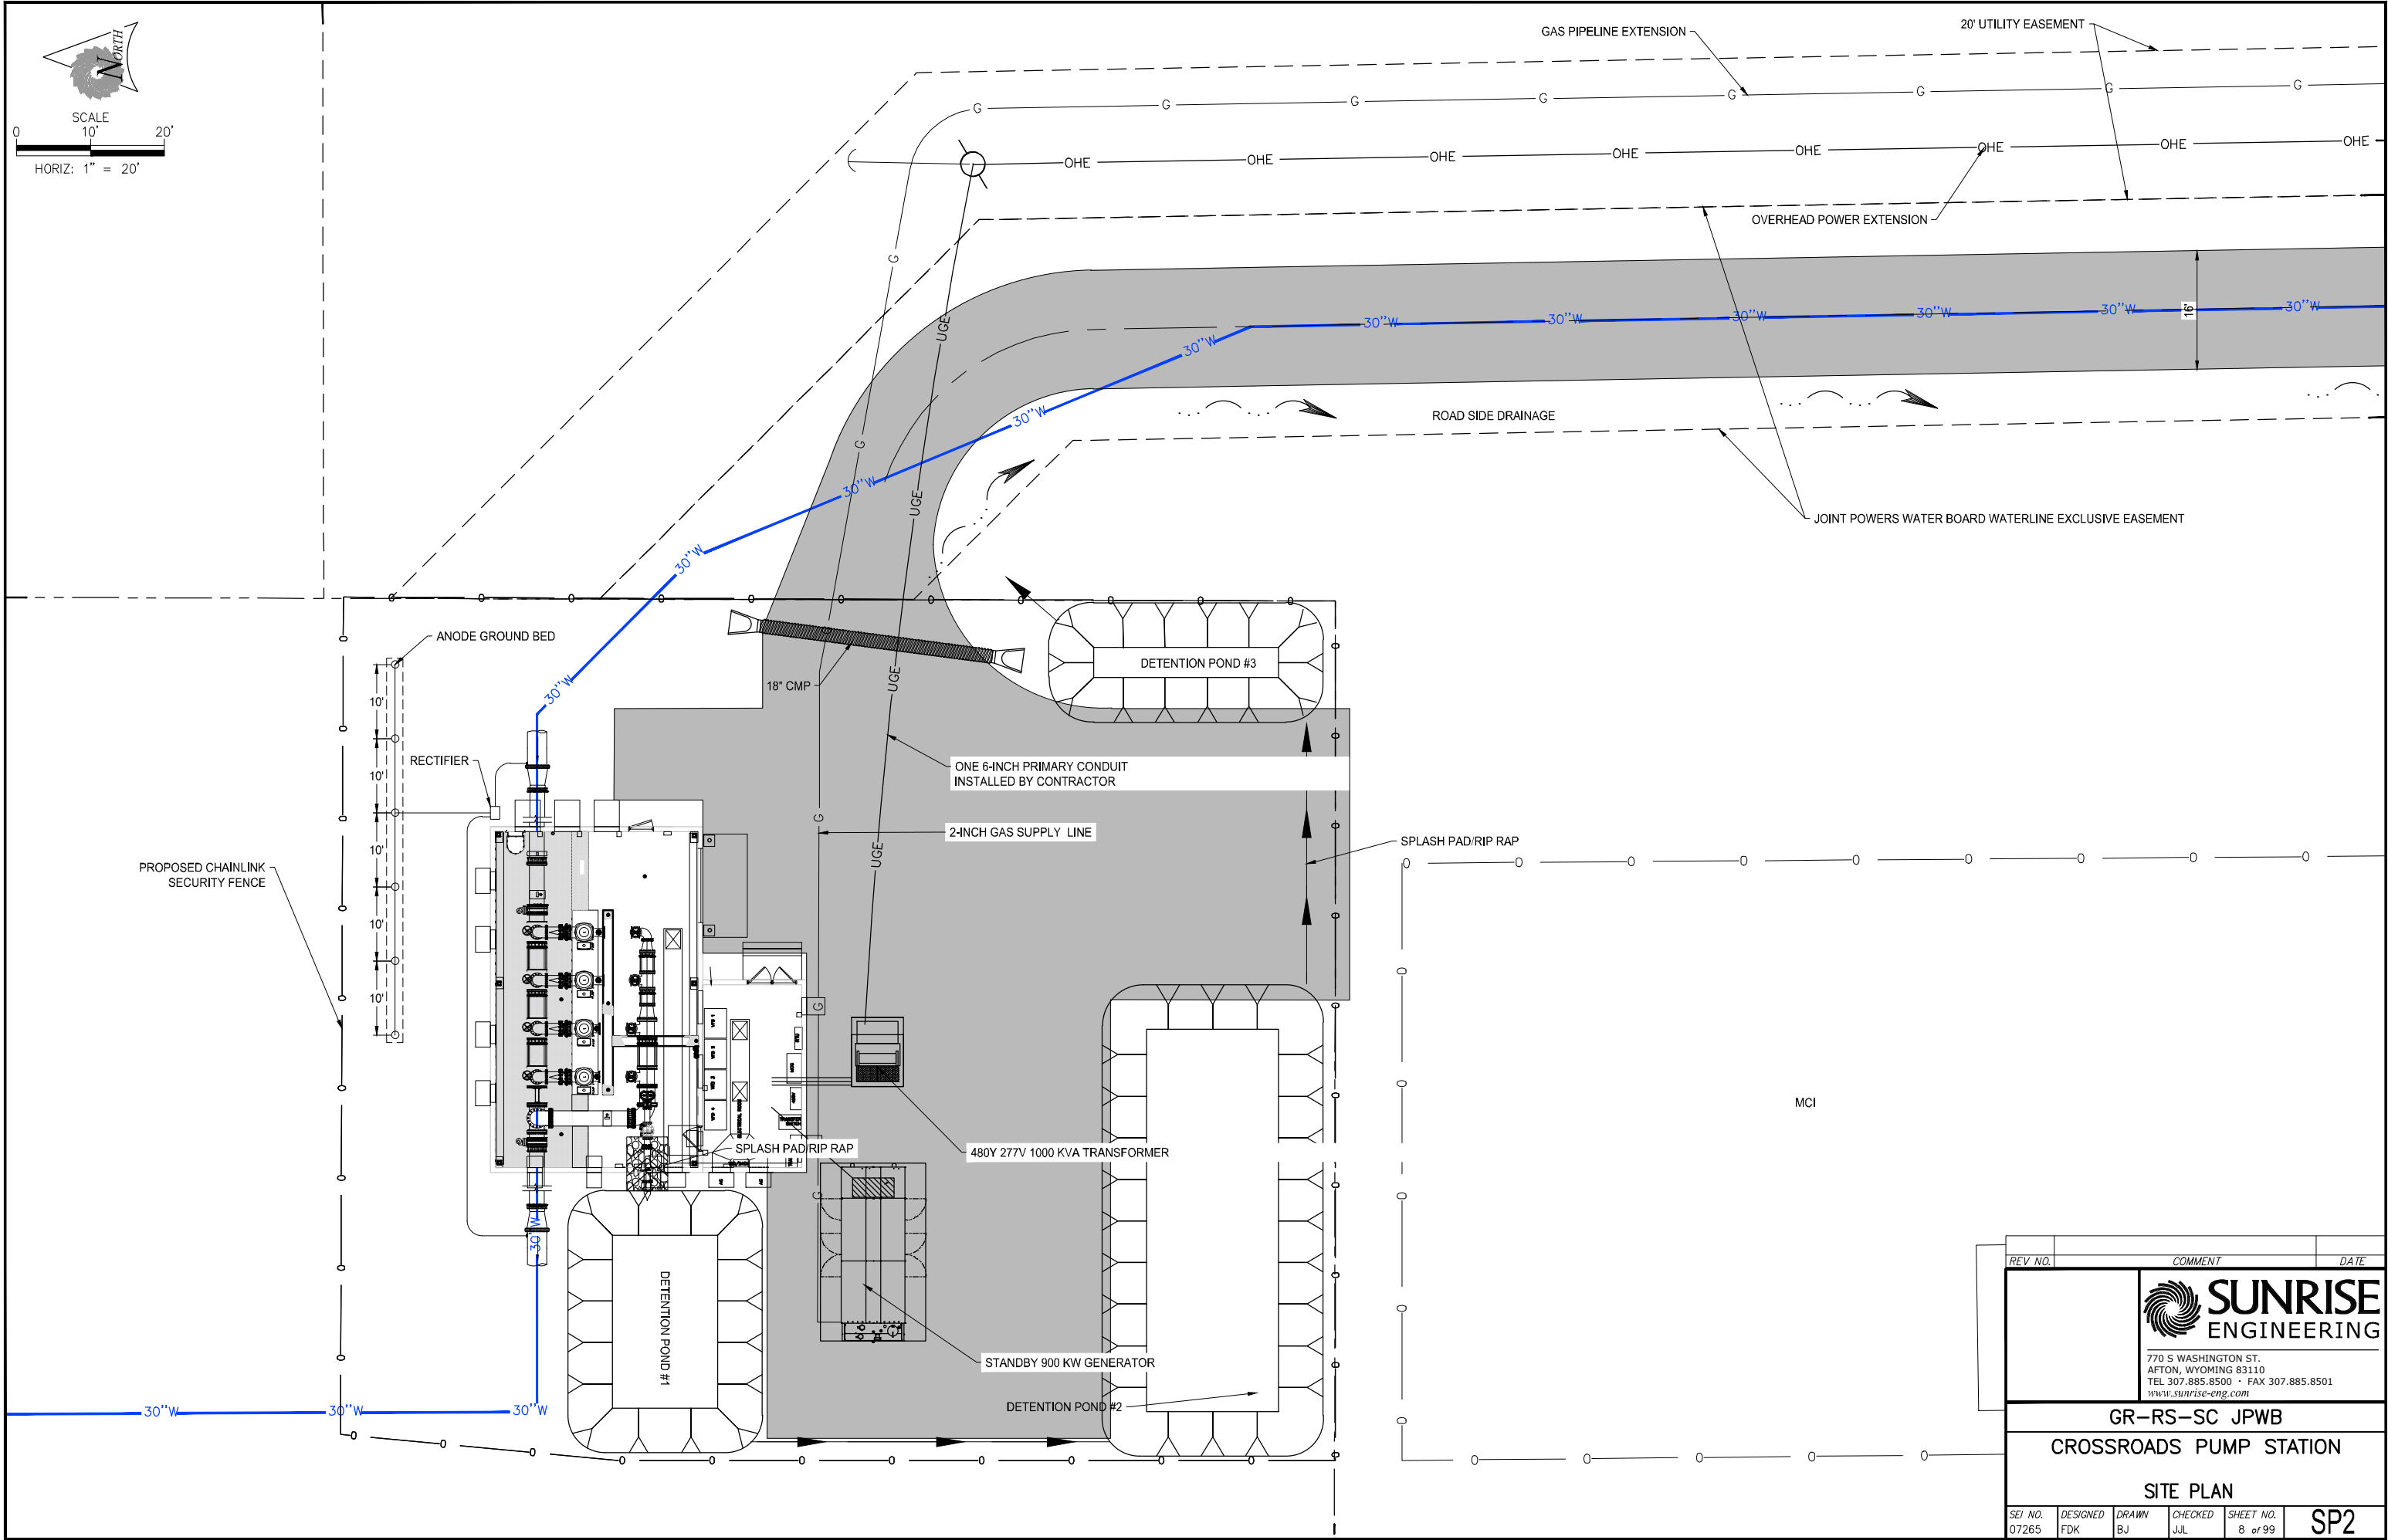


REV. NO.	COMMENT	DATE
SUNRISE ENGINEERING 770 S WASHINGTON ST. AFTON, WYOMING 83110 TEL 307.885.8500 • FAX 307.885.8501 www.sunrise-eng.com		
GR-RS-SC JPWB		
CROSSROADS PUMP STATION		
SITE PLAN		
SEI NO. 07265	DESIGNED FDK	DRAWN BJ
CHECKED JUL	SHEET NO. 8 of 99	SP2

P:\WDOC GR-RS-SC JPWB Cross Roads Pump Station Level III (507265)\Dwg C3D\Civil\Site Plan\Pump Station Site Plan.dwg Feb 13, 2026 9:33am bjenkins

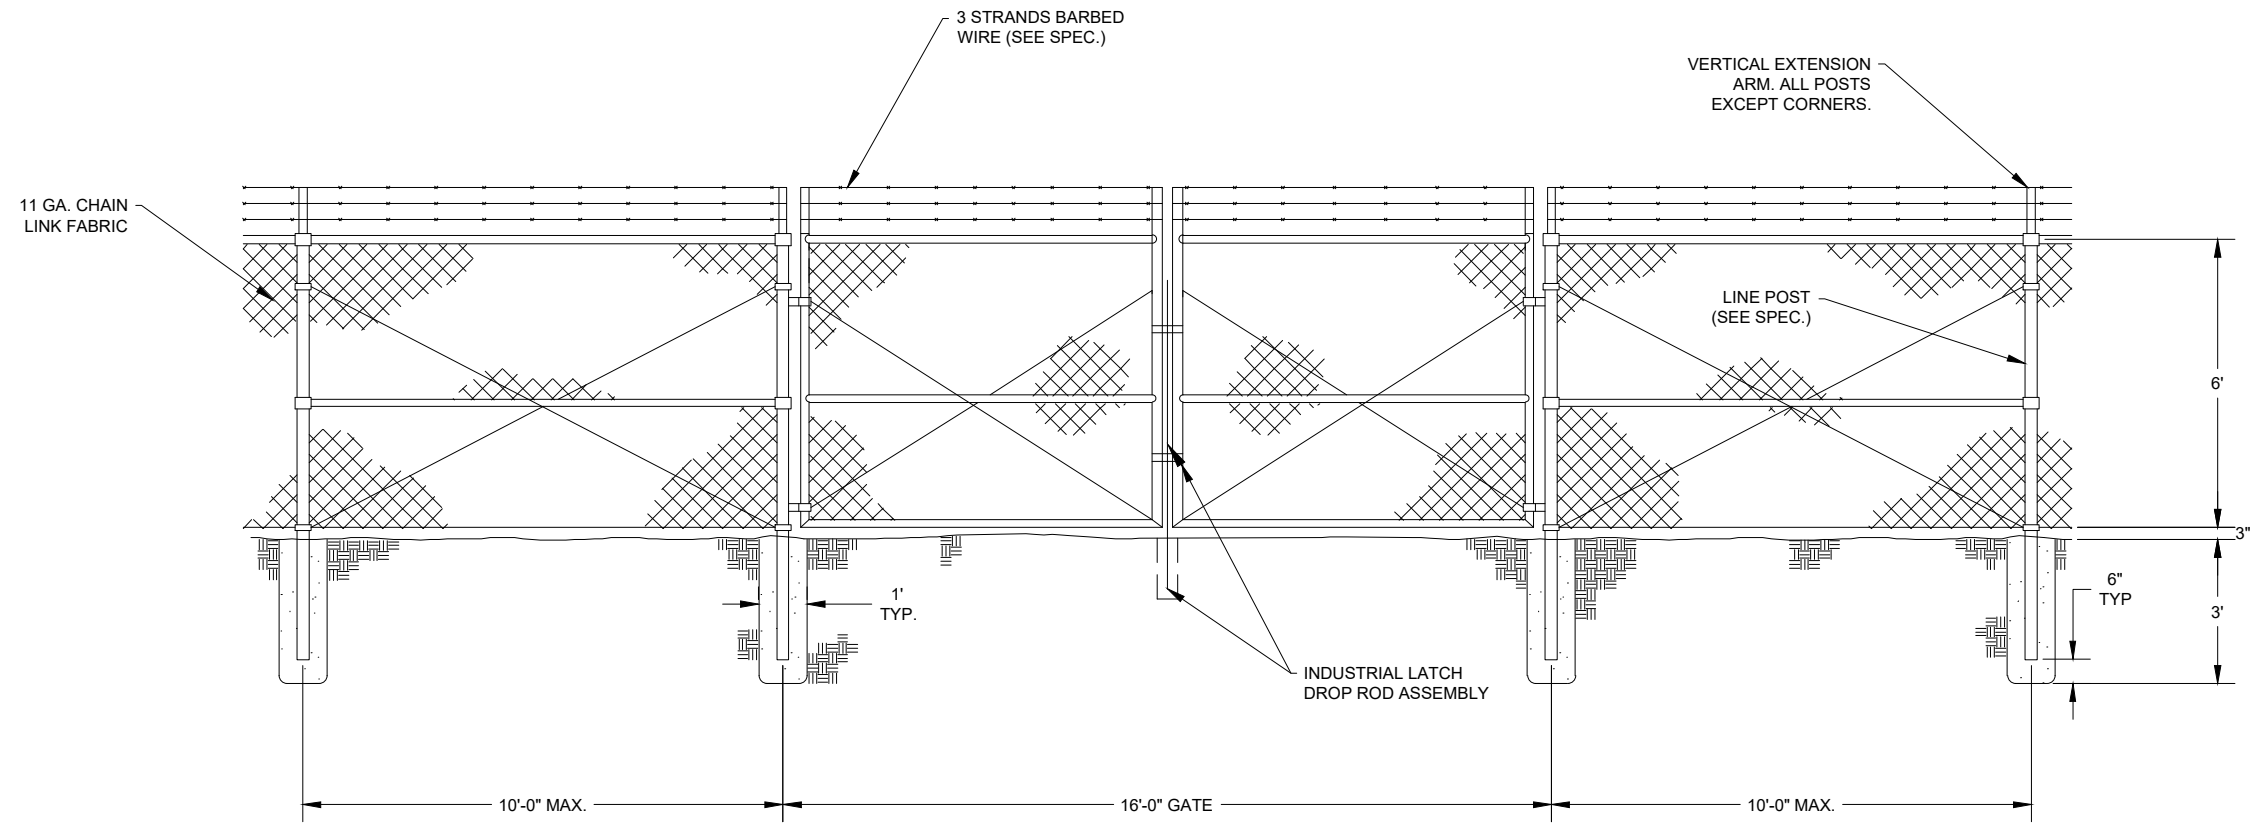


NOTE:
PROVIDE GATE KEEPER
WITH EACH GATE.

A DOUBLE GATE (CHAINLINK FENCE)
~ TYPICAL DETAIL


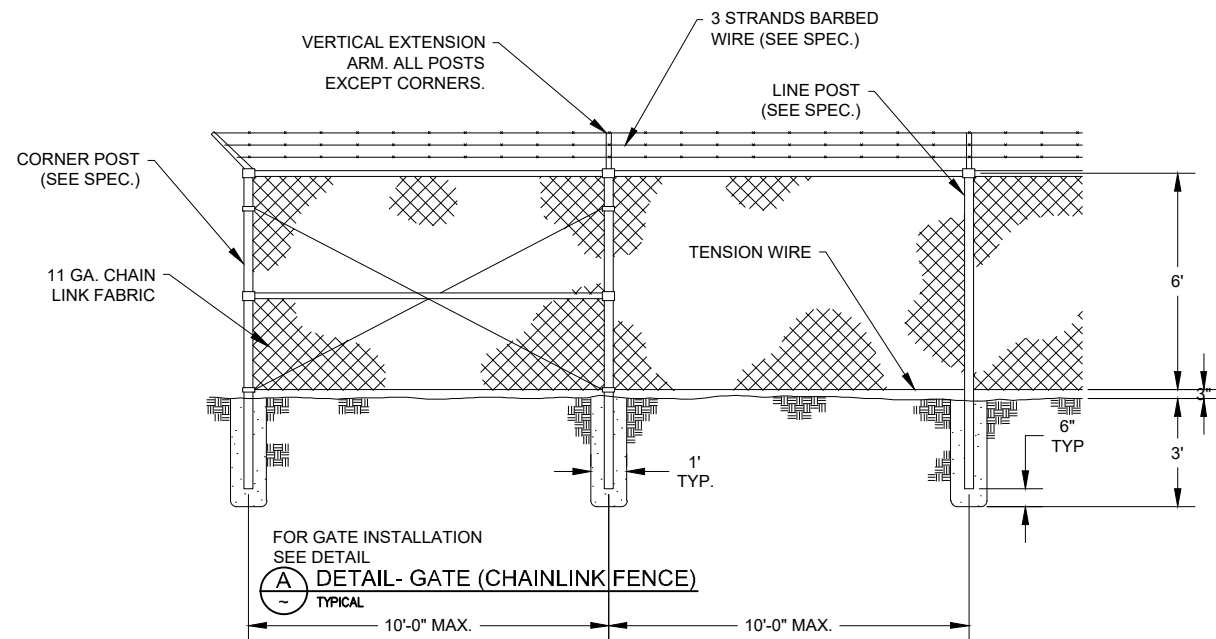


B CHAIN LINK FENCE CORNER POST BRACING
~ TYPICAL DETAIL

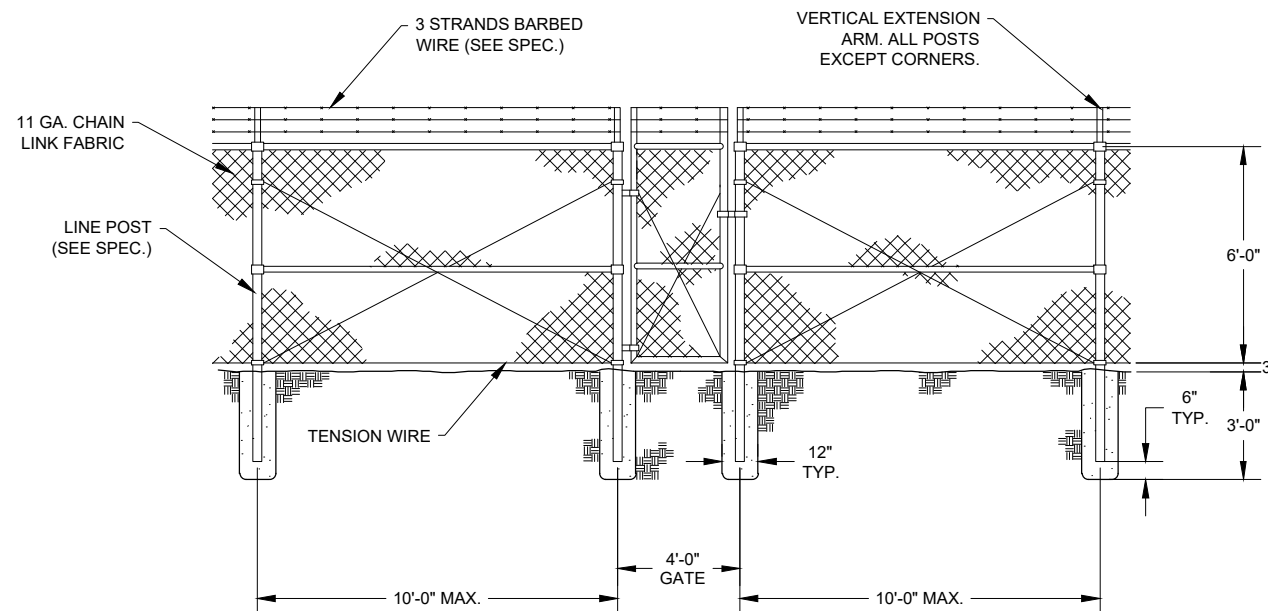


C WALK-IN GATE (CHAINLINK FENCE)
~ TYPICAL DETAIL

REV. NO.	COMMENT	DATE
 SUNRISE ENGINEERING 770 S WASHINGTON ST. AFTON, WYOMING 83110 TEL 307.885.8500 • FAX 307.885.8501 www.sunrise-eng.com		
GR-RS-SC JPWB		
CROSSROADS PUMP STATION		
FENCE DETAILS		
SEI NO. 07265	DESIGNED FDK	DRAWN BJ
CHECKED JUL	SHEET NO. 10 of 99	F1

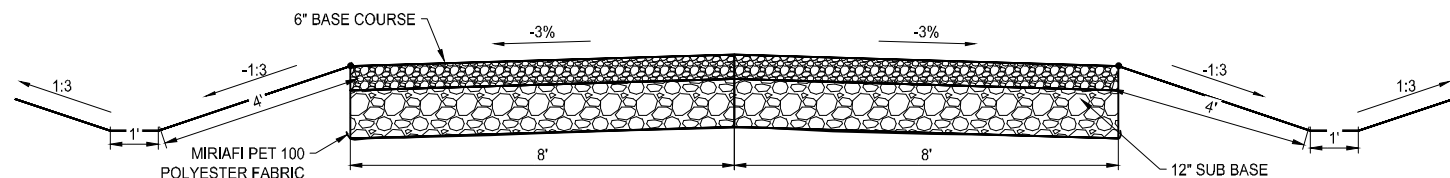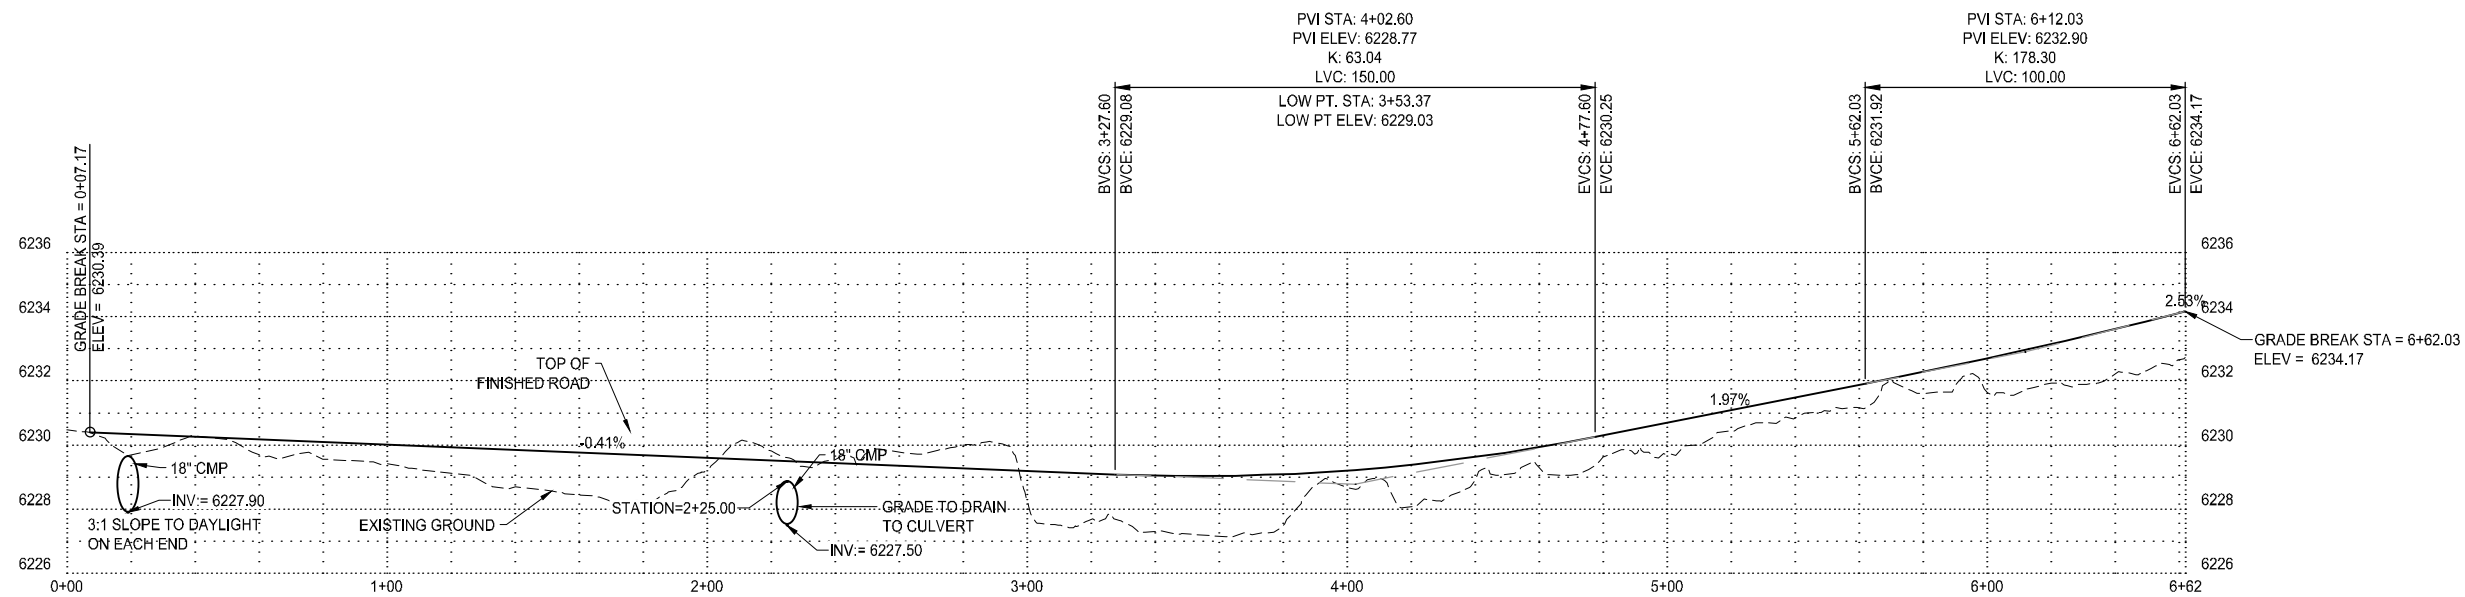


(B) ACCESS ROAD
NOT TO SCALE SECTION VIEW

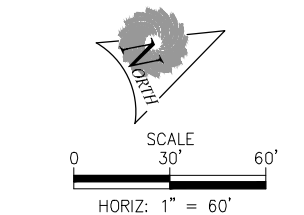

811 Know what's below.
Call before you dig.
1-800-849-2476

REV. NO.	COMMENT	DATE
SUNRISE ENGINEERING 770 S WASHINGTON ST. AFTON, WYOMING 83110 TEL 307.885.8500 • FAX 307.885.8501 www.sunrise-eng.com		
GR-RS-SC JPWB		
CROSSROADS PUMP STATION ACCESS ROAD PLAN AND PROFILE		
SEI NO. 07265	DESIGNED FDK	DRAWN BJ
CHECKED JUL	SHEET NO. 11 of 99	RP









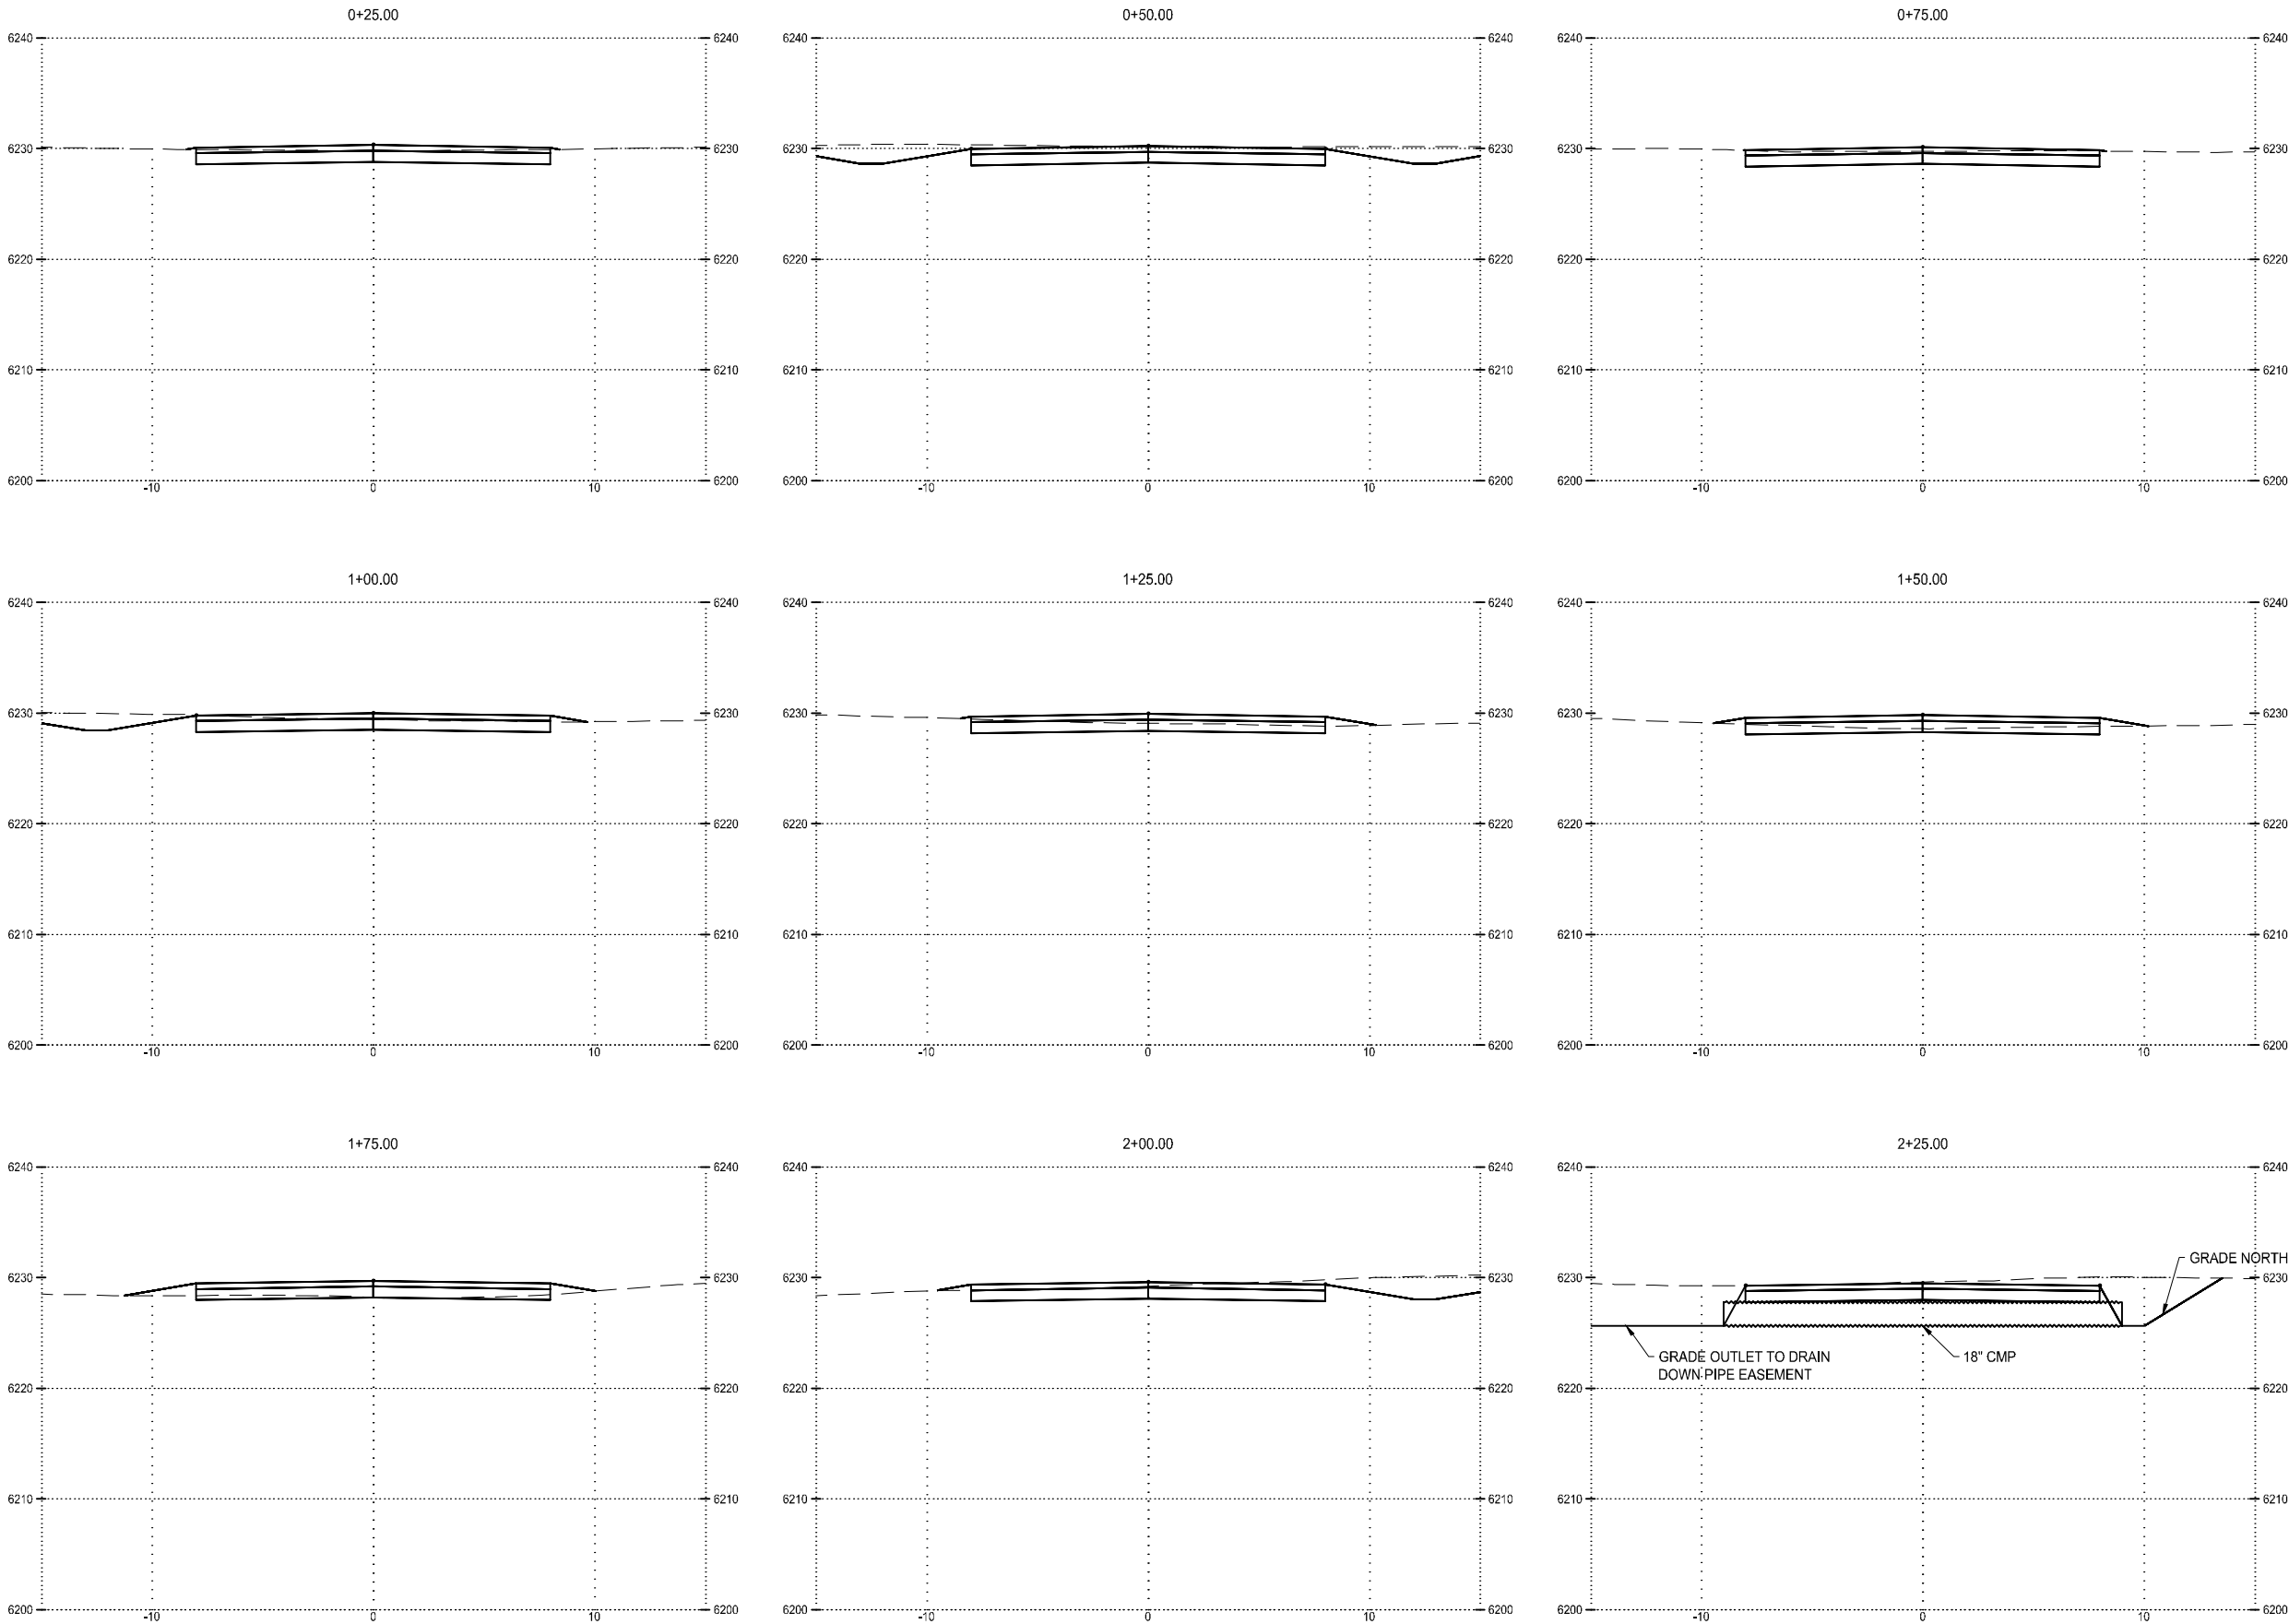


REV. NO.	COMMENT	DATE









**SUNRISE**
ENGINEERING
770 S WASHINGTON ST.
AFTON, WYOMING 83110
TEL 307.885.8500 • FAX 307.885.8501
www.sunrise-eng.com

GR-RS-SC JPWB
CROSSROADS PUMP STATION
ACCESS ROAD
SECTIONS



SEI NO. 07265	DESIGNED FDK	DRAWN BJ	CHECKED JUL	SHEET NO. 12 of 99	RS1
------------------	-----------------	-------------	----------------	-----------------------	------------

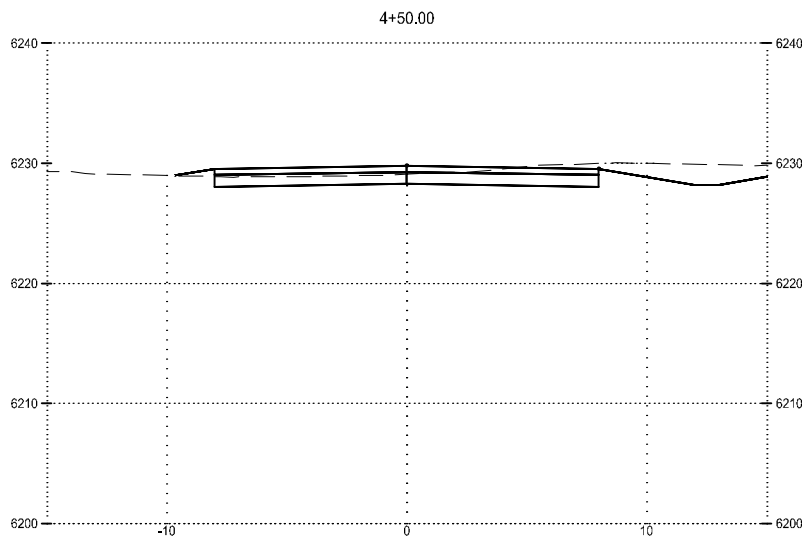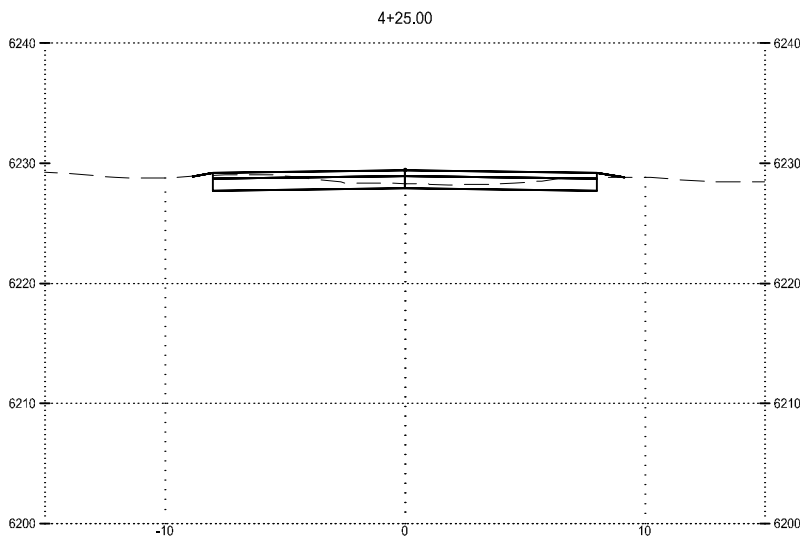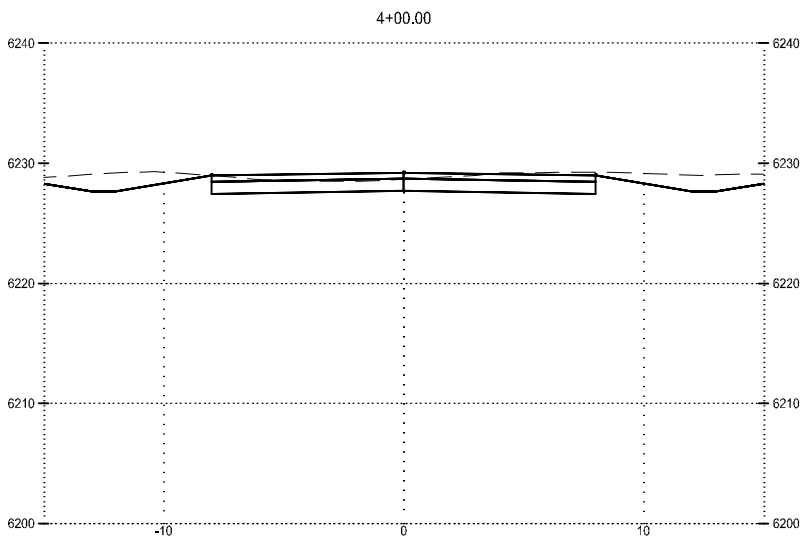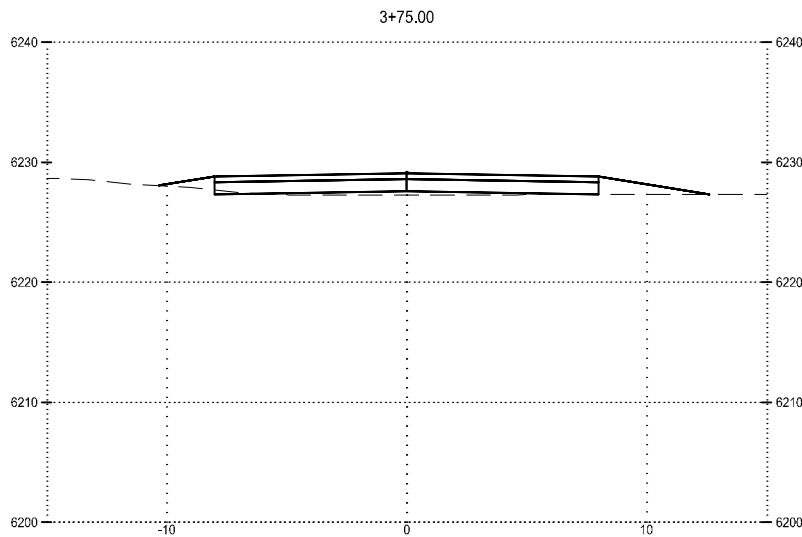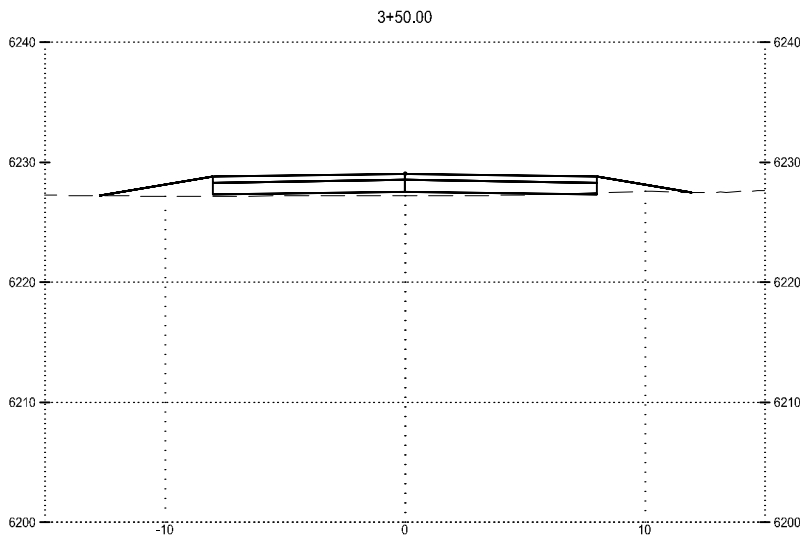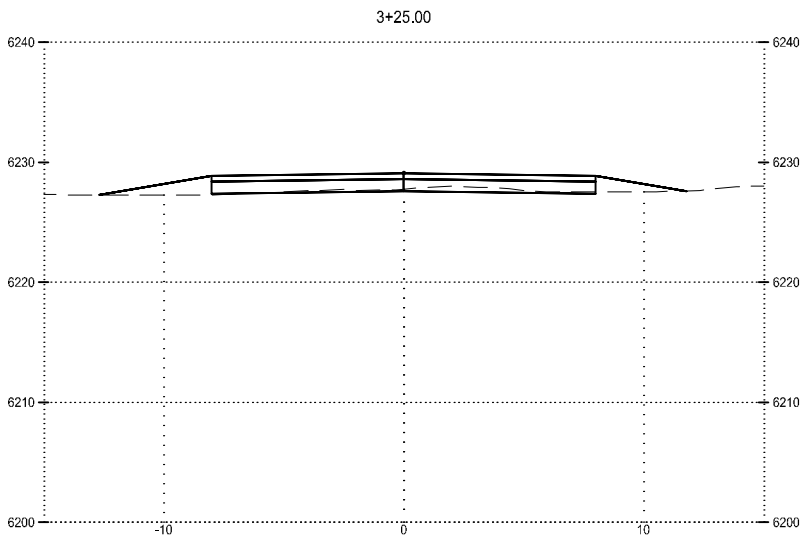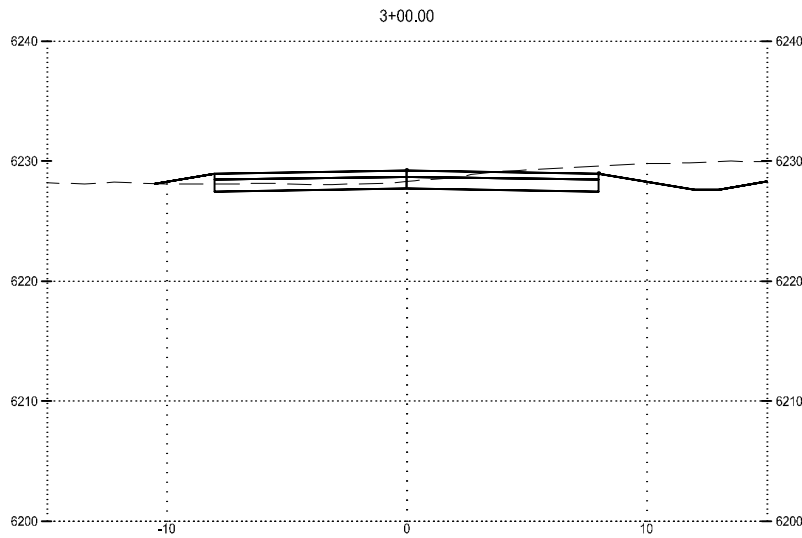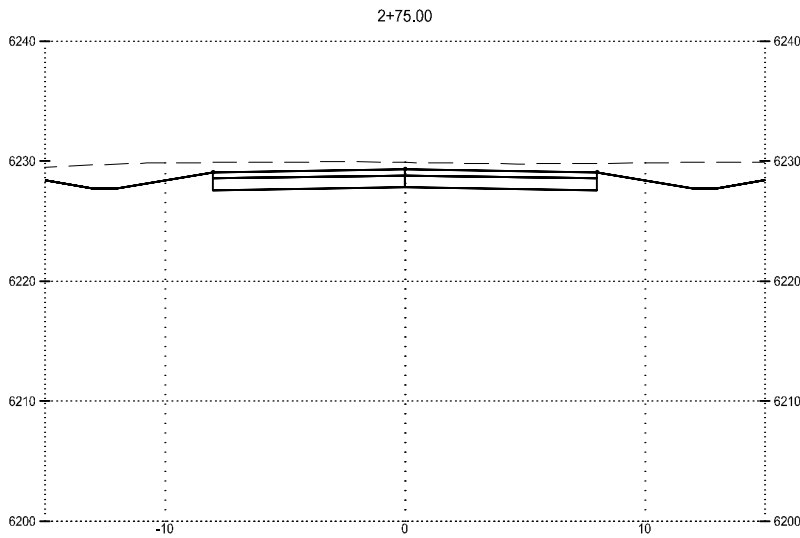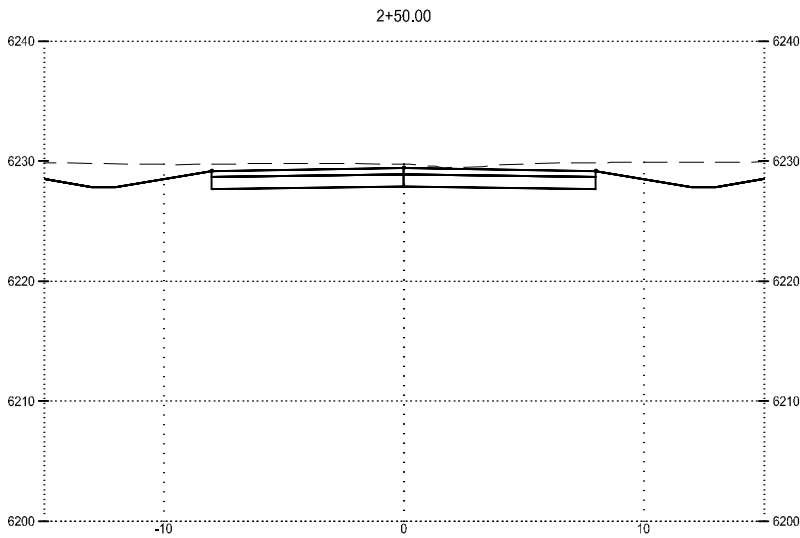

REV NO.		COMMENT		DATE	
		 SUNRISE ENGINEERING 770 S WASHINGTON ST. AFTON, WYOMING 83110 TEL 307.885.8500 • FAX 307.885.8501 www.sunrise-eng.com			
GR-RS-SC JPWB					
CROSSROADS PUMP STATION ACCESS ROAD SECTIONS					
SEI NO. 07265	DESIGNED FDK	DRAWN BJ	CHECKED JUL	SHEET NO. 13 of 99	RS2

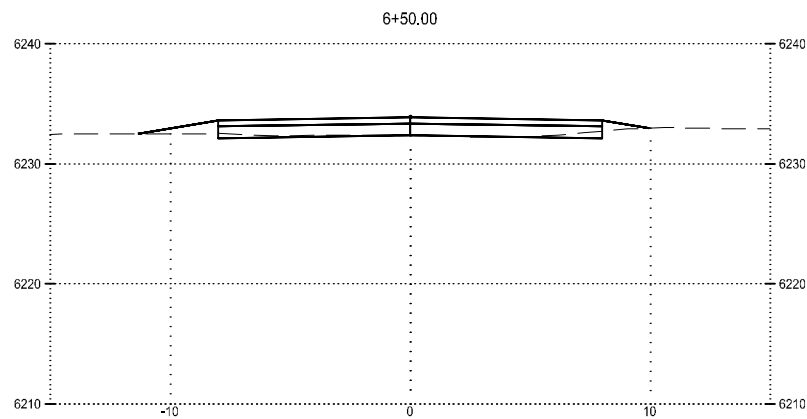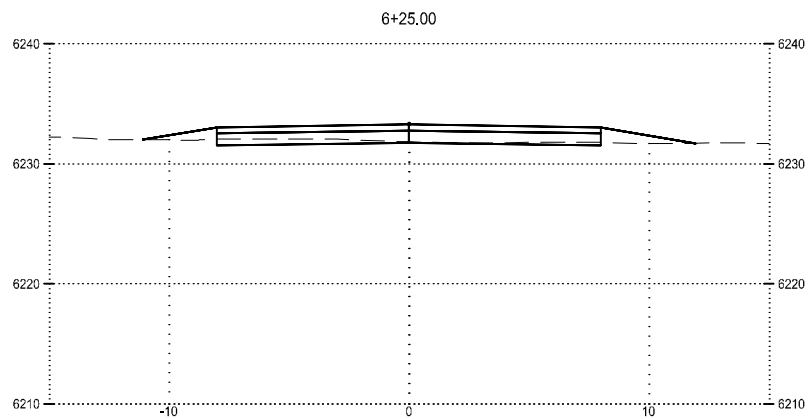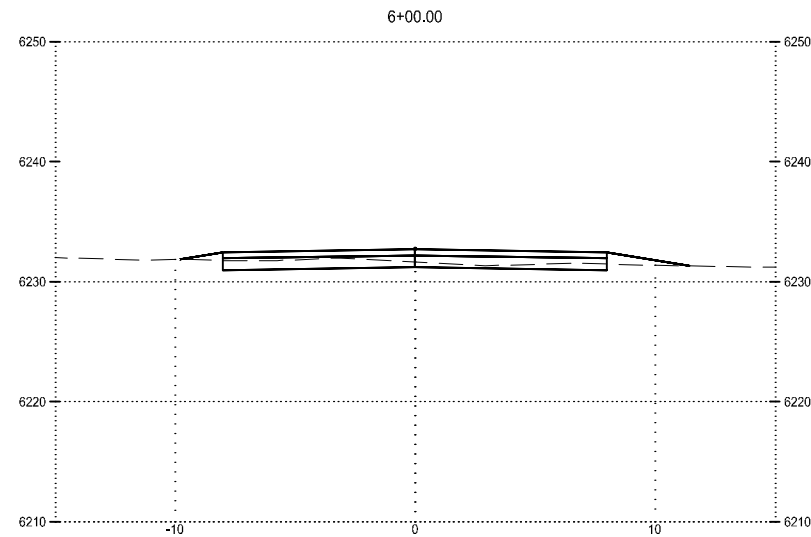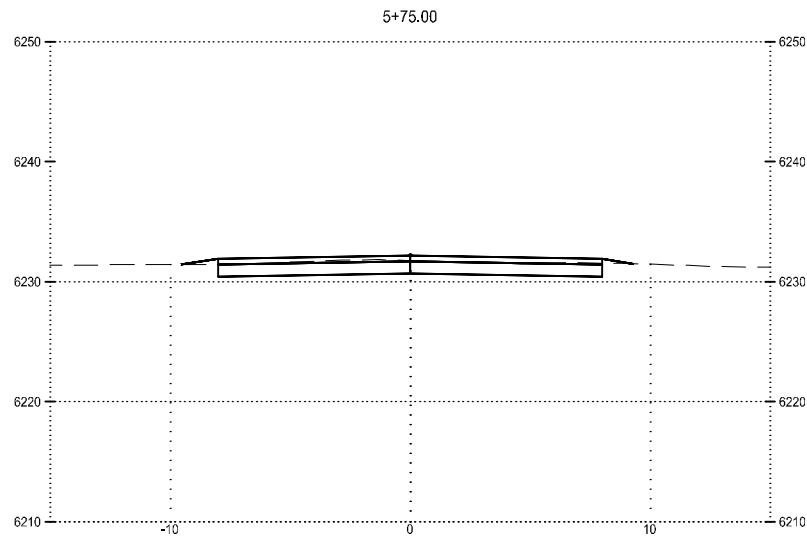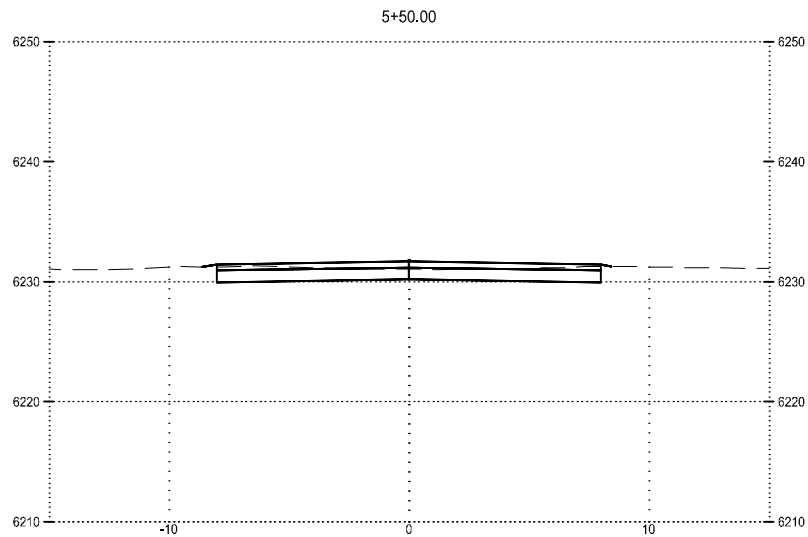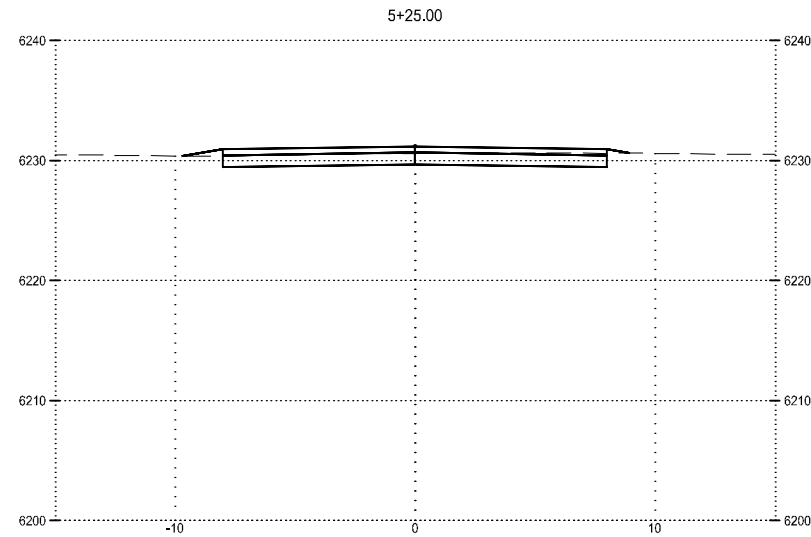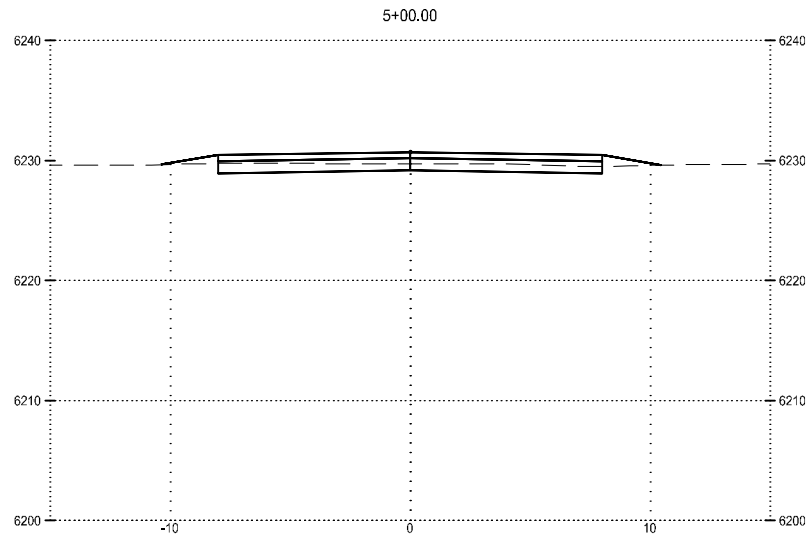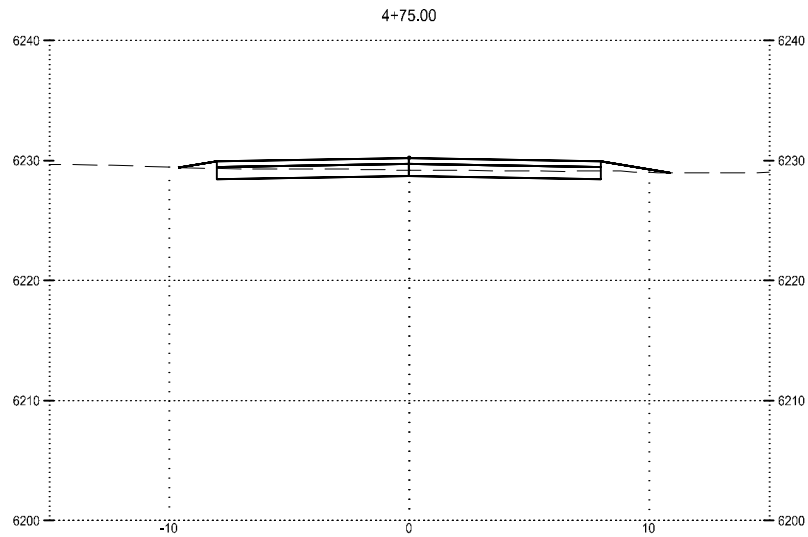


REV NO.		COMMENT		DATE	
		SUNRISE ENGINEERING 770 S WASHINGTON ST. AFTON, WYOMING 83110 TEL 307.885.8500 • FAX 307.885.8501 www.sunrise-eng.com			
GR-RS-SC JPWB					
CROSSROADS PUMP STATION ACCESS ROAD SECTIONS					
SEI NO. 07265	DESIGNED FDK	DRAWN BJ	CHECKED JUL	SHEET NO. 14 of 99	RS3

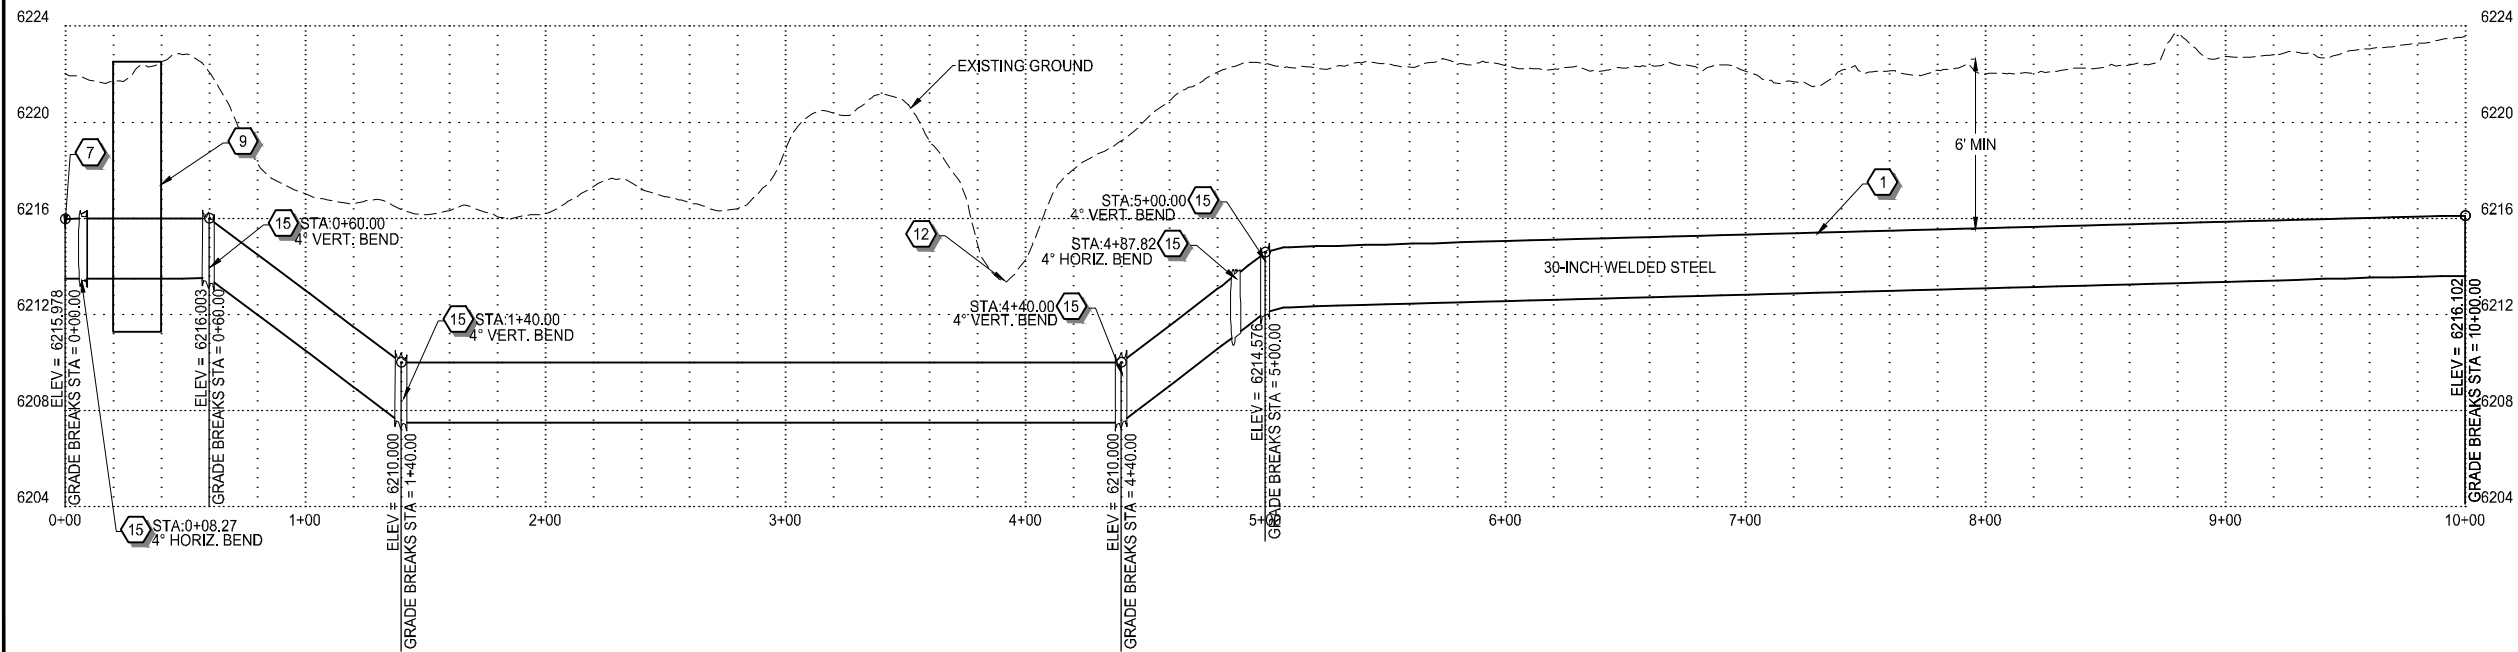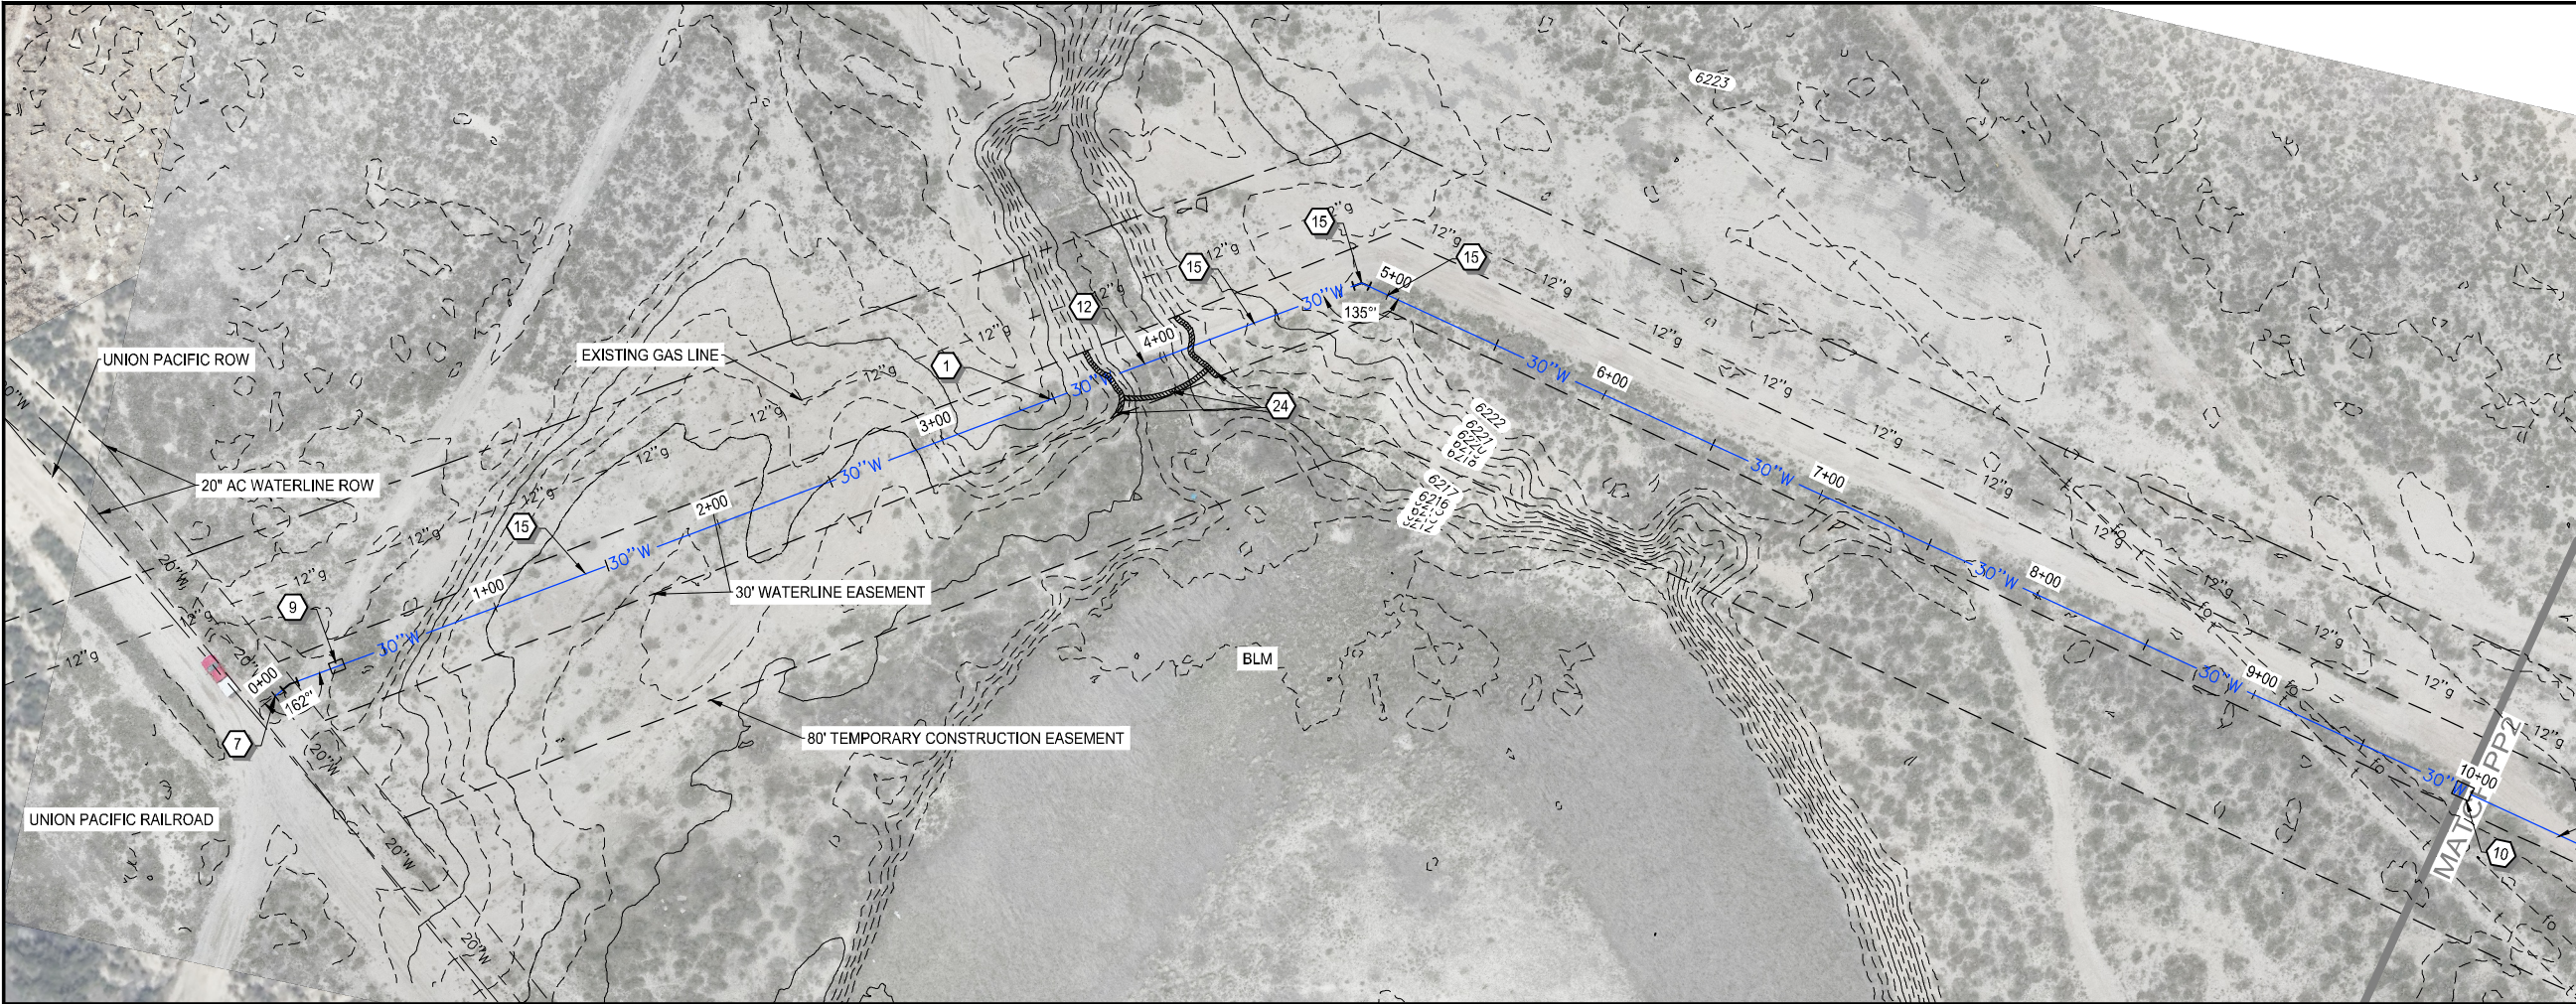

WATERLINE NOTES:

- NEW 30" WATERLINE PER (A/D2) (B/D2)
- CONNECT TO EXISTING 12" WATERLINE PER (C/D8) (D/D8) (E/D8)
- BEND (90°, 45°, 221/2°, ETC.) WITH THRUST BLOCK. (A/D3)
- BUTTERLY VALVE PER (C/D2)
- BLOWOFF ASSEMBLY PER (C/D4)
- TEE WITH THRUST BLOCK PER (A/D3)
- CONNECT TO EXISTING 20" WATERLINE PER (A/D1)
- MANWAY WITH AIRVAC PER (A/D8) (C/D7)
- MANWAY WITH AIR RELEASE PER (A/D1) (D13)
- MANWAY PER (A/D10) (A/D12)
- AIRVAC VALVE PER (C/D10) (C/D12)
- EPHEMERAL WASH CROSSING PER (A/D4)
- CONNECT TO EXISTING 18" WATERLINE PER (A/D8)
- CLAY CUT-OFF WALL PER (A/D5)
- 2-PIECE BEND (A/D3)
- 3-PIECE BEND (A/D3)
- JIM BRIDGER PIPELINE CROSSING (A/D) (B/D7)
- GATE VALVE PER DETAIL (D/D2)
- WEAK SOILS CROSSING (E/D1)
- CONCRETE PIPELINE ANCHOR (D/D13)
- 30"x12" CROSS WITH THRUST BLOCK PER (A/D3)
- CHECK VALVE VAULT (A/D8) (B/D8)
- EROSION BLANKET PER (E/D10) (G/D10)
- SEDIMENT LOG/WATTLE PER (A/D16) (B/D16)
- FIRE HYDRANT PER (E/D5)

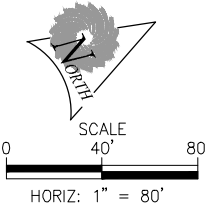

811 Know what's below.
Call before you dig.
1-800-849-2476

REV. NO.	COMMENT	DATE
----------	---------	------




770 S WASHINGTON ST.
AFTON, WYOMING 83110
TEL 307.885.8500 · FAX 307.885.8501
www.sunrise-eng.com

GR-RS-SC JPWB
CROSSROADS PUMP STATION


PLAN AND PROFILE

SEI NO.	DESIGNED	DRAWN	CHECKED	SHEET NO.	
07265	FDK	BJ	JUL	15 of 99	PP1

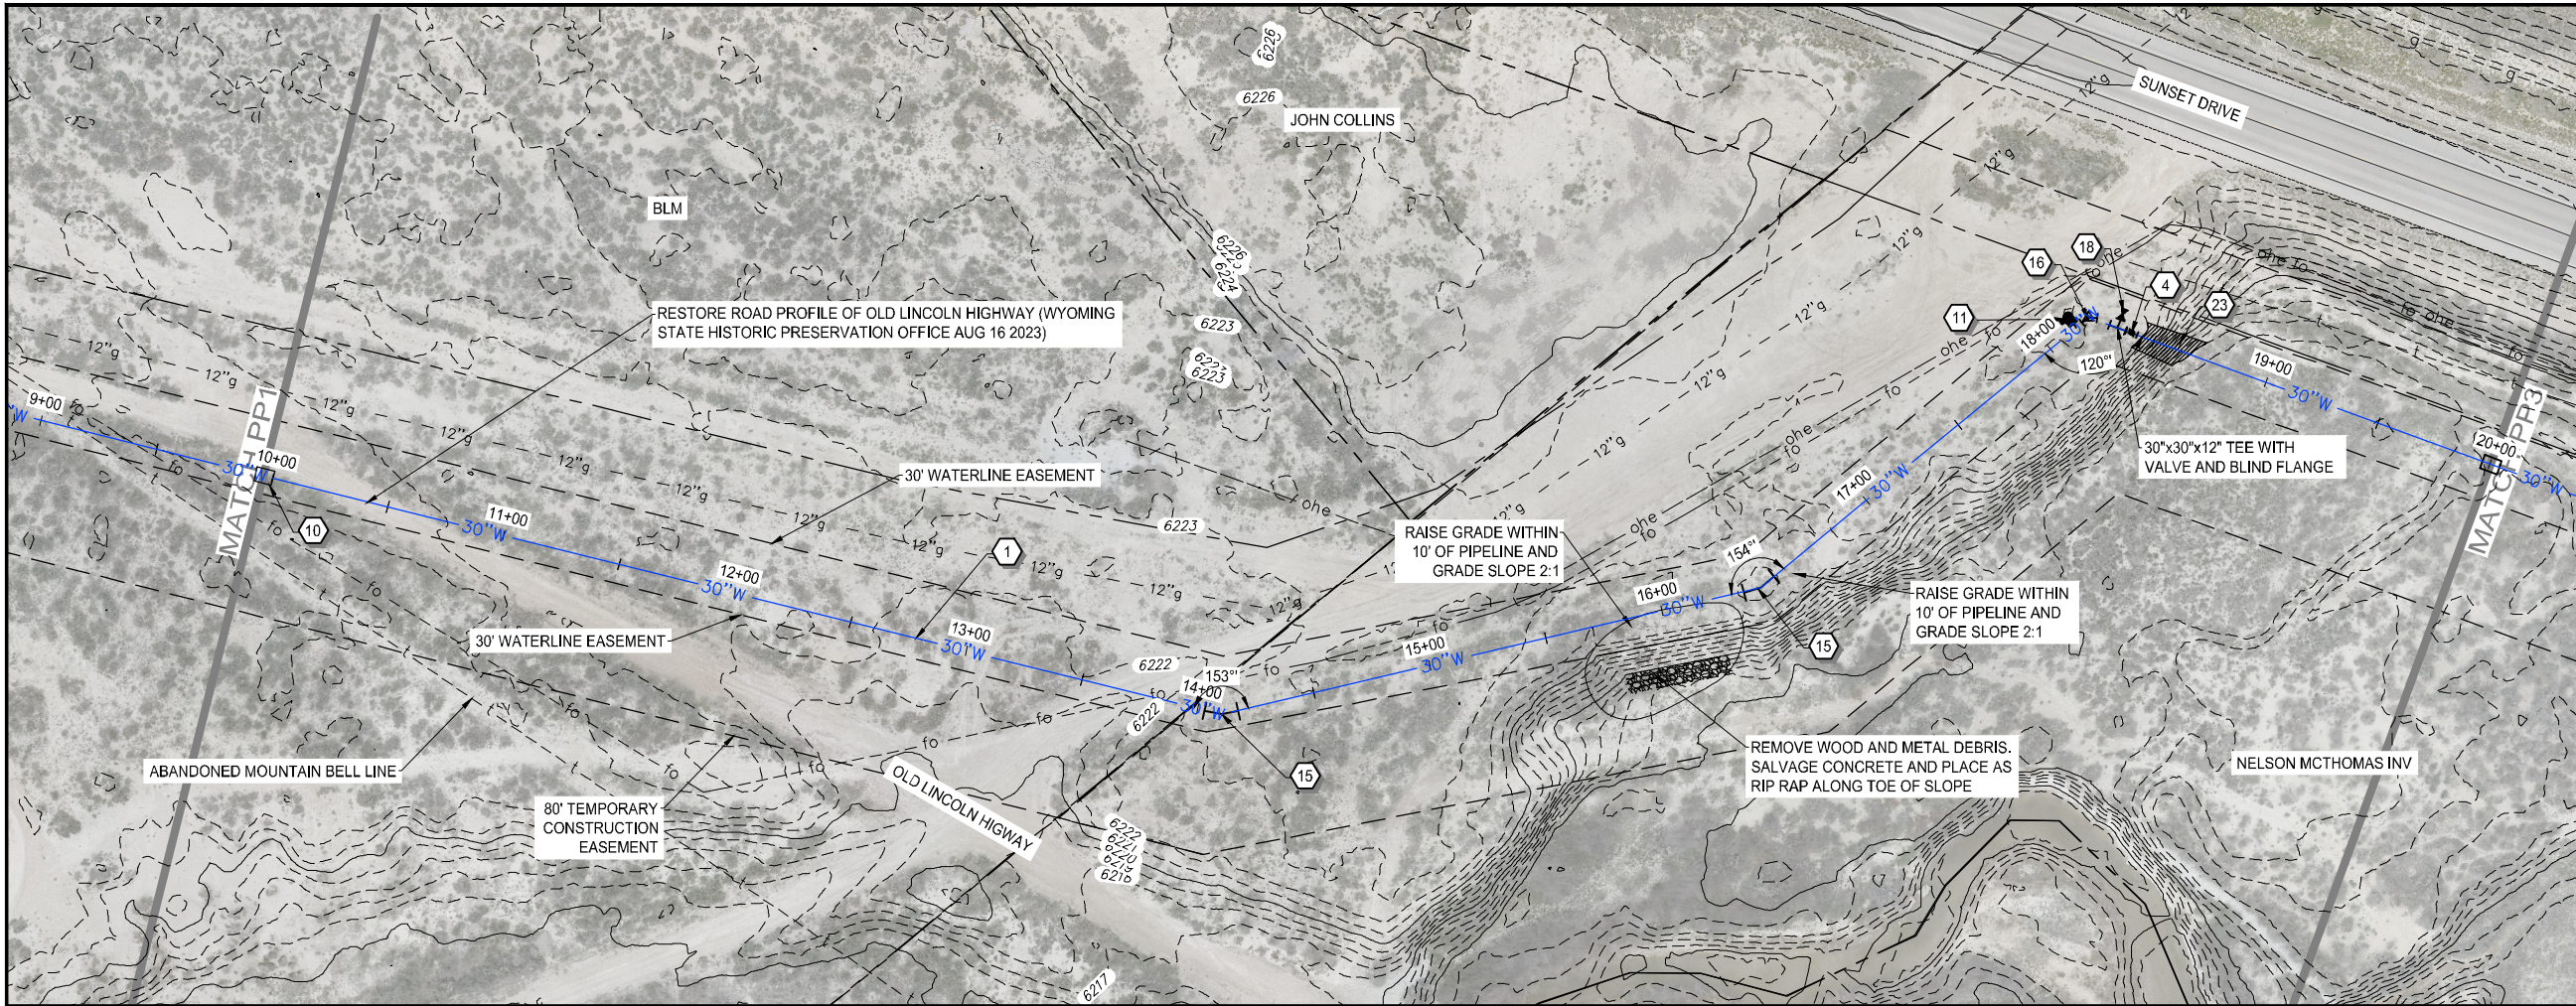

WATERLINE NOTES:

- 1 NEW 30" WATERLINE PER (A) (B) (D2) (D2)
- 2 CONNECT TO EXISTING 12" WATERLINE PER (C) (D) (D6) (D6) (E) (D6) (D6)
- 3 BEND (90°, 45°, 221/2°, ETC.) WITH THRUST BLOCK. (A) (D3)
- 4 BUTTERFLY VALVE PER (C) (D2)
- 5 BLOWOFF ASSEMBLY PER (C) (D4)
- 6 TEE WITH THRUST BLOCK PER (A) (D3)
- 7 CONNECT TO EXISTING 20" WATERLINE PER (A) (D1)
- 8 MANWAY WITH AIRVAC PER (A) (D8) (C) (D7)
- 9 MANWAY WITH AIR RELEASE PER (A) (D11) (D13)
- 10 MANWAY PER (A) (D10) (A) (D7)
- 11 AIRVAC VALVE PER (C) (D10) (C) (D7)
- 12 EPHEMERAL WASH CROSSING PER (A) (D4)
- 13 CONNECT TO EXISTING 18" WATERLINE PER (A) (D6)
- 14 CLAY CUT-OFF WALL PER (A) (D5)
- 15 2-PIECE BEND (A) (D3)
- 16 3-PIECE BEND (A) (D3)
- 17 JIM BRIDGER PIPELINE CROSSING (A) (B) (D7)
- 18 GATE VALVE PER DETAIL (D) (D2)
- 19 WEAK SOILS CROSSING (E) (D1)
- 20 CONCRETE PIPELINE ANCHOR (D) (D13)
- 21 30"x12" CROSS WITH THRUST BLOCK PER (A) (D3)
- 22 CHECK VALVE VAULT (A) (D6) (B) (D8)
- 23 EROSION BLANKET PER (F) (D10) (G) (D10)
- 24 SEDIMENT LOG/WATTLE PER (A) (D16) (B) (D16)
- 25 FIRE HYDRANT PER (E) (D5)

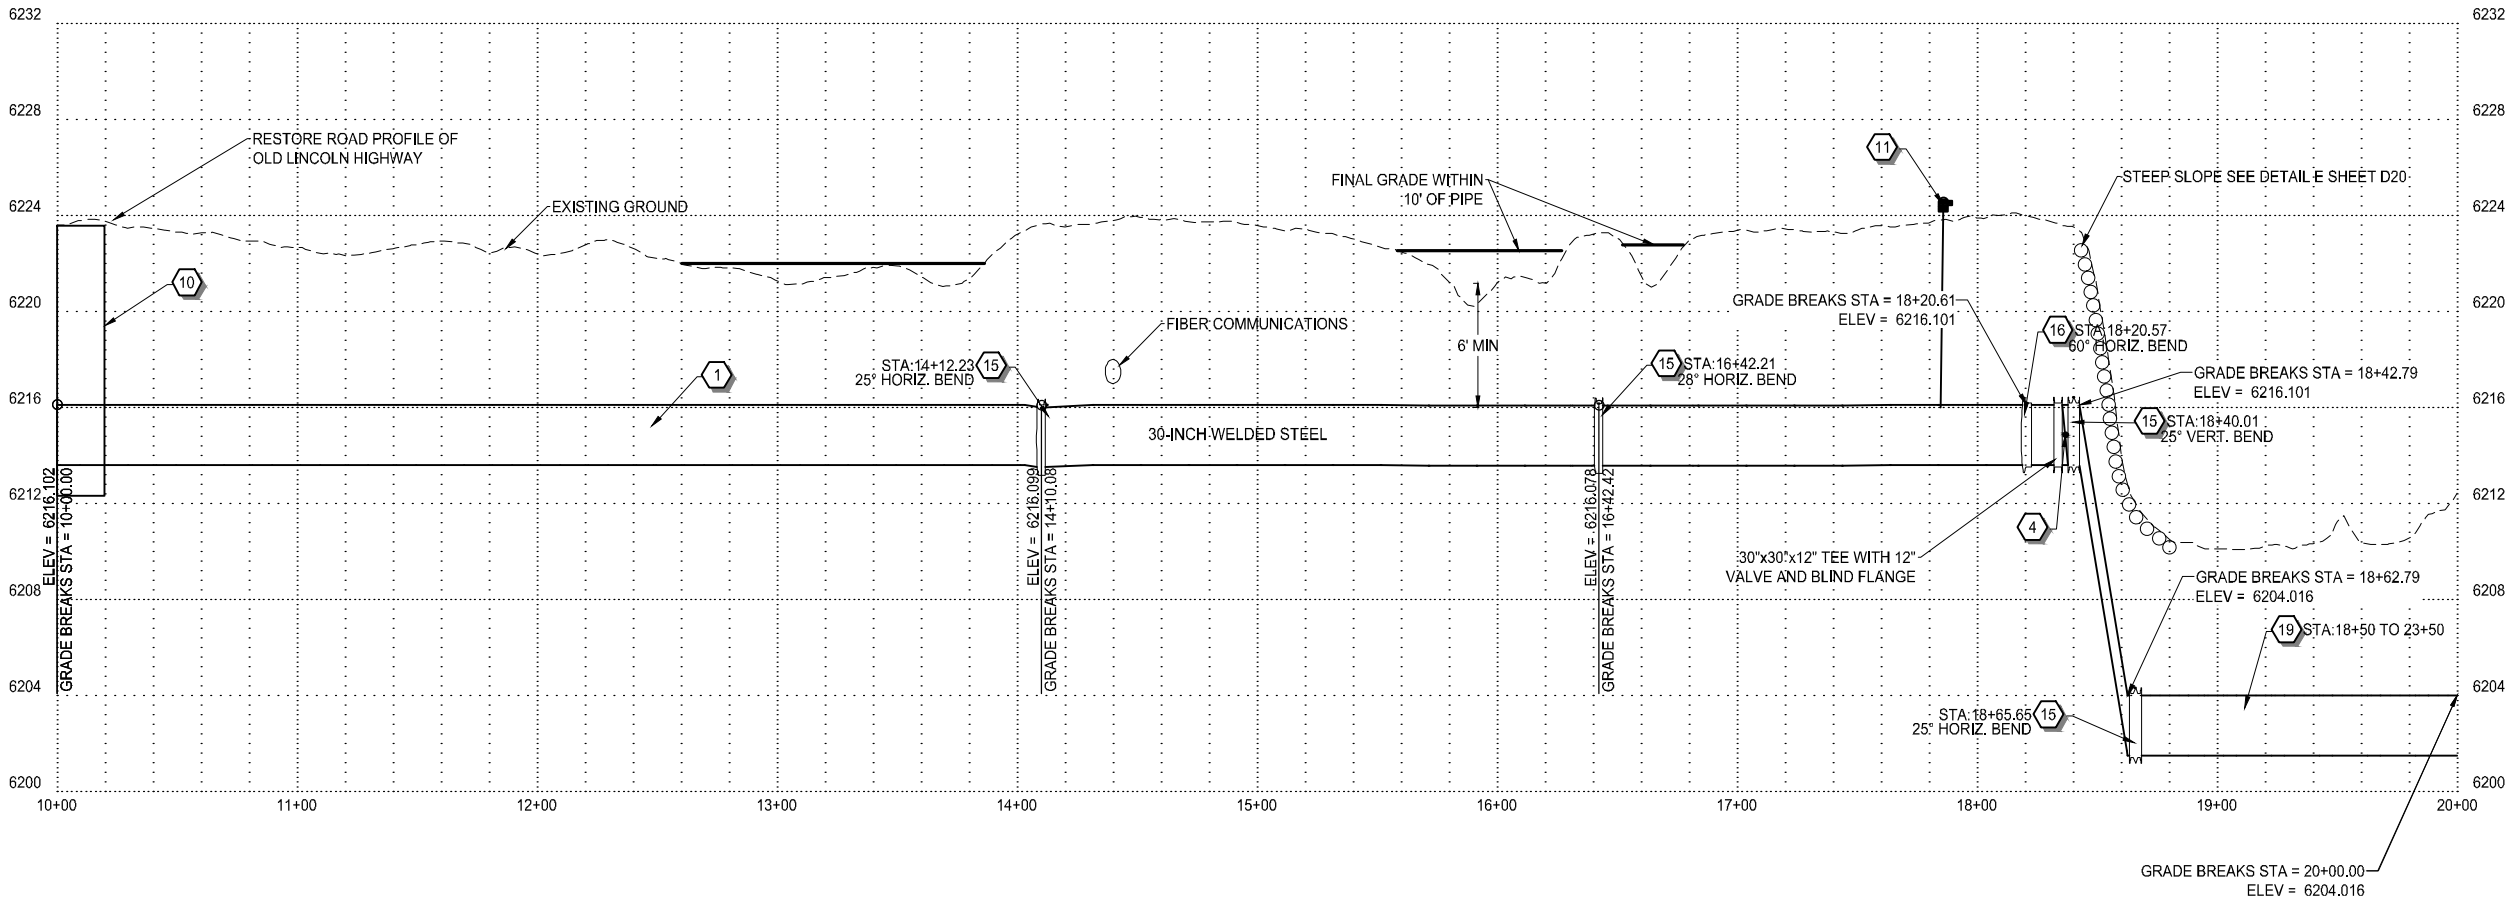

SCALE
0 40' 80'
HORIZ: 1" = 80'

811 Know what's below.
Call before you dig.
1-800-849-2476

REV. NO.	COMMENT	DATE
----------	---------	------





770 S WASHINGTON ST.
AFTON, WYOMING 83110
TEL 307.885.8500 · FAX 307.885.8501
www.sunrise-eng.com

GR-RS-SC JPWB
CROSSROADS PUMP STATION

PLAN AND PROFILE

SEI NO.	DESIGNED	DRAWN	CHECKED	SHEET NO.	
07265	FDK	BJ	JUL	16 of 99	PP2

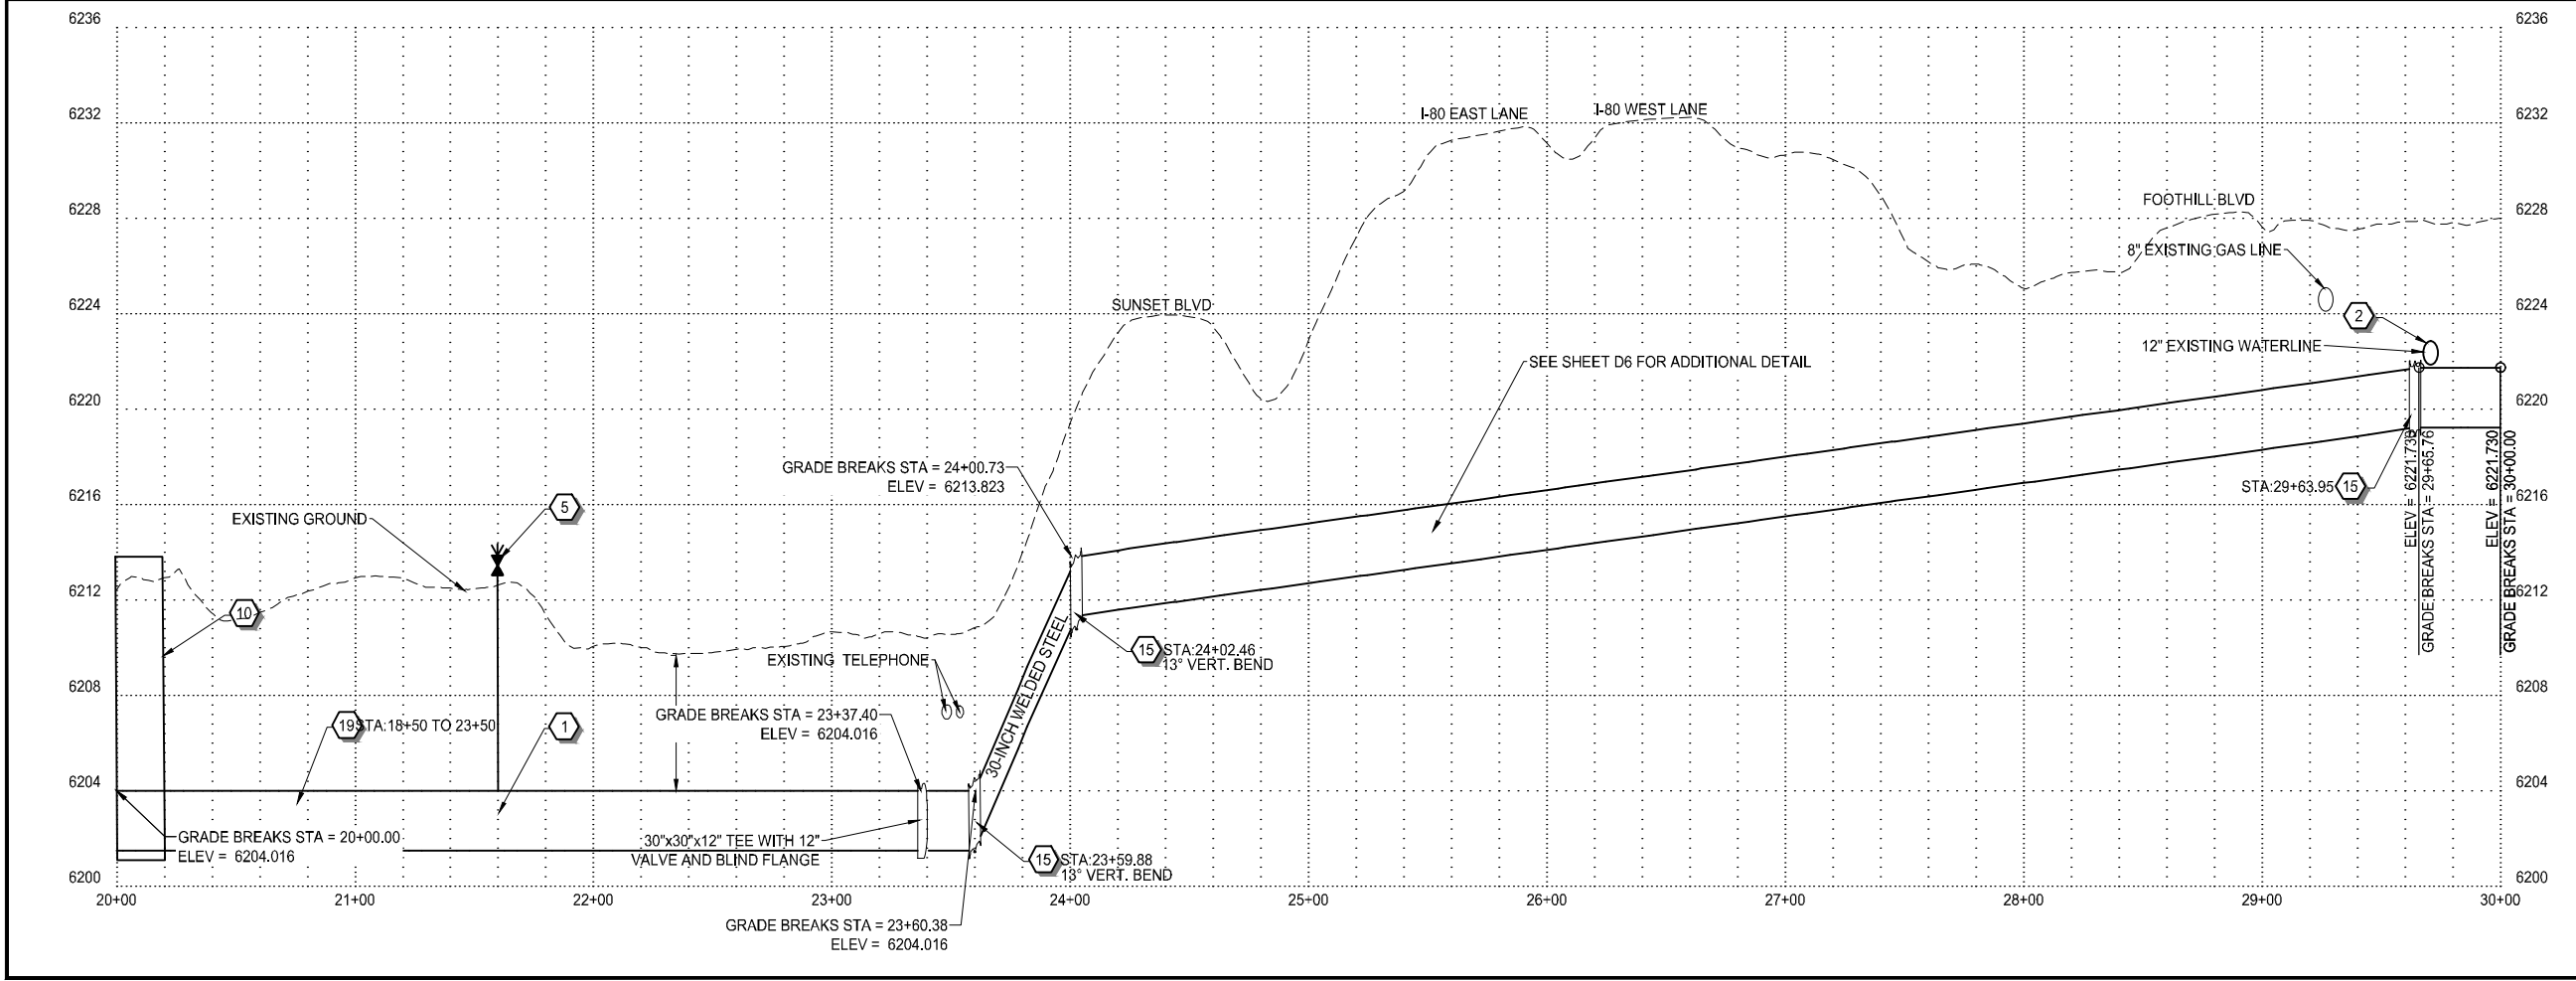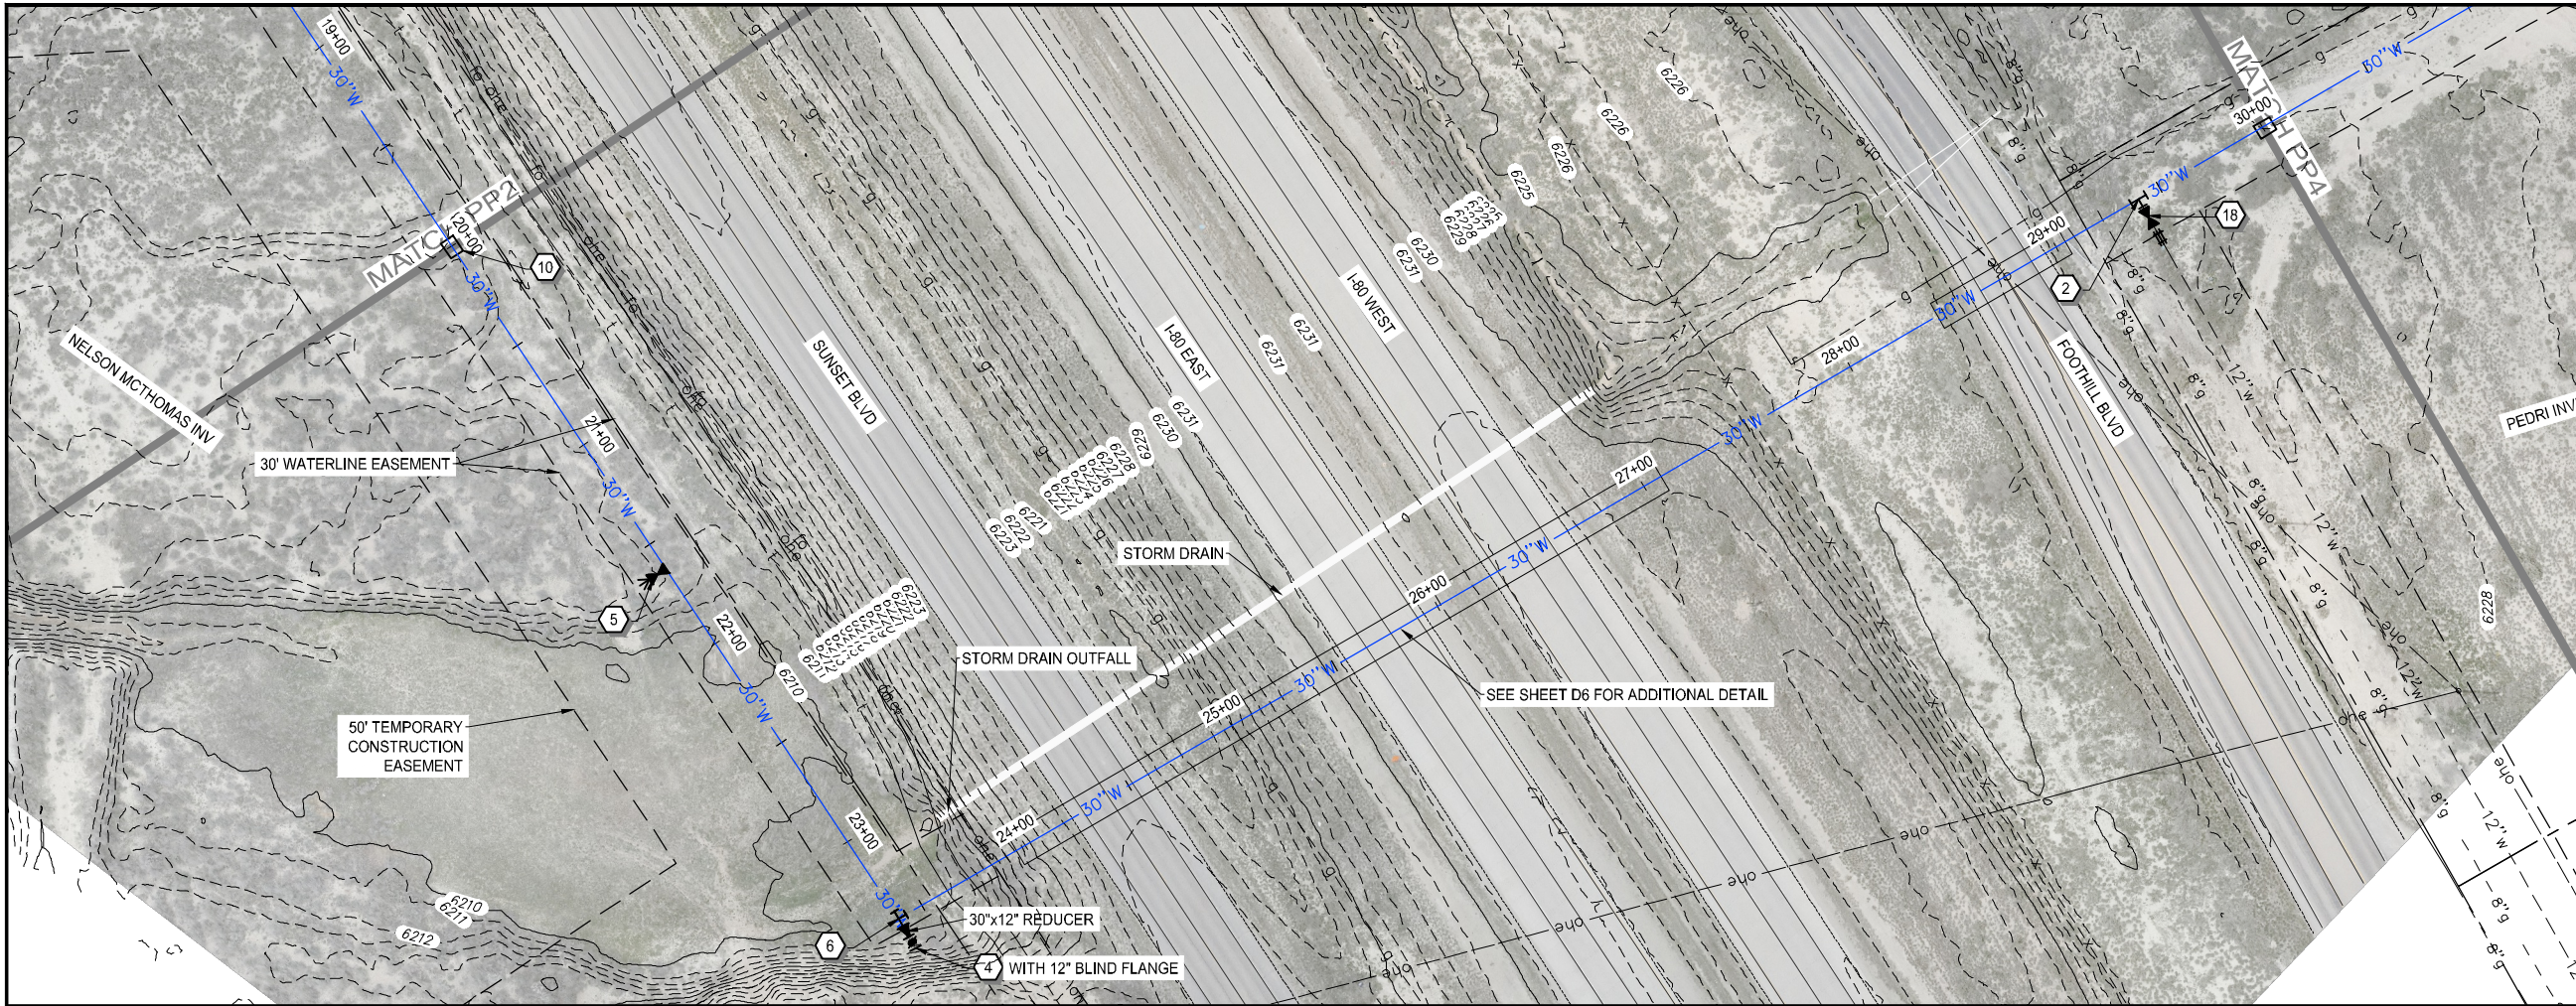

WATERLINE NOTES:

- 1 NEW 30" WATERLINE PER (A/B) (D2/D2)
- 2 CONNECT TO EXISTING 12" WATERLINE PER (C/D) (D6/D6)
- 3 BEND (90°, 45°, 221/2°, ETC.) WITH THRUST BLOCK. (A/D3)
- 4 BUTTERLY VALVE PER (C/D2)
- 5 BLOWOFF ASSEMBLY PER (C/D4)
- 6 TEE WITH THRUST BLOCK PER (A/D3)
- 7 CONNECT TO EXISTING 20" WATERLINE PER (A/D1)
- 8 MANWAY WITH AIRVAC PER (A/D9) (C/D17)
- 9 MANWAY WITH AIR RELEASE PER (A/D11) (D13)
- 10 MANWAY PER (A/D10) (A/D12)
- 11 AIRVAC VALVE PER (C/D10) (C/D12)
- 12 EPHEMERAL WASH CROSSING PER (A/D4)
- 13 CONNECT TO EXISTING 18" WATERLINE PER (A/D5)
- 14 CLAY CUT-OFF WALL PER (A/D5)
- 15 2-PIECE BEND (A/D3)
- 16 3-PIECE BEND (A/D3)
- 17 JIM BRIDGER PIPELINE CROSSING (A/B) (D1/D1)
- 18 GATE VALVE PER DETAIL (D/D2)
- 19 WEAK SOILS CROSSING (E/D1)
- 20 CONCRETE PIPELINE ANCHOR (D/D13)
- 21 30"x12" CROSS WITH THRUST BLOCK PER (A/D3)
- 22 CHECK VALVE VAULT (A/D6) (B/D8)
- 23 EROSION BLANKET PER (E/D10) (G/D18)
- 24 SEDIMENT LOG/WATTLE PER (A/D16) (B/D19)
- 25 FIRE HYDRANT PER (E/D5)



SCALE
0 40' 80'
HORIZ: 1" = 80'

811 Know what's below.
Call before you dig.
1-800-849-2476

REV. NO.	COMMENT	DATE
----------	---------	------




770 S WASHINGTON ST.
AFTON, WYOMING 83110
TEL 307.885.8500 · FAX 307.885.8501
www.sunrise-eng.com

GR-RS-SC JPWB
CROSSROADS PUMP STATION



PLAN AND PROFILE

SEI NO. 07265	DESIGNED FDK	DRAWN BJ	CHECKED JUL	SHEET NO. 17 of 99	PP3
------------------	-----------------	-------------	----------------	-----------------------	-----

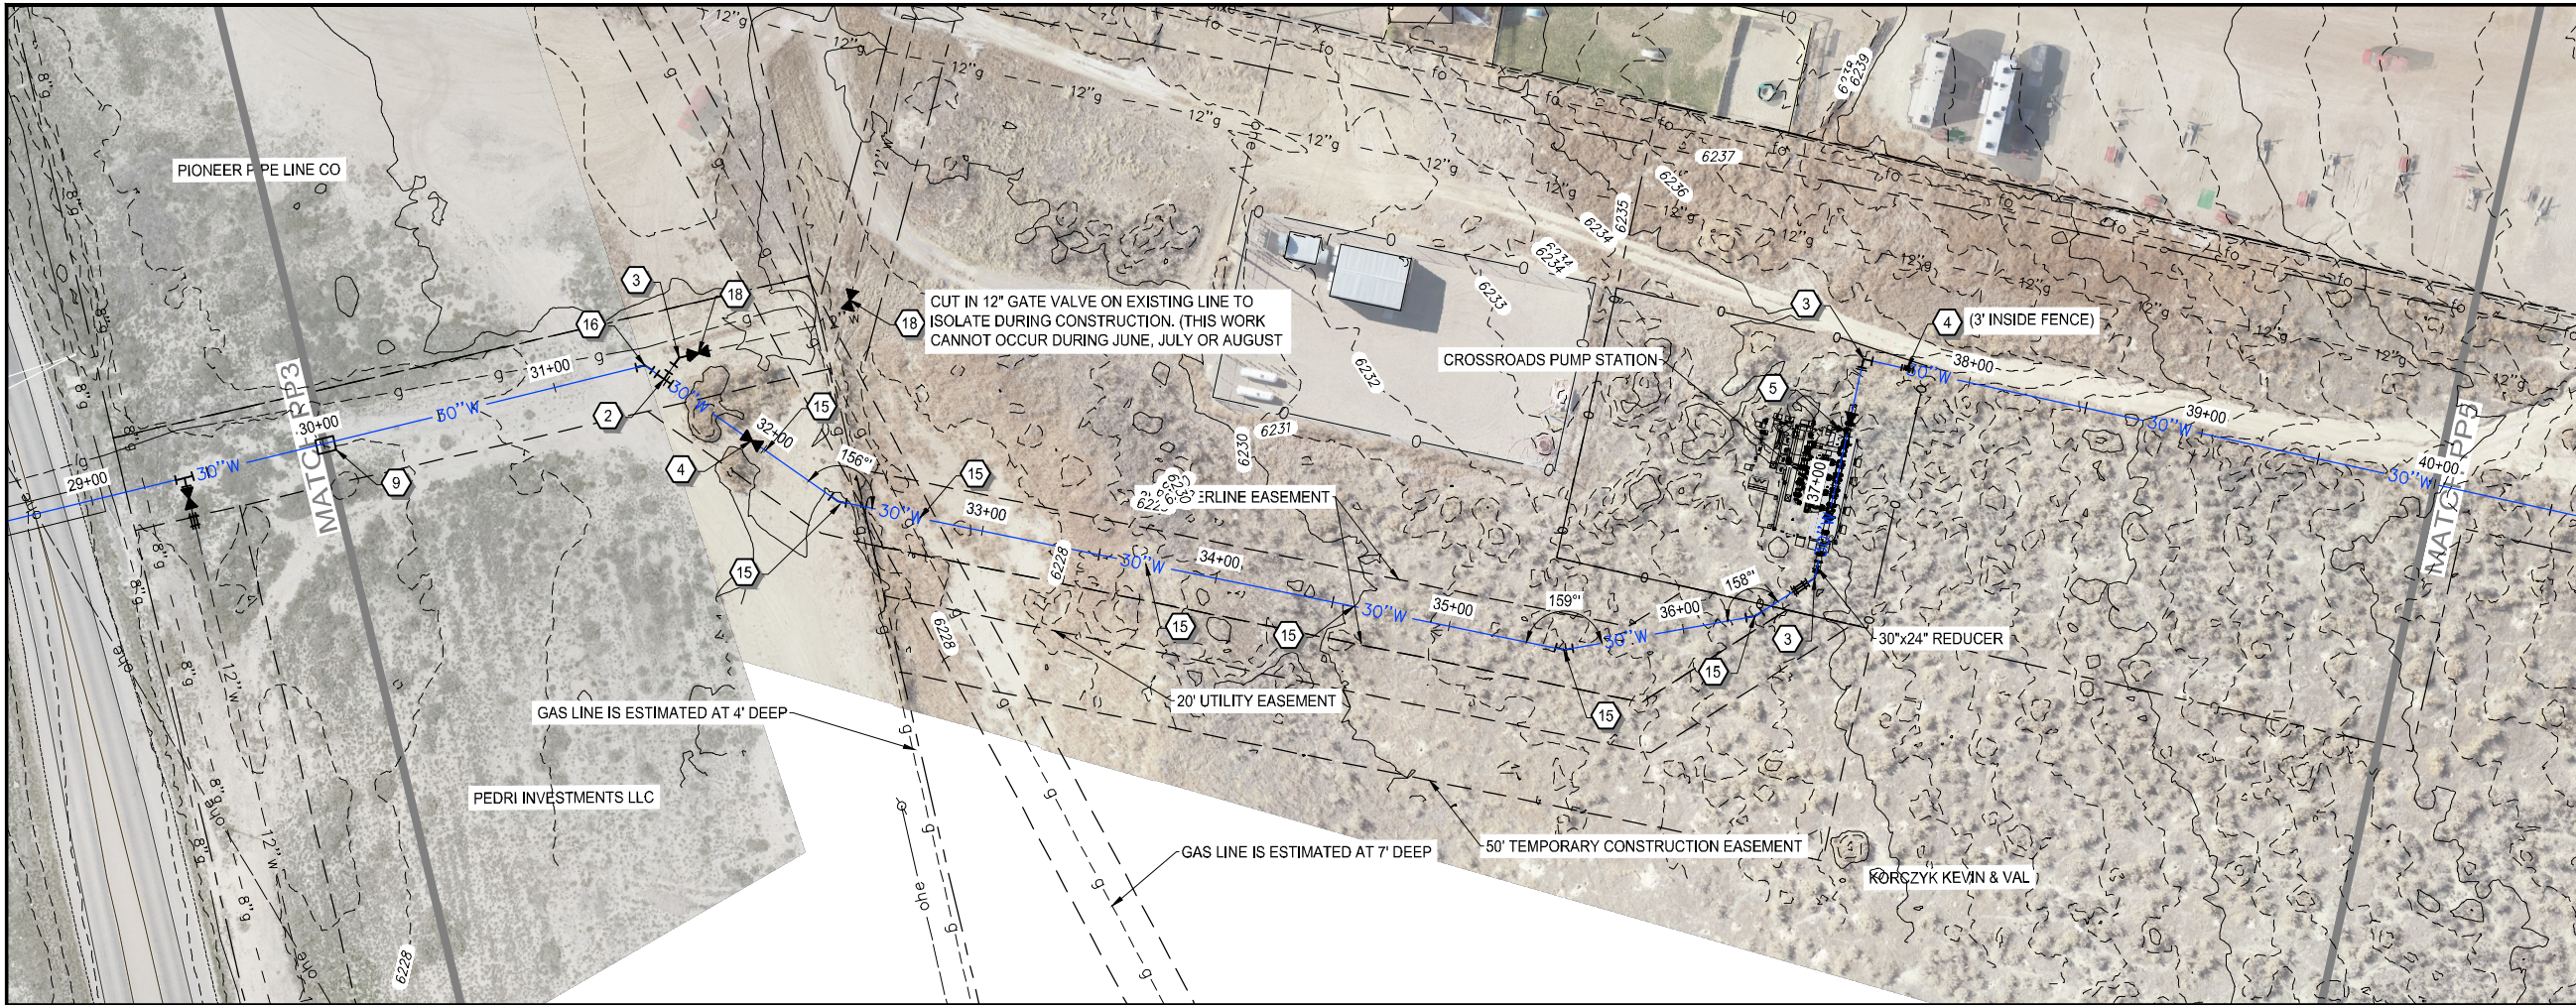

WATERLINE NOTES:

 

- 1 NEW 30" WATERLINE PER (A/B D2/D2)
- 2 CONNECT TO EXISTING 12" WATERLINE PER (C/D D8/D8 D9)
- 3 BEND (90°, 45°, 221/2°, ETC.) WITH THRUST BLOCK. (A/D3)
- 4 BUTTERFLY VALVE PER (C/D2)
- 5 BLOWOFF ASSEMBLY PER (C/D4)
- 6 TEE WITH THRUST BLOCK PER (A/D3)
- 7 CONNECT TO EXISTING 20" WATERLINE PER (A/D1)
- 8 MANWAY WITH AIRVAC PER (A/D8 D9/D9 D17)
- 9 MANWAY WITH AIR RELEASE PER (A/D11 D13)
- 10 MANWAY PER (A/D10 D12)
- 11 AIRVAC VALVE PER (C/D10 D12)
- 12 EPHEMERAL WASH CROSSING PER (A/D4)
- 13 CONNECT TO EXISTING 18" WATERLINE PER (A/D5)
- 14 CLAY CUT-OFF WALL PER (A/D5)
- 15 2-PIECE BEND (A/D3)
- 16 3-PIECE BEND (A/D3)
- 17 JIM BRIDGER PIPELINE CROSSING (A/B D1/D1)
- 18 GATE VALVE PER DETAIL (D/D2)
- 19 WEAK SOILS CROSSING (E/D1)
- 20 CONCRETE PIPELINE ANCHOR (D/D13)
- 21 30"x12" CROSS WITH THRUST BLOCK PER (A/D3)
- 22 CHECK VALVE VAULT (A/D6 B/D8)
- 23 EROSION BLANKET PER (E/D10 D18)
- 24 SEDIMENT LOG/WATTLE PER (A/D16 B/D16)
- 25 FIRE HYDRANT PER (E/D5)

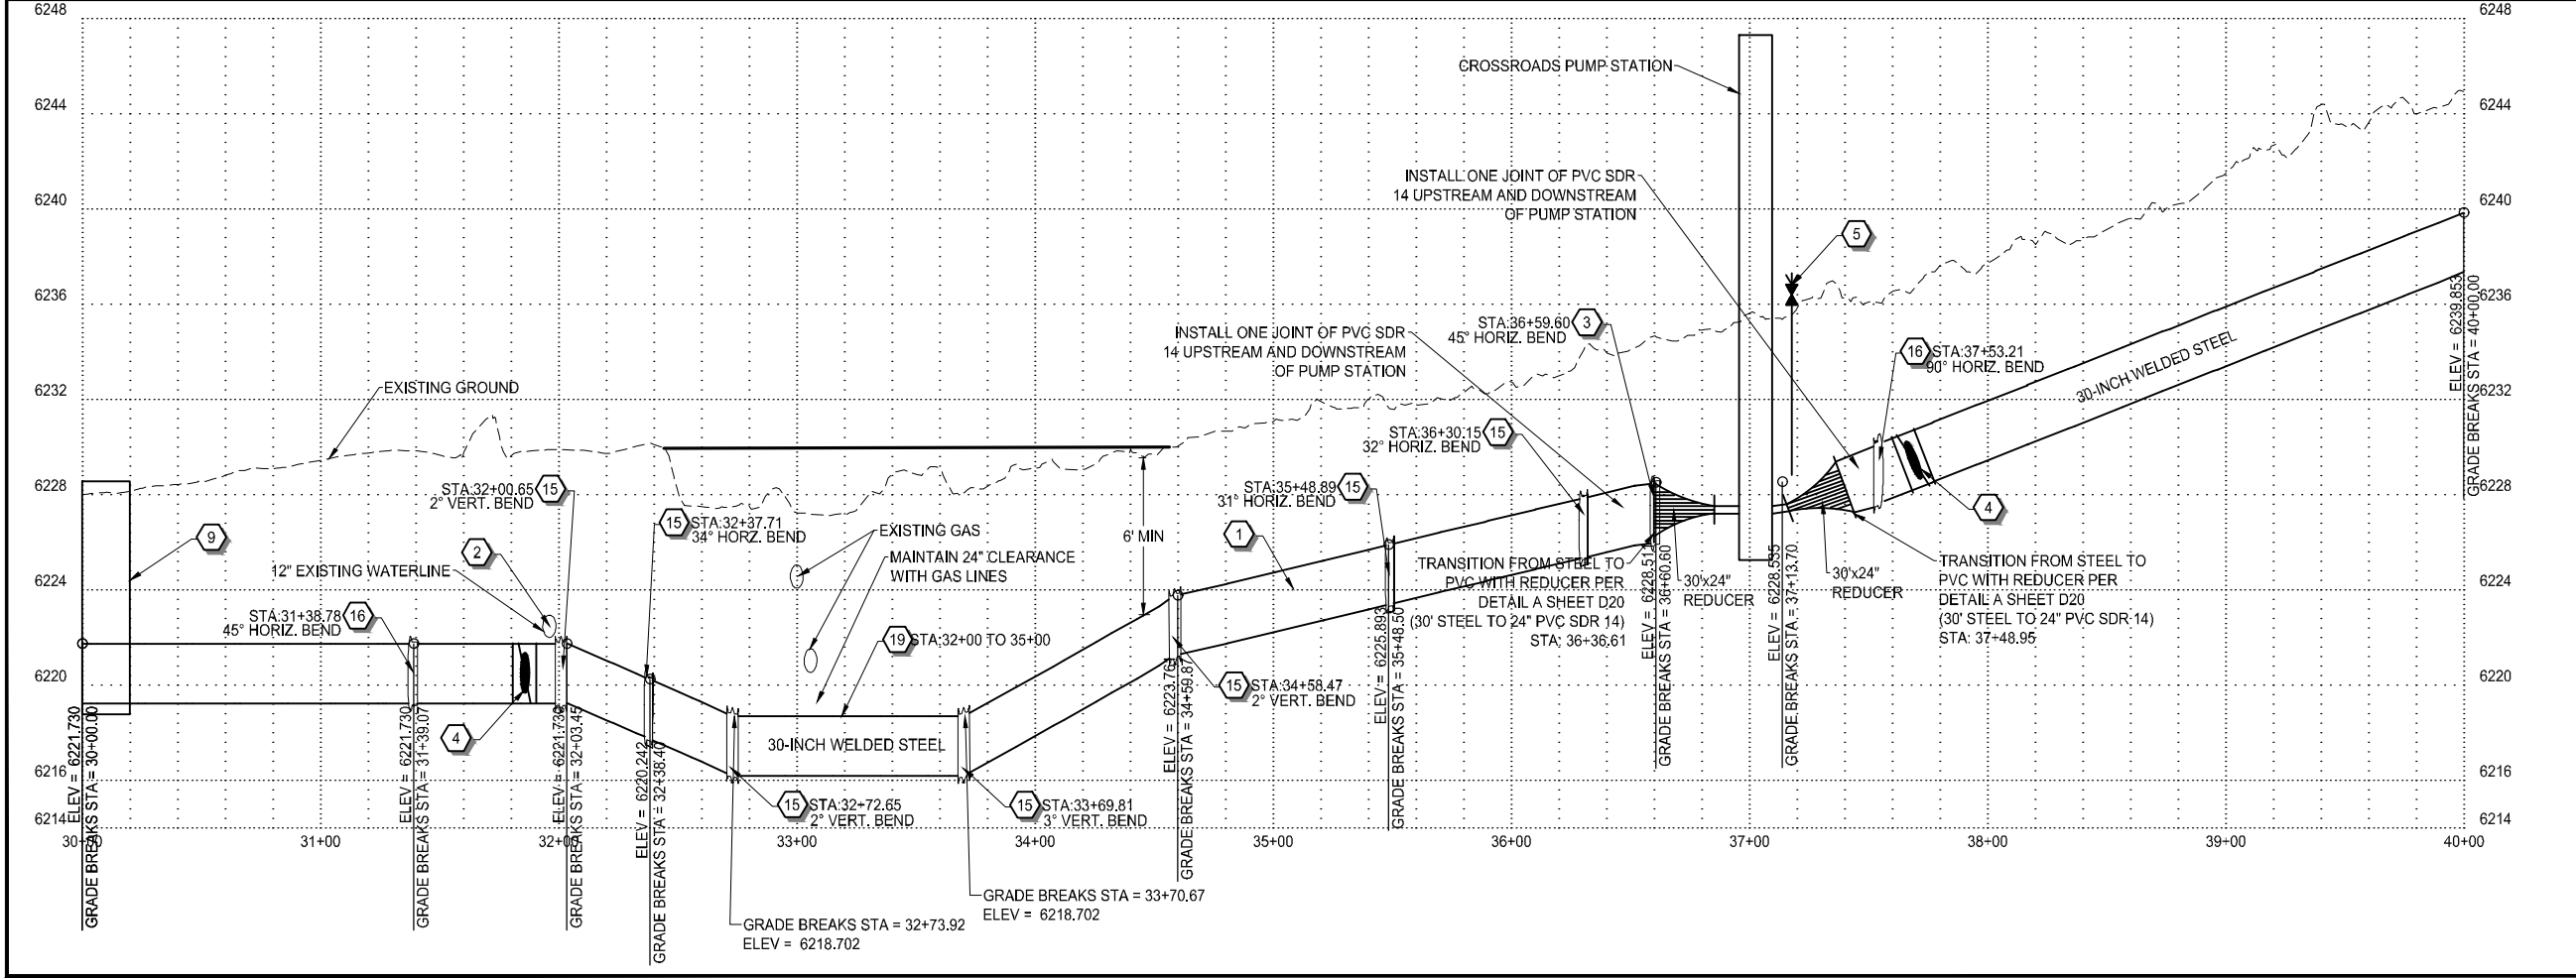



Know what's below.
Call before you dig.
1-800-849-2476

REV. NO.	COMMENT	DATE
 SUNRISE ENGINEERING 770 S WASHINGTON ST. AFTON, WYOMING 83110 TEL 307.885.8500 • FAX 307.885.8501 www.sunrise-eng.com		
GR-RS-SC JPWB		
CROSSROADS PUMP STATION		
PLAN AND PROFILE		
SEI NO. 07265	DESIGNED FDK	DRAWN BJ
CHECKED JUL	SHEET NO. 18 of 99	PP4

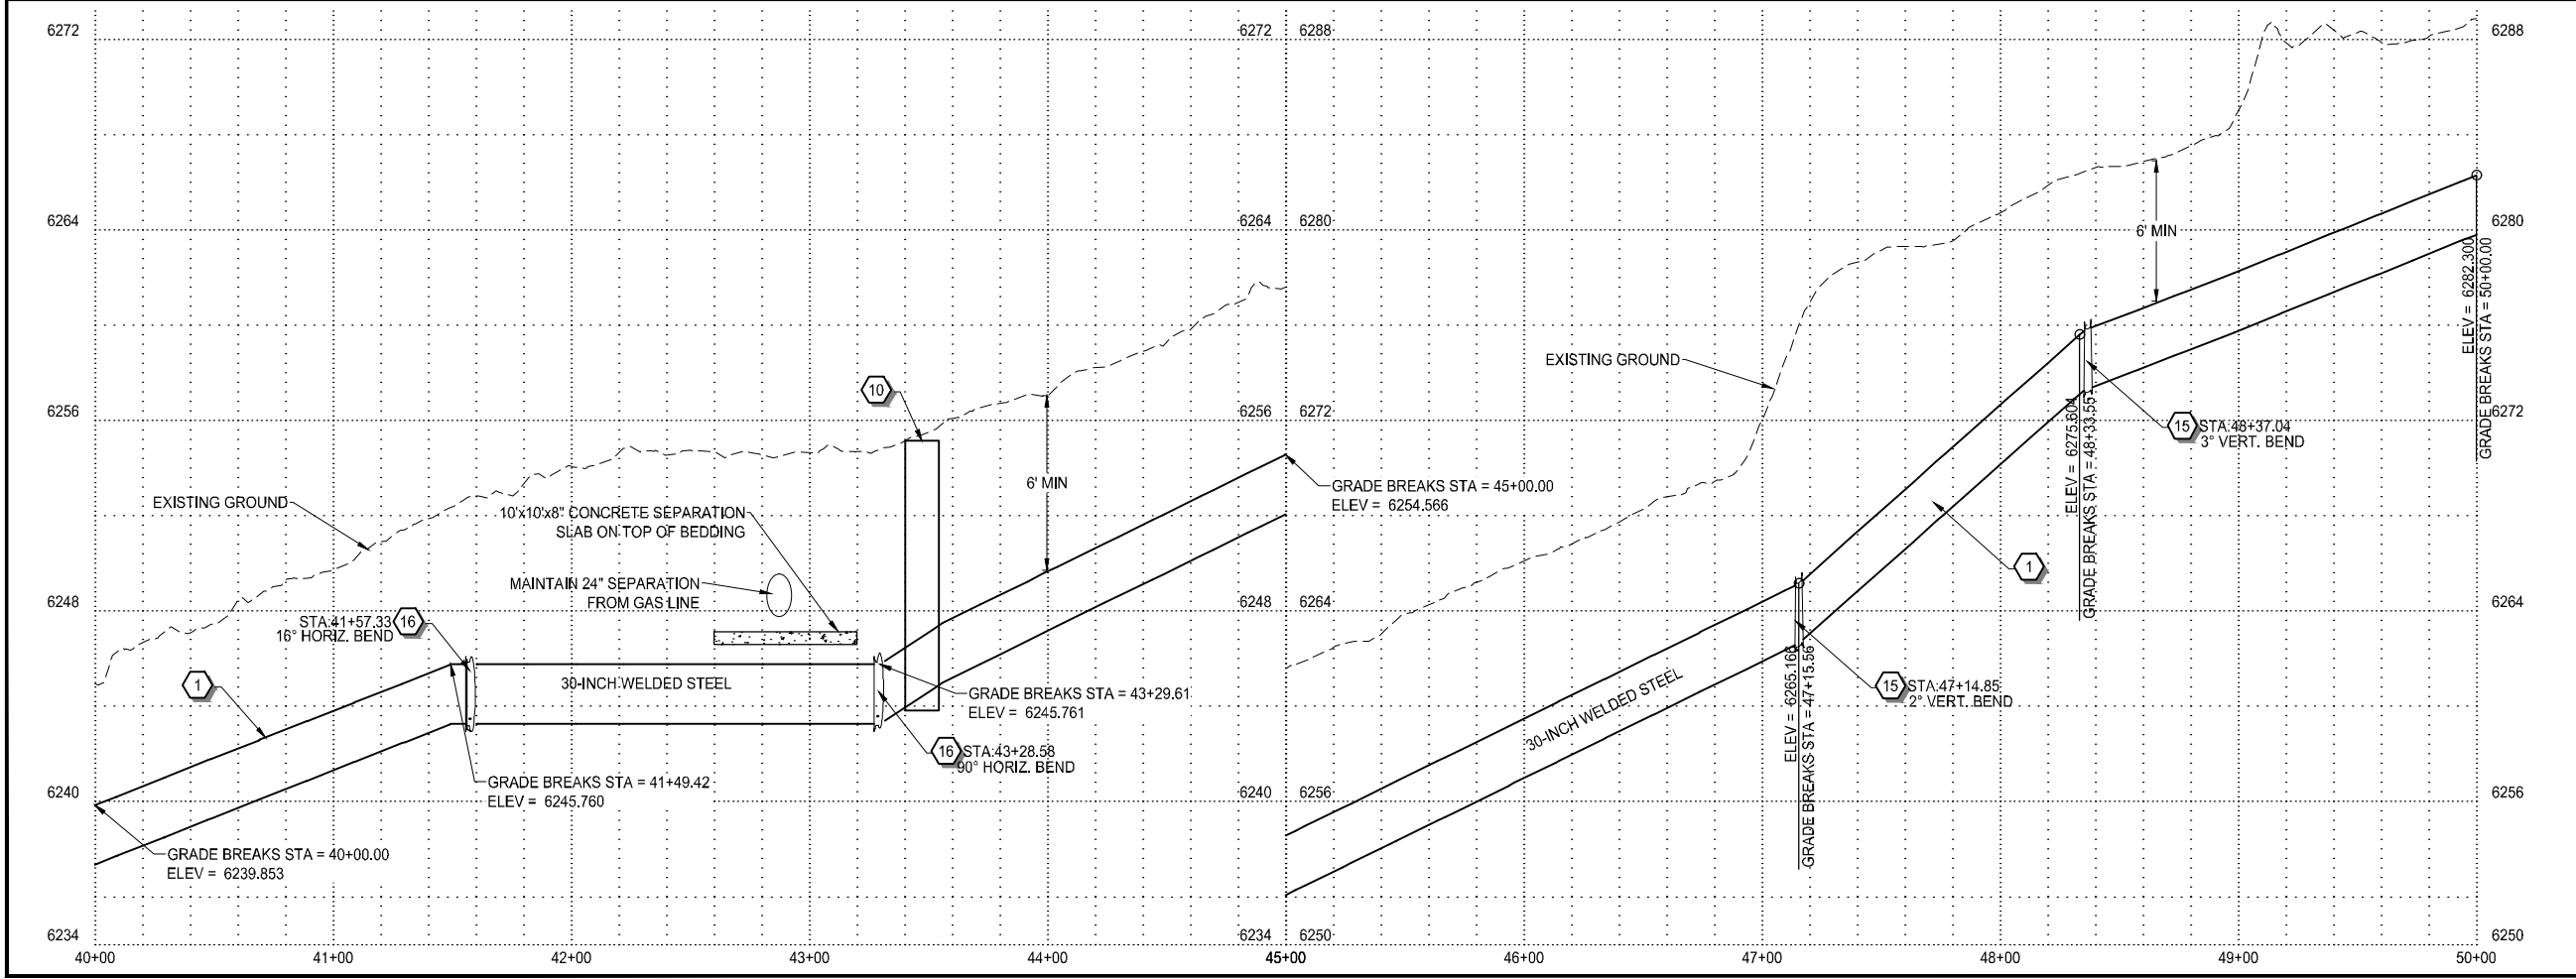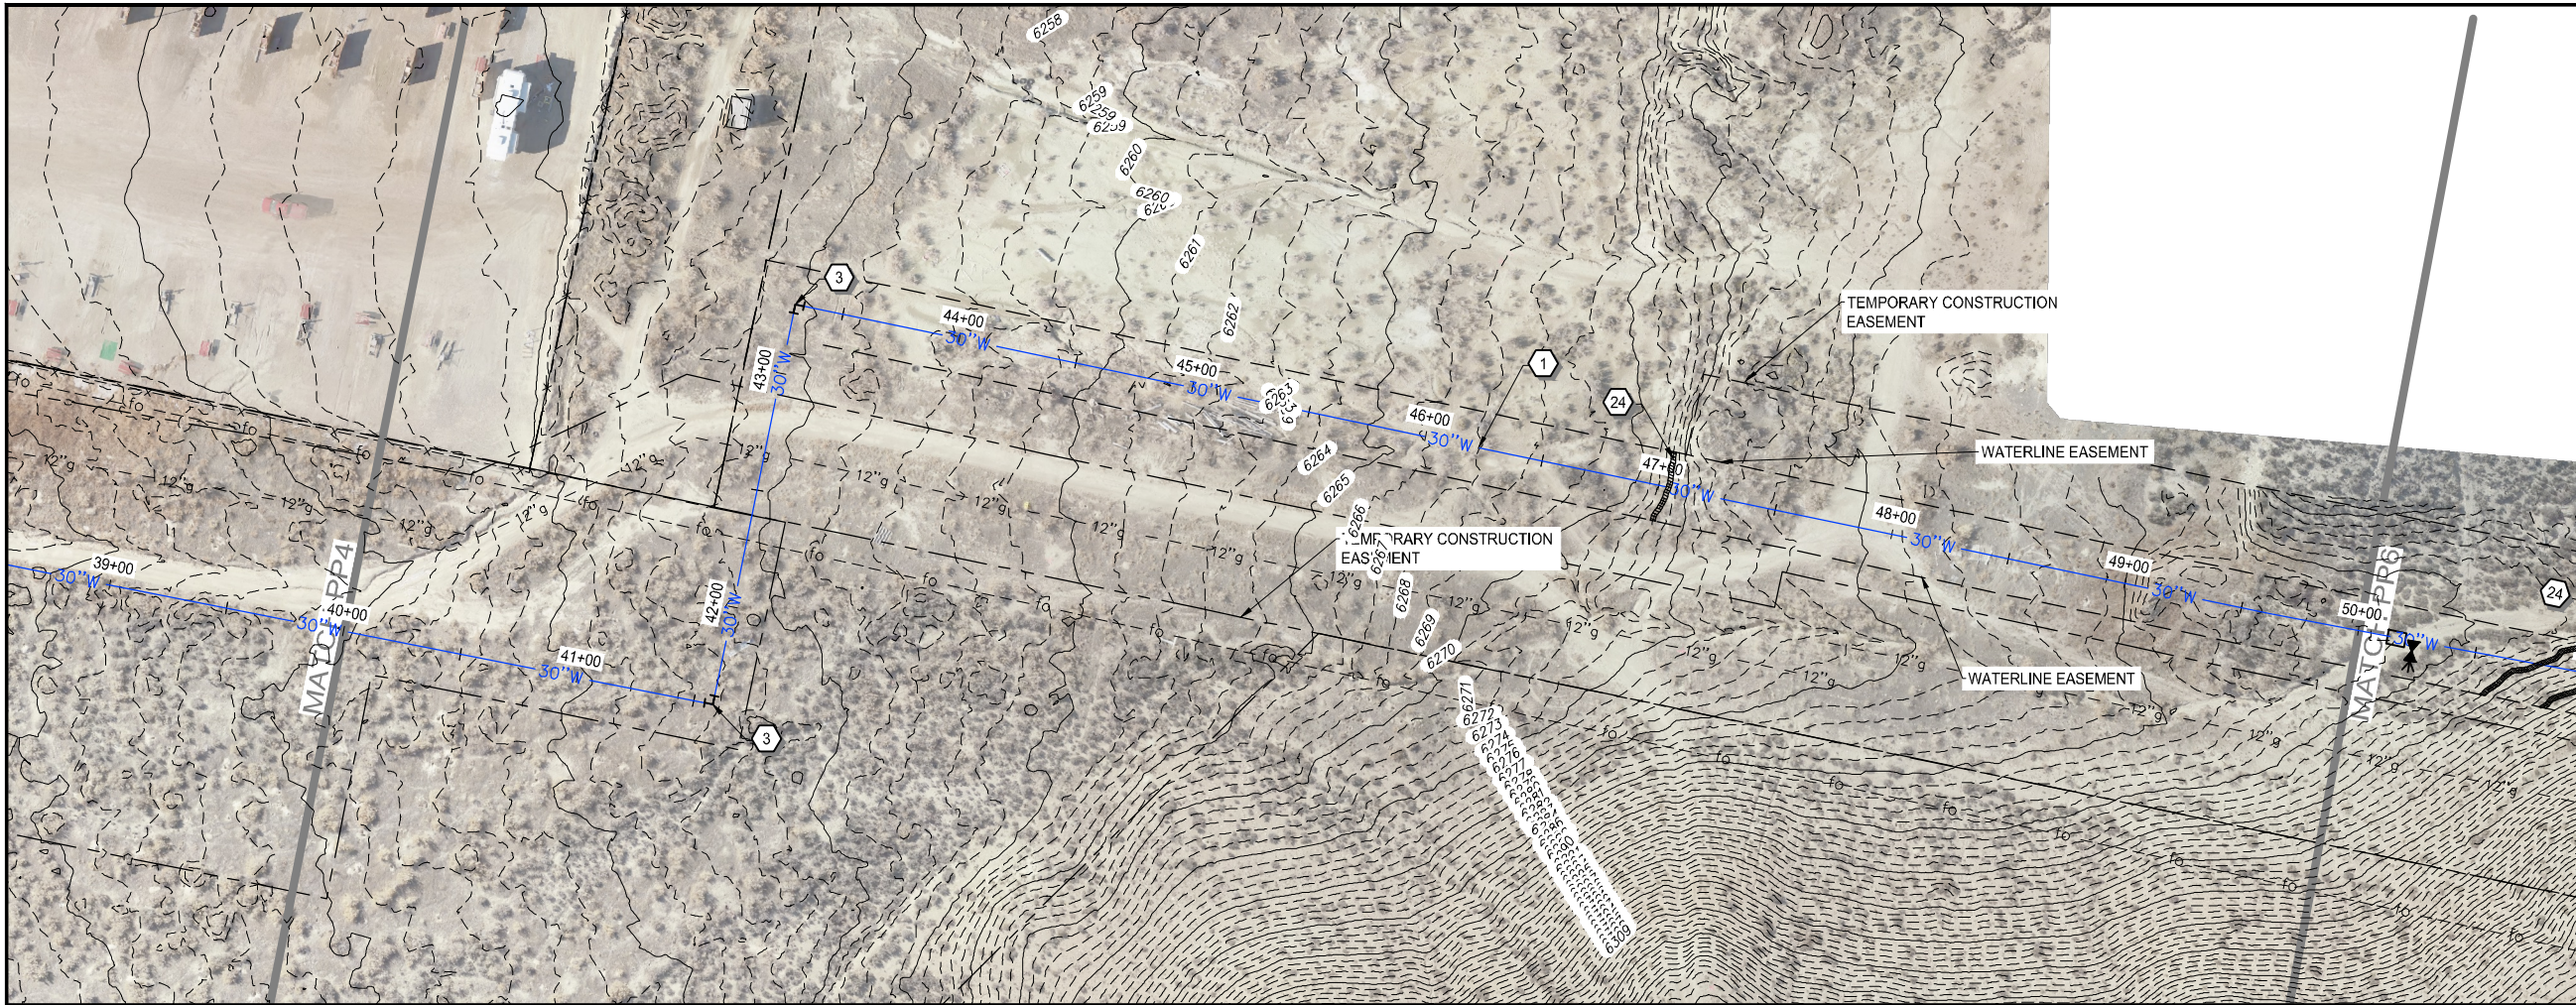

WATERLINE NOTES:



- 1 NEW 30" WATERLINE PER (A/B) (D2/D2)
- 2 CONNECT TO EXISTING 12" WATERLINE PER (D8/D8) (D9/D9)
- 3 BEND (90°, 45°, 221/2°, ETC.) WITH THRUST BLOCK. (A/D3)
- 4 BUTTERLY VALVE PER (C/D2)
- 5 BLOWOFF ASSEMBLY PER (C/D4)
- 6 TEE WITH THRUST BLOCK PER (A/D3)
- 7 CONNECT TO EXISTING 20" WATERLINE PER (A/D1)
- 8 MANWAY WITH AIRVAC PER (A/D8) (C/D12)
- 9 MANWAY WITH AIR RELEASE PER (A/D11) (A/D13)
- 10 MANWAY PER (A/D10) (A/D12)
- 11 AIRVAC VALVE PER (C/D10) (C/D12)
- 12 EPHEMERAL WASH CROSSING PER (A/D4)
- 13 CONNECT TO EXISTING 18" WATERLINE PER (A/D8)
- 14 CLAY CUT-OFF WALL PER (A/D5)
- 15 2-PIECE BEND (A/D3)
- 16 3-PIECE BEND (A/D3)
- 17 JIM BRIDGER PIPELINE CROSSING (A/D1) (B/D1)
- 18 GATE VALVE PER DETAIL (D/D2)
- 19 WEAK SOILS CROSSING (E/D1)
- 20 CONCRETE PIPELINE ANCHOR (D/D13)
- 21 30"x12" CROSS WITH THRUST BLOCK PER (A/D3)
- 22 CHECK VALVE VAULT (A/D6) (B/D8)
- 23 EROSION BLANKET PER (E/D10) (G/D18)
- 24 SEDIMENT LOG/WATTLE PER (A/D16) (B/D18)
- 25 FIRE HYDRANT PER (E/D5)




SCALE
0 40' 80'
HORIZ: 1" = 80'

811 Know what's below.
Call before you dig.
1-800-849-2476

REV. NO.	COMMENT	DATE
 SUNRISE ENGINEERING		
770 S WASHINGTON ST. AFTON, WYOMING 83110 TEL 307.885.8500 · FAX 307.885.8501 www.sunrise-eng.com		
GR-RS-SC JPWB		
CROSSROADS PUMP STATION		
PLAN AND PROFILE		
SEI NO. 07265	DESIGNED FDK	DRAWN BJ
CHECKED JUL	SHEET NO. 19 of 99	PP5

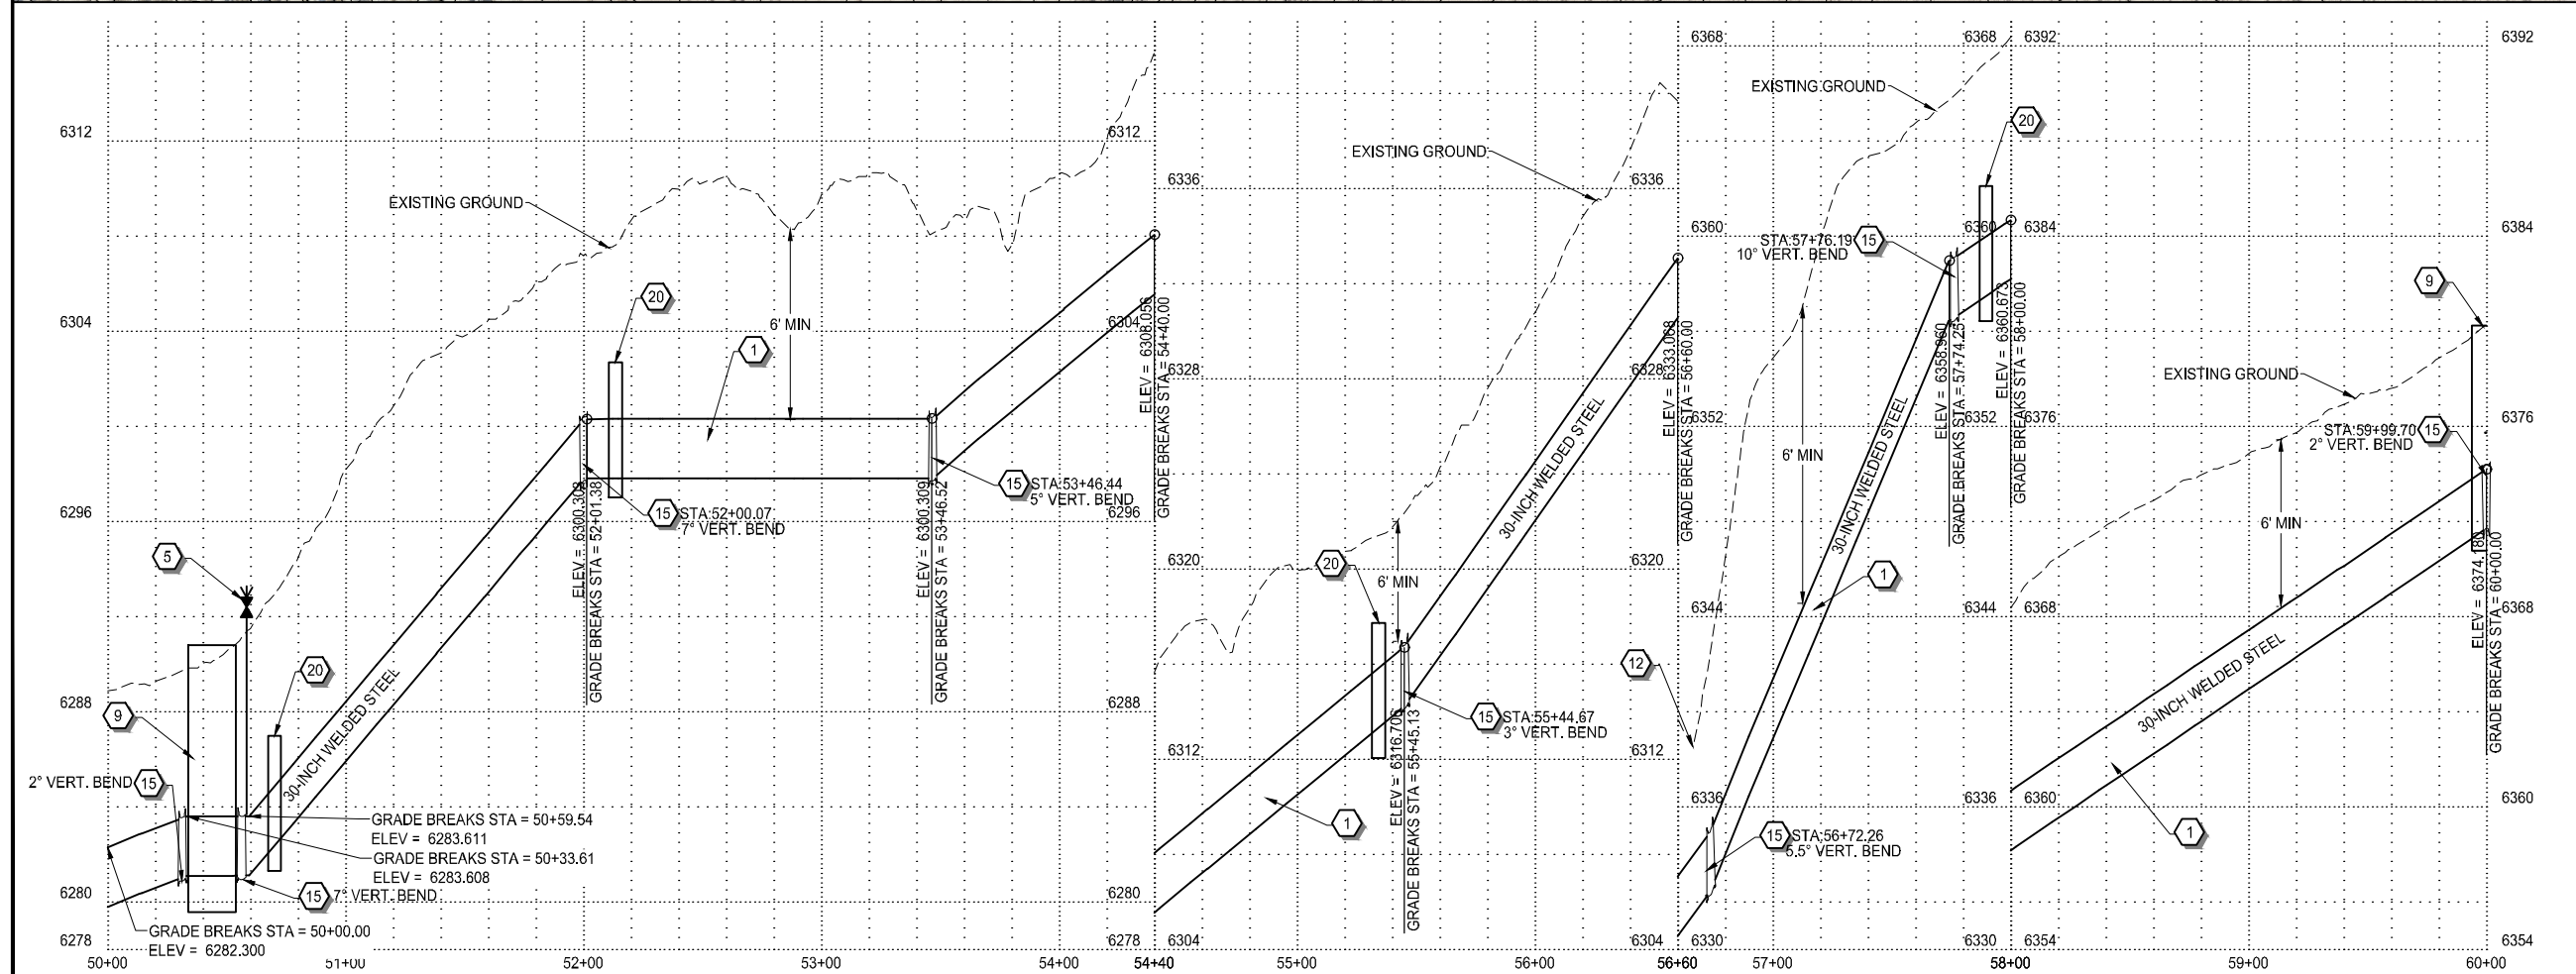
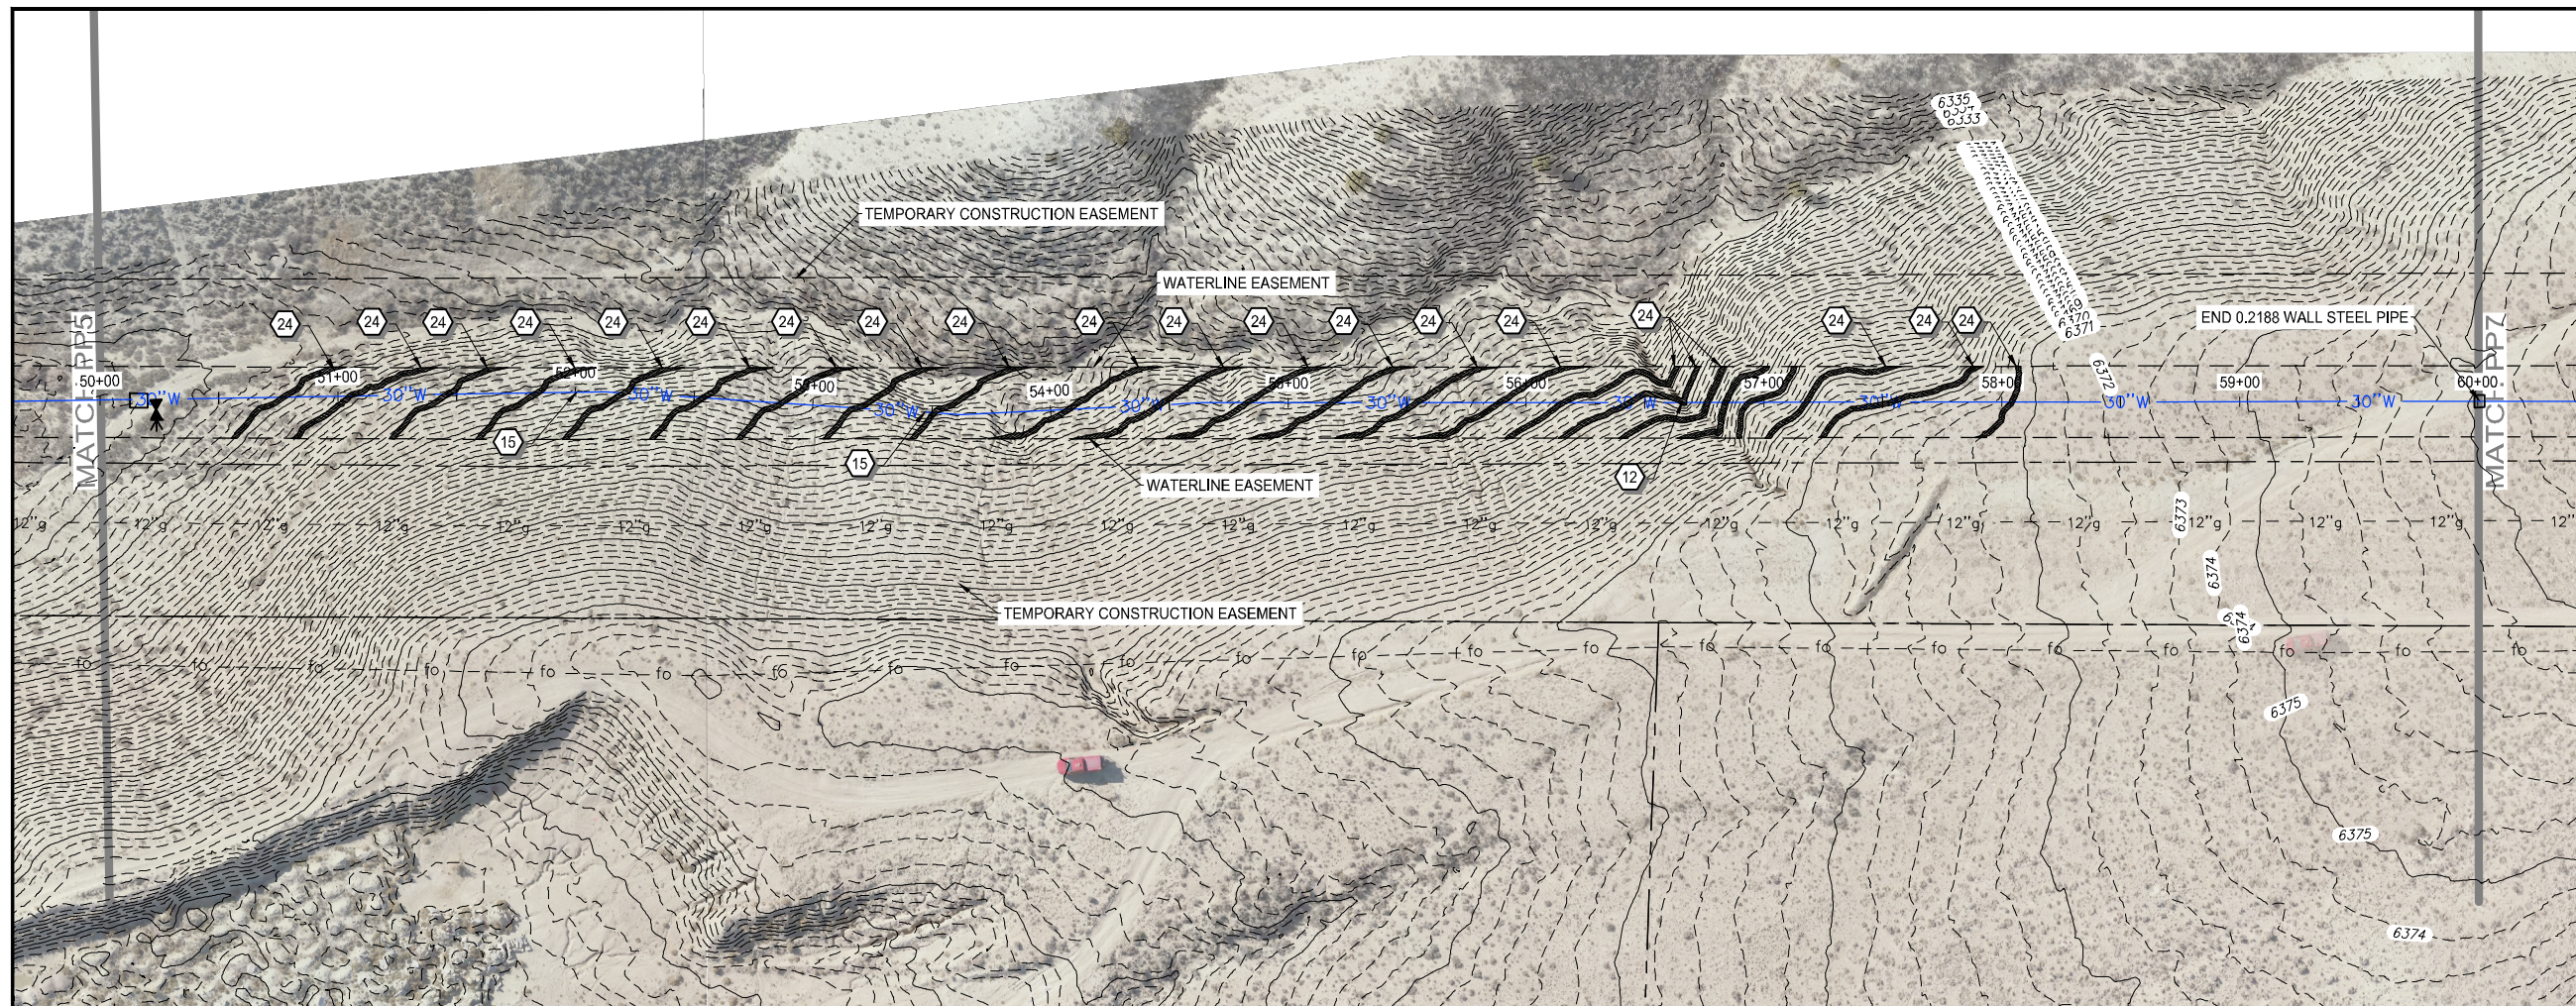


- WATERLINE NOTES:**
- 1 NEW 30" WATERLINE PER (A/D2)(B/D2)
 - 2 CONNECT TO EXISTING 12" WATERLINE PER (C/D8)(D/D8)(E/D8)
 - 3 BEND (90°, 45°, 221/2°, ETC.) WITH THRUST BLOCK. (A/D3)
 - 4 BUTTERLY VALVE PER (C/D2)
 - 5 BLOWOFF ASSEMBLY PER (C/D4)
 - 6 TEE WITH THRUST BLOCK PER (A/D3)
 - 7 CONNECT TO EXISTING 20" WATERLINE PER (A/D1)
 - 8 MANWAY WITH AIRVAC PER (A/D8)(C/D12)
 - 9 MANWAY WITH AIR RELEASE PER (A/D11)(D13)
 - 10 MANWAY PER (A/D10)(A/D12)
 - 11 AIRVAC VALVE PER (C/D10)(C/D12)
 - 12 EPHEMERAL WASH CROSSING PER (A/D4)
 - 13 CONNECT TO EXISTING 18" WATERLINE PER (A/D6)
 - 14 CLAY CUT-OFF WALL PER (A/D5)
 - 15 2-PIECE BEND (A/D3)
 - 16 3-PIECE BEND (A/D3)
 - 17 JIM BRIDGER PIPELINE CROSSING (A/D1)(B/D1)
 - 18 GATE VALVE PER DETAIL (D/D2)
 - 19 WEAK SOILS CROSSING (E/D1)
 - 20 CONCRETE PIPELINE ANCHOR (D/D13)
 - 21 30"x12" CROSS WITH THRUST BLOCK PER (A/D3)
 - 22 CHECK VALVE VAULT (A/D6)(B/D8)
 - 23 EROSION BLANKET PER (F/D10)(G/D10)
 - 24 SEDIMENT LOG/WATTLE PER (A/D16)(B/D16)
 - 25 FIRE HYDRANT PER (E/D5)

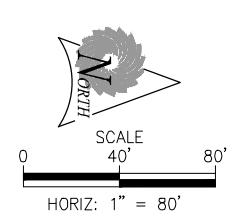


811 Know what's below.
Call before you dig.
1-800-849-2476

REV. NO.	COMMENT	DATE
 SUNRISE ENGINEERING		
770 S WASHINGTON ST. AFTON, WYOMING 83110 TEL 307.885.8500 • FAX 307.885.8501 www.sunrise-eng.com		
GR-RS-SC JPWB		
CROSSROADS PUMP STATION		
PLAN AND PROFILE		
SEI NO. 07265	DESIGNED FDK	DRAWN BJ
CHECKED JUL	SHEET NO. 20 of 99	PP6

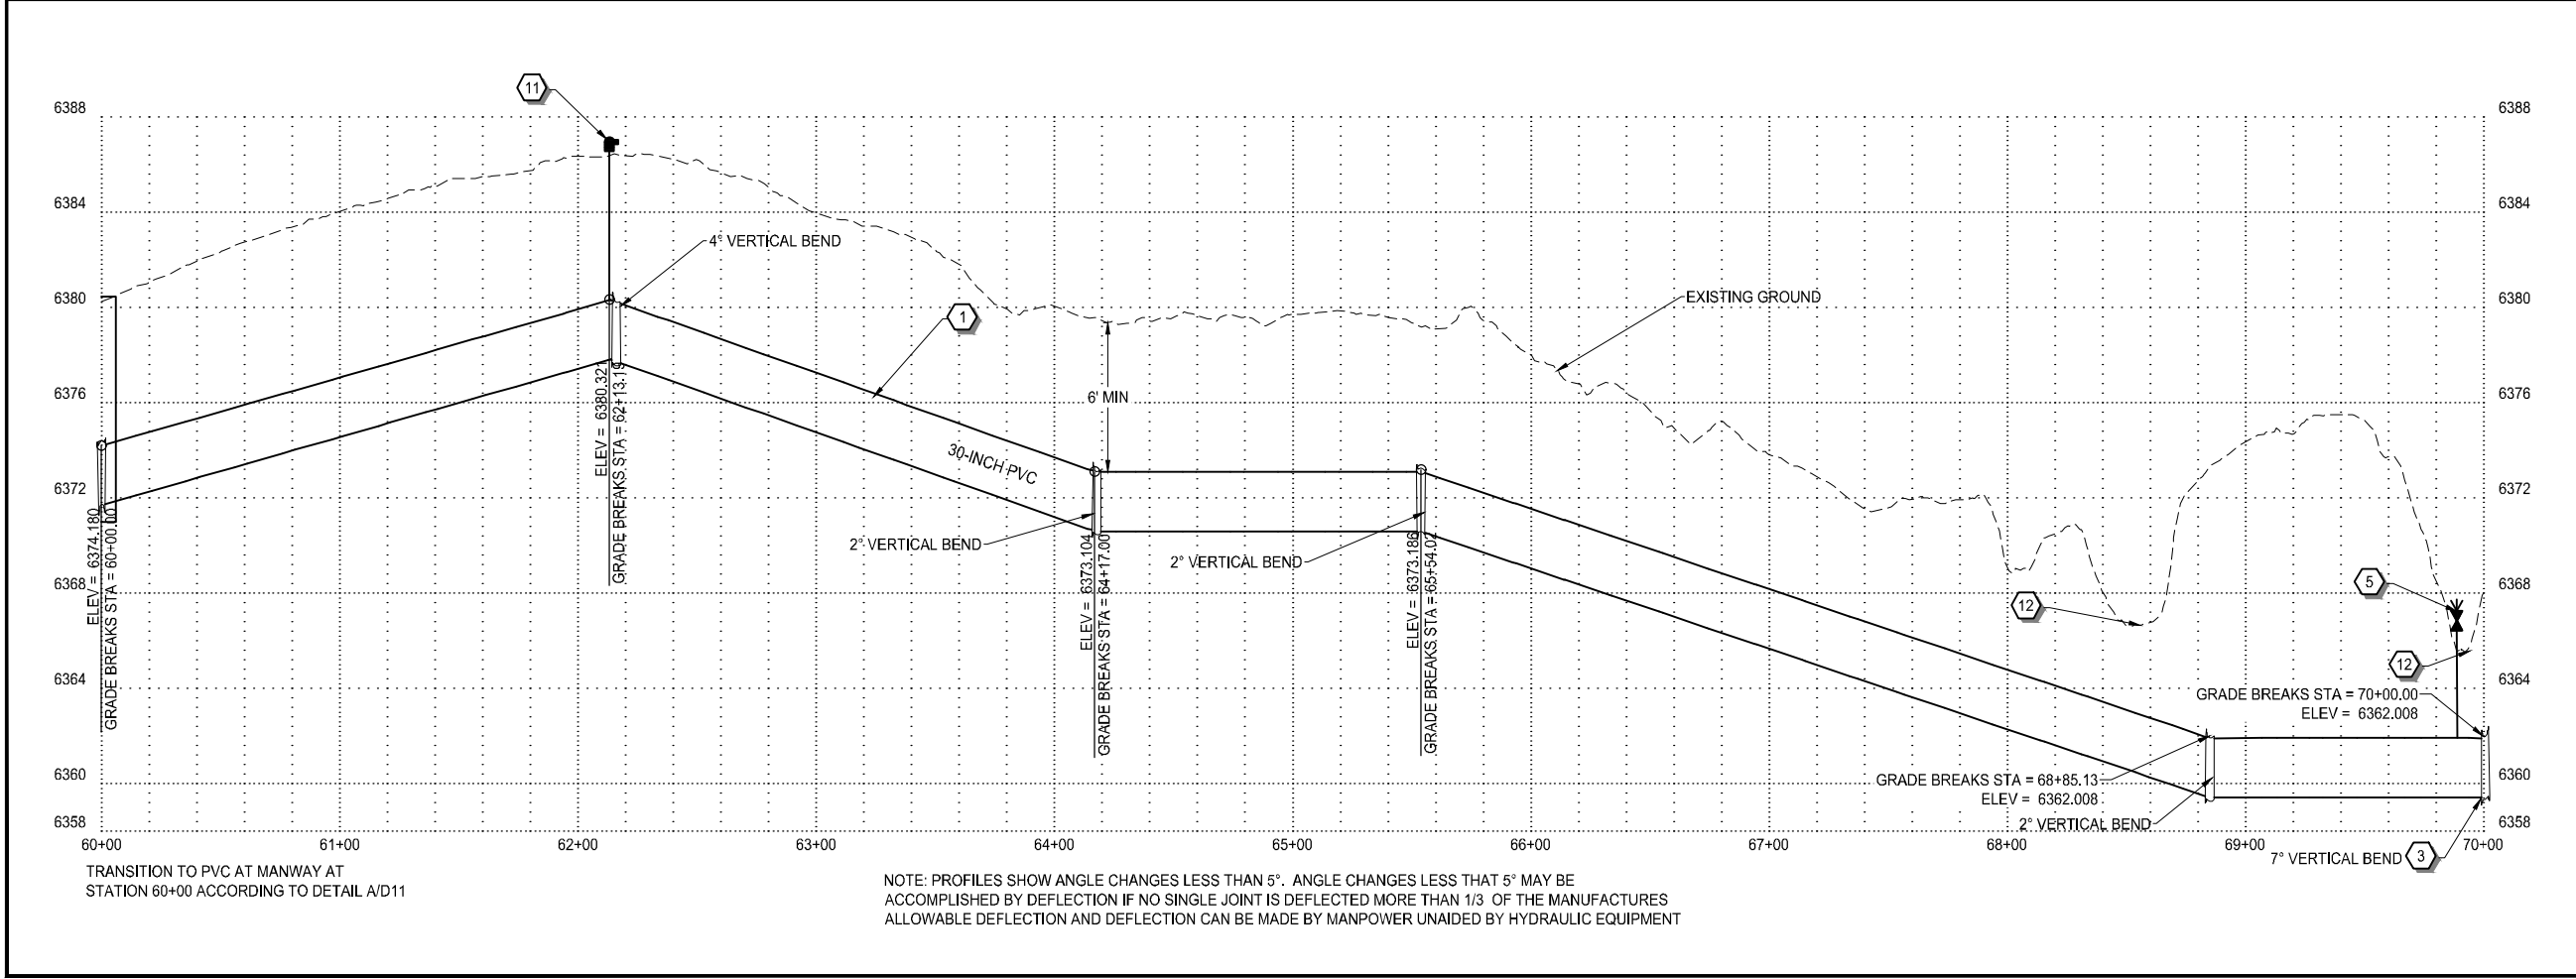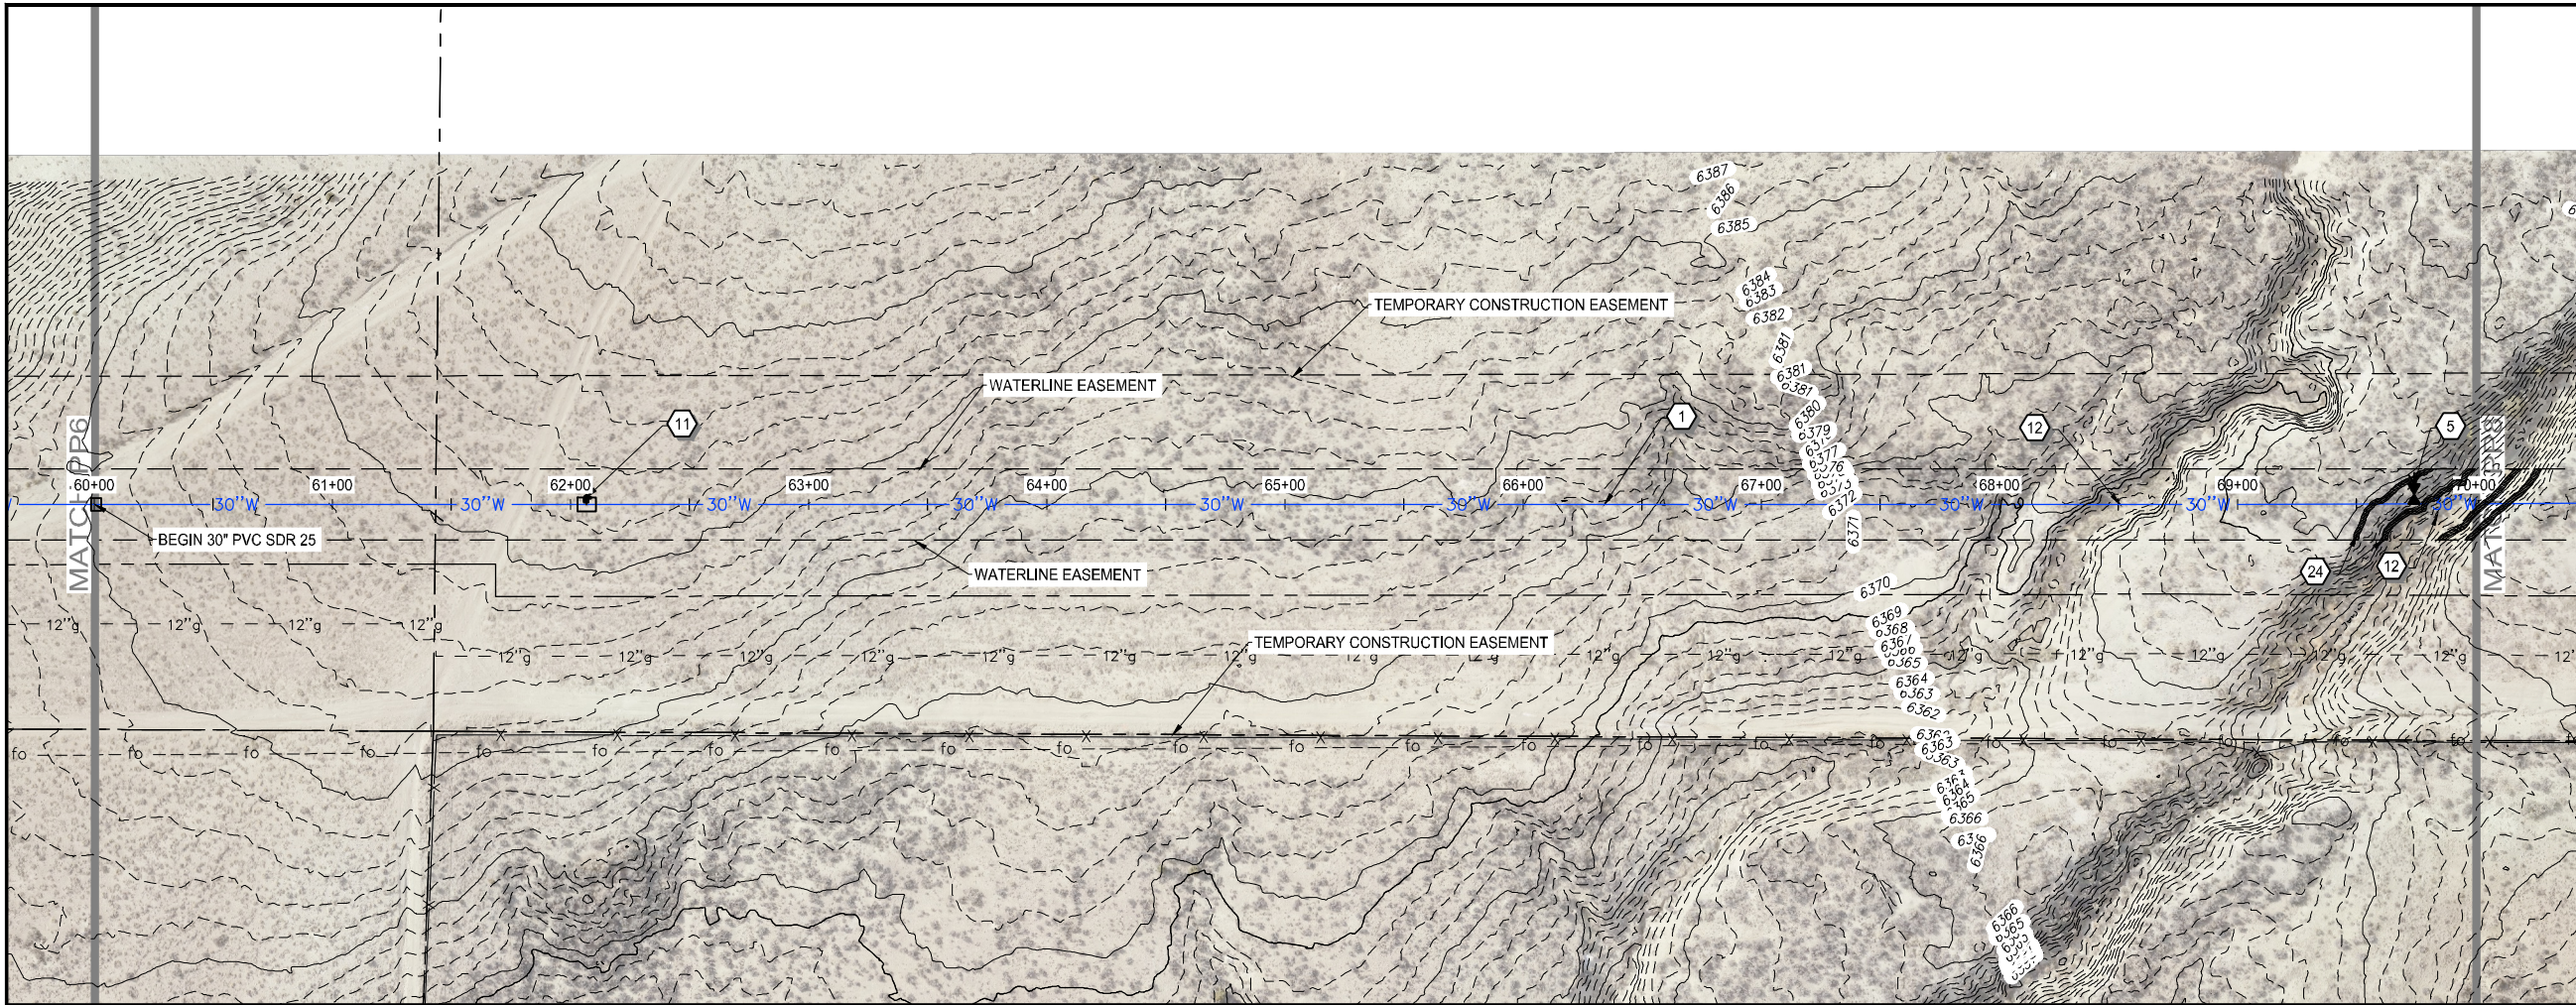

WATERLINE NOTES:


 
- 1 NEW 30" WATERLINE PER (A/D2) (B/D2)
- 2 CONNECT TO EXISTING 12" WATERLINE PER (C/D8) (D/D8) (E/D8)
- 3 BEND (90°, 45°, 221/2°, ETC.) WITH THRUST BLOCK. (A/D3)
- 4 BUTTERLY VALVE PER (C/D7)
- 5 BLOWOFF ASSEMBLY PER (C/D4)
- 6 TEE WITH THRUST BLOCK PER (A/D3)
- 7 CONNECT TO EXISTING 20" WATERLINE PER (A/D1)
- 8 MANWAY WITH AIRVAC PER (A/D8) (C/D7)
- 9 MANWAY WITH AIR RELEASE PER (A/D1) (D13)
- 10 MANWAY PER (A/D10) (A/D12)
- 11 AIRVAC VALVE PER (C/D10) (C/D12)
- 12 EPHEMERAL WASH CROSSING PER (A/D4)
- 13 CONNECT TO EXISTING 18" WATERLINE PER (A/D8)
- 14 CLAY CUT-OFF WALL PER (A/D5)
- 15 2-PIECE BEND (A/D3)
- 16 3-PIECE BEND (A/D3)
- 17 JIM BRIDGER PIPELINE CROSSING (A/D1) (B/D1)
- 18 GATE VALVE PER DETAIL (D/D7)
- 19 WEAK SOILS CROSSING (E/D1)
- 20 CONCRETE PIPELINE ANCHOR (D/D13)
- 21 30"x12" CROSS WITH THRUST BLOCK PER (A/D3)
- 22 CHECK VALVE VAULT (A/D8) (B/D8)
- 23 EROSION BLANKET PER (E/D10) (G/D10)
- 24 SEDIMENT LOG/WATTLE PER (A/D16) (B/D16)
- 25 FIRE HYDRANT PER (E/D5)



SCALE
0 40' 80'
HORIZ: 1" = 80'



811 Know what's below.
Call before you dig.
1-800-849-2476

REV NO.	COMMENT	DATE
 SUNRISE ENGINEERING		
770 S WASHINGTON ST. AFTON, WYOMING 83110 TEL 307.885.8500 • FAX 307.885.8501 www.sunrise-eng.com		
GR-RS-SC JPWB		
CROSSROADS PUMP STATION		
PLAN AND PROFILE		
SEI NO. 07265	DESIGNED FDK	DRAWN BJ
CHECKED JUL	SHEET NO. 21 of 99	PP7

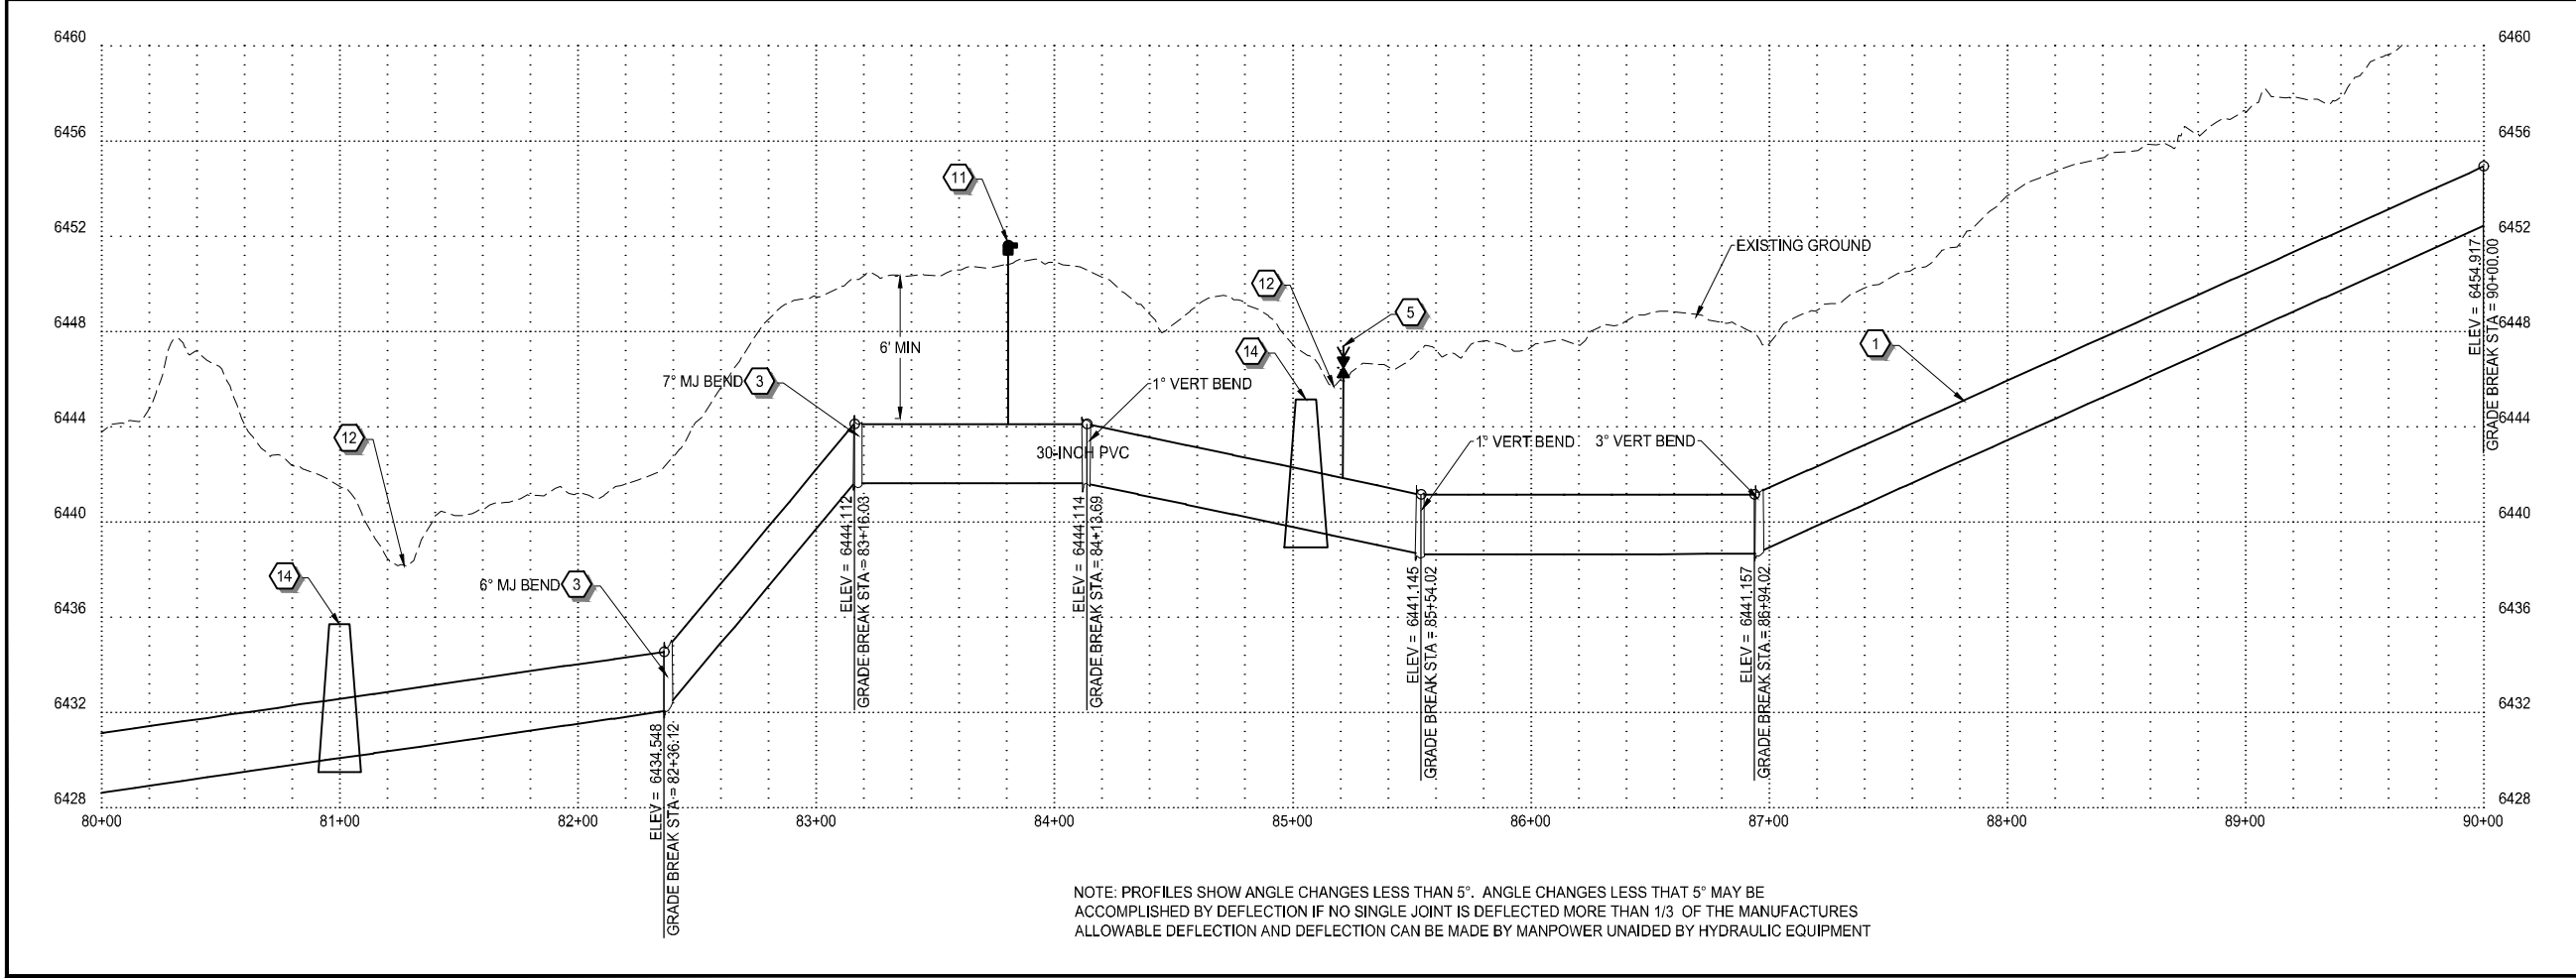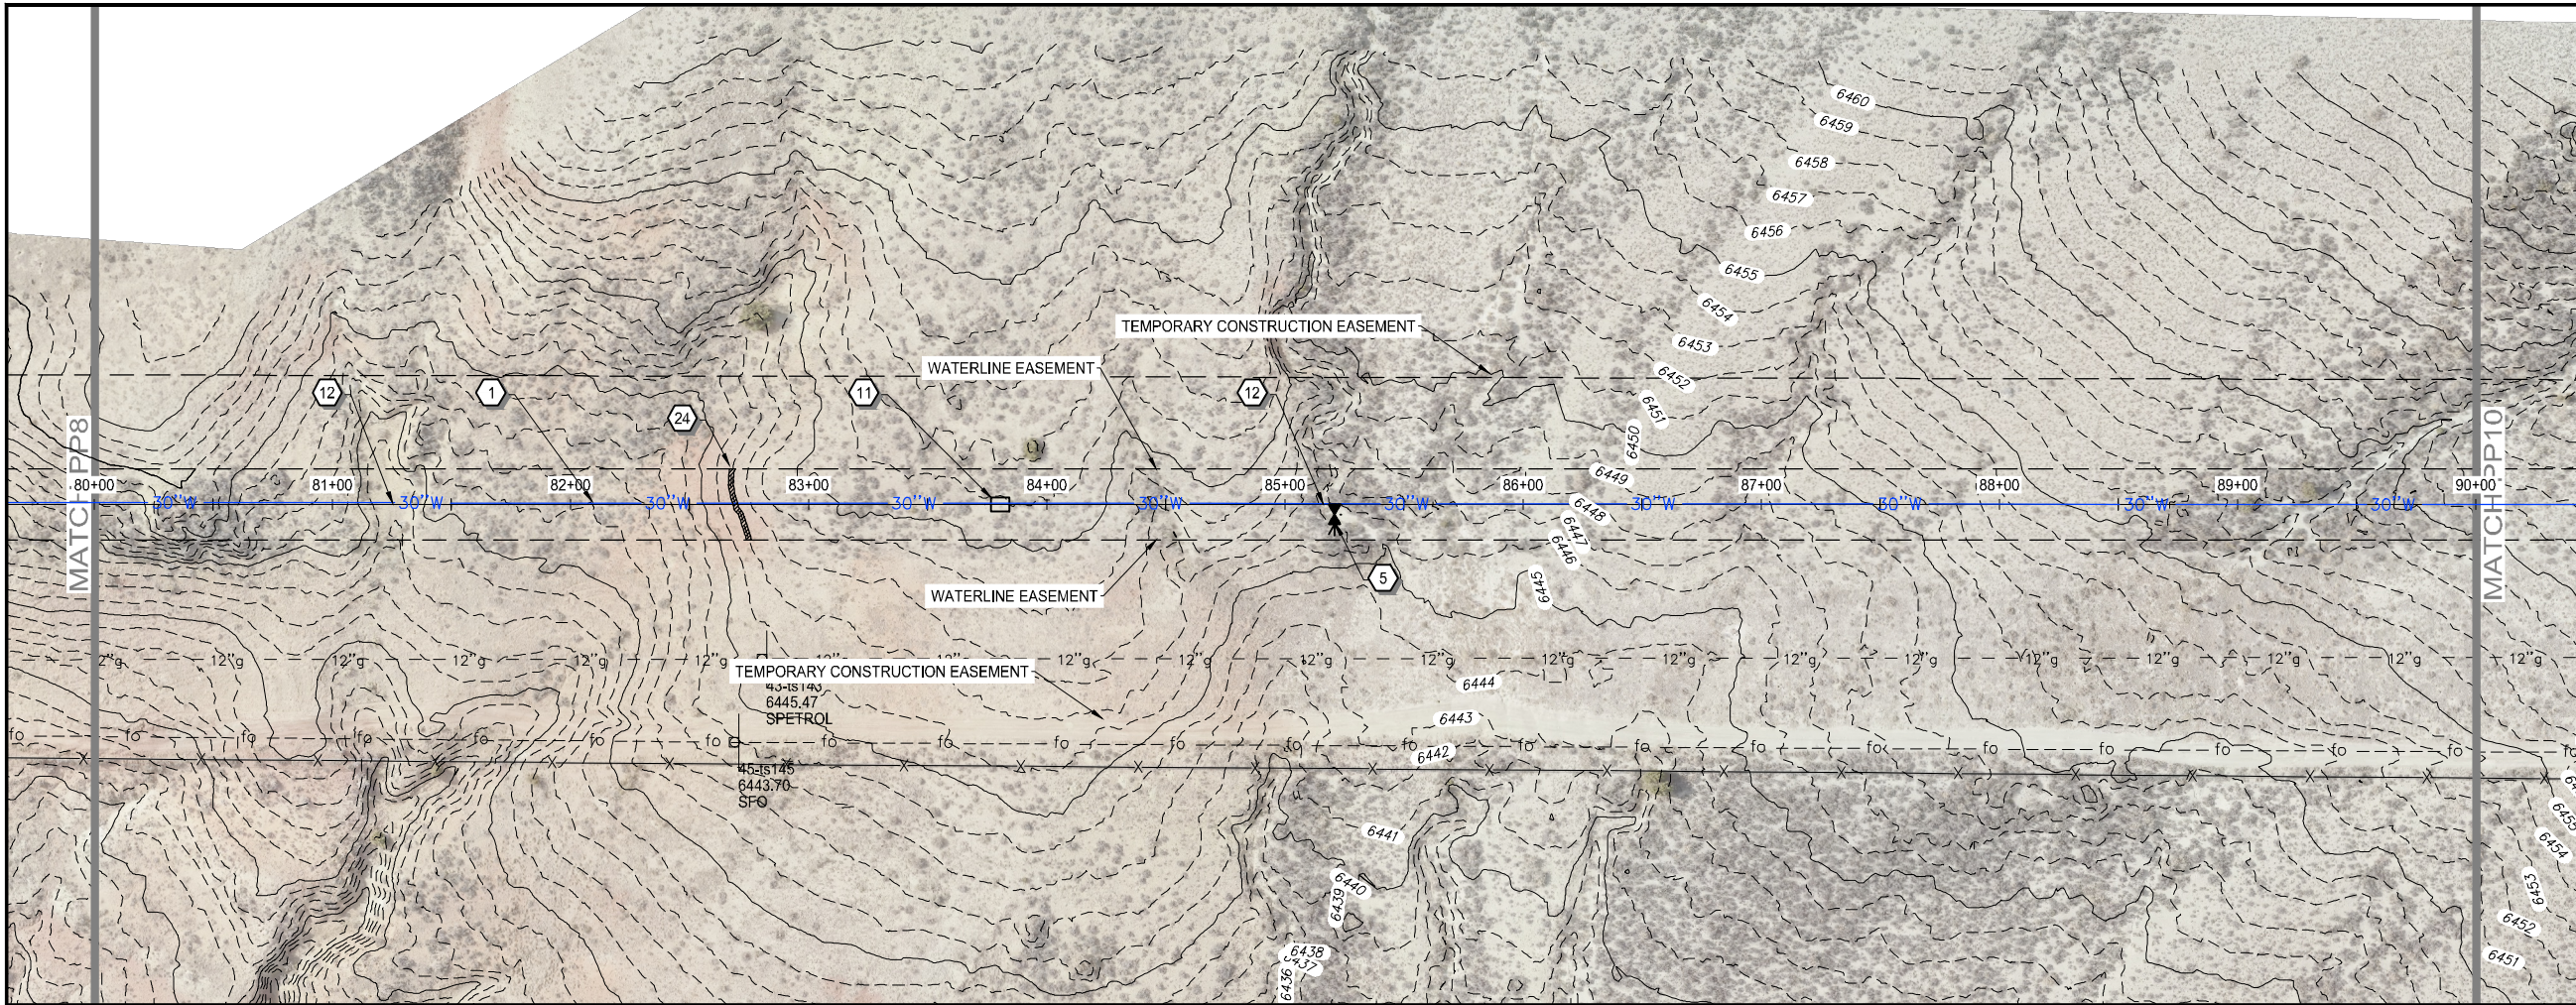

WATERLINE NOTES:

  - 1 NEW 30" WATERLINE PER (A/D2) (B/D2)
- 2 CONNECT TO EXISTING 12" WATERLINE PER (C/D8) (D/D8) (E/D8)
- 3 BEND (90°, 45°, 221/2°, ETC.) WITH THRUST BLOCK. (A/D3)
- 4 BUTTERLY VALVE PER (C/D2)
- 5 BLOWOFF ASSEMBLY PER (C/D4)
- 6 TEE WITH THRUST BLOCK PER (A/D3)
- 7 CONNECT TO EXISTING 20" WATERLINE PER (A/D1)
- 8 MANWAY WITH AIRVAC PER (A/D8) (C/D7)
- 9 MANWAY WITH AIR RELEASE PER (A/D11) (B/D13)
- 10 MANWAY PER (A/D10) (A/D12)
- 11 AIRVAC VALVE PER (C/D10) (C/D12)
- 12 EPHEMERAL WASH CROSSING PER (A/D4)
- 13 CONNECT TO EXISTING 18" WATERLINE PER (A/D8)
- 14 CLAY CUT-OFF WALL PER (A/D5)
- 15 2-PIECE BEND (A/D3)
- 16 3-PIECE BEND (A/D3)
- 17 JIM BRIDGER PIPELINE CROSSING (A/D1) (B/D1)
- 18 GATE VALVE PER DETAIL (D/D2)
- 19 WEAK SOILS CROSSING (E/D1)
- 20 CONCRETE PIPELINE ANCHOR (D/D13)
- 21 30"x12" CROSS WITH THRUST BLOCK PER (A/D3)
- 22 CHECK VALVE VAULT (A/D8) (B/D8)
- 23 EROSION BLANKET PER (E/D10) (G/D10)
- 24 SEDIMENT LOG/WATTLE PER (A/D16) (B/D16)
- 25 FIRE HYDRANT PER (E/D5)





Know what's below.
Call before you dig.
1-800-849-2476




770 S WASHINGTON ST.
AFTON, WYOMING 83110
TEL 307.885.8500 • FAX 307.885.8501
www.sunrise-eng.com

GR-RS-SC JPWB
CROSSROADS PUMP STATION


PLAN AND PROFILE

SEI NO. 07265	DESIGNED FDK	DRAWN BJ	CHECKED JUL	SHEET NO. 23 of 99	PP9
------------------	-----------------	-------------	----------------	-----------------------	-----

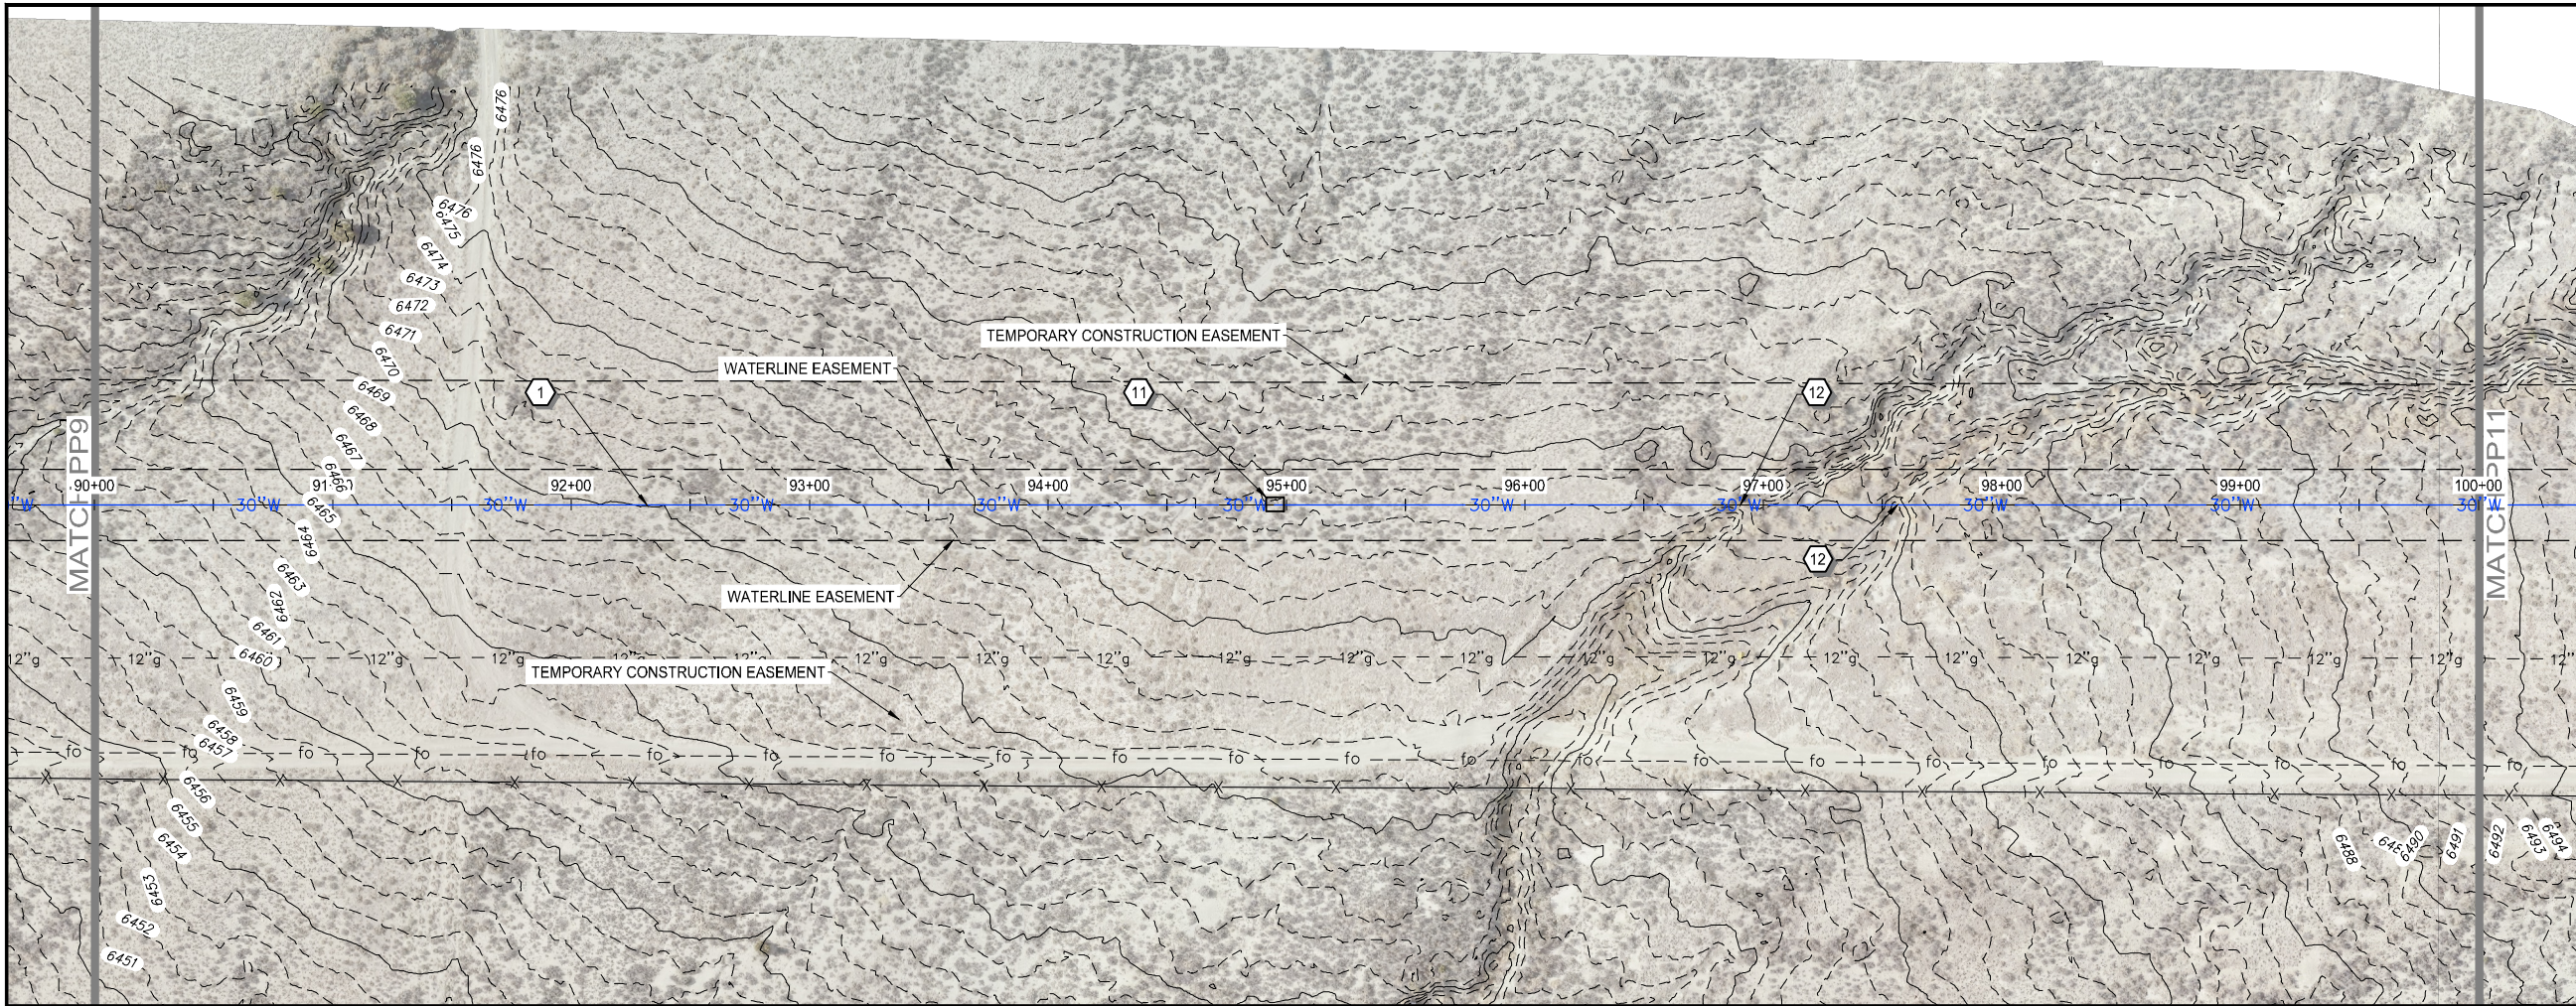


WATERLINE NOTES:

- 1 NEW 30" WATERLINE PER (A/D2) (B/D2)
- 2 CONNECT TO EXISTING 12" WATERLINE PER (C/D8) (D/D8) (E/D8)
- 3 BEND (90°, 45°, 221/2°, ETC.) WITH THRUST BLOCK. (A/D3)
- 4 BUTTERLY VALVE PER (C/D2)
- 5 BLOWOFF ASSEMBLY PER (C/D4)
- 6 TEE WITH THRUST BLOCK PER (A/D3)
- 7 CONNECT TO EXISTING 20" WATERLINE PER (A/D1)
- 8 MANWAY WITH AIRVAC PER (A/D8) (C/D7)
- 9 MANWAY WITH AIR RELEASE PER (A/D11) (D13)
- 10 MANWAY PER (A/D10) (A/D12)
- 11 AIRVAC VALVE PER (C/D10) (C/D12)
- 12 EPHEMERAL WASH CROSSING PER (A/D4)
- 13 CONNECT TO EXISTING 18" WATERLINE PER (A/D6)
- 14 CLAY CUT-OFF WALL PER (A/D5)
- 15 2-PIECE BEND (A/D3)
- 16 3-PIECE BEND (A/D3)
- 17 JIM BRIDGER PIPELINE CROSSING (A/D1) (B/D1)
- 18 GATE VALVE PER DETAIL (D/D2)
- 19 WEAK SOILS CROSSING (E/D1)
- 20 CONCRETE PIPELINE ANCHOR (D/D13)
- 21 30"x12" CROSS WITH THRUST BLOCK PER (A/D3)
- 22 CHECK VALVE VAULT (A/D6) (B/D8)
- 23 EROSION BLANKET PER (E/D10) (G/D10)
- 24 SEDIMENT LOG/WATTLE PER (A/D16) (B/D16)
- 25 FIRE HYDRANT PER (E/D5)

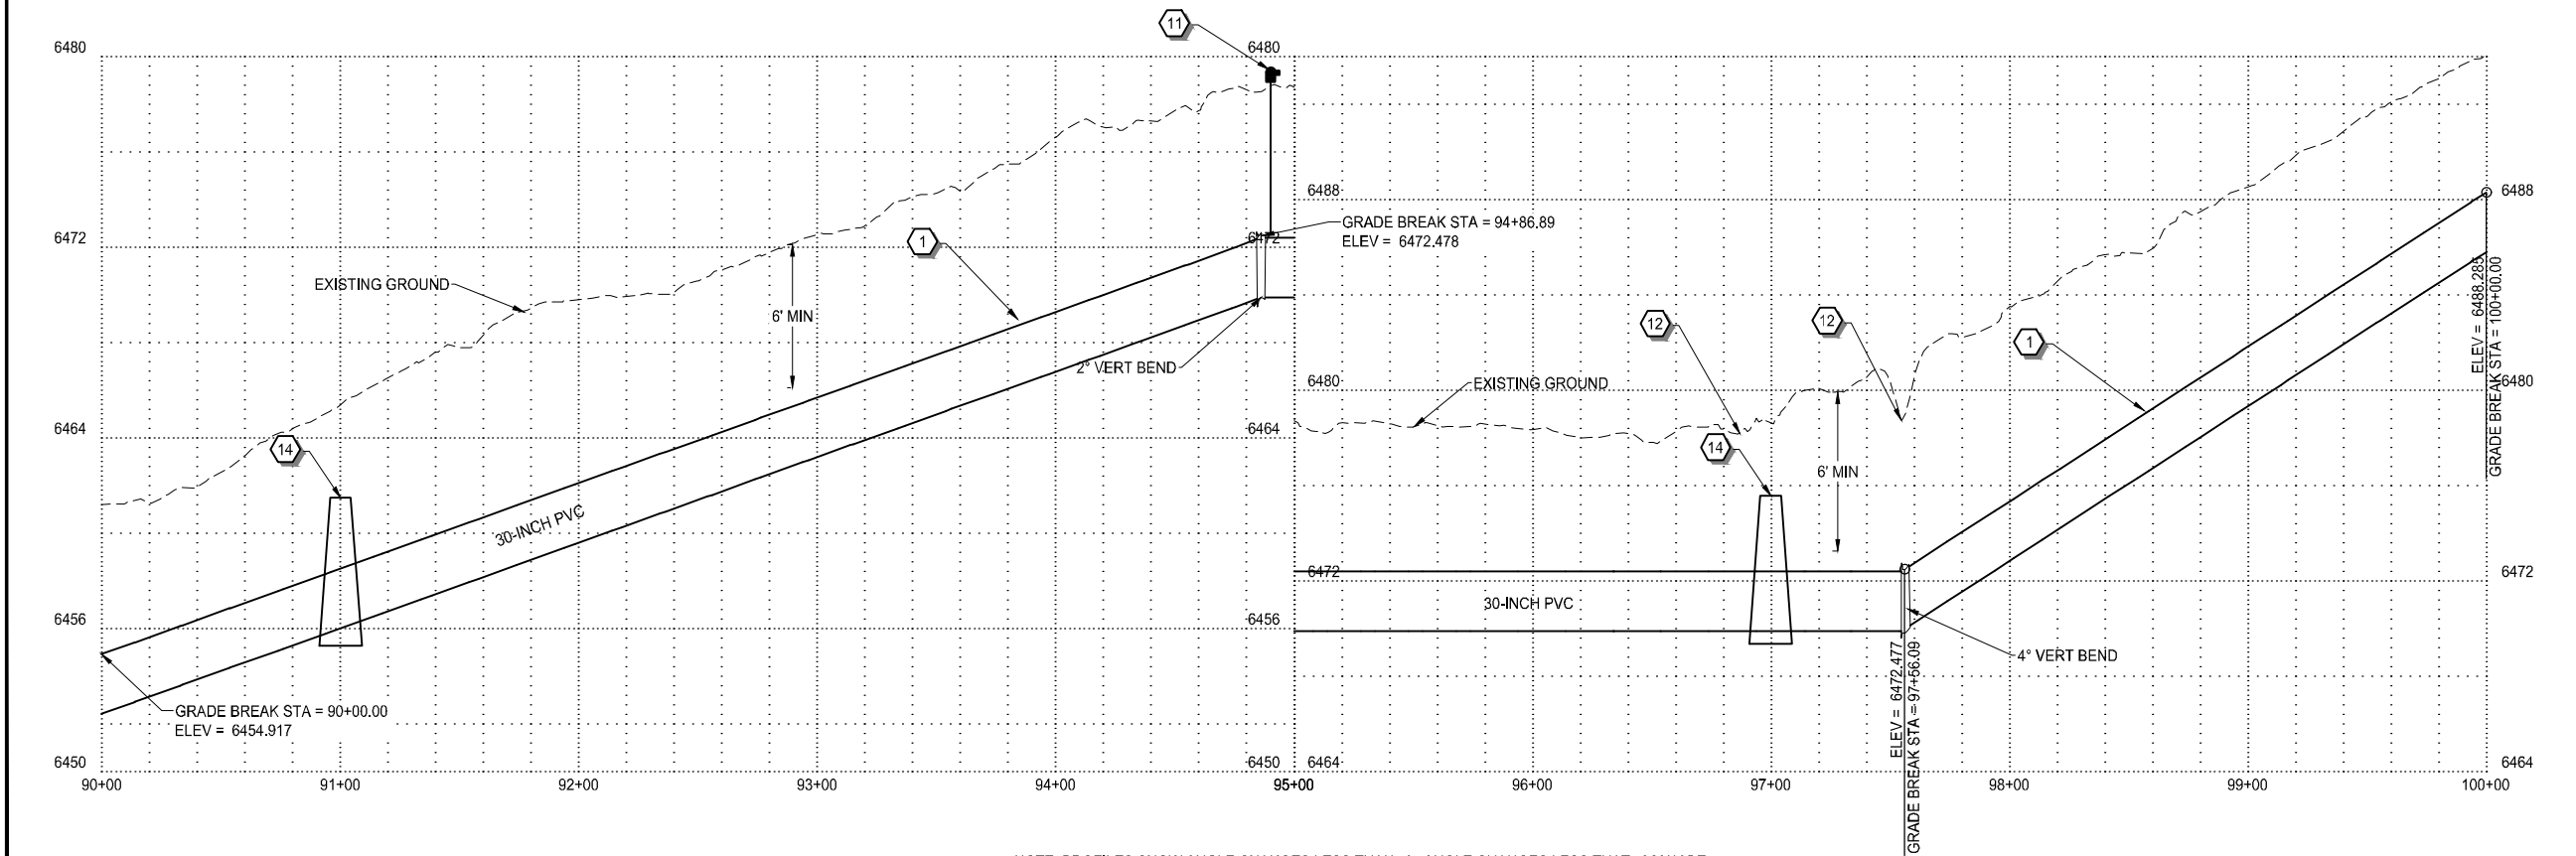

 NOTE: PROFILES SHOW ANGLE CHANGES LESS THAN 5°. ANGLE CHANGES LESS THAT 5° MAY BE ACCOMPLISHED BY DEFLECTION IF NO SINGLE JOINT IS DEFLECTED MORE THAN 1/3 OF THE MANUFACTURES ALLOWABLE DEFLECTION AND DEFLECTION CAN BE MADE BY MANPOWER UNAIDED BY HYDRAULIC EQUIPMENT



SCALE
0 40' 80'
HORIZ: 1" = 80'

811 Know what's below.
Call before you dig.
1-800-849-2476




770 S WASHINGTON ST.
AFTON, WYOMING 83110
TEL 307.885.8500 • FAX 307.885.8501
www.sunrise-eng.com

GR-RS-SC JPWB
CROSSROADS PUMP STATION



PLAN AND PROFILE

SEI NO.	DESIGNED	DRAWN	CHECKED	SHEET NO.	
07265	FDK	BJ	JLL	24 of 99	PP10

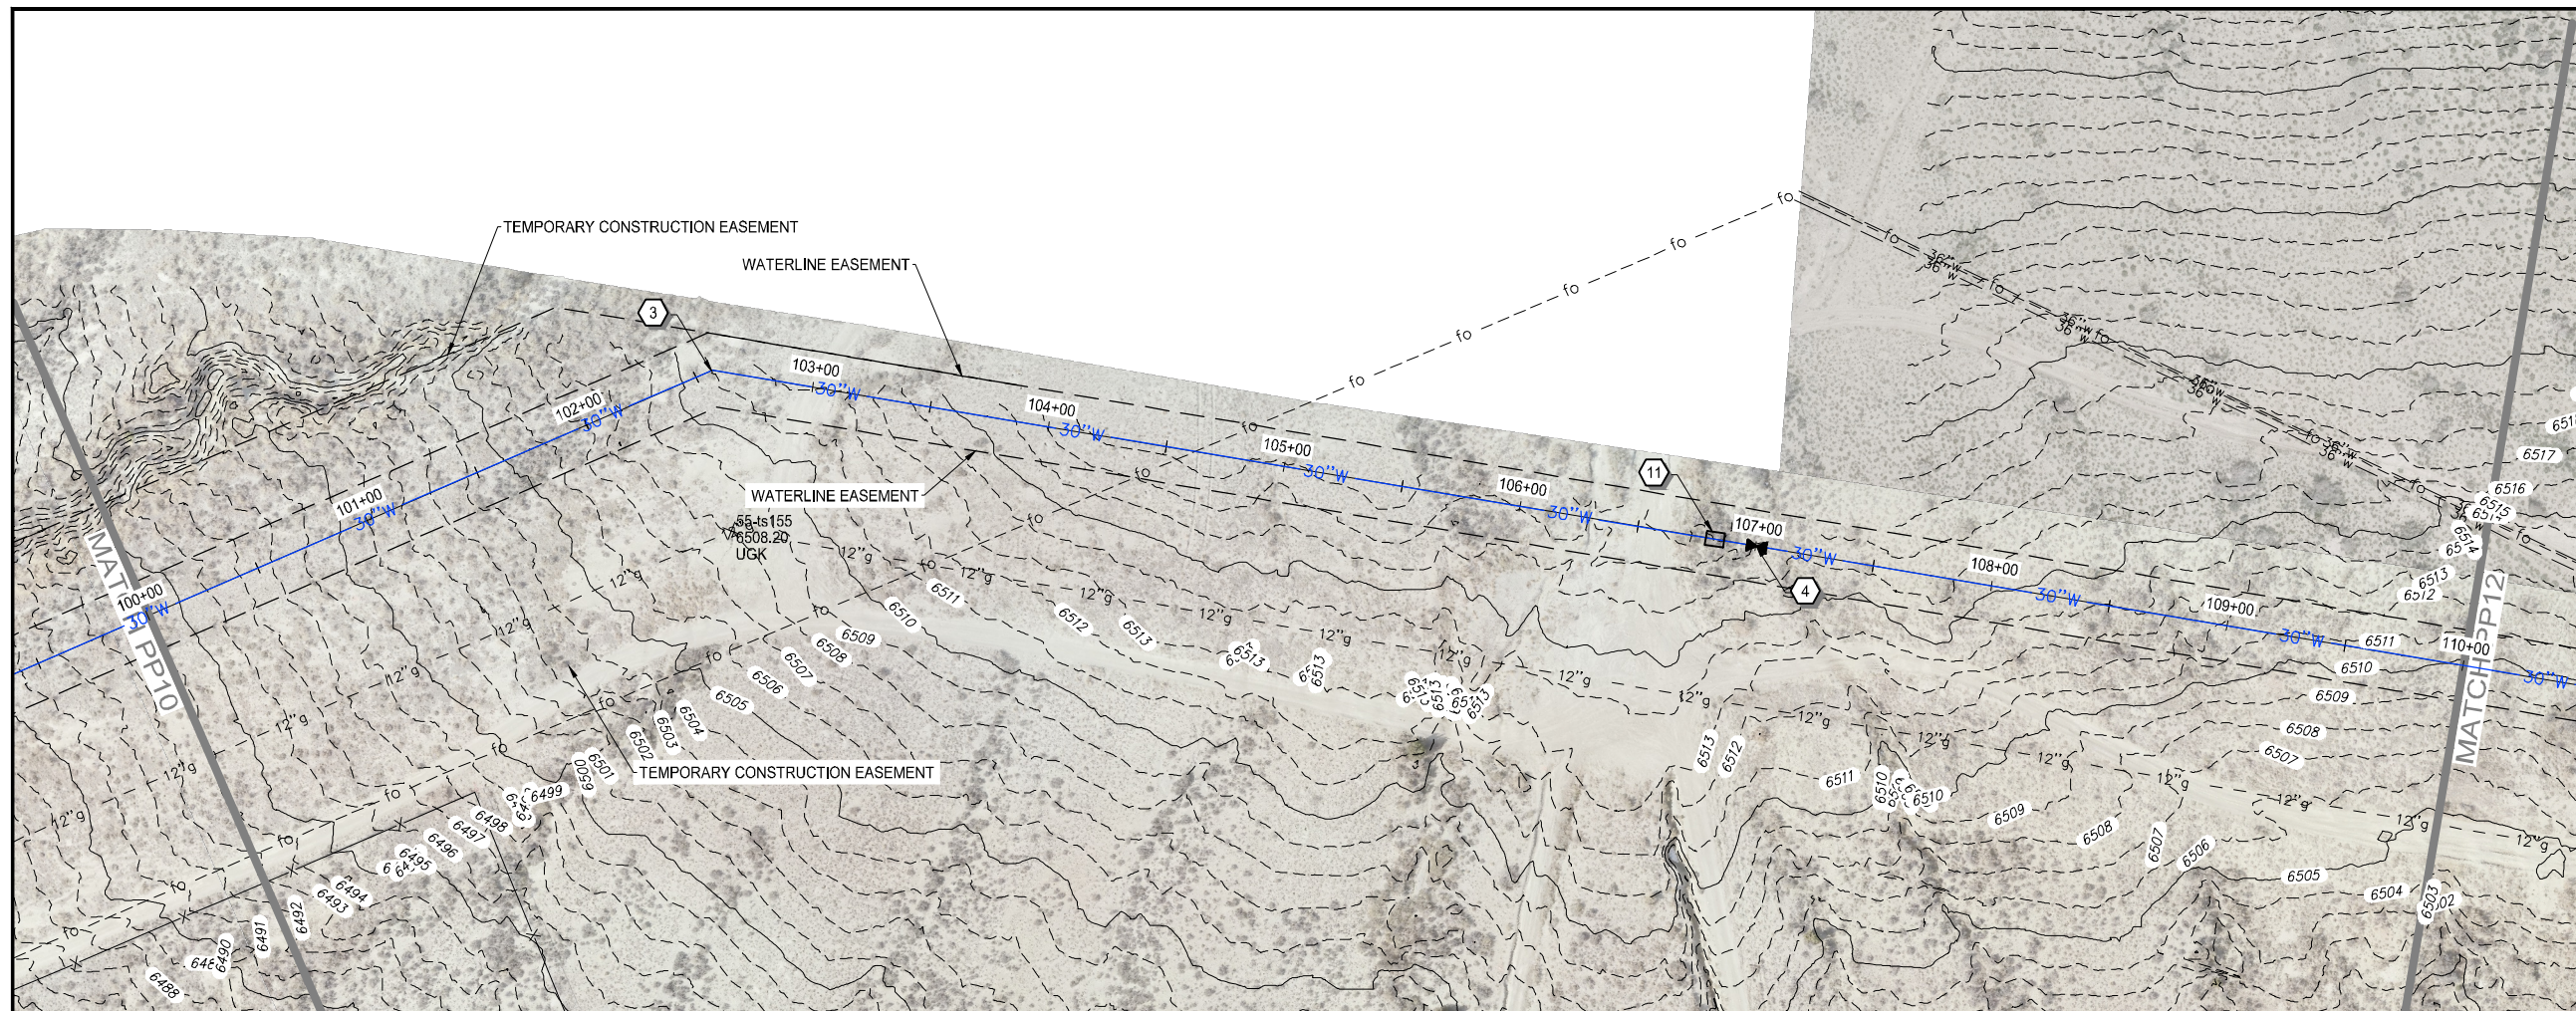

WATERLINE NOTES:

- 1 NEW 30" WATERLINE PER (A/D2) (B/D2)
- 2 CONNECT TO EXISTING 12" WATERLINE PER (C/D8) (D/D8) (E/D8)
- 3 BEND (90°, 45°, 221/2°, ETC.) WITH THRUST BLOCK. (A/D3)
- 4 BUTTERLY VALVE PER (C/D2)
- 5 BLOWOFF ASSEMBLY PER (C/D4)
- 6 TEE WITH THRUST BLOCK PER (A/D3)
- 7 CONNECT TO EXISTING 20" WATERLINE PER (A/D1)
- 8 MANWAY WITH AIRVAC PER (A/D8) (C/D7)
- 9 MANWAY WITH AIR RELEASE PER (A/D11) (A/D13)
- 10 MANWAY PER (A/D10) (A/D12)
- 11 AIRVAC VALVE PER (C/D10) (C/D12)
- 12 EPHEMERAL WASH CROSSING PER (A/D4)
- 13 CONNECT TO EXISTING 18" WATERLINE PER (A/D8)
- 14 CLAY CUT-OFF WALL PER (A/D5)
- 15 2-PIECE BEND (A/D3)
- 16 3-PIECE BEND (A/D3)
- 17 JIM BRIDGER PIPELINE CROSSING (A/D1) (B/D1)
- 18 GATE VALVE PER DETAIL (D/D2)
- 19 WEAK SOILS CROSSING (E/D1)
- 20 CONCRETE PIPELINE ANCHOR (D/D13)
- 21 30"x12" CROSS WITH THRUST BLOCK PER (A/D3)
- 22 CHECK VALVE VAULT (A/D8) (B/D8)
- 23 EROSION BLANKET PER (E/D10) (G/D10)
- 24 SEDIMENT LOG/WATTLE PER (A/D16) (B/D16)
- 25 FIRE HYDRANT PER (E/D5)

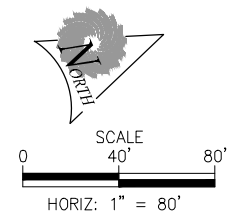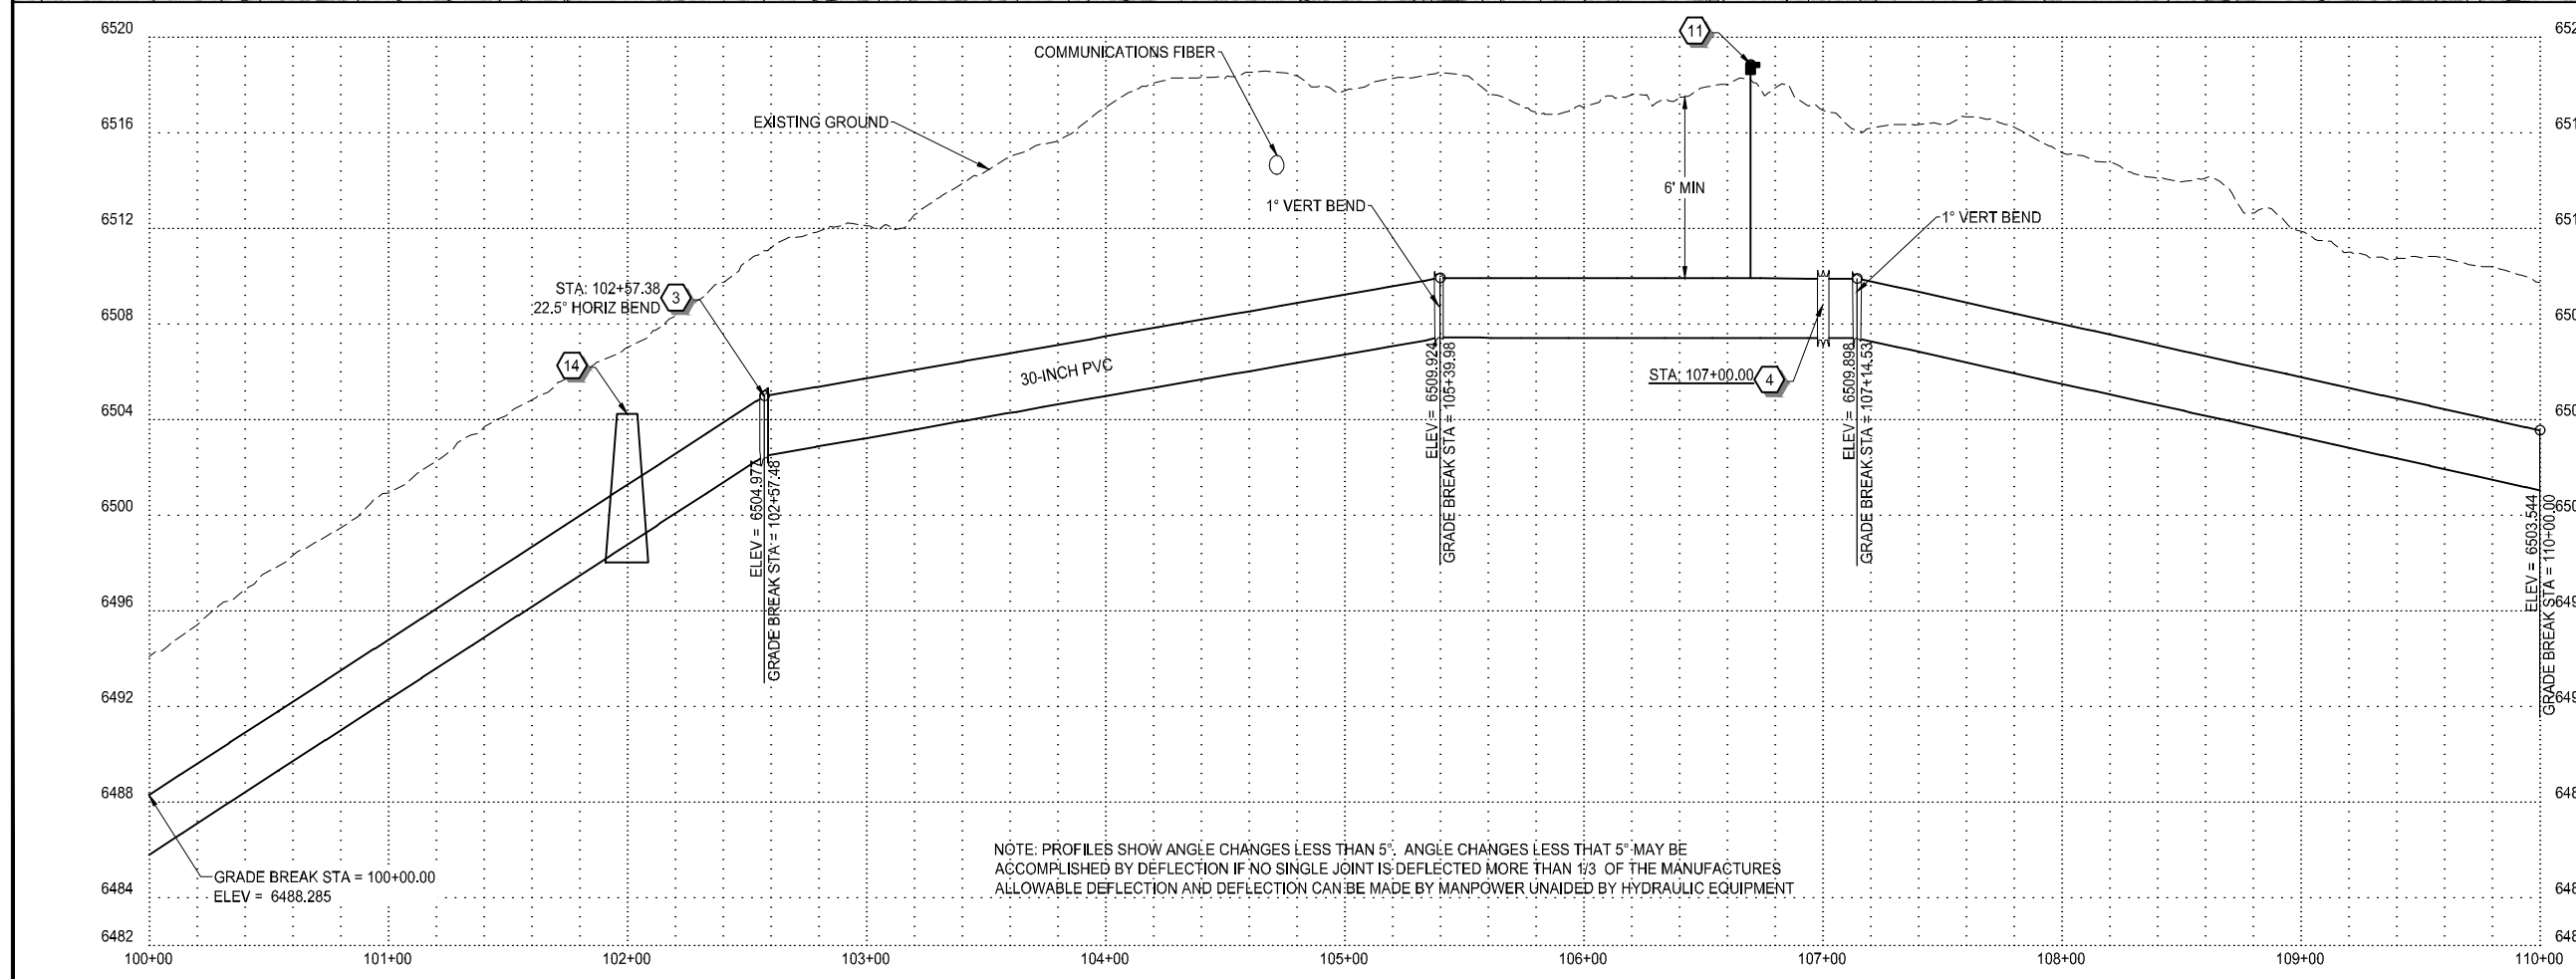

811 Know what's below.
Call before you dig.
1-800-849-2476




770 S WASHINGTON ST.
AFTON, WYOMING 83110
TEL 307.885.8500 • FAX 307.885.8501
www.sunrise-eng.com

GR-RS-SC JPWB
CROSSROADS PUMP STATION


PLAN AND PROFILE

SEI NO. 07265	DESIGNED FDK	DRAWN BJ	CHECKED JUL	SHEET NO. 25 of 99	PP11
------------------	-----------------	-------------	----------------	-----------------------	------

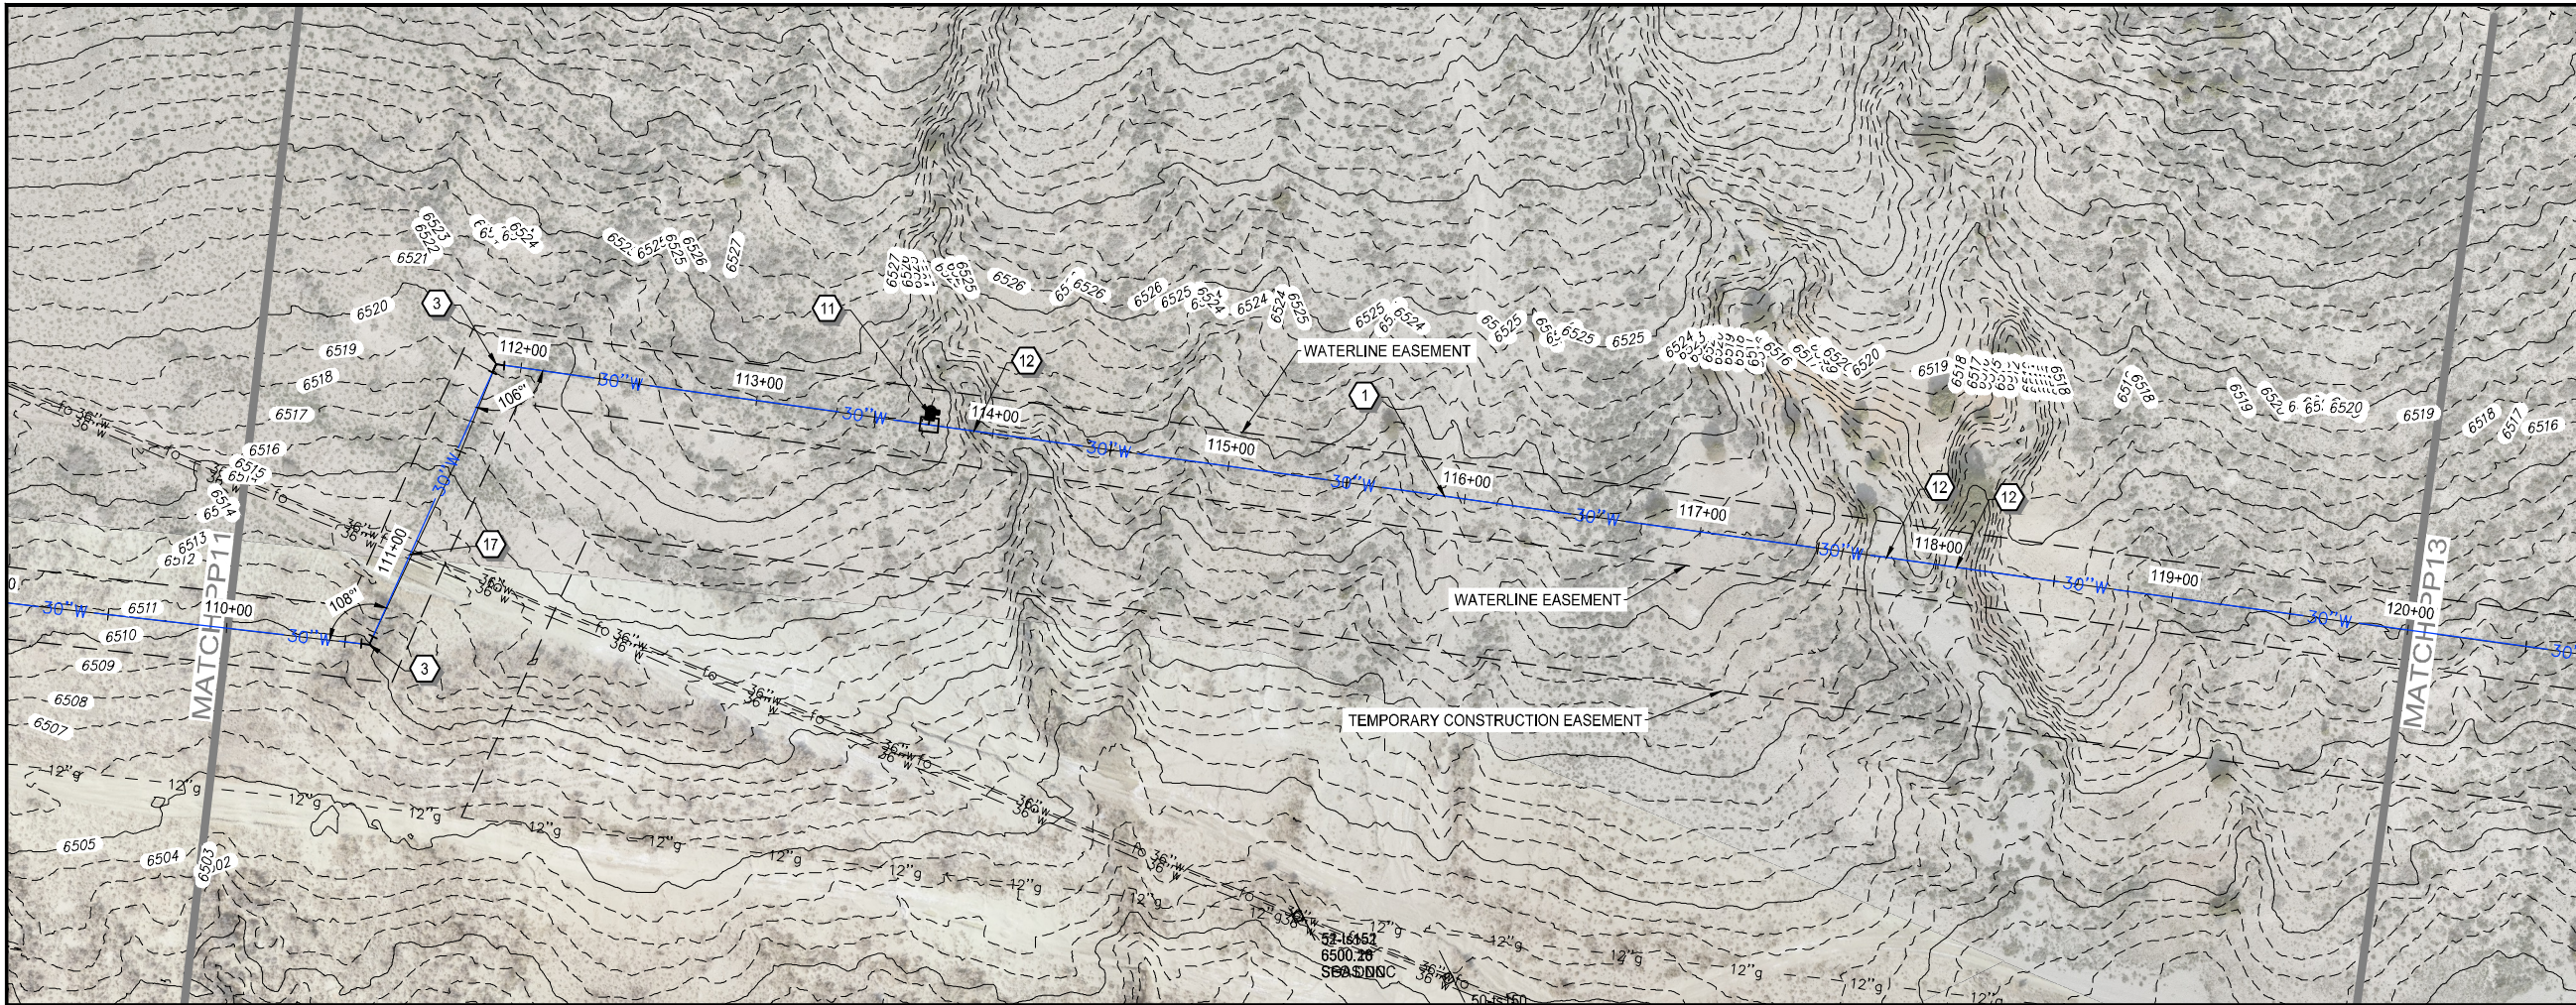


WATERLINE NOTES:

- 1 NEW 30" WATERLINE PER (A/D2) (B/D2)
- 2 CONNECT TO EXISTING 12" WATERLINE PER (C/D8) (D/D8) (E/D8)
- 3 BEND (90°, 45°, 221/2°, ETC.) WITH THRUST BLOCK. (A/D3)
- 4 BUTTERLY VALVE PER (C/D2)
- 5 BLOWOFF ASSEMBLY PER (C/D4)
- 6 TEE WITH THRUST BLOCK PER (A/D3)
- 7 CONNECT TO EXISTING 20" WATERLINE PER (A/D1)
- 8 MANWAY WITH AIRVAC PER (A/D8) (C/D7)
- 9 MANWAY WITH AIR RELEASE PER (A/D11) (B/D13)
- 10 MANWAY PER (A/D10) (A/D12)
- 11 AIRVAC VALVE PER (C/D10) (C/D12)
- 12 EPHEMERAL WASH CROSSING PER (A/D4)
- 13 CONNECT TO EXISTING 18" WATERLINE PER (A/D6)
- 14 CLAY CUT-OFF WALL PER (A/D5)
- 15 2-PIECE BEND (A/D3)
- 16 3-PIECE BEND (A/D3)
- 17 JIM BRIDGER PIPELINE CROSSING (A/D1) (B/D1)
- 18 GATE VALVE PER DETAIL (D/D2)
- 19 WEAK SOILS CROSSING (E/D1)
- 20 CONCRETE PIPELINE ANCHOR (D/D13)
- 21 30"x12" CROSS WITH THRUST BLOCK PER (A/D3)
- 22 CHECK VALVE VAULT (A/D8) (B/D8)
- 23 EROSION BLANKET PER (E/D10) (G/D10)
- 24 SEDIMENT LOG/WATTLE PER (A/D16) (B/D16)
- 25 FIRE HYDRANT PER (E/D5)

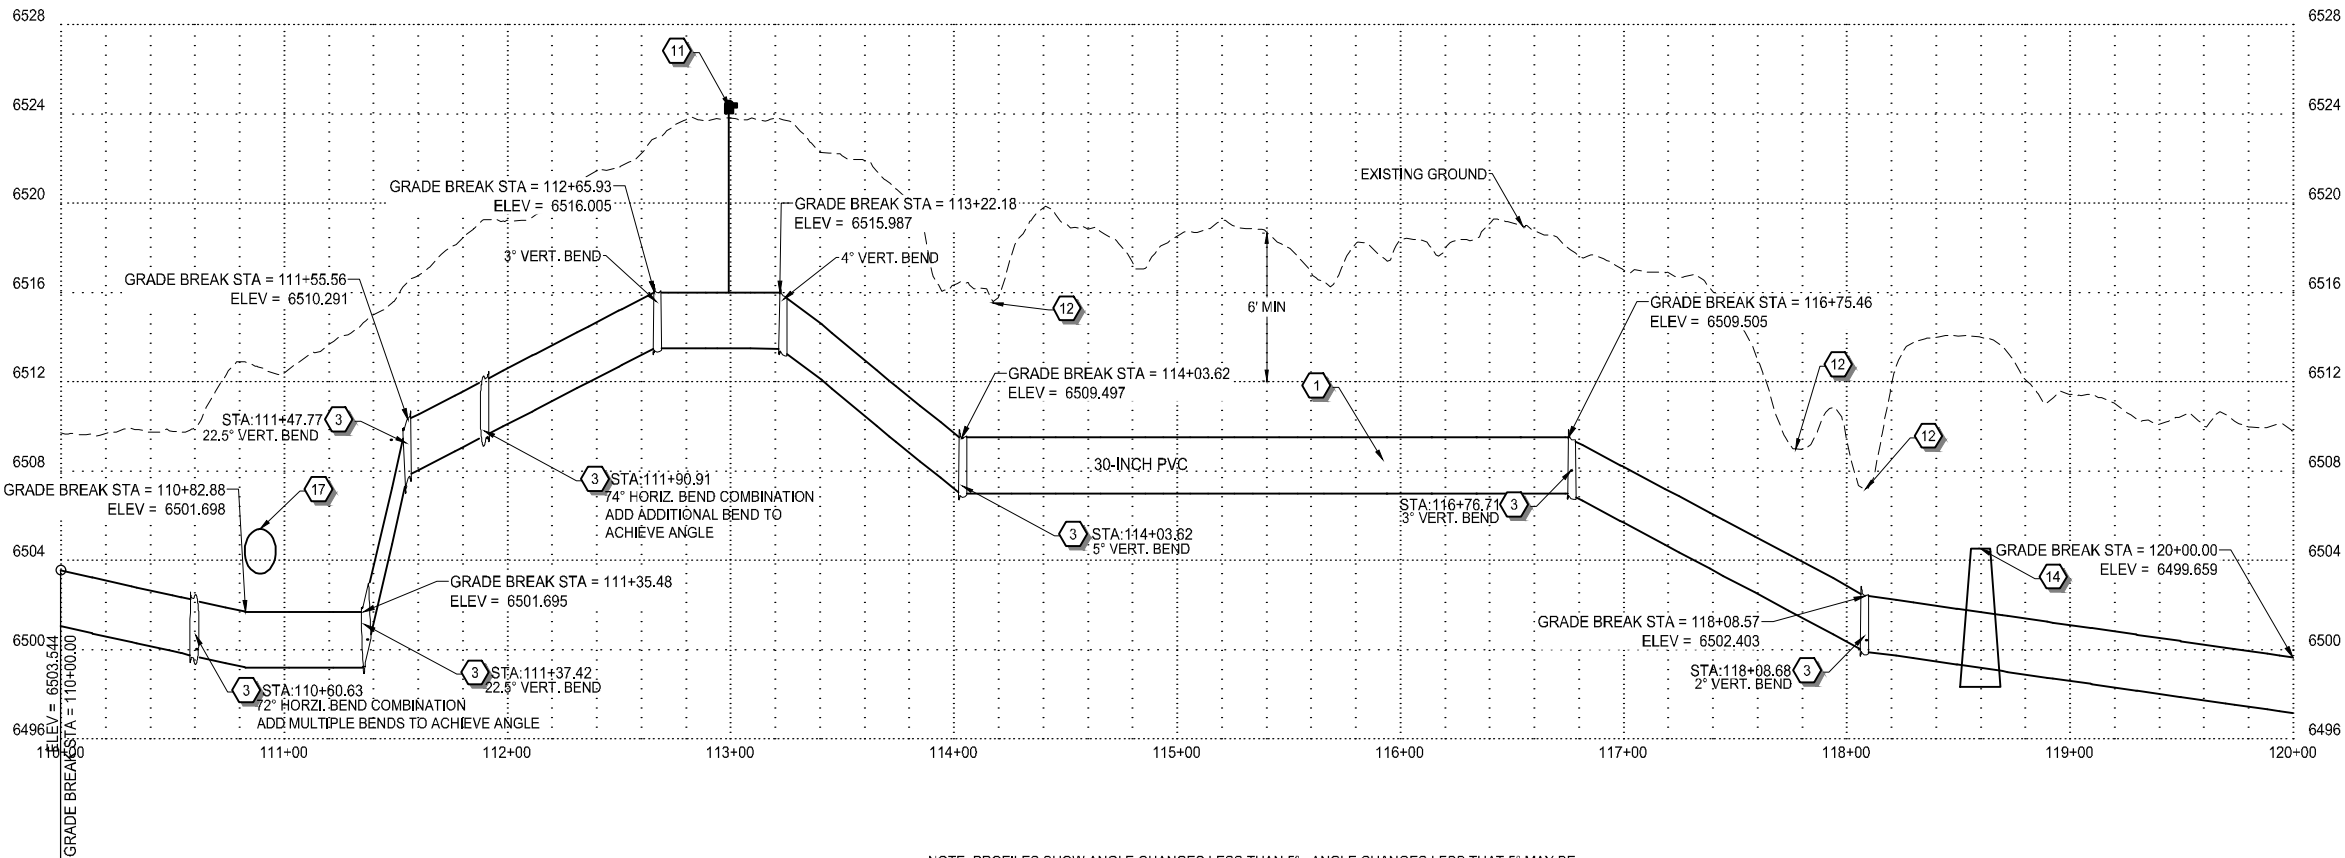

NOTE: PROFILES SHOW ANGLE CHANGES LESS THAN 5°. ANGLE CHANGES LESS THAN 5° MAY BE ACCOMPLISHED BY DEFLECTION IF NO SINGLE JOINT IS DEFLECTED MORE THAN 1/3 OF THE MANUFACTURES ALLOWABLE DEFLECTION AND DEFLECTION CAN BE MADE BY MANPOWER UNAIDED BY HYDRAULIC EQUIPMENT

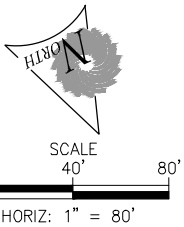

811 Know what's below.
Call before you dig.
1-800-849-2476




770 S WASHINGTON ST.
AFTON, WYOMING 83110
TEL 307.885.8500 • FAX 307.885.8501
www.sunrise-eng.com

GR-RS-SC JPWB
CROSSROADS PUMP STATION


PLAN AND PROFILE

SEI NO.	DESIGNED	DRAWN	CHECKED	SHEET NO.	
07265	FDK	BJ	JUL	26 of 99	PP12

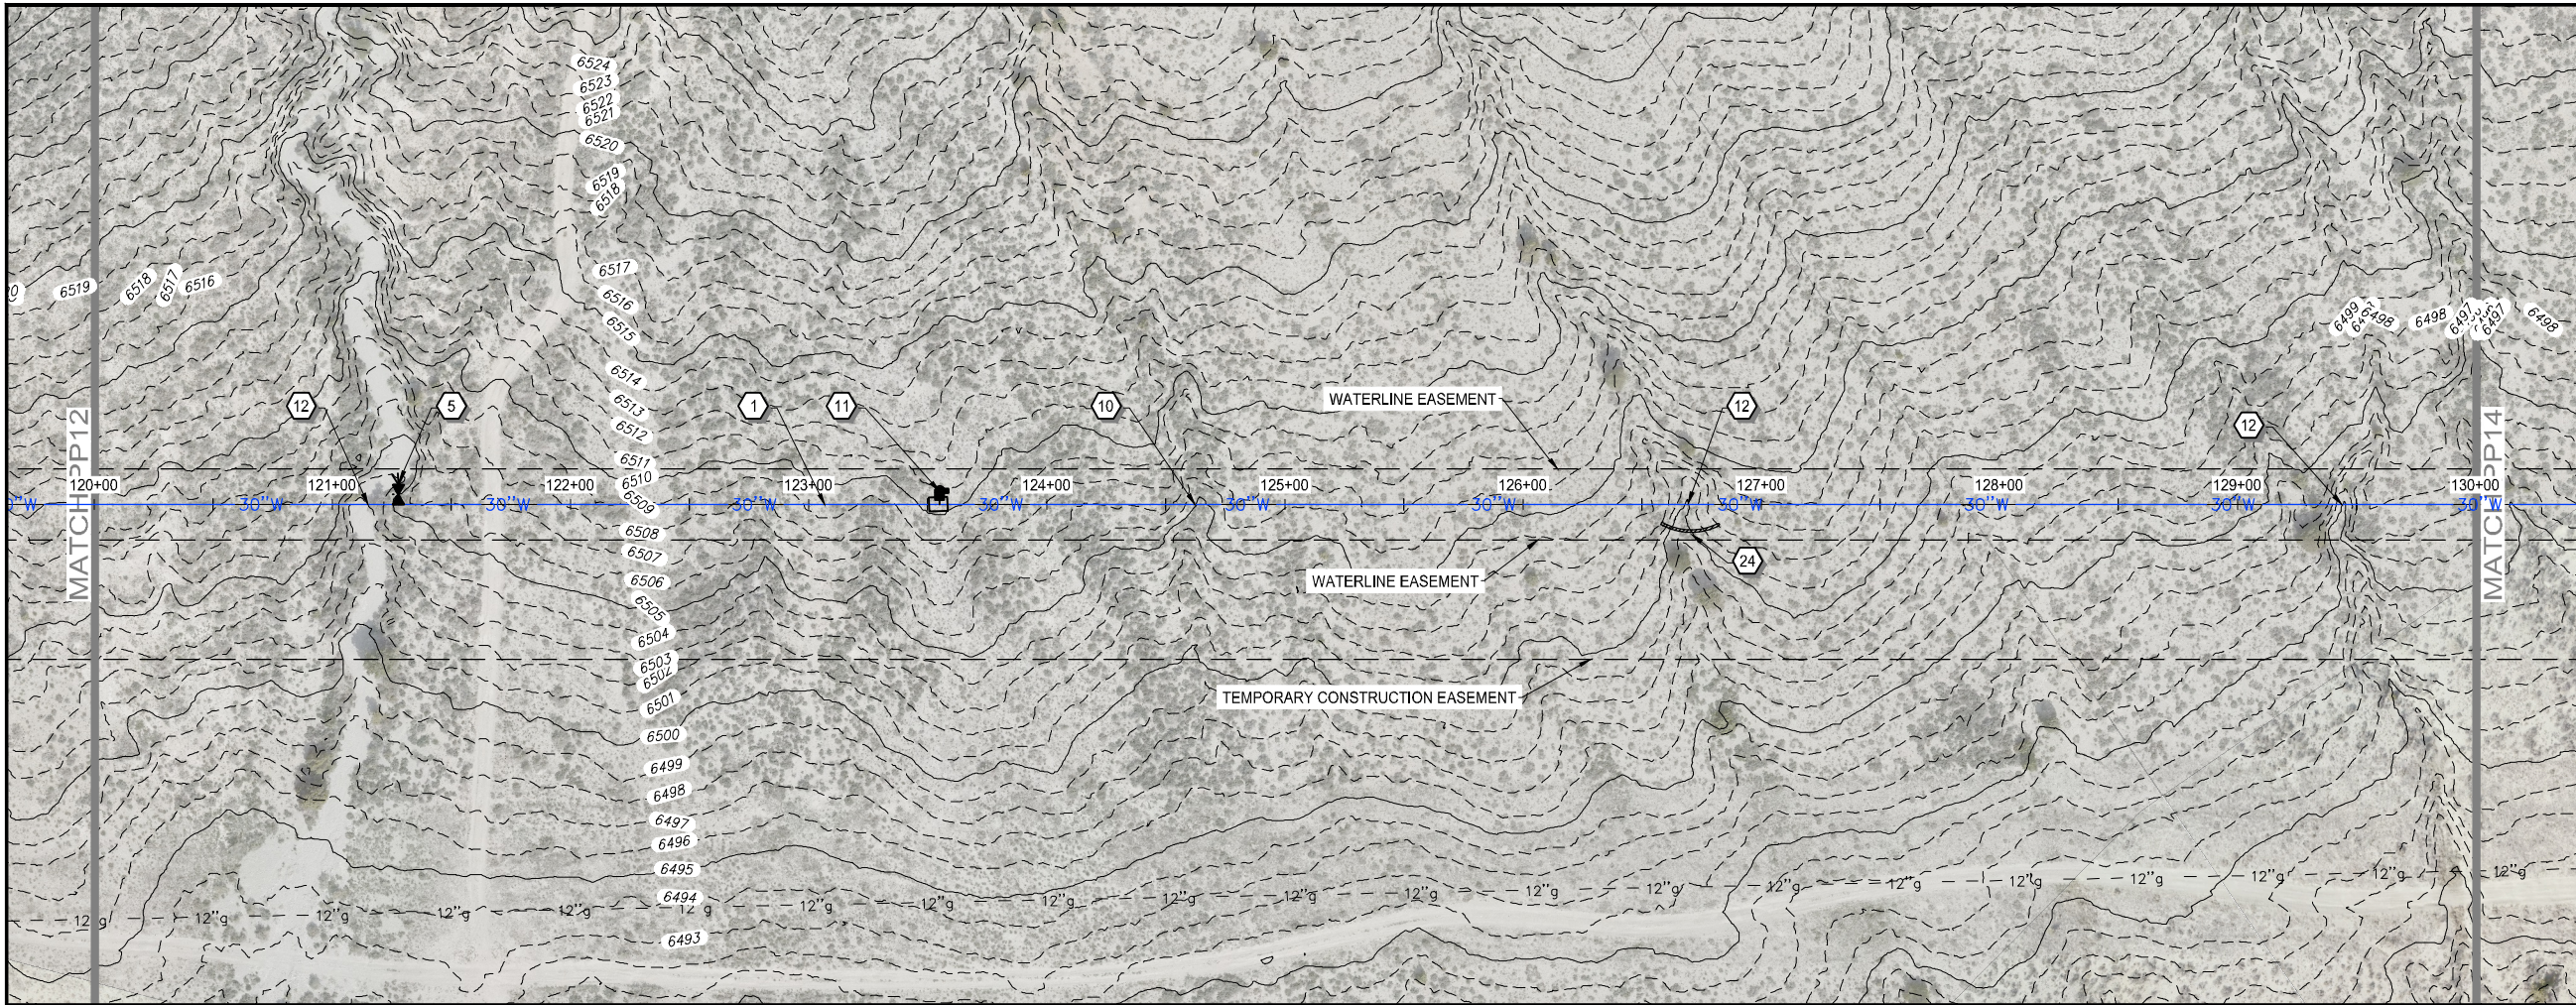


WATERLINE NOTES:

- 1 NEW 30" WATERLINE PER (A/D2) (B/D2)
- 2 CONNECT TO EXISTING 12" WATERLINE PER (C/D8) (D/D8) (E/D8)
- 3 BEND (90°, 45°, 221/2°, ETC.) WITH THRUST BLOCK. (A/D3)
- 4 BUTTERLY VALVE PER (C/D2)
- 5 BLOWOFF ASSEMBLY PER (C/D4)
- 6 TEE WITH THRUST BLOCK PER (A/D3)
- 7 CONNECT TO EXISTING 20" WATERLINE PER (A/D1)
- 8 MANWAY WITH AIRVAC PER (A/D8) (C/D7)
- 9 MANWAY WITH AIR RELEASE PER (A/D11) (B/D13)
- 10 MANWAY PER (A/D10) (A/D7)
- 11 AIRVAC VALVE PER (C/D10) (C/D7)
- 12 EPHEMERAL WASH CROSSING PER (A/D4)
- 13 CONNECT TO EXISTING 18" WATERLINE PER (A/D8)
- 14 CLAY CUT-OFF WALL PER (A/D5)
- 15 2-PIECE BEND (A/D3)
- 16 3-PIECE BEND (A/D3)
- 17 JIM BRIDGER PIPELINE CROSSING (A/D1) (B/D7)
- 18 GATE VALVE PER DETAIL (D/D2)
- 19 WEAK SOILS CROSSING (E/D1)
- 20 CONCRETE PIPELINE ANCHOR (D/D13)
- 21 30"x12" CROSS WITH THRUST BLOCK PER (A/D3)
- 22 CHECK VALVE VAULT (A/D8) (B/D8)
- 23 EROSION BLANKET PER (F/D10) (G/D10)
- 24 SEDIMENT LOG/WATTLE PER (A/D16) (B/D16)
- 25 FIRE HYDRANT PER (E/D5)

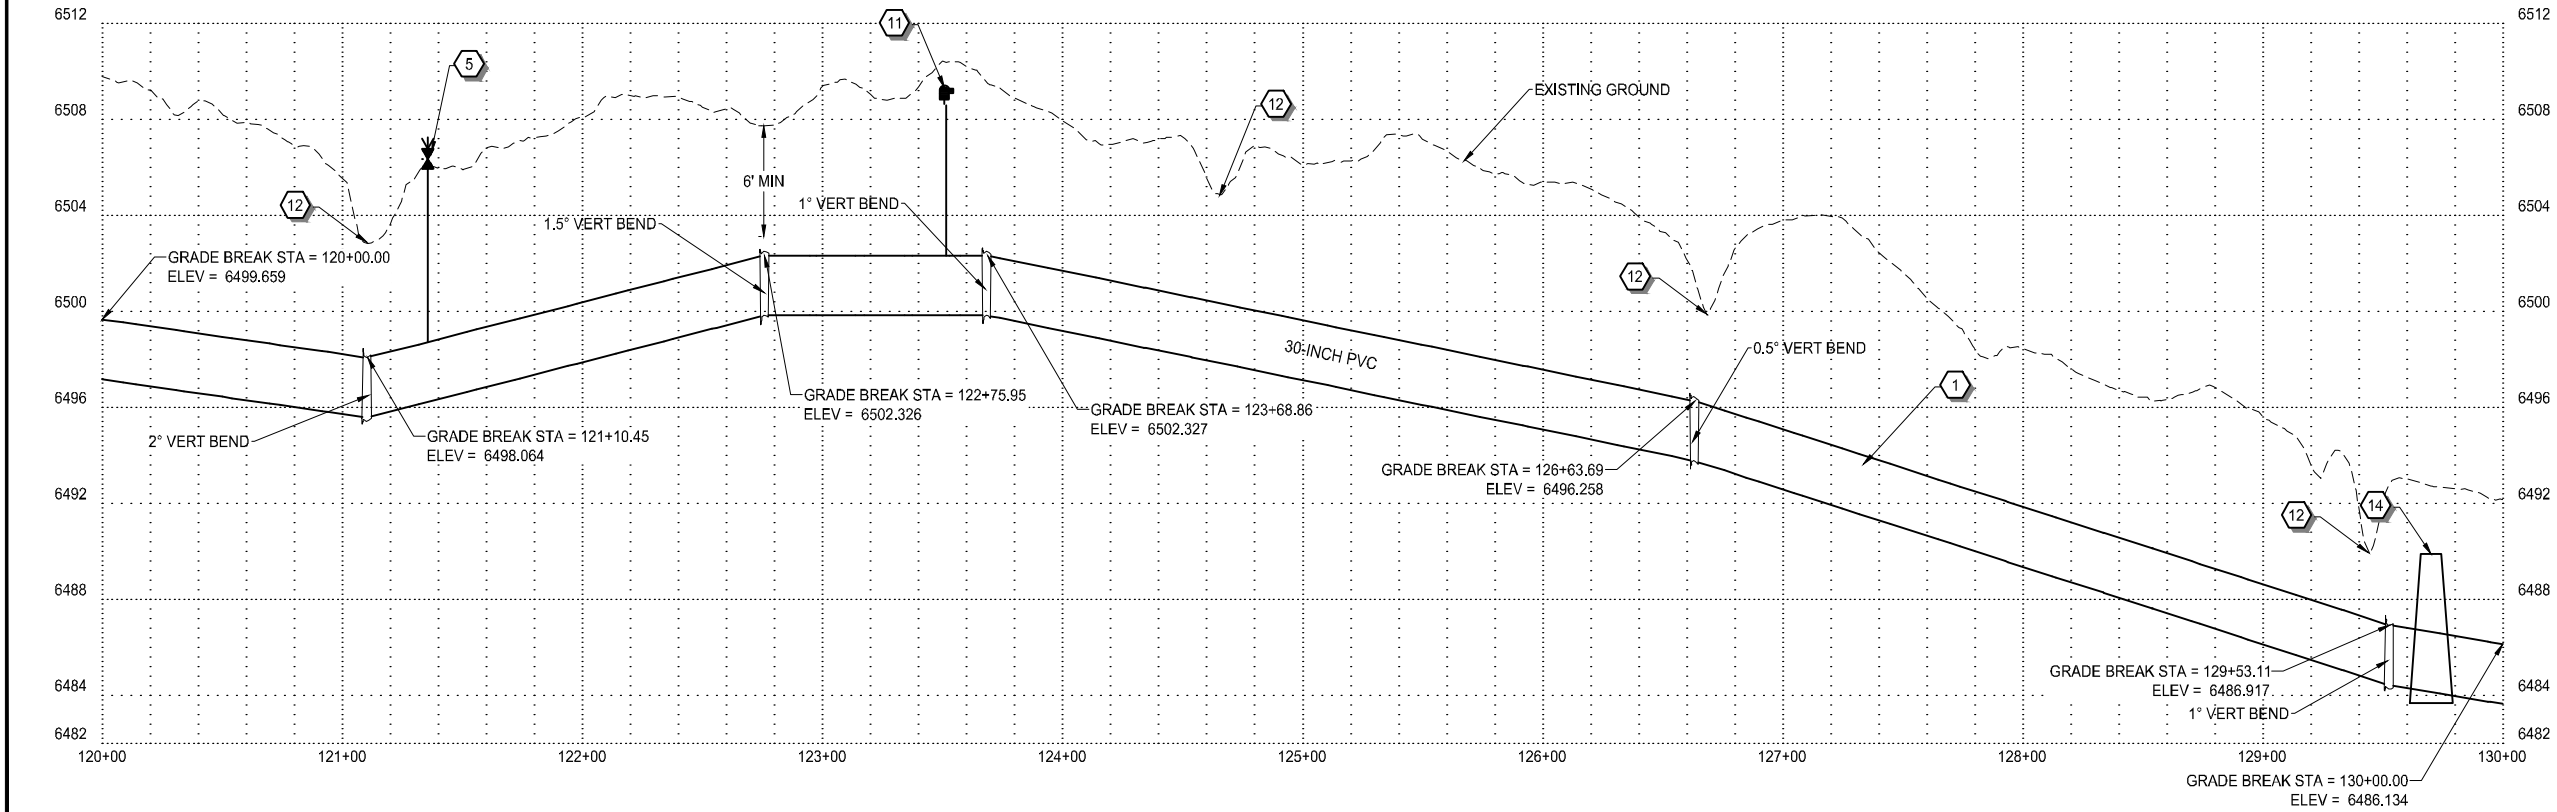

NOTE: PROFILES SHOW ANGLE CHANGES LESS THAN 5°. ANGLE CHANGES LESS THAT 5° MAY BE ACCOMPLISHED BY DEFLECTION IF NO SINGLE JOINT IS DEFLECTED MORE THAN 1/3 OF THE MANUFACTURES ALLOWABLE DEFLECTION AND DEFLECTION CAN BE MADE BY MANPOWER UNAIDED BY HYDRAULIC EQUIPMENT

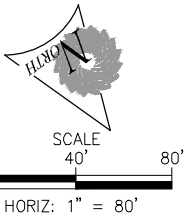

811 Know what's below.
Call before you dig.
1-800-849-2476




770 S WASHINGTON ST.
AFTON, WYOMING 83110
TEL 307.885.8500 · FAX 307.885.8501
www.sunrise-eng.com

GR-RS-SC JPWB
CROSSROADS PUMP STATION


PLAN AND PROFILE

SEI NO. 07265	DESIGNED FDK	DRAWN BJ	CHECKED JUL	SHEET NO. 27 of 99	PP13
------------------	-----------------	-------------	----------------	-----------------------	------

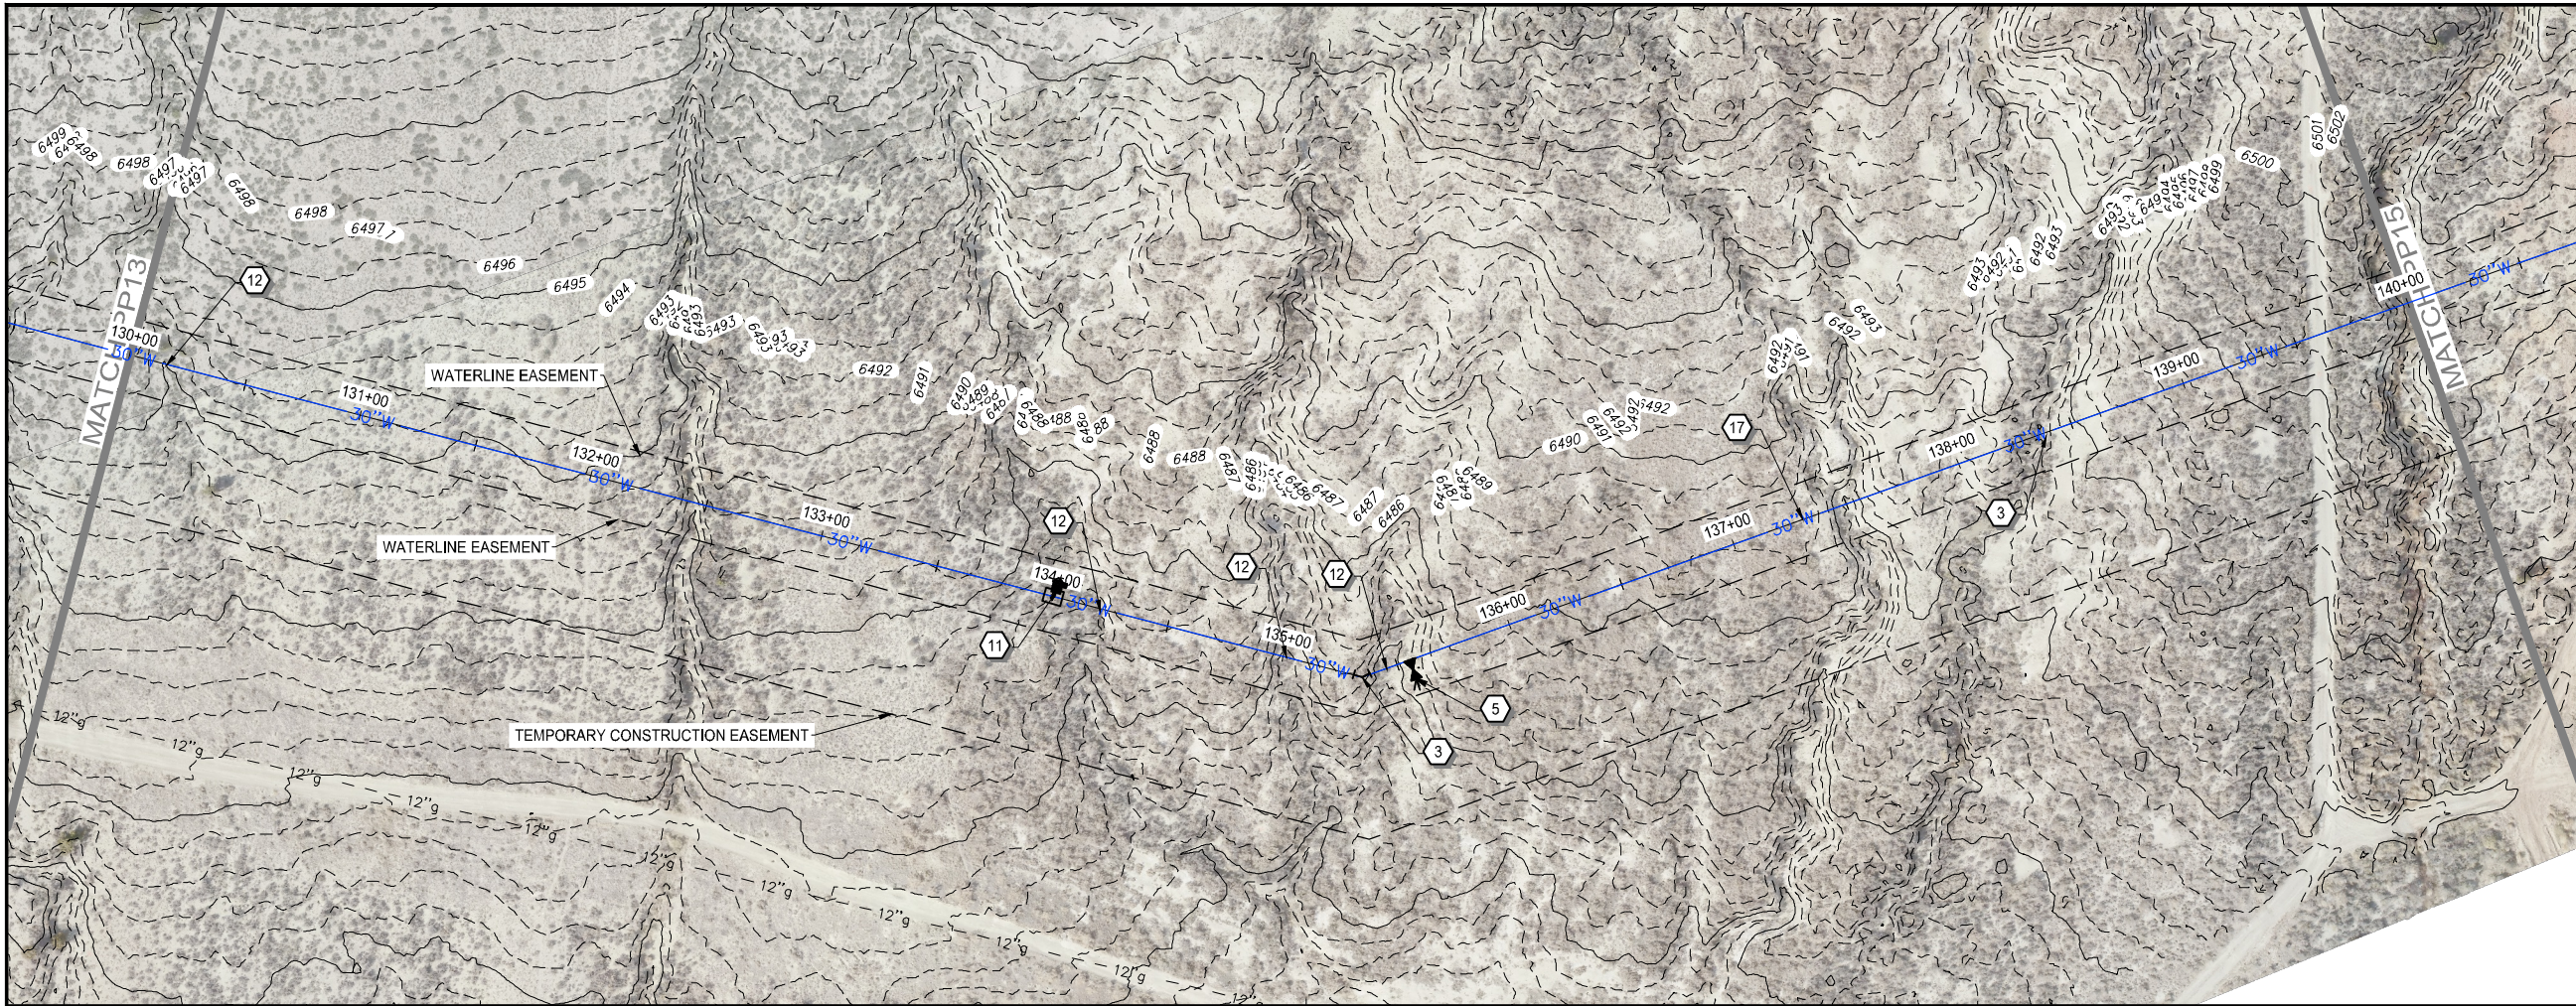


WATERLINE NOTES:

- 1 NEW 30" WATERLINE PER (A/D2) (B/D2)
- 2 CONNECT TO EXISTING 12" WATERLINE PER (C/D8) (D/D8) (E/D8)
- 3 BEND (90°, 45°, 221/2°, ETC.) WITH THRUST BLOCK. (A/D3)
- 4 BUTTERLY VALVE PER (C/D7)
- 5 BLOWOFF ASSEMBLY PER (C/D4)
- 6 TEE WITH THRUST BLOCK PER (A/D3)
- 7 CONNECT TO EXISTING 20" WATERLINE PER (A/D1)
- 8 MANWAY WITH AIRVAC PER (A/D8) (C/D7)
- 9 MANWAY WITH AIR RELEASE PER (A/D11) (B/D13)
- 10 MANWAY PER (A/D10) (A/D12)
- 11 AIRVAC VALVE PER (C/D10) (C/D12)
- 12 EPHEMERAL WASH CROSSING PER (A/D4)
- 13 CONNECT TO EXISTING 18" WATERLINE PER (A/D6)
- 14 CLAY CUT-OFF WALL PER (A/D5)
- 15 2-PIECE BEND (A/D3)
- 16 3-PIECE BEND (A/D3)
- 17 JIM BRIDGER PIPELINE CROSSING (A/D1) (B/D1)
- 18 GATE VALVE PER DETAIL (D/D7)
- 19 WEAK SOILS CROSSING (E/D1)
- 20 CONCRETE PIPELINE ANCHOR (D/D13)
- 21 30"x12" CROSS WITH THRUST BLOCK PER (A/D3)
- 22 CHECK VALVE VAULT (A/D6) (B/D8)
- 23 EROSION BLANKET PER (E/D10) (G/D10)
- 24 SEDIMENT LOG/WATTLE PER (A/D16) (B/D16)
- 25 FIRE HYDRANT PER (E/D5)

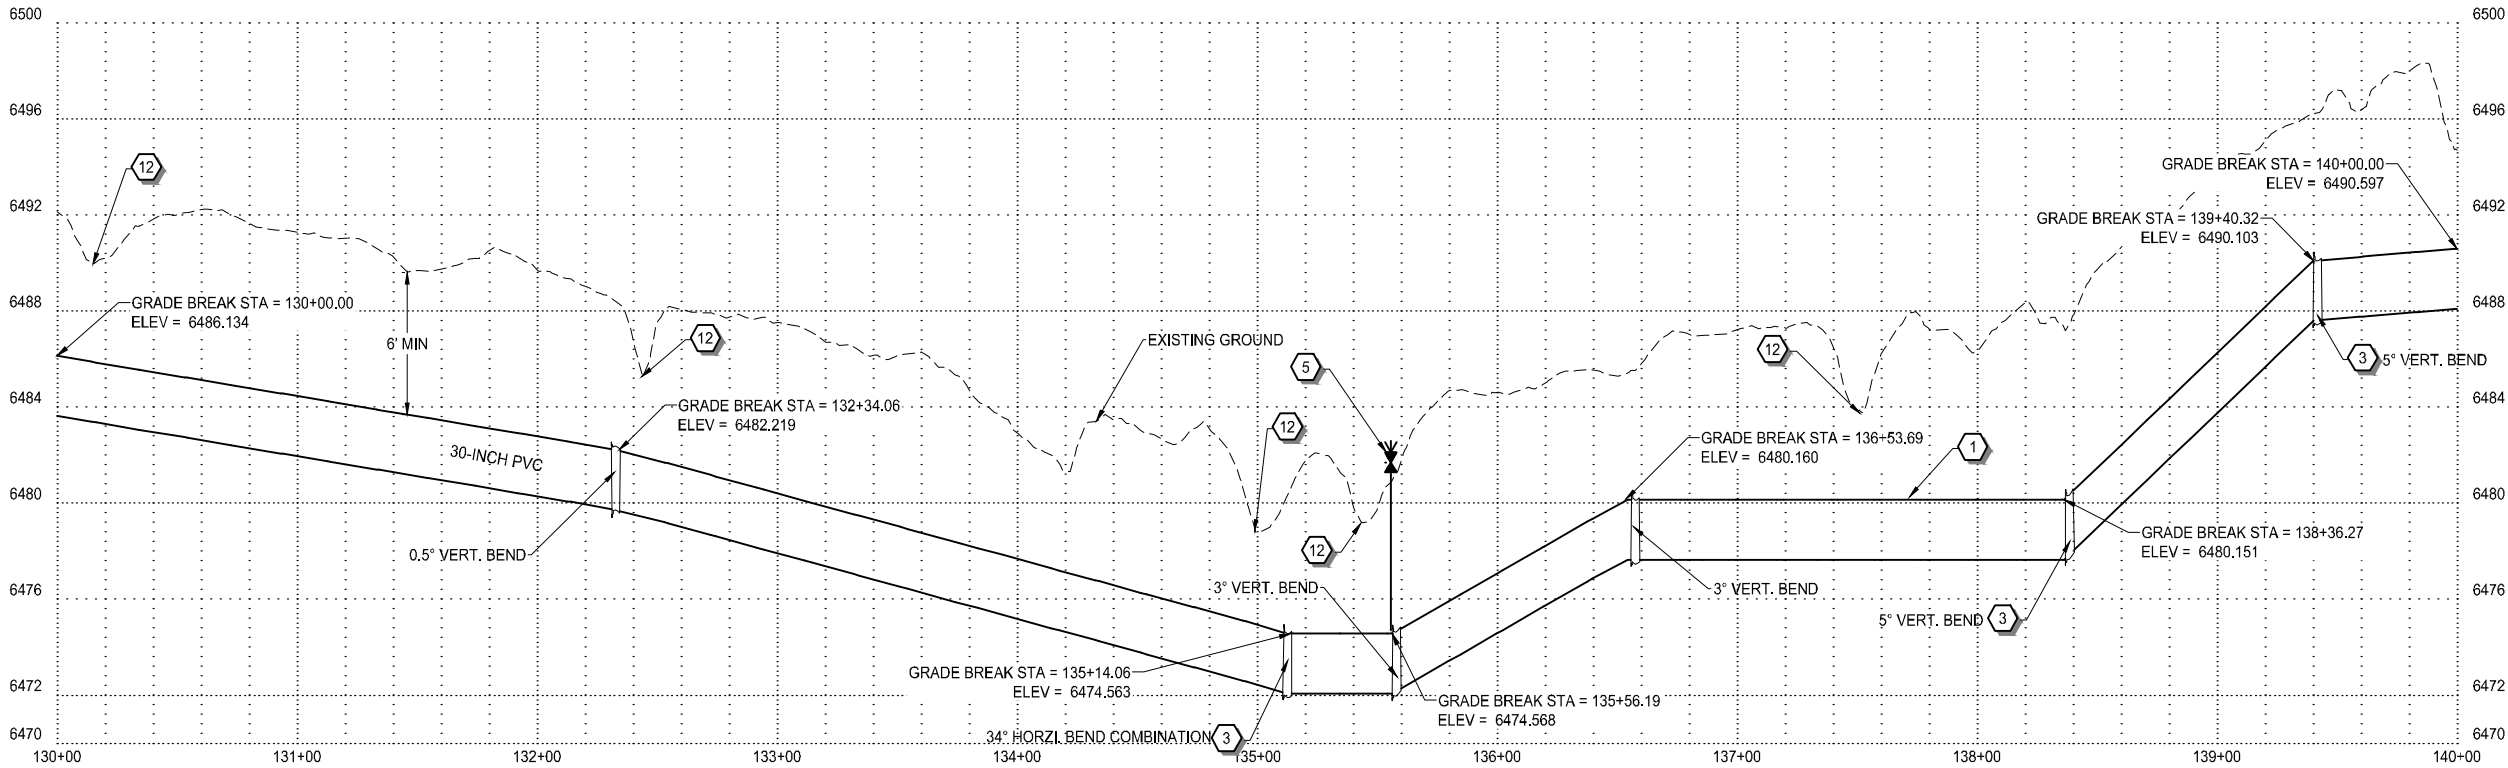

NOTE: PROFILES SHOW ANGLE CHANGES LESS THAN 5°. ANGLE CHANGES LESS THAT 5° MAY BE ACCOMPLISHED BY DEFLECTION IF NO SINGLE JOINT IS DEFLECTED MORE THAN 1/3 OF THE MANUFACTURES ALLOWABLE DEFLECTION AND DEFLECTION CAN BE MADE BY MANPOWER UNDAIED BY HYDRAULIC EQUIPMENT

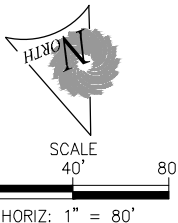


770 S WASHINGTON ST.
AFTON, WYOMING 83110
TEL 307.885.8500 · FAX 307.885.8501
www.sunrise-eng.com

GR-RS-SC JPWB

CROSSROADS PUMP STATION



PLAN AND PROFILE

SEI NO.	DESIGNED	DRAWN	CHECKED	SHEET NO.	
07265	FDK	BJ	JUL	28 of 99	PP14

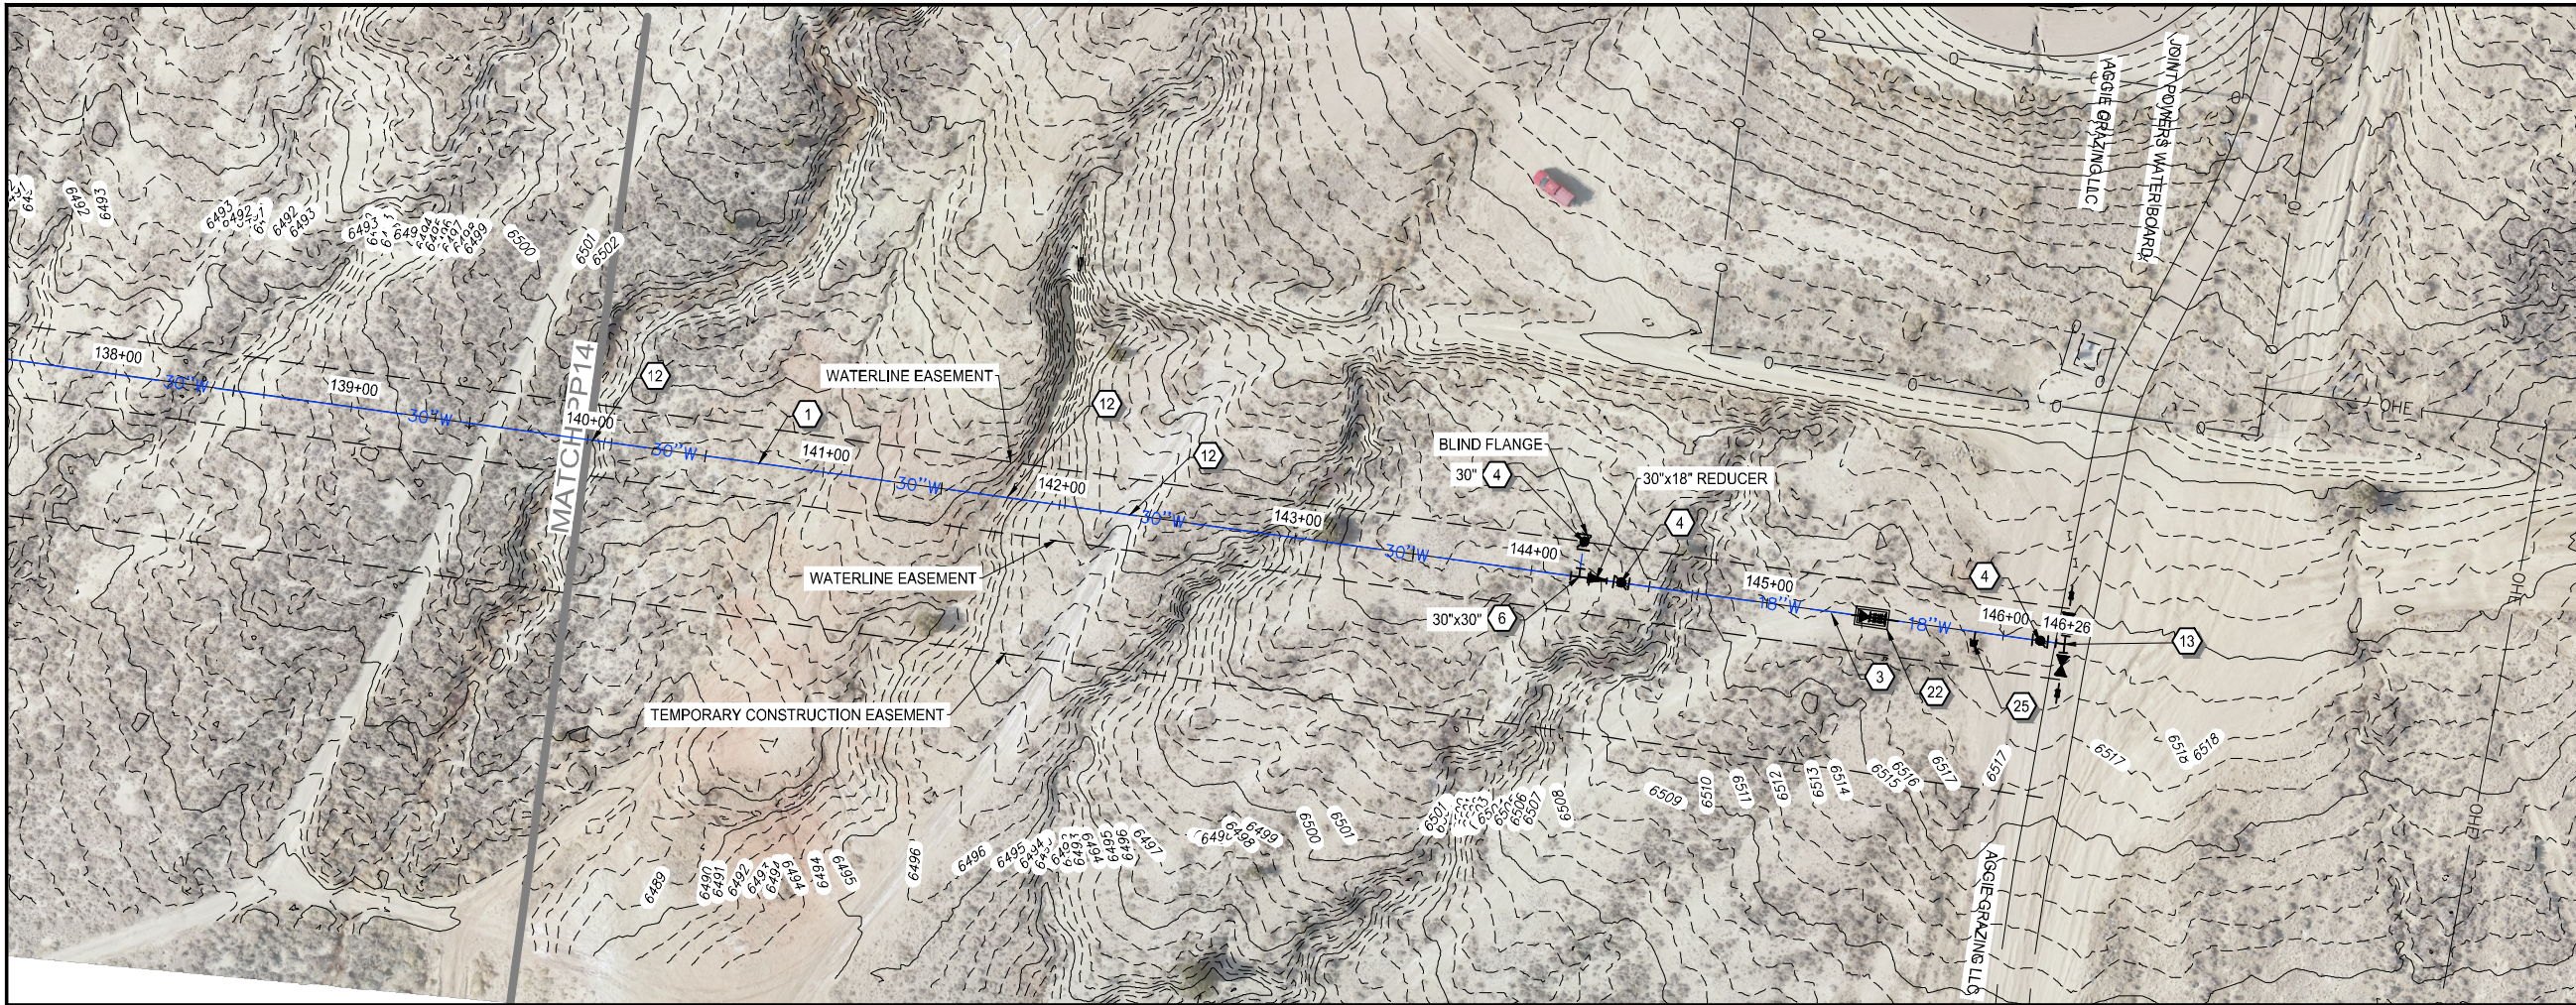

WATERLINE NOTES:

- 1 NEW 30" WATERLINE PER (A/D2) (B/D2)
- 2 CONNECT TO EXISTING 12" WATERLINE PER (C/D8) (D/D8) (E/D8)
- 3 BEND (90°, 45°, 221/2°, ETC.) WITH THRUST BLOCK. (A/D3)
- 4 BUTTERLY VALVE PER (C/D2)
- 5 BLOWOFF ASSEMBLY PER (C/D4)
- 6 TEE WITH THRUST BLOCK PER (A/D3)
- 7 CONNECT TO EXISTING 20" WATERLINE PER (A/D1)
- 8 MANWAY WITH AIRVAC PER (A/D9) (C/D17)
- 9 MANWAY WITH AIR RELEASE PER (A/D11) (B/D17)
- 10 MANWAY PER (A/D10) (A/D12)
- 11 AIRVAC VALVE PER (C/D10) (C/D12)
- 12 EPHEMERAL WASH CROSSING PER (A/D4)
- 13 CONNECT TO EXISTING 18" WATERLINE PER (A/D5)
- 14 CLAY CUT-OFF WALL PER (A/D5)
- 15 2-PIECE BEND (A/D3)
- 16 3-PIECE BEND (A/D3)
- 17 JIM BRIDGER PIPELINE CROSSING (A/D1) (B/D1)
- 18 GATE VALVE PER DETAIL (D/D2)
- 19 WEAK SOILS CROSSING (E/D1)
- 20 CONCRETE PIPELINE ANCHOR (D/D13)
- 21 30"x12" CROSS WITH THRUST BLOCK PER (A/D3)
- 22 CHECK VALVE VAULT (A/D6) (B/D8)
- 23 EROSION BLANKET PER (E/D10) (G/D18)
- 24 SEDIMENT LOG/WATTLE PER (A/D16) (B/D19)
- 25 FIRE HYDRANT PER (E/D5)

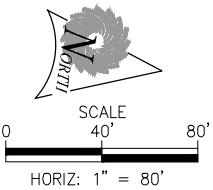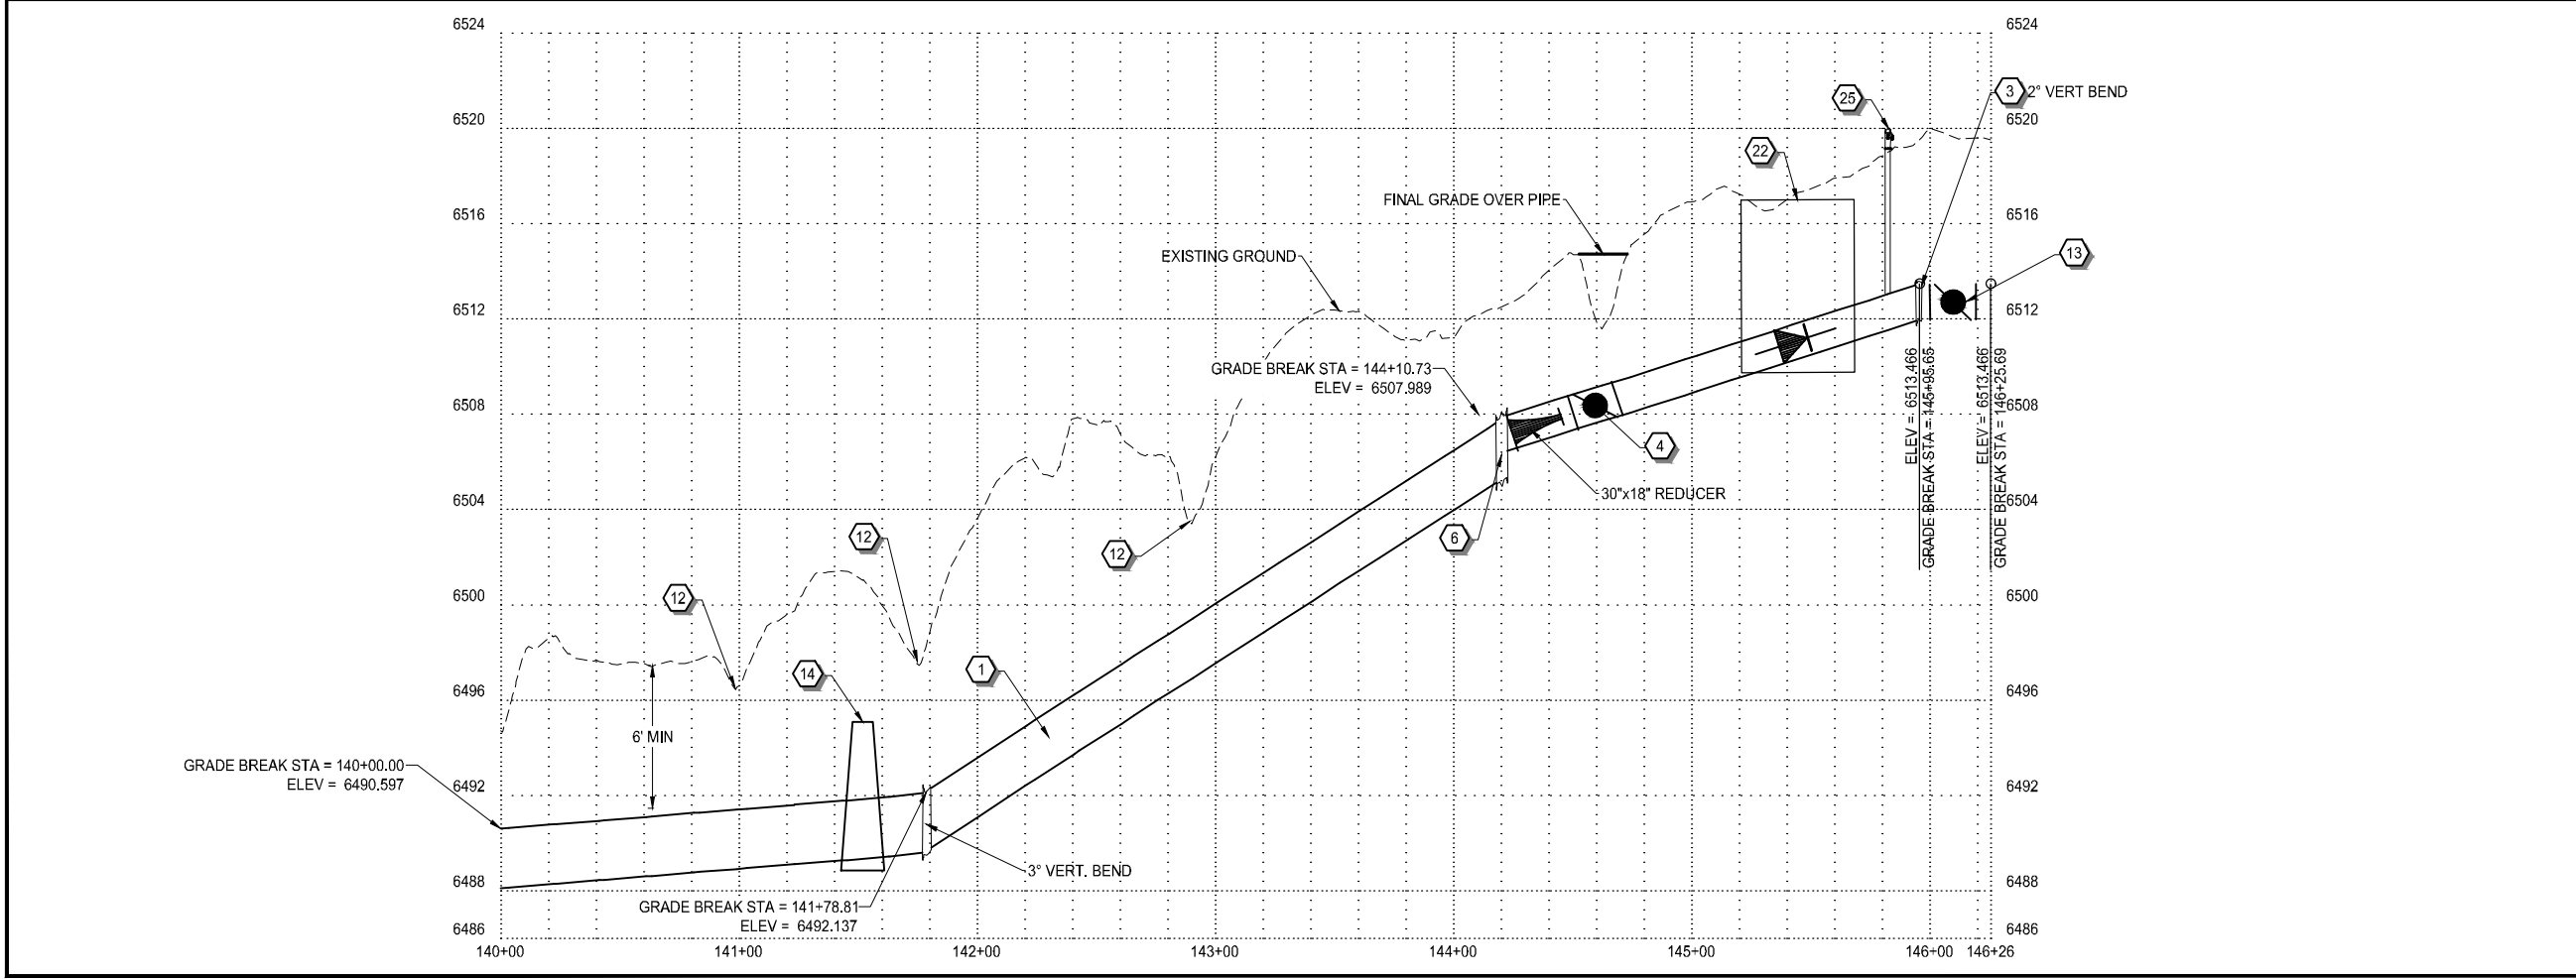



Know what's below.
Call before you dig.
1-800-849-2476




770 S WASHINGTON ST.
AFTON, WYOMING 83110
TEL 307.885.8500 • FAX 307.885.8501
www.sunrise-eng.com

GR-RS-SC JPWB
CROSSROADS PUMP STATION

PLAN AND PROFILE

SEI NO. 07265	DESIGNED FDK	DRAWN BJ	CHECKED JUL	SHEET NO. 29 of 99	PP15
------------------	-----------------	-------------	----------------	-----------------------	------

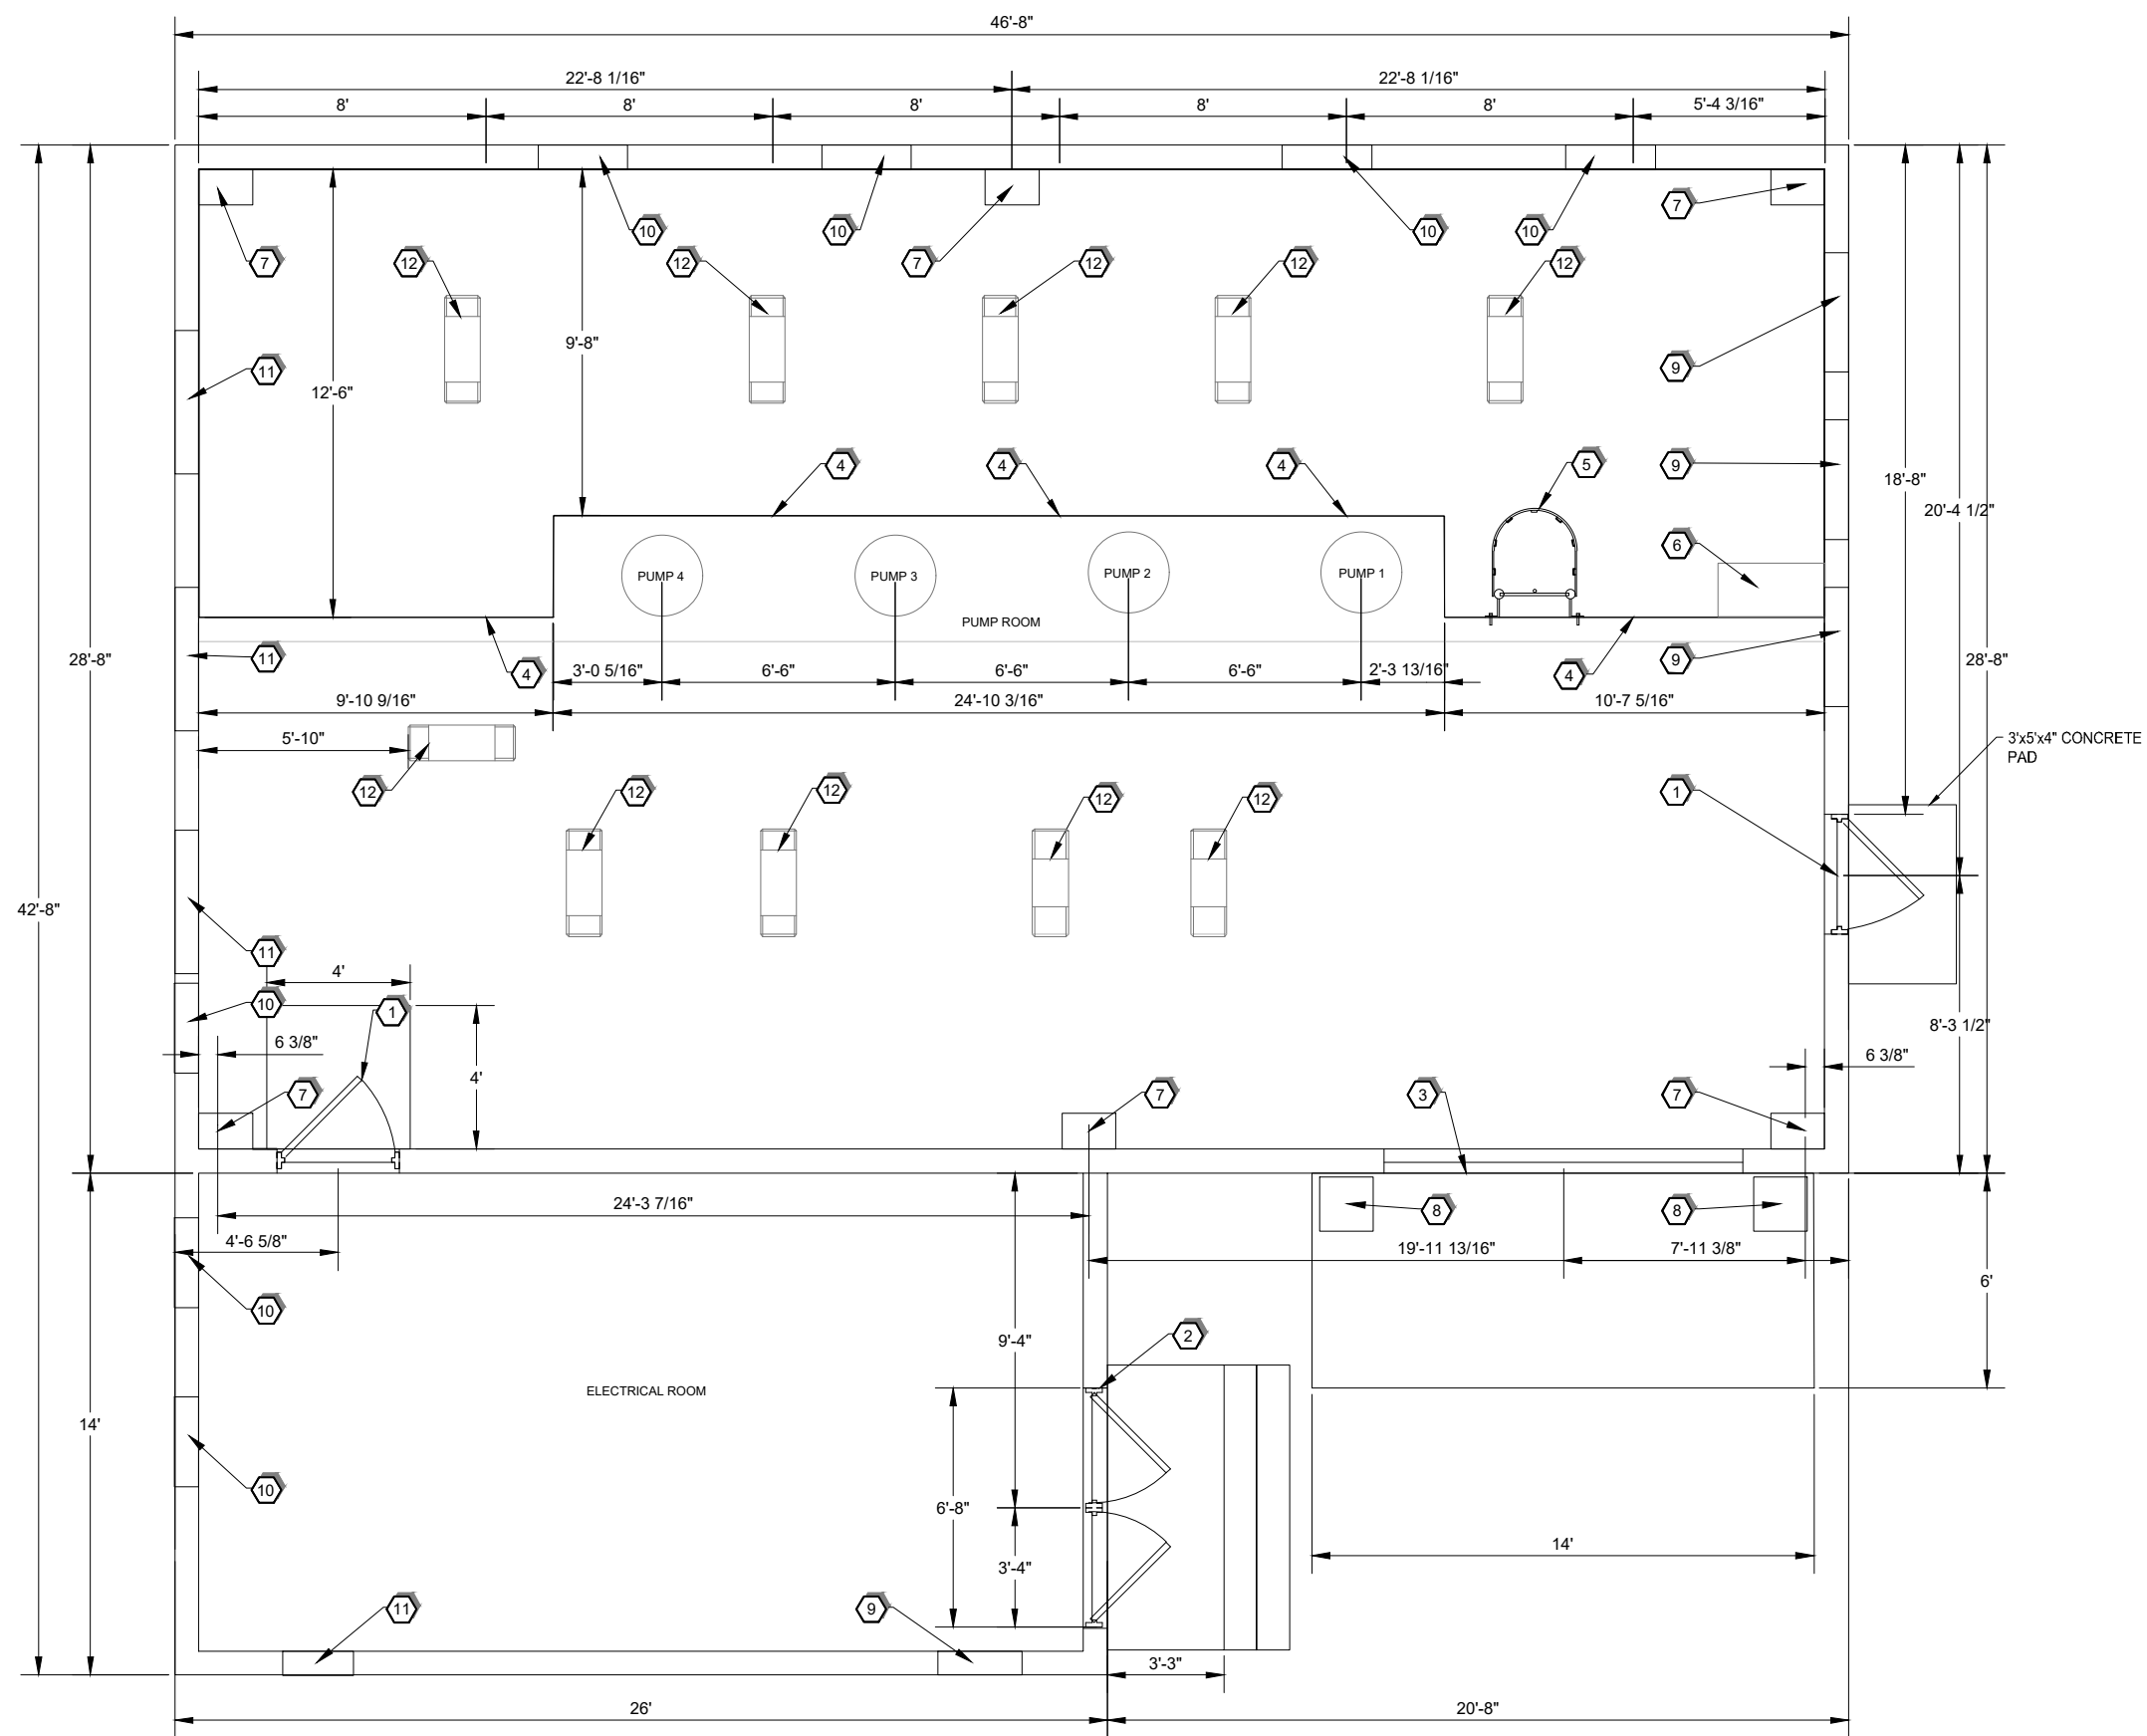

- 1 3'x7' SINGLE DOOR
 - 2 6'x7' DOUBLE DOOR
 - 3 10'x12' ROLL UP DOOR DETAIL H, S8
 - 4 GRATE SUPPORT, DETAIL E, S9
 - 5 LADDER DETAIL I, H, S9
 - 6 SUMP PIT DETAIL I, D8
 - 7 HOIST BASE, DETAIL D, S7
 - 8 BOLLARDS, DETAIL C, S5
 - 9 LOUVER, SEE LOUVER SCHEDULE, M1
 - 10 AIR HANDLER, SEE AIR HANDLER SCHEDULE, M1
 - 11 FAN, SEE FAN SCHEDULE, M1
 - 12 SUPPORT SADDLE, DETAIL E, S6
- NOTE: ALL WALLS ARE 8" CMU



A FLOOR PLAN
 ~ 3/16" = 1'

REV. NO.	COMMENT	DATE
SUNRISE ENGINEERING 770 S WASHINGTON ST. AFTON, WYOMING 83110 TEL 307.885.8500 • FAX 307.885.8501 www.sunrise-eng.com		
GR-RS-SC JPWB		
CROSSROADS PUMP STATION		
FLOOR PLAN		
SEI NO. 07265	DESIGNED FDK	DRAWN BJ
CHECKED JLL	SHEET NO. 30 of 99	A1

P:\WDC GR-RS-SC JPWB Cross Roads Pump Station Level III (S07265)\Dwg C3D\Pump Station\Details\Pump Station Layout.dwg Feb 13, 2026 9:38am bjenkins

(H) MASONRY CONTROL JOINT
S7 TYPICAL DETAIL

(H) MASONRY CONTROL JOINT
S7 TYPICAL DETAIL

RAIN CUTTER AND DOWN SPOUT

ELEV. 6256.75'
TOP OF WALL

ELEV. 6237.25'
TOP OF FOUNDATION

FINISHED GRADE ELEV: 6236.75

EXISTING GRADE ELEV: 6236.25

ELEV. 6233.41'
TOP OF FOOTING

FINISHED GRADE ELEV: 6236.75

EXISTING GRADE ELEV: 6236.25


ELEV. 6236.75'
TOP OF PUMP ROOM FLOOR

ELEV. 6228.96'
TOP OF FOOTING

(A) SOUTH SIDE OF PUMP STATION
3/16" = 1' ELEVATION VIEW


REV. NO.	COMMENT	DATE
SUNRISE ENGINEERING 770 S WASHINGTON ST. AFTON, WYOMING 83110 TEL 307.885.8500 • FAX 307.885.8501 www.sunrise-eng.com		
GR-RS-SC JPWB		
CROSSROADS PUMP STATION		
BUILDING ELEVATIONS		
SEI NO. 07265	DESIGNED FDK	DRAWN BJ
CHECKED JUL	SHEET NO. 31 of 99	A2

P:\WDC GR-RS-SC JPWB Cross Roads Pump Station Level III (S07265)\Dwg CSD\Pump Station\Details\Pump Station Layout.dwg Feb 13, 2026 9:38am bjenkins

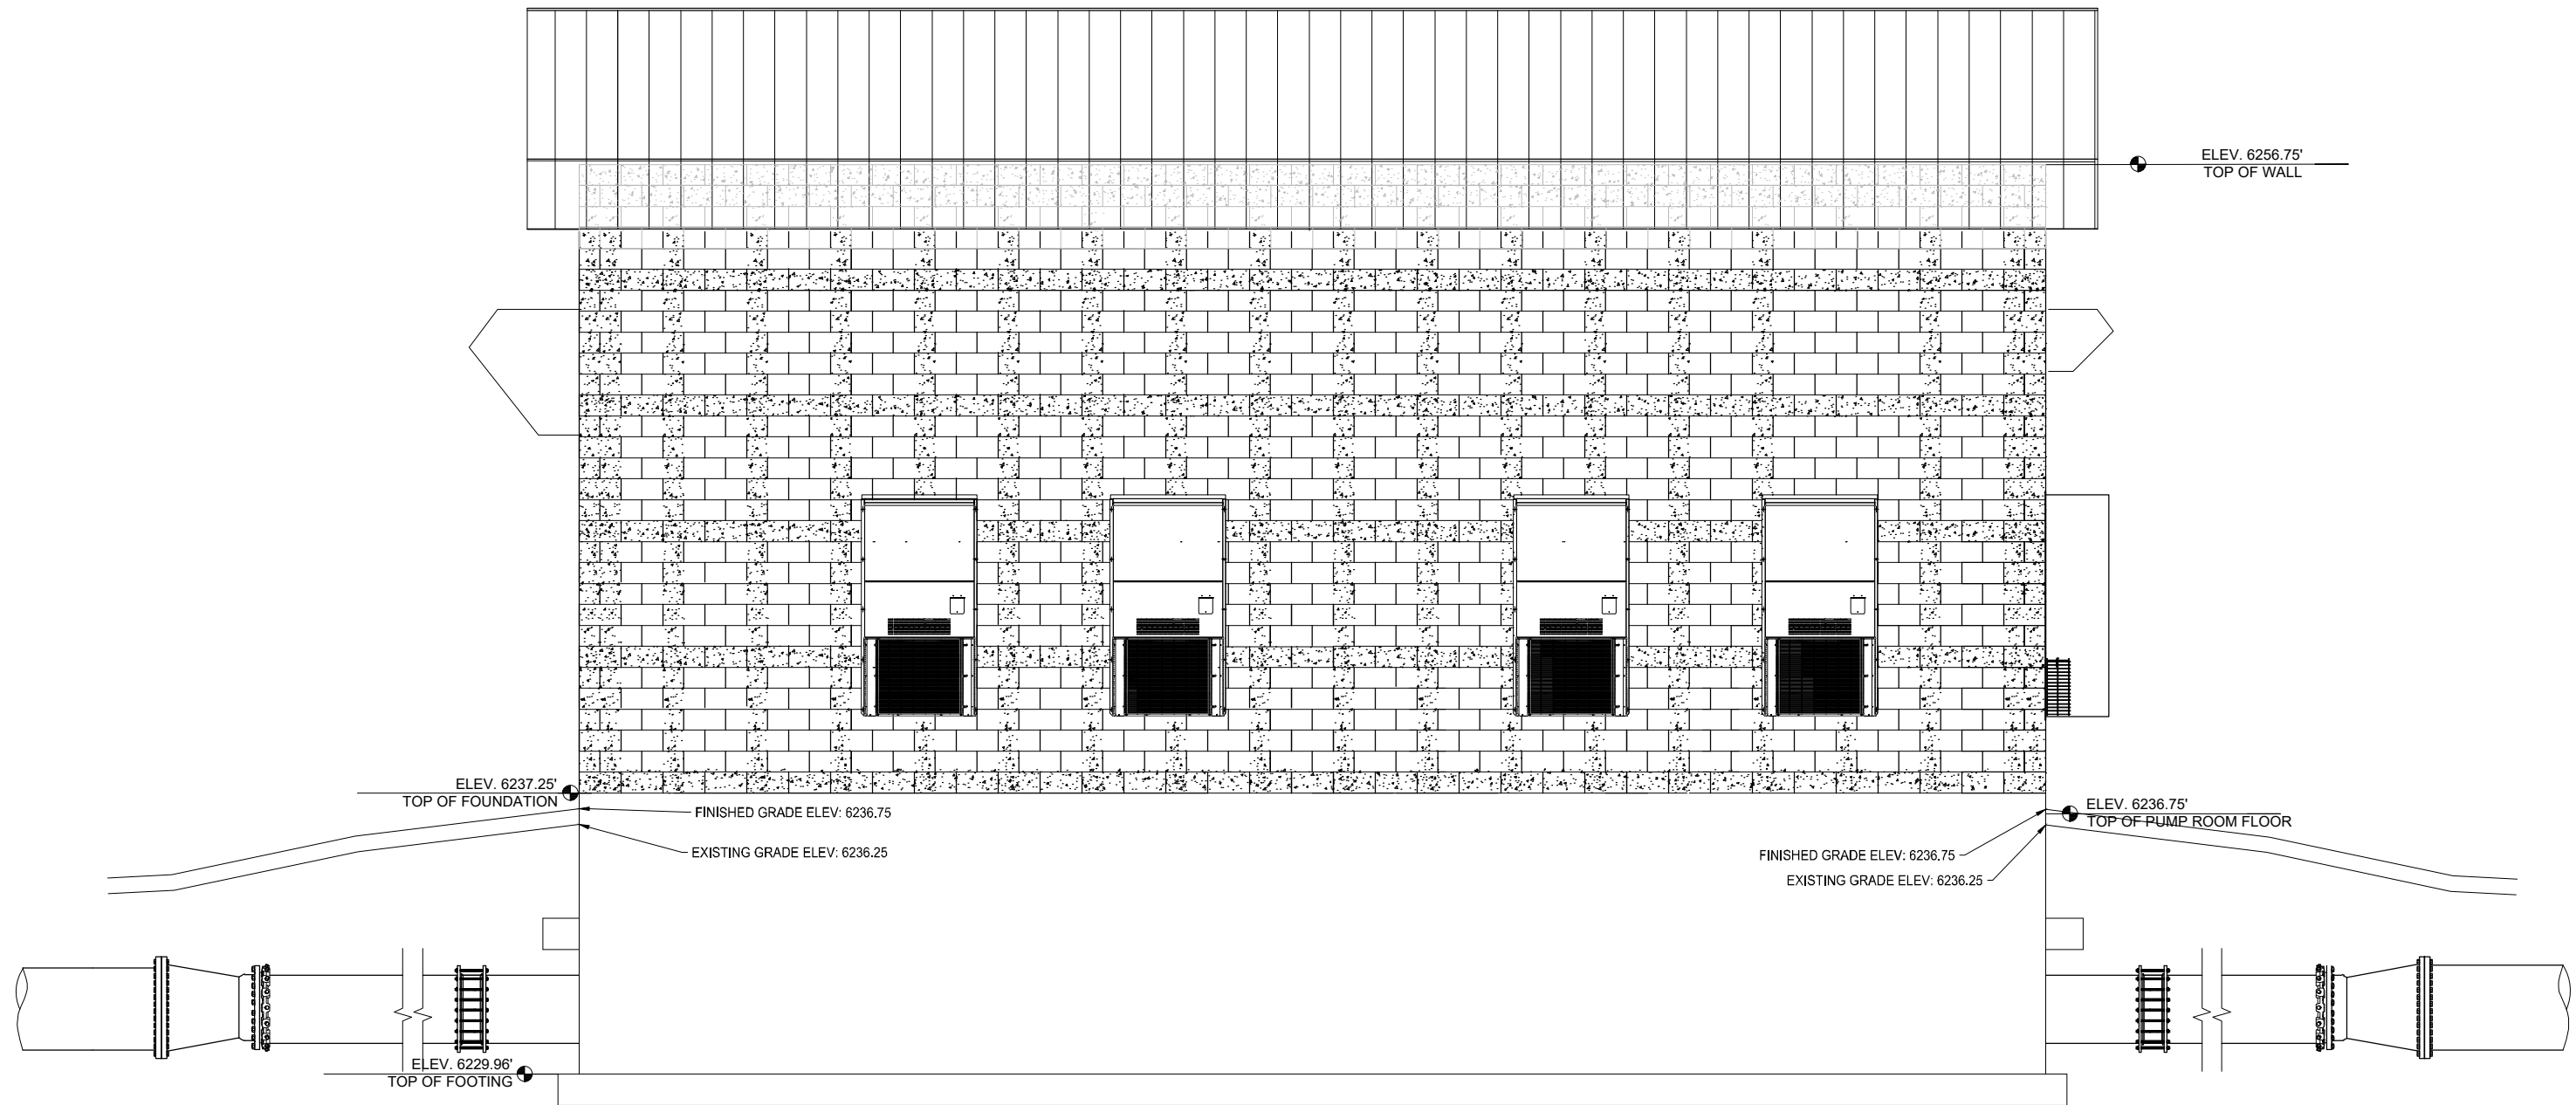


A NORTH SIDE OF PUMP STATION
 ~ 3/16" = 1' ELEVATION VIEW

REV. NO.	COMMENT	DATE
 SUNRISE ENGINEERING 770 S WASHINGTON ST. AFTON, WYOMING 83110 TEL 307.885.8500 • FAX 307.885.8501 www.sunrise-eng.com		
GR-RS-SC JPWB		
CROSSROADS PUMP STATION		
BUILDING ELEVATIONS		
SEI NO. 07265	DESIGNED FDK	DRAWN BJ
CHECKED JUL	SHEET NO. 32 of 99	A3

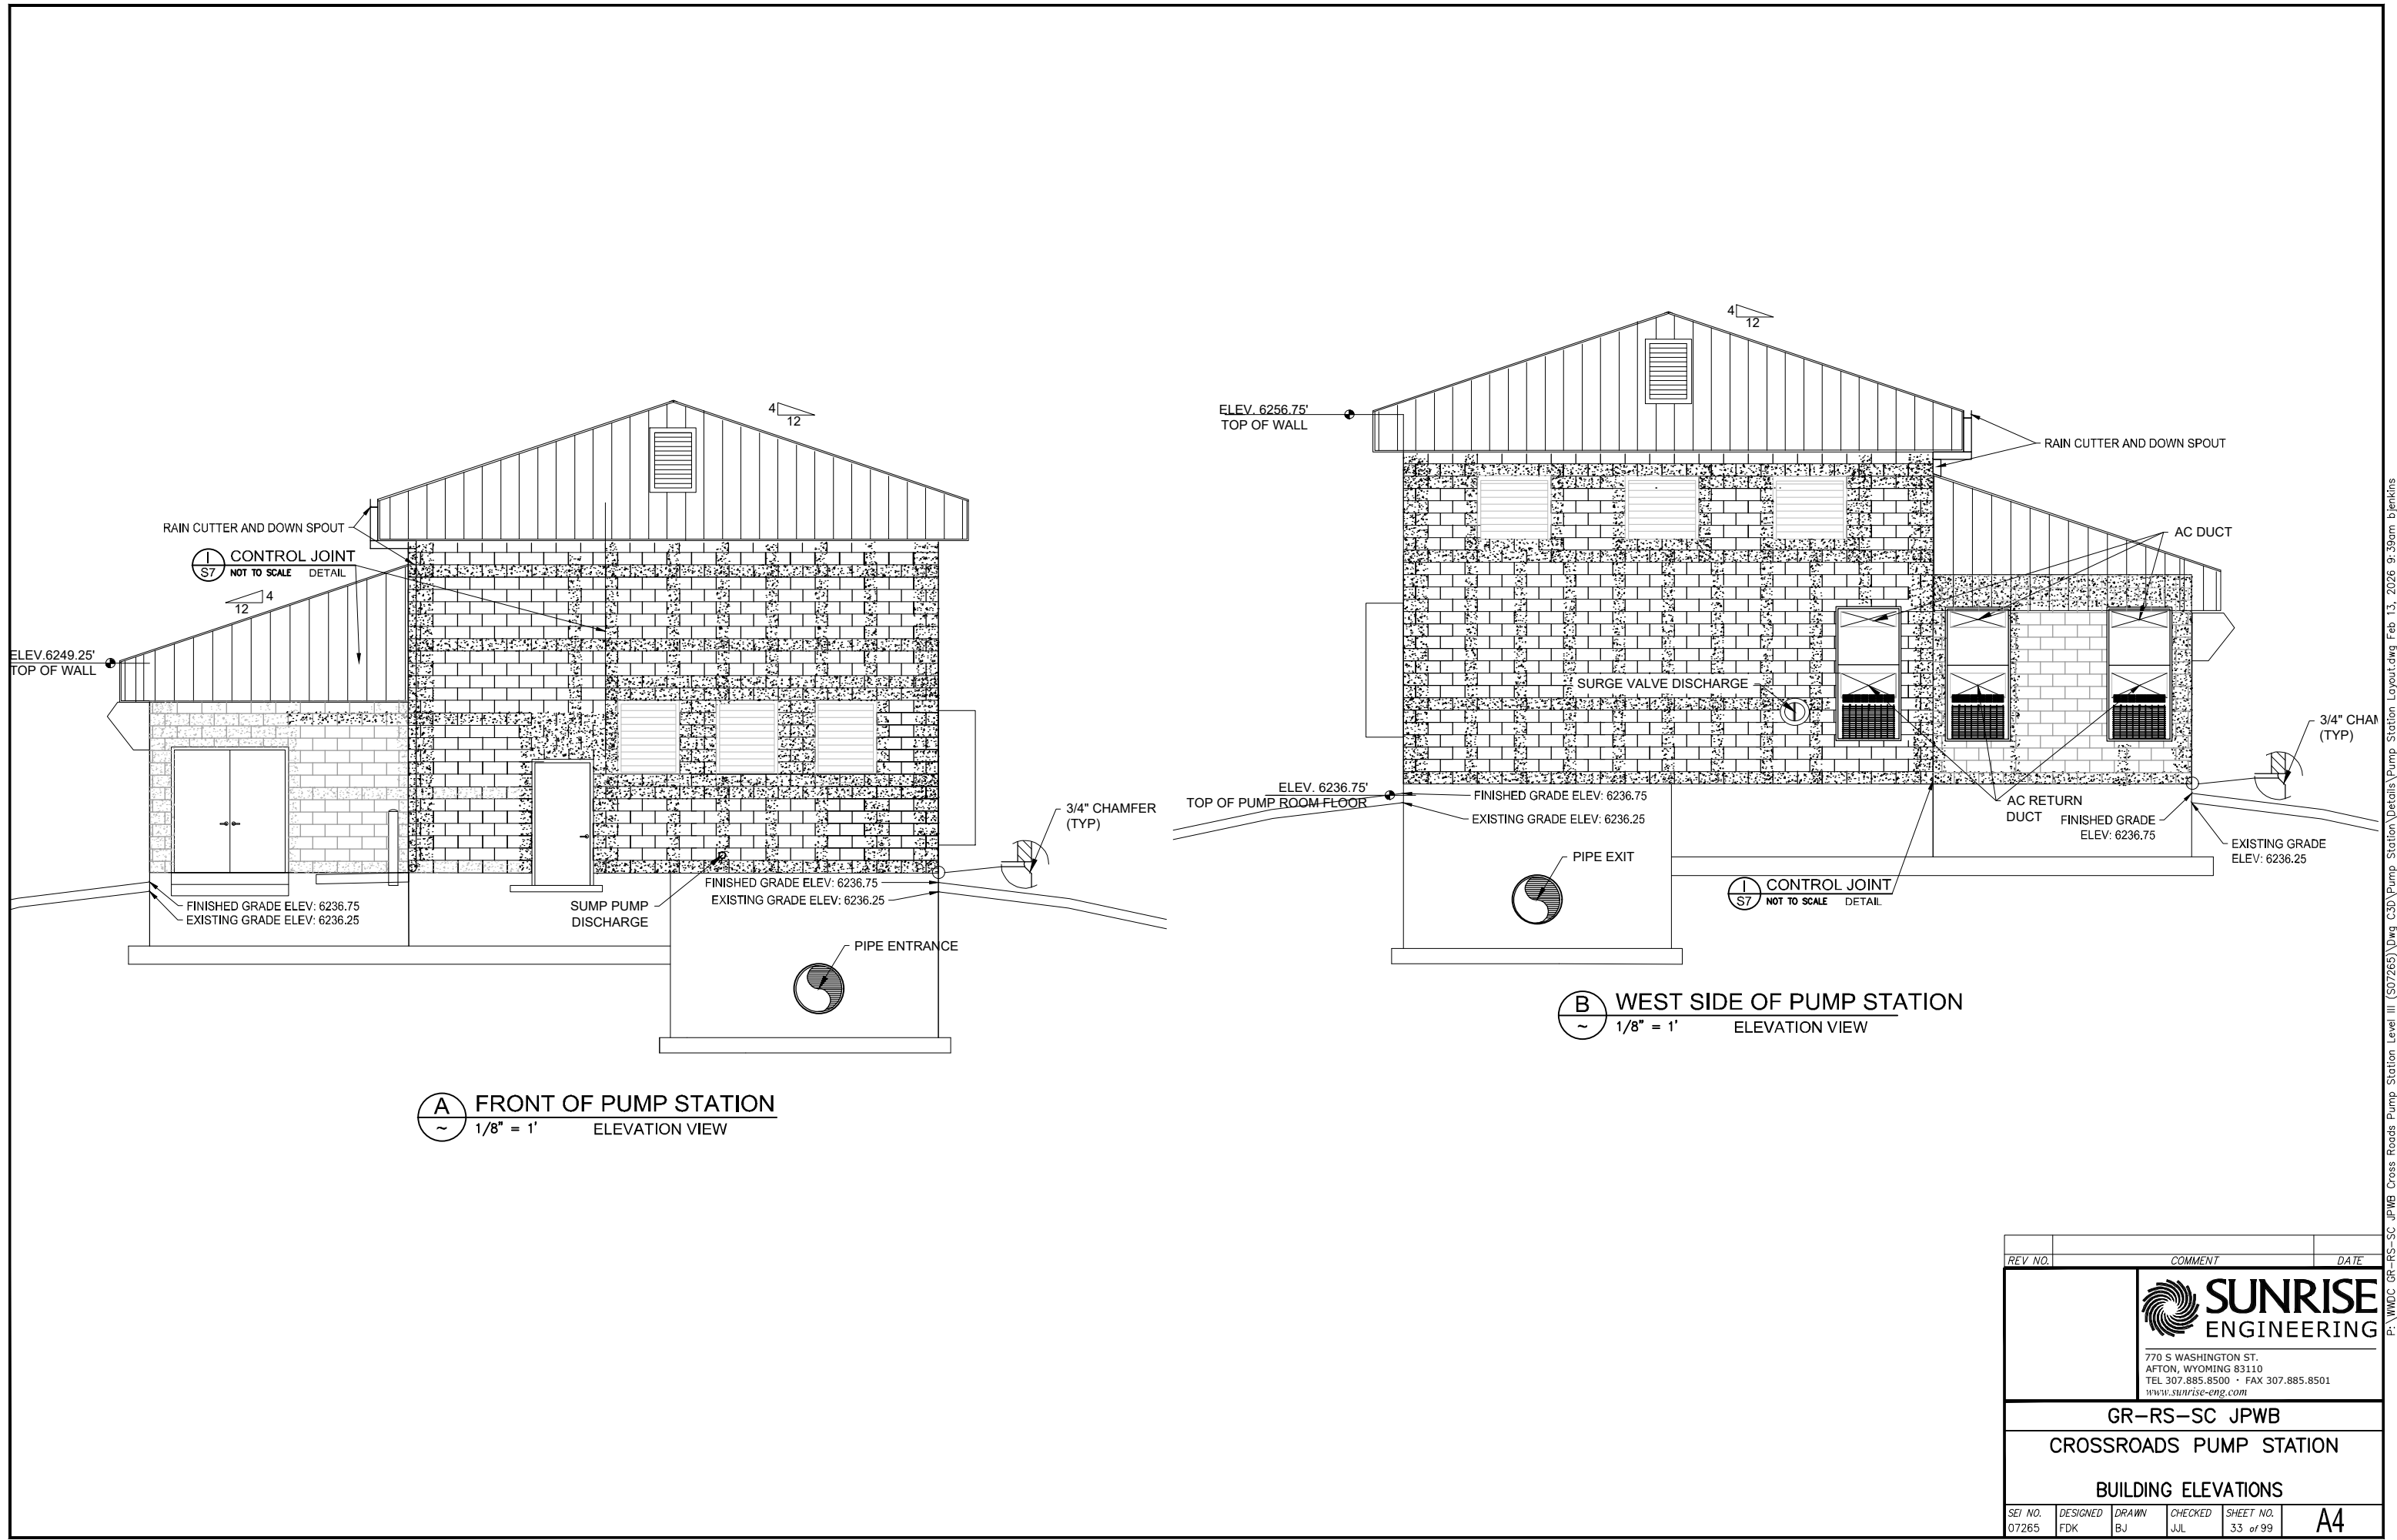


REV. NO.	COMMENT	DATE
 SUNRISE ENGINEERING 770 S WASHINGTON ST. AFTON, WYOMING 83110 TEL 307.885.8500 • FAX 307.885.8501 www.sunrise-eng.com		
GR-RS-SC JPWB		
CROSSROADS PUMP STATION		
BUILDING ELEVATIONS		
SEI NO. 07265	DESIGNED FDK	DRAWN BJ
CHECKED JUL	SHEET NO. 33 of 99	A4

P:\WDC GR-RS-SC JPWB Cross Roads Pump Station Level III (S07265)\Dwg CSD\Pump Station Details\Pump Station Layout.dwg Feb 13, 2026 9:39am bjenkins

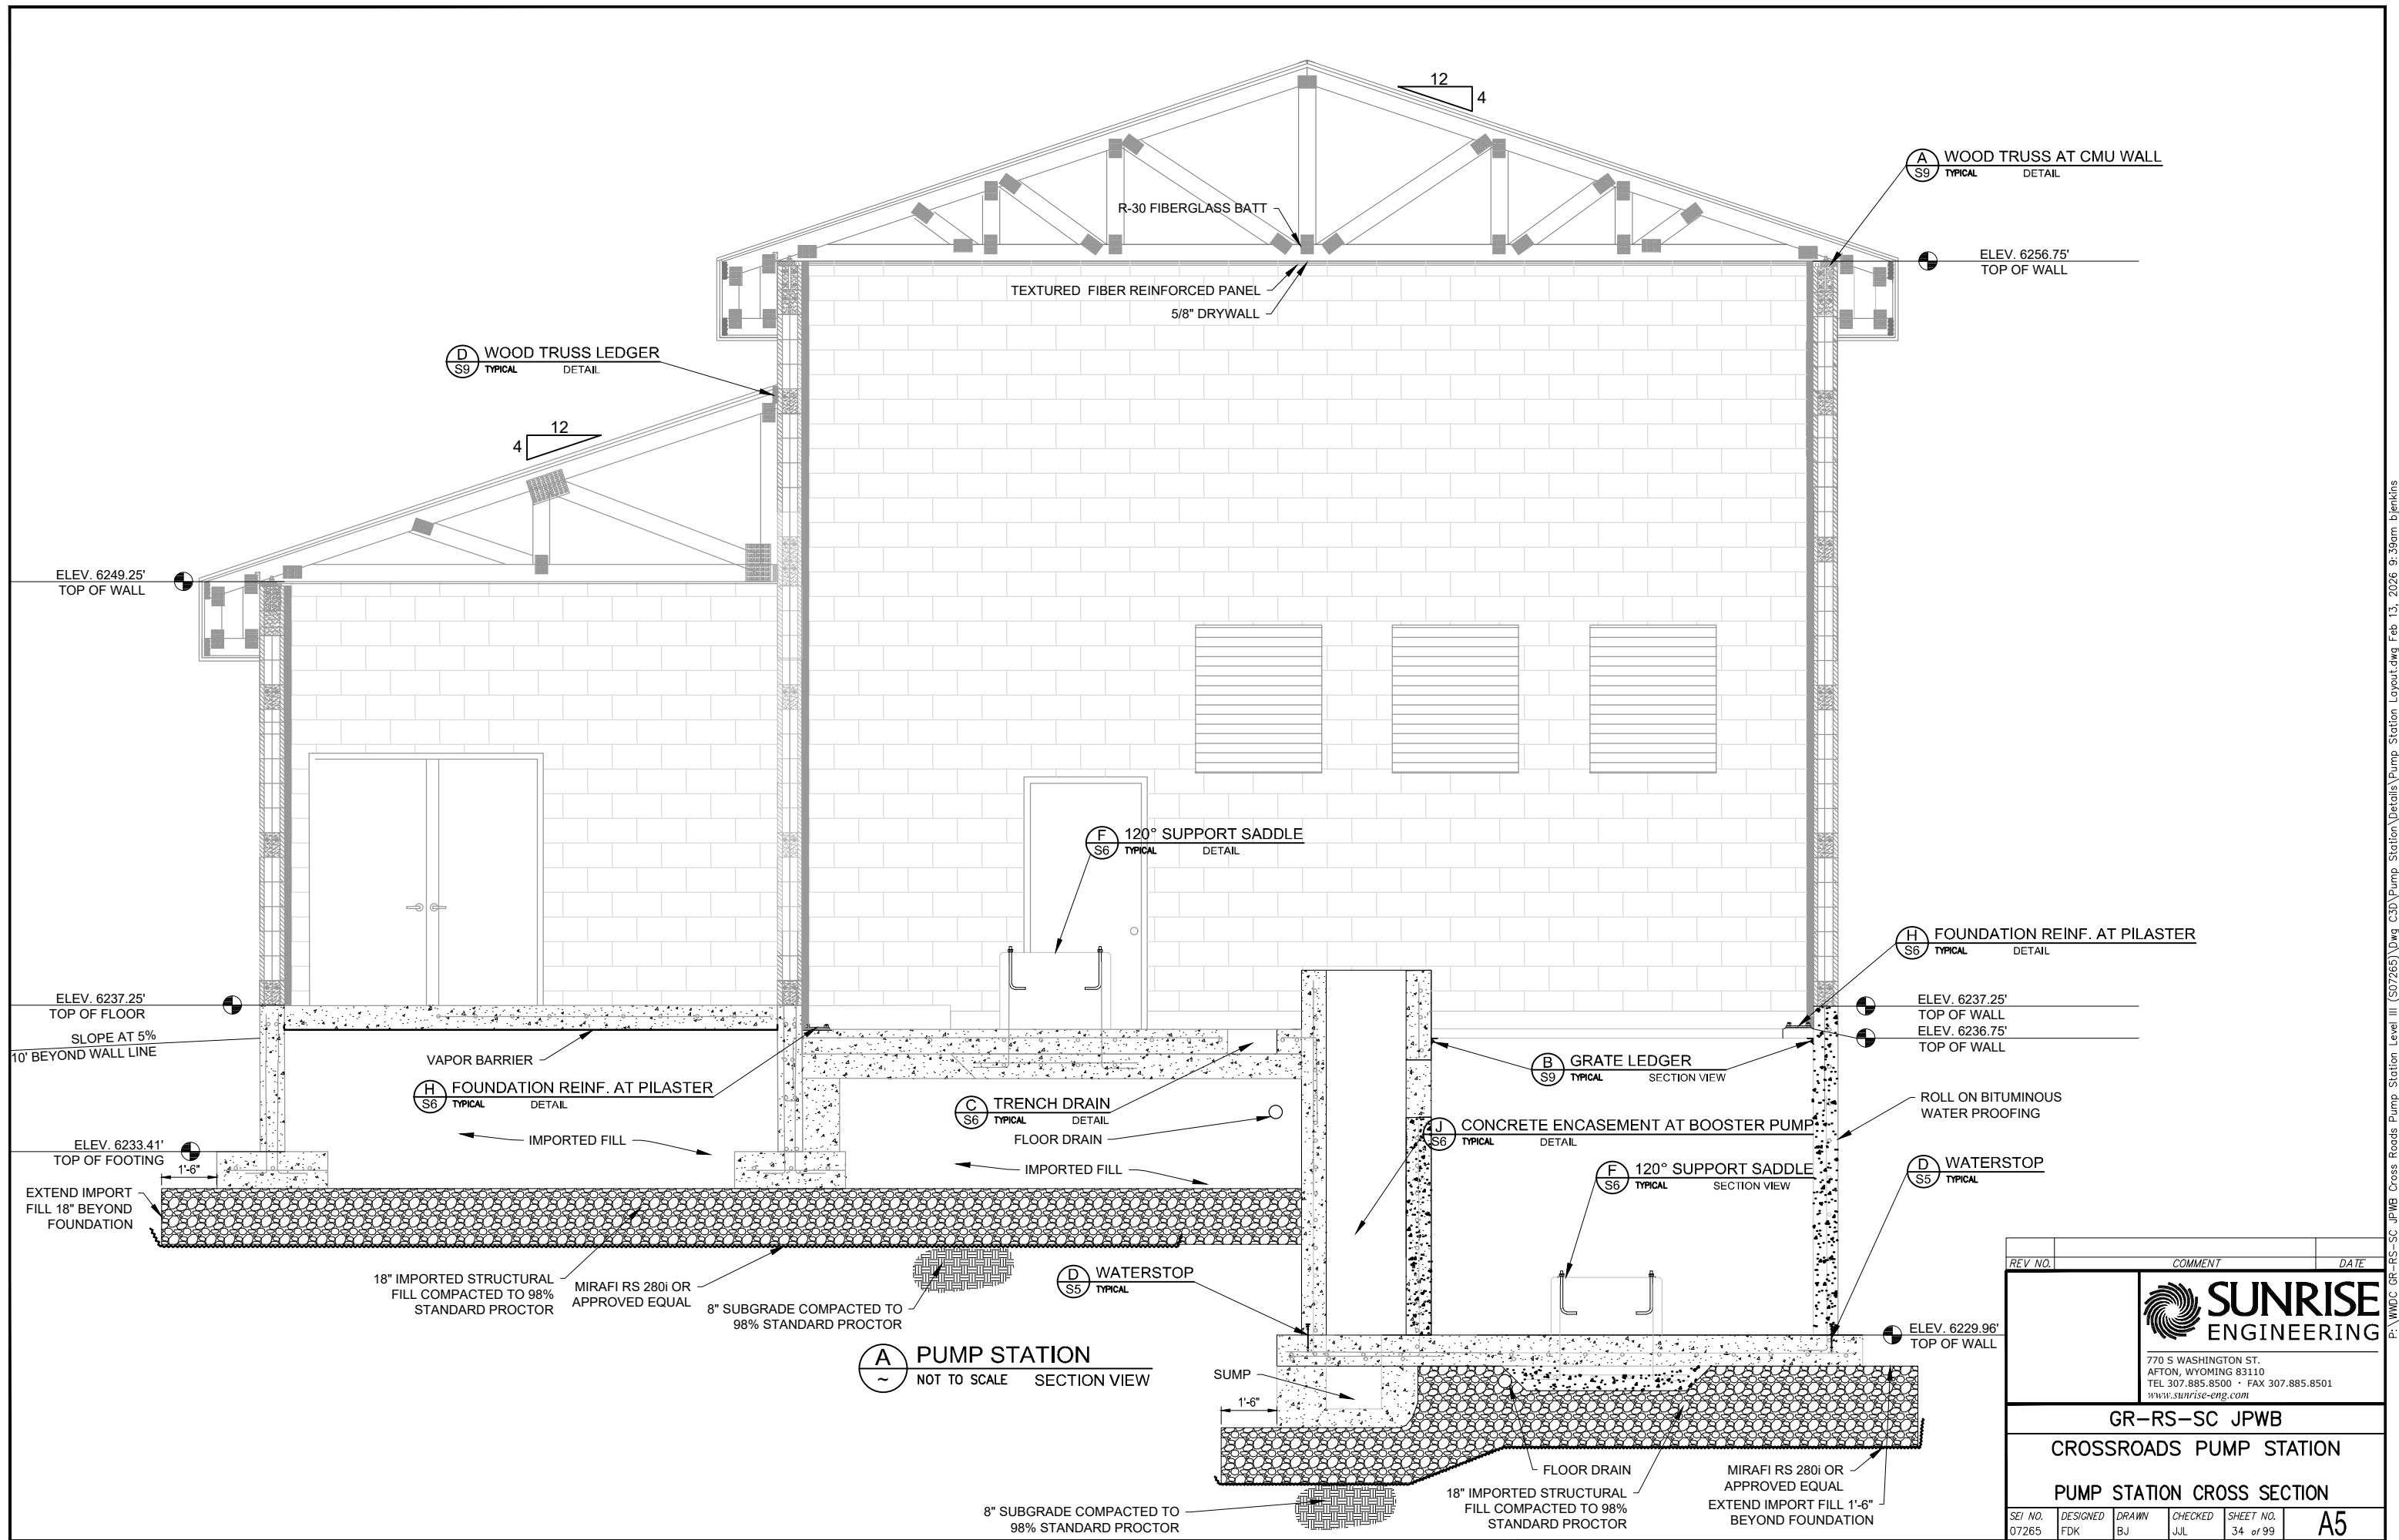

REV. NO.	COMMENT	DATE
SUNRISE ENGINEERING 770 S WASHINGTON ST. AFTON, WYOMING 83110 TEL 307.885.8500 • FAX 307.885.8501 www.sunrise-eng.com		
GR-RS-SC JPWB		
CROSSROADS PUMP STATION		
PUMP STATION CROSS SECTION		
SEI NO. 07265	DESIGNED FDK	DRAWN BJ
CHECKED JUL	SHEET NO. 34 of 99	A5

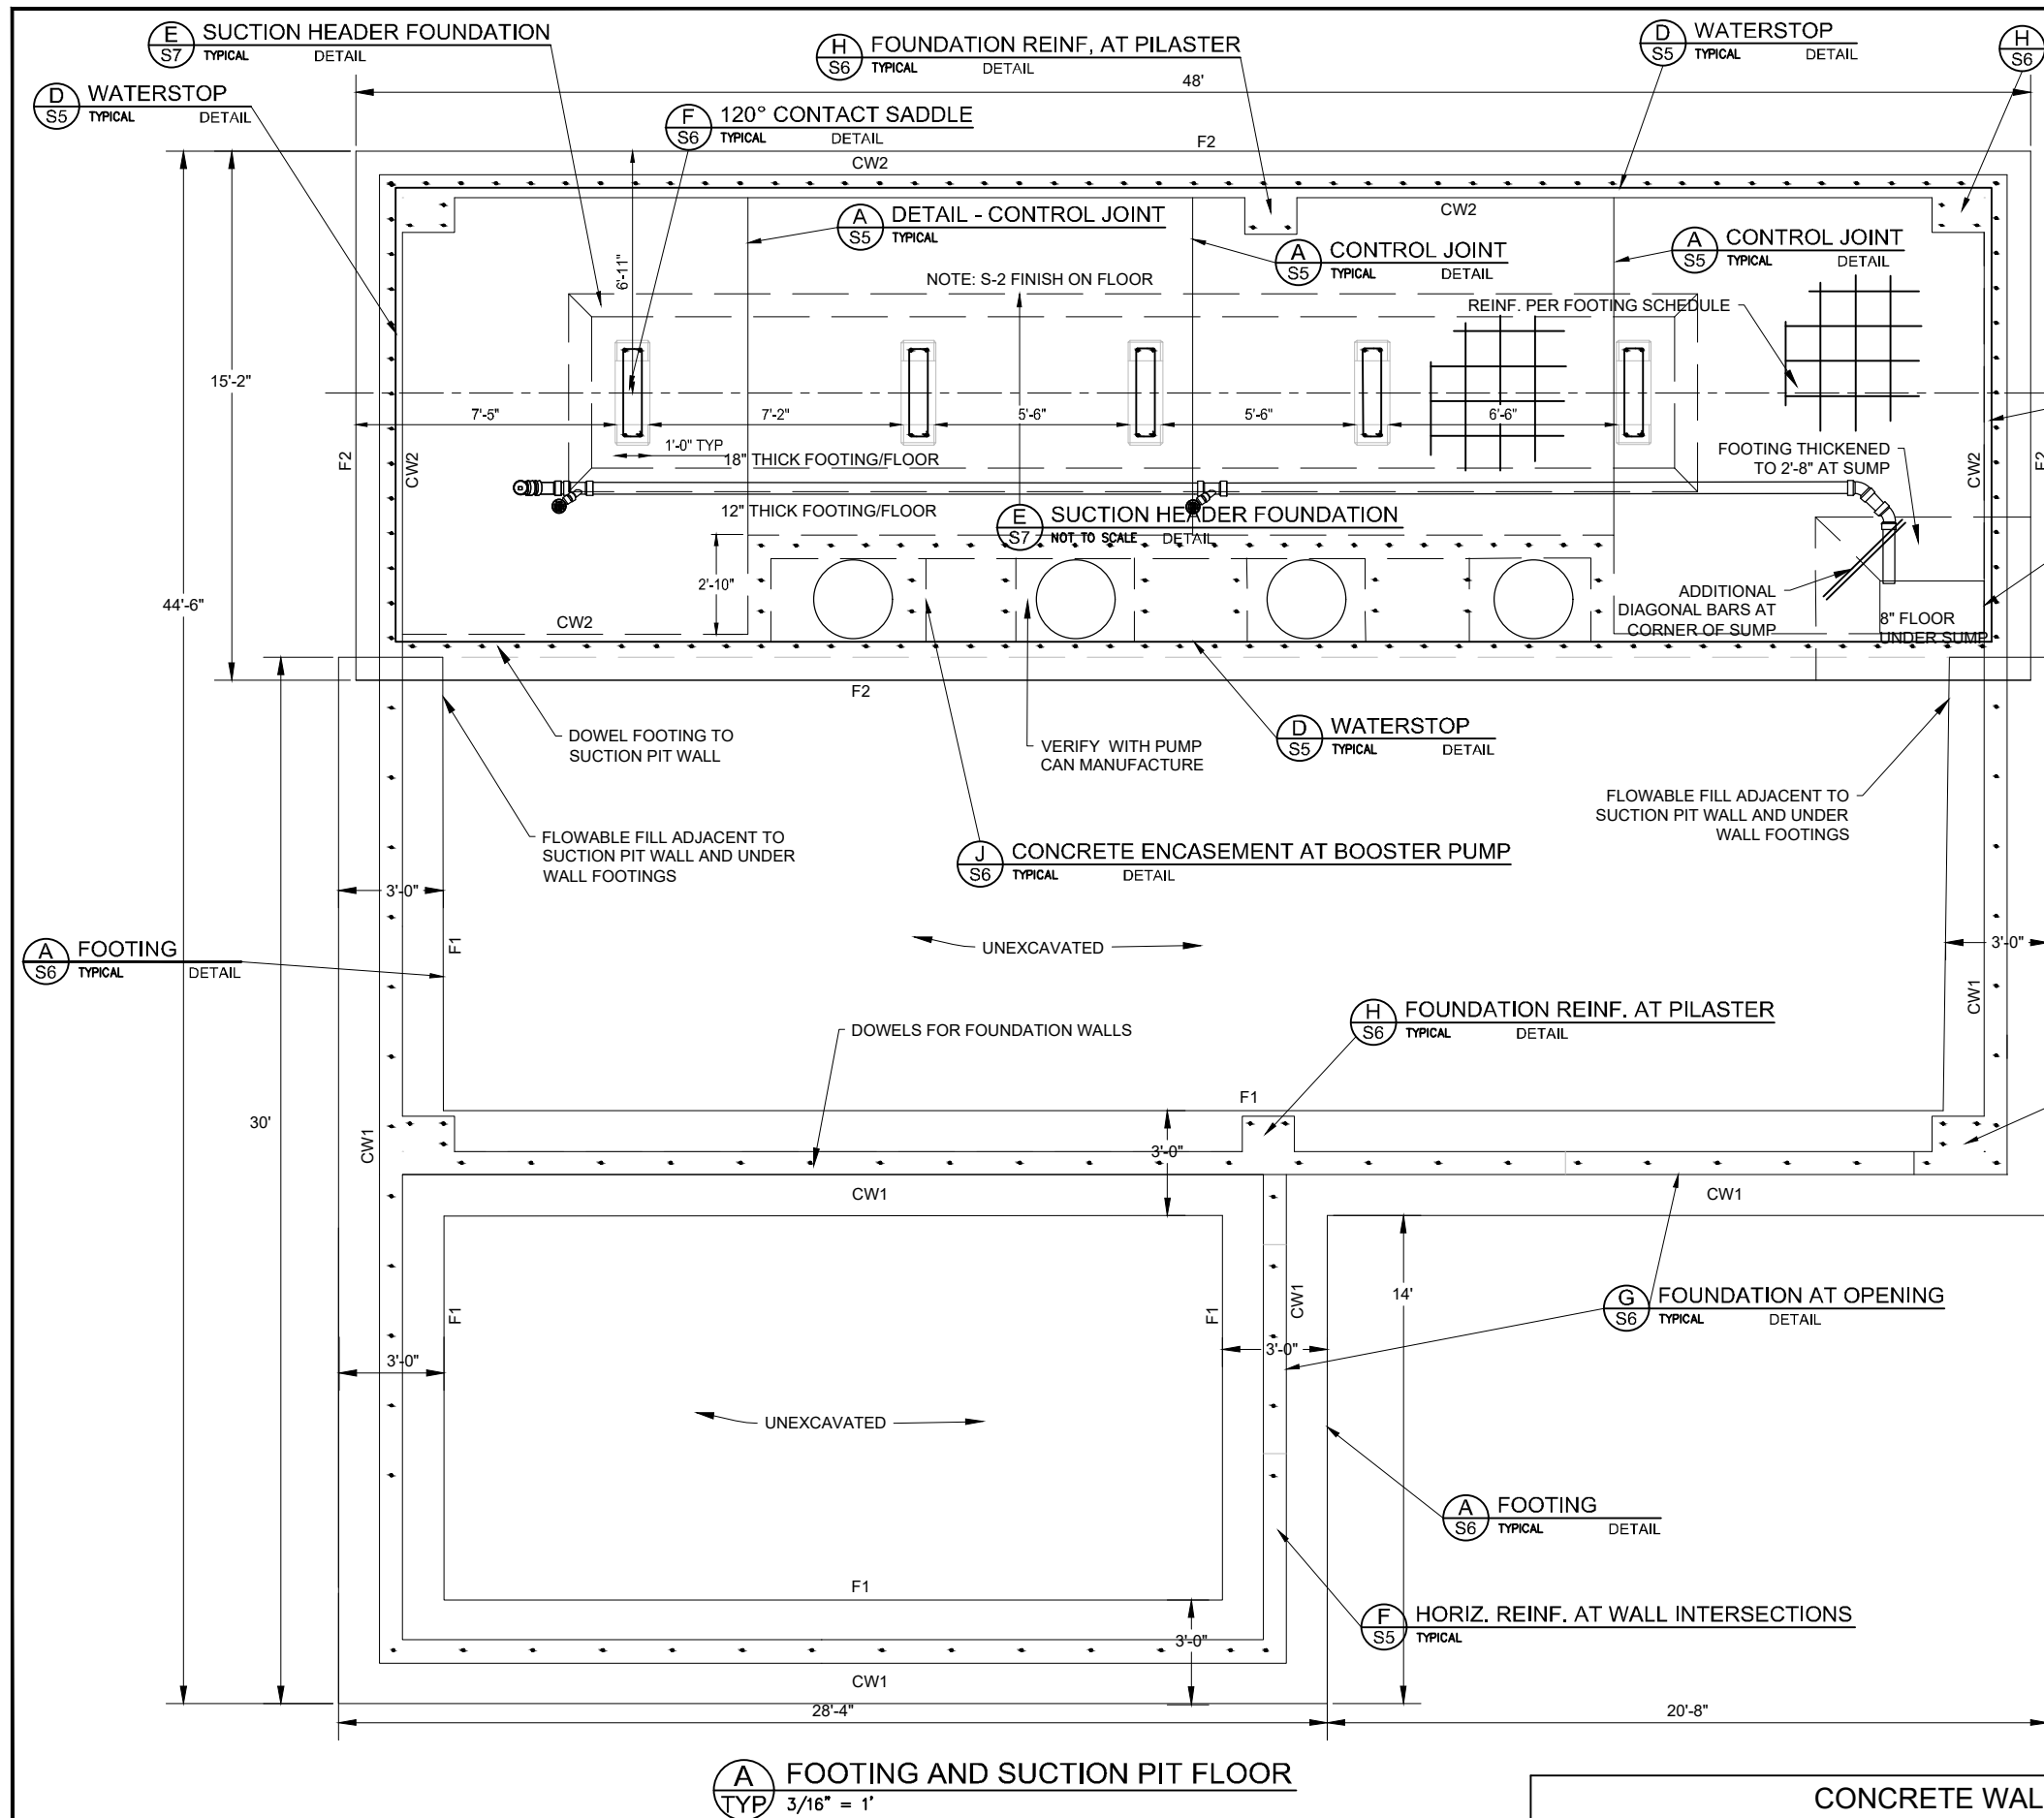

FOUNDATION REQUIREMENTS

1. VERIFY LOCATION AND SIZE OF ALL INSERTS AND OPENINGS IN SLAB, WALLS, AND FLOORS WITH MECHANICAL, PLUMBING, AND ELECTRICAL PRIOR TO CONSTRUCTION.
2. ALL FOOTINGS AND SLABS SHALL BE PLACED ON STRUCTURAL FILL AS DEFINED IN THE GEOTECHNICAL REPORT. THE MOISTURE CONTENT OF STRUCTURAL FILL SHALL BE CONDITIONED TO NEAR OPTIMUM WATER CONTENT, PLACED IN UNIFORM LIFTS NOT EXCEEDING 8 INCHES IN LOOSE THICKNESS, AND COMPACTED PER REQUIREMENTS OF THE GEOTECHNICAL REPORT.
3. ALL STANDARD WALL FOOTINGS SHALL EXTEND TO AT LEAST 48 INCHES BELOW FINISHED GRADE FOR FROST PROTECTION.
4. F1, F2, F3, ETC... DENOTES FOOTING PER FOOTING SCHEDULE ON THIS SHEET.
5. CW1, CW2, CW3, ETC... DENOTES CONCRETE WALL PER CONCRETE WALL SCHEDULE ON THIS SHEET.
6. CONCRETE CONTROL JOINTS SHALL BE AS SHOWN ON THESE DRAWINGS AND PER THE REFERENCED DETAILS.
7. CONCRETE CONTRACTOR TO REFER TO SHEET S2 FOR REQUIRED REINFORCEMENT TO MATCH MASONRY REINFORCEMENT.
8. PLACE SLABS ON GRADE OVER VAPOR BARRIER (AS REQ'D) PER THE GEOTECHNICAL REPORT.
9. BASEMENT CONCRETE SLAB SHALL BE 12 INCHES THICK WITH REINFORCEMENT AS SHOWN IN THE FOOTING SCHEDULE, UNLESS NOTED OTHERWISE.
10. FOR SMALL PIPES/CONDUITS, THROUGH FOUNDATION WALLS AND FOOTINGS, SEE PIPING PLANS.
11. CONCRETE LAP SPLICE REQUIREMENTS PER ACI 350.

FOOTING SCHEDULE					
MARK	WIDTH	LENGTH	THICKNESS	REINFORCEMENT	BOT OF FOOTING ELEV
F1	3'-0"	CONT.	1'-0"	(4) #5 CONT. AT BOTTOM	6232.41'
F2	SEE PLAN	SEE PLAN	1'-0"	#6 AT 10" OC BOTH WAYS TOP AND BOTTOM	6227.96'

CONCRETE WALL SCHEDULE					
MARK	THICKNESS	HEIGHT	VERT REINFORCING	HORIZ REINFORCING	TOP OF WALL ELEV
CW1	8"	4'-0"	#5 AT 16" O.C. "CENTERED"	#5 AT 18" O.C. "CENTERED"	6236.75'
CW2	8"	9'-0"	#5 AT 16" O.C. "CENTERED"	#5 AT 18" O.C. "CENTERED"	6236.75'

REV NO.	COMMENT	DATE
 SUNRISE ENGINEERING 770 S WASHINGTON ST. AFTON, WYOMING 83110 TEL 307.885.8500 · FAX 307.885.8501 www.sunrise-eng.com		
GR-RS-SC JPWB		
CROSSROADS PUMP STATION		
FOOTINGS AND FOUNDATION PLAN		
SEI NO. 07265	DESIGNED FDK	DRAWN BJ
CHECKED JUL	SHEET NO. 35 of 99	S1


MASONRY REQUIREMENTS


1. ML DENOTES MASONRY LINTEL PER (E S6)
2. MJ DENOTES MASONRY JAMB PER (B S7)
3. MASONRY CONTROL JOINTS (MCJ) SHALL BE PLACED IN MASONRY WALLS WHERE SPECIFICALLY SHOWN ON DRAWINGS AND AT ALL INTERIOR TO EXTERIOR WALL INTERSECTIONS. SEE (H S7) TO COORDINATE EXACT LOCATION OF CONTROL JOINTS WITH CIVIL PLANS.
4. SEE DETAIL (A S7) FOR VERTICAL REINFORCEMENT REQUIREMENTS AT CORNERS. SEE NOTE ON THIS PAGE, AND DETAIL (C S7) FOR HORIZONTAL REINFORCEMENT REQUIREMENTS AT WALL AND INTERSECTIONS.
5. VERIFY ALL DIMENSIONS, ELEVATIONS, SLOPES, ETC W/ ARCHITECTURAL AND/OR CIVIL PLANS PRIOR TO CONSTRUCTION. RESOLVE DISCREPANCIES AND CONFLICTS WITH ENGINEER OF RECORD.
6. REINFORCING IN MASONRY WALL SHALL BE LAPPED WITH REINFORCEMENT FROM CONCRETE WALL BELOW.
7. HORIZONTAL REINFORCING IN WALL SHALL BE CONTINUOUS, EXCEPT AT CONTROL JOINTS. BOND BEAMS AT TOP AND BOTTOM OF WALL TO RUN CONTINUOUS THROUGH CONTROL JOINTS.
8. EXTERIOR WALLS AND PUMP ROOM SEPARATION WALL SHALL BE SOLID GROUTED. INTERIOR WALLS TO BE GROUTED AT ALL VERTICAL REINFORCING AND BOND BEAMS PER GENERAL STRUCTURAL NOTES, UNLESS NOTED OTHERWISE.
9. ANCHOR BOLTS AT TOPS OF WALL SHALL BE PER MASONRY WALL SCHEDULE.
10. SEE MASONRY REINFORCING SPLICE SCHEDULE (G S7)

MASONRY WALL REINFORCEMENT NOTE:

MASONRY WALL UNITS SHALL BE 10"X 8"X 16" CMU
TYPICAL VERTICAL REINFORCEMENT SHALL BE #5 WITH SPACING SHOWN ON TABLE. (S7, DETAIL A) MASONRY LINTEL AND JAMB TABLES PROVIDED AND SHOWN ON DRAWINGS. PROVIDE (1) #5 IN BOND BEAM AT BOTTOM, AT 4'-8", 8'-8", 12'-8" AND 16'-8" LIFTS FOR HORIZONTAL REINFORCEMENT. PROVIDE (2) #5 IN BOND BEAM AT TOP COURSE OF WALL.

REV. NO.	COMMENT	DATE
 SUNRISE ENGINEERING 770 S WASHINGTON ST. AFTON, WYOMING 83110 TEL 307.885.8500 • FAX 307.885.8501 www.sunrise-eng.com		
GR-RS-SC JPWB		
CROSSROADS PUMP STATION MASONRY WALL LAYOUT AND REINFORCEMENT		
SEI NO. 07265	DESIGNED FDK	DRAWN BJ
CHECKED JUL	SHEET NO. 37 of 99	S3

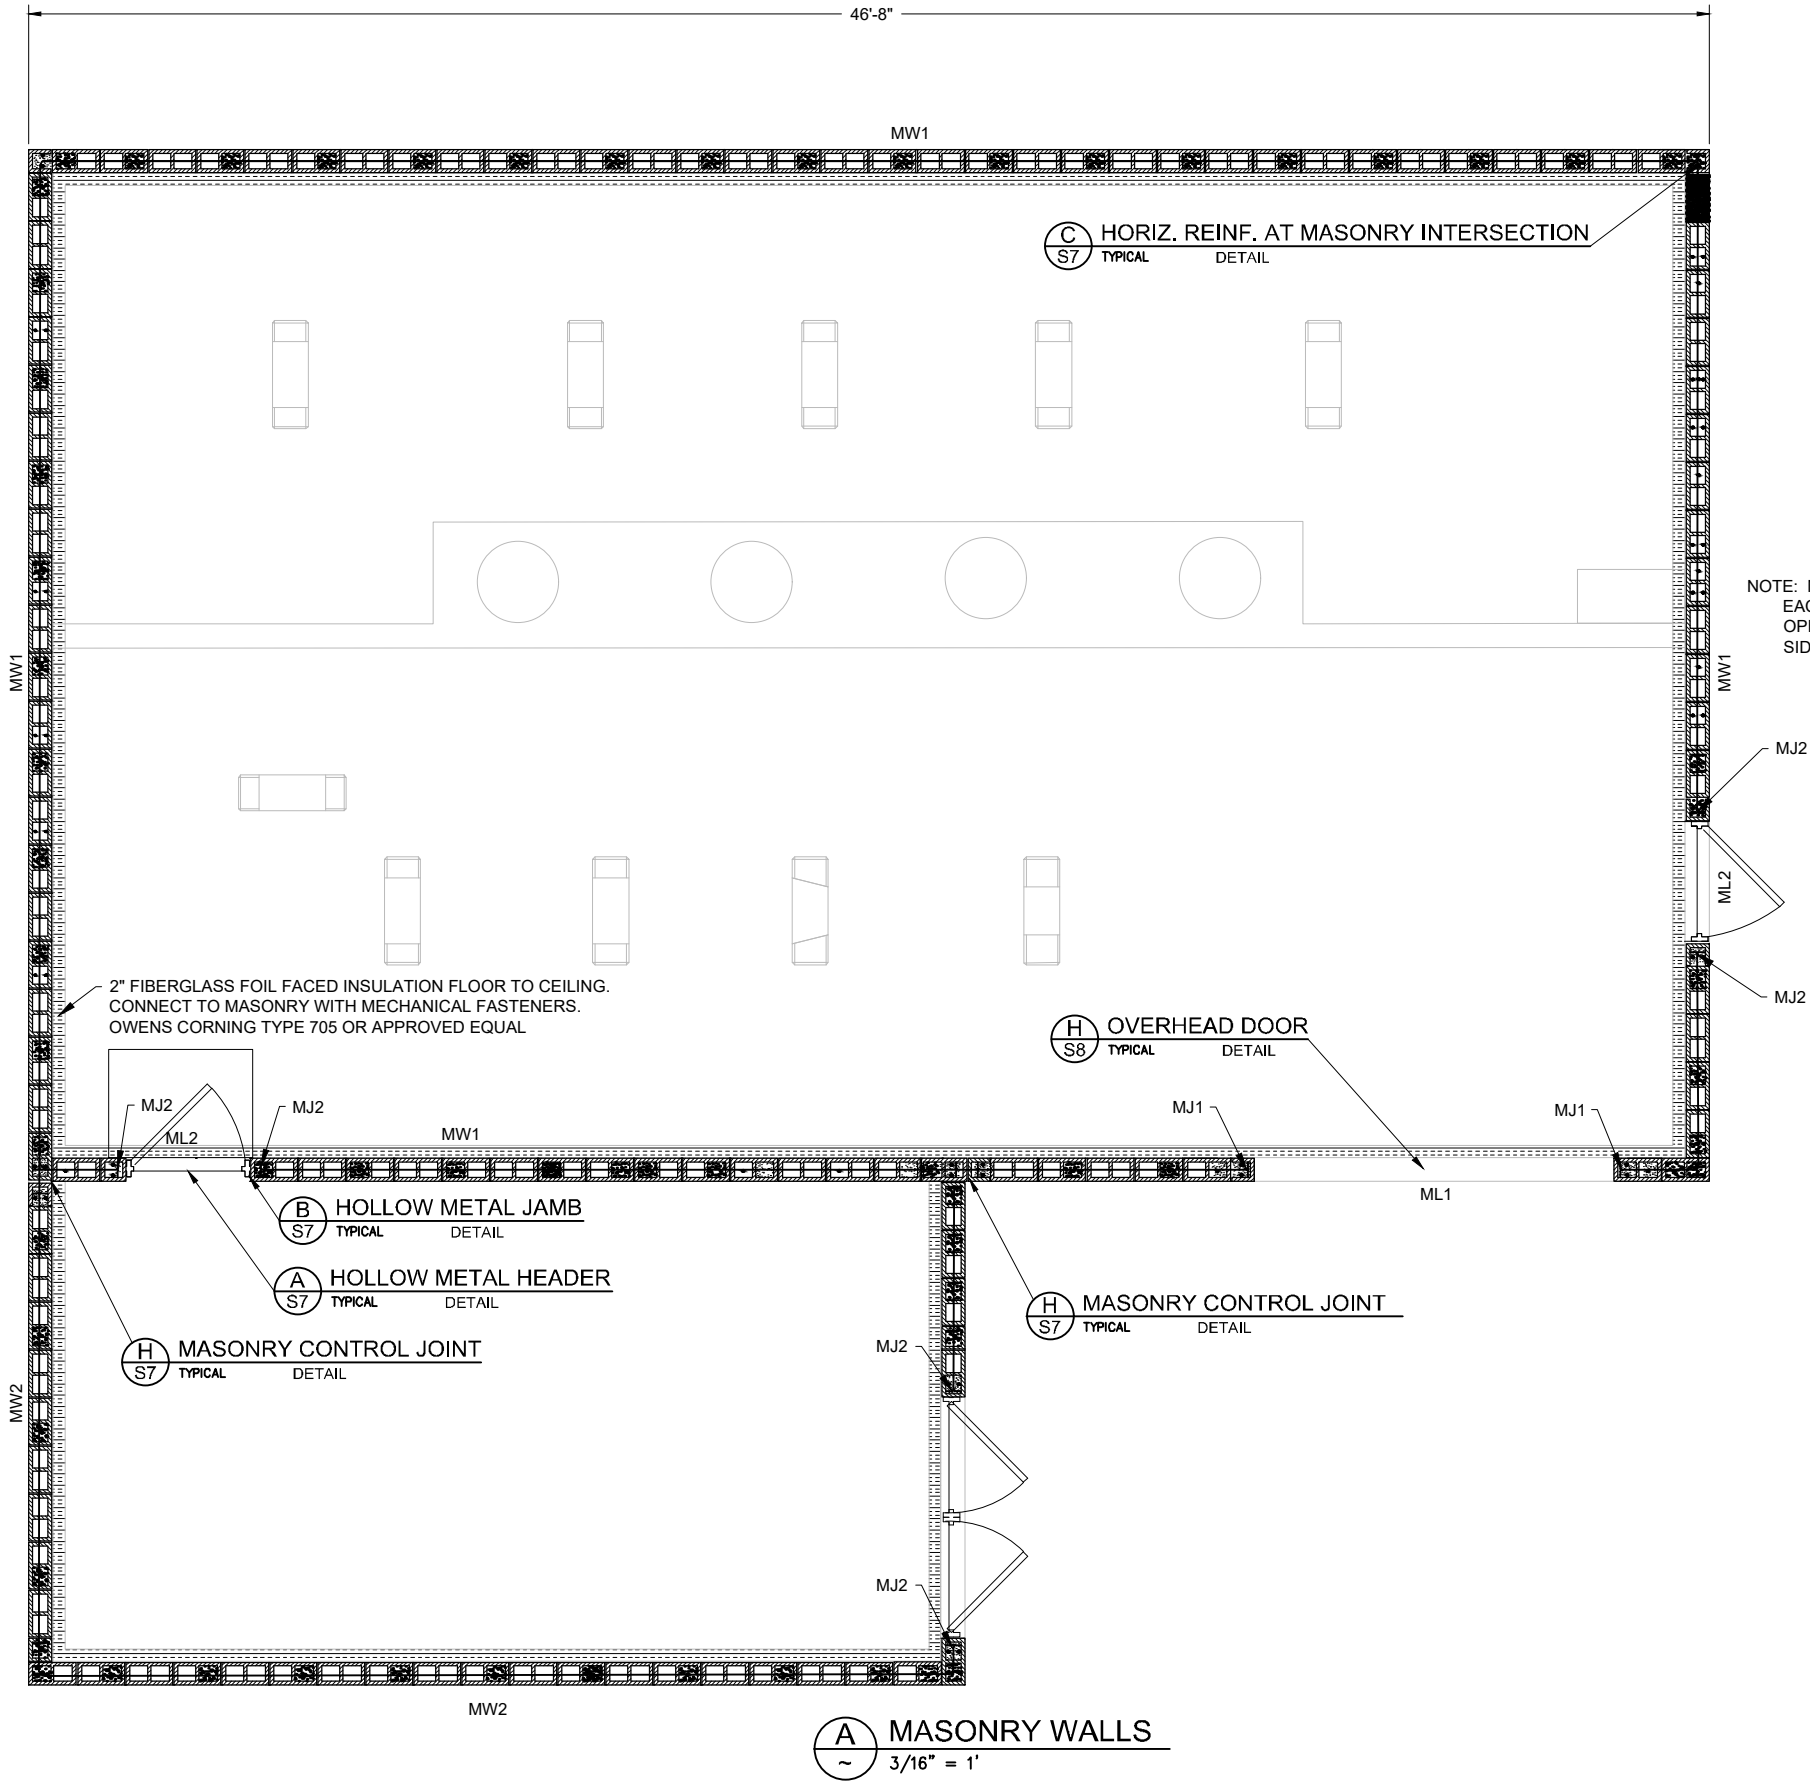

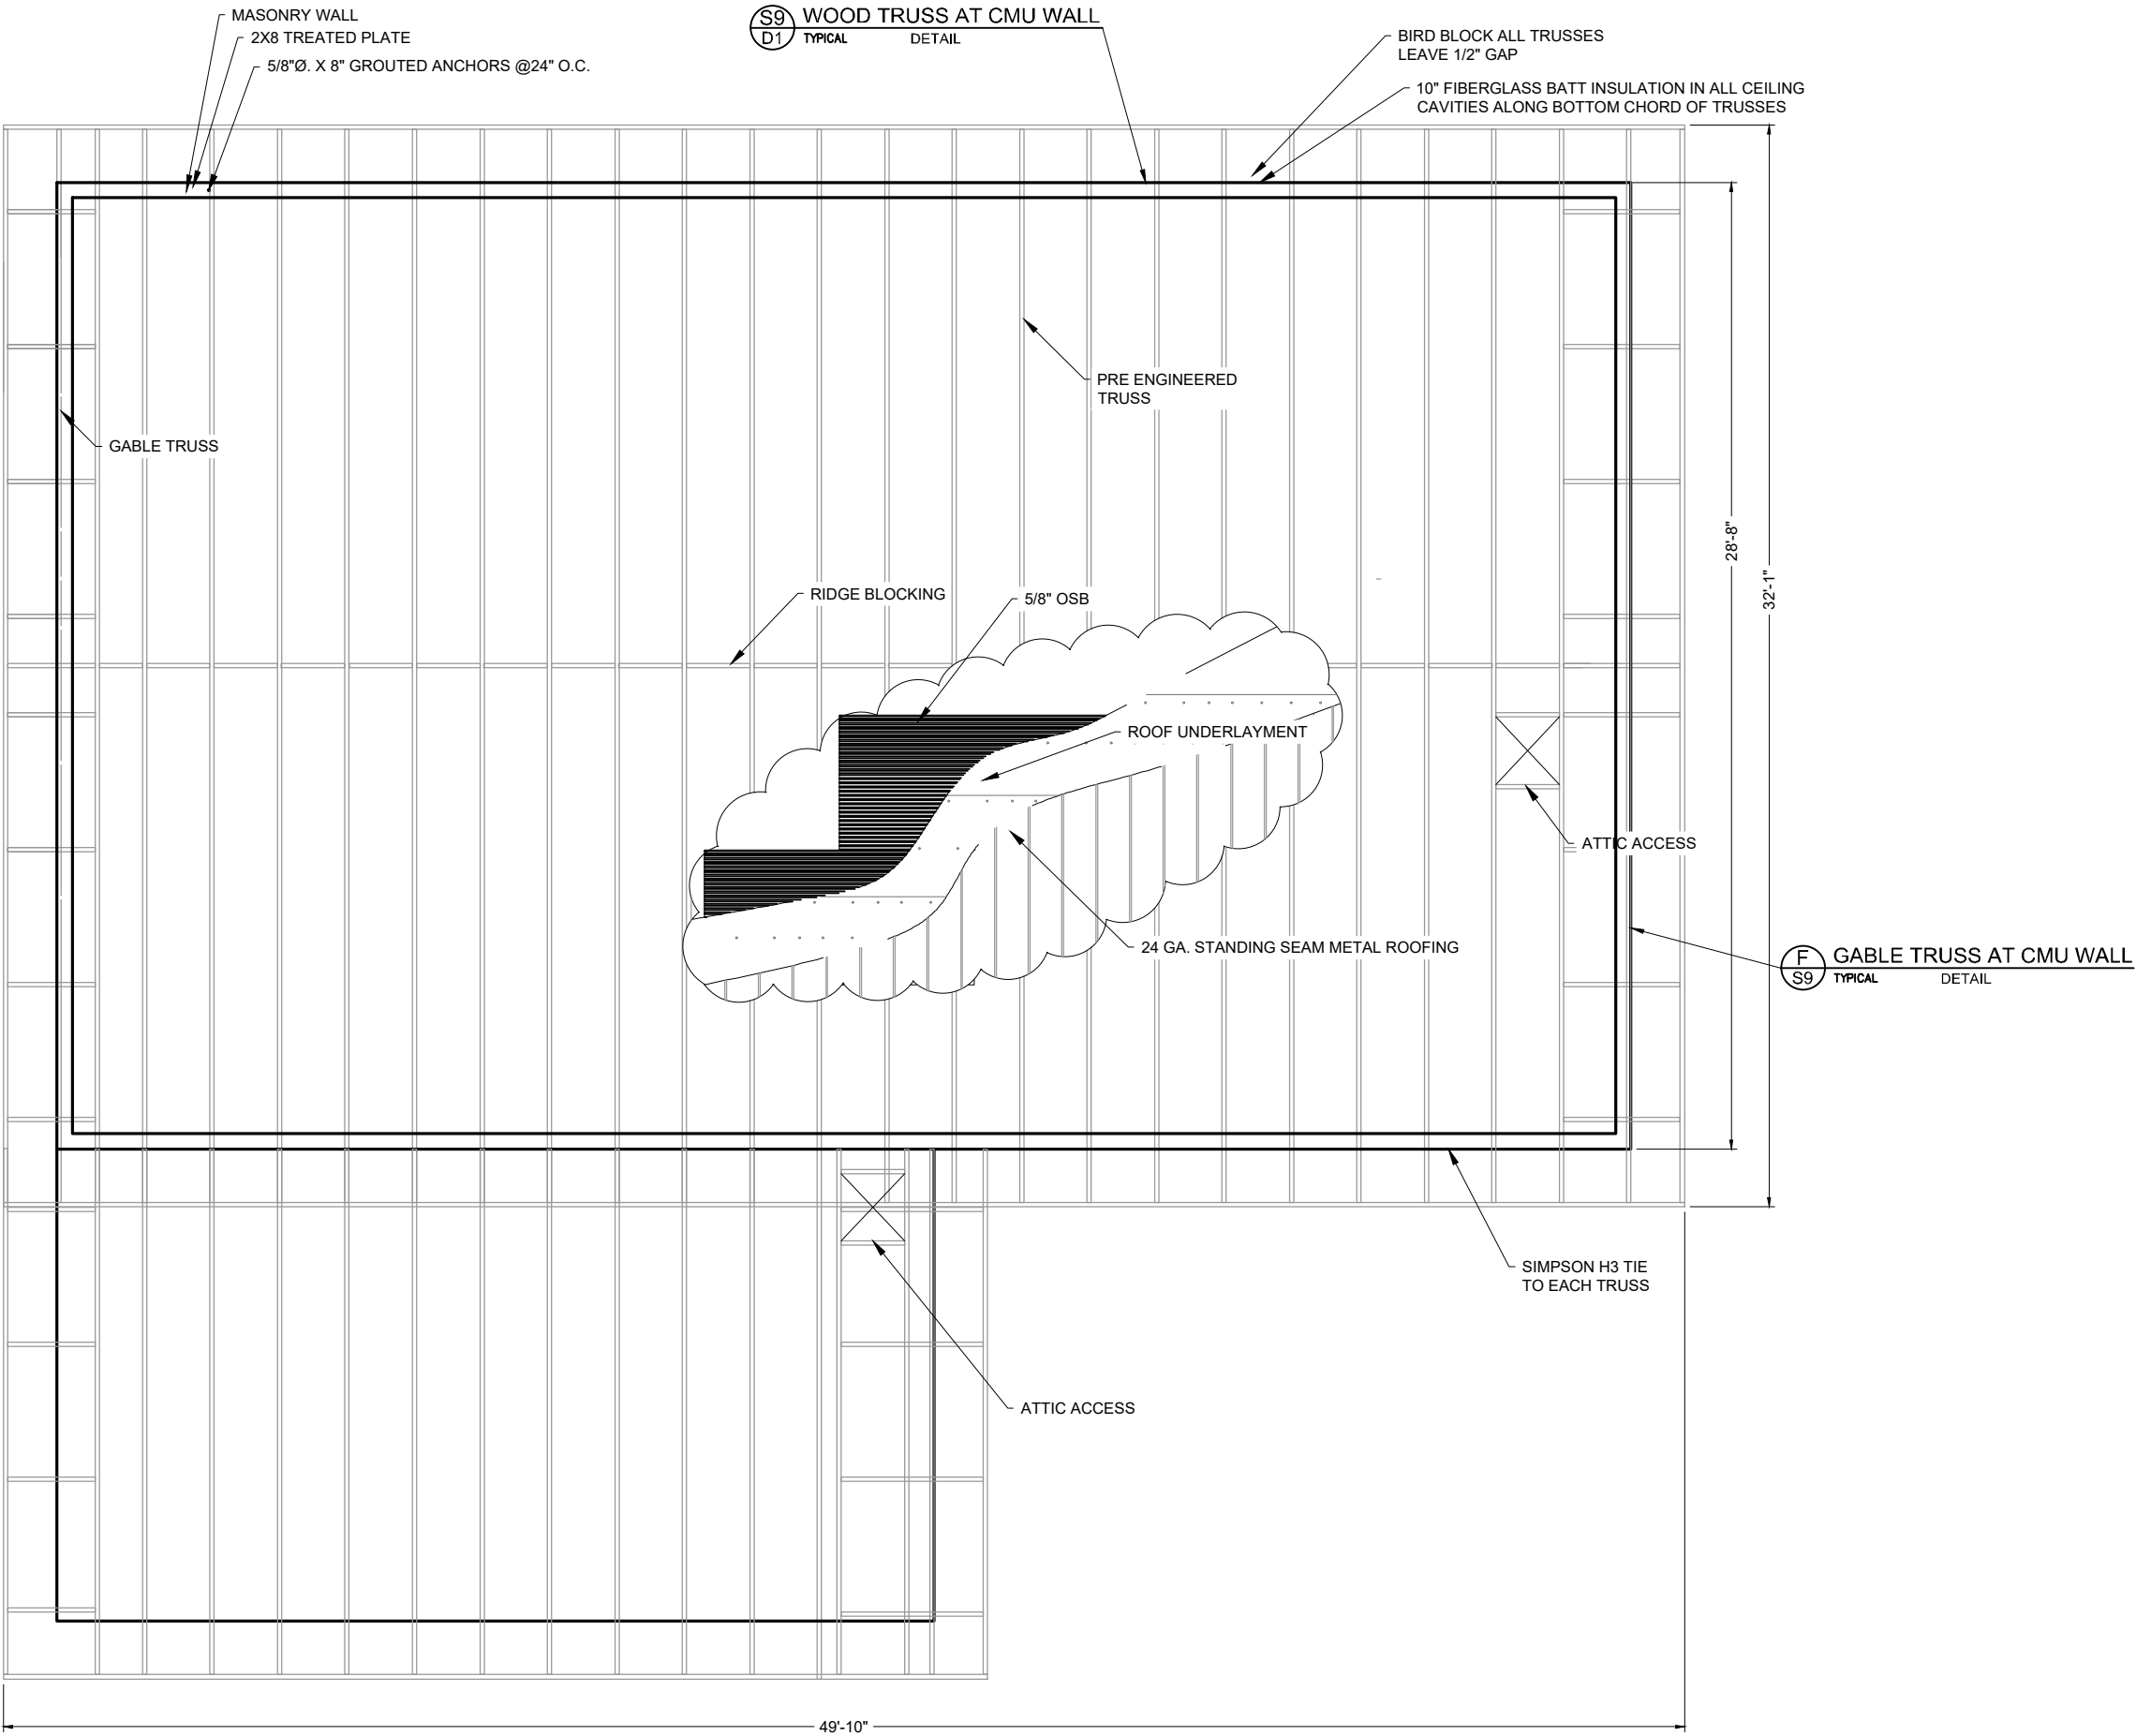


ROOF FRAMING REQUIREMENTS

1. NOTIFY ENGINEER OF RECORD FOR PENETRATIONS THROUGH BEAMS, JOISTS, COLUMNS AND OTHER STRUCTURAL MEMBERS. PENETRATIONS SHALL COMPLY WITH THE REQUIREMENTS OF THE ENGINEER AND MANUFACTURER OF THE STRUCTURAL ELEMENT.
2. ALL BEAMS, HEADERS, JOISTS, AND TRUSSES SHALL HAVE SUFFICIENT BEARING AREA PER REQUIREMENTS OF THE AMERICAN WOOD COUNCIL NATIONAL DESIGN SPECIFICATION (NDS) 2018. ALL BEARING POINTS SHALL HAVE A CONTINUOUS LOAD PATH TO FOUNDATIONS.
3. ALL FINISHES SHALL BE PER THE OWNER. ENGINEER OF RECORD IS NOT RESPONSIBLE FOR WATER PROOFING AND CORROSION PROTECTION OF STRUCTURAL ELEMENTS. THIS RESPONSIBILITY FALLS SOLELY UPON THE CONTRACTOR.
4. ALL HARDWARE SHOWN ON THE DRAWINGS SHALL BE SIMPSON STRONG TIE OR APPROVED EQUAL.
5. ROOF FRAMING MEMBERS SHOWN ON DRAWINGS SHALL BE PREFABRICATED WOOD TRUSSES SPACED AT 24" OC, SEE THE GSN ROOF PITCH (4/12).
6. PROVIDE 1/2" PLYWOOD SHEATHING TO BOTTOM CHORD OF ROOF JOISTS/TRUSS W/ R-30 INSULATION BETWEEN EACH MEMBER.

ROOF SHEATHING REQUIREMENTS:


- 1- 5/8" OSB PLYWOOD OR OSB PER GSN
- 2- 8D AT 6" OC BOUNDARY FASTENERS (DIAPHRAGM BOUNDARIES, SHEAR PANEL BLOCKING, SOLID BLOCKING, AND DRAG MEMBERS AS NOTED ON FRAMING DETAILS)
- 3- 8D AT 6" OC EDGE FASTENERS (AT SUPPORTED PANEL EDGES)
- 4- 8D AT 12" OC FIELD FASTENERS (ALONG INTERMEDIATE FRAMING MEMBERS)
- 5- ALT FASTENERS #8 X 2" MIN ZINC COATED, FLAT/BUGLE HEAD SCREWS W/ SPACING NOTED ABOVE. SCREWS SHALL BE QUICK DRIVE WSNTL WOOD SCREWS, GRABBER PLYWOOD SCREWS, OR GRABBER COARSE THREAD SCREWS.

REV. NO.	COMMENT	DATE
SUNRISE ENGINEERING 770 S WASHINGTON ST. AFTON, WYOMING 83110 TEL 307.885.8500 · FAX 307.885.8501 www.sunrise-eng.com		
GR-RS-SC JPWB		
CROSSROADS PUMP STATION		
ROOF FRAMING PLAN		
SEI NO. 07265	DESIGNED FDK	DRAWN BJ
CHECKED JUL	SHEET NO. 38 of 99	S4

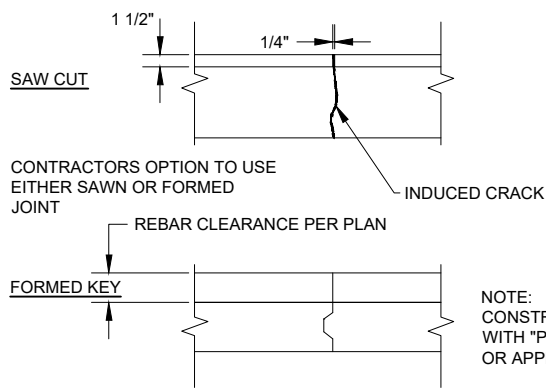


A CONTROL JOINT IN SLAB
TYPICAL DETAIL

NOTE:
CONSTRUCTION JOINTS MADE
WITH "PNA DIAMOND DOWELS"
OR APPROVED EQUAL

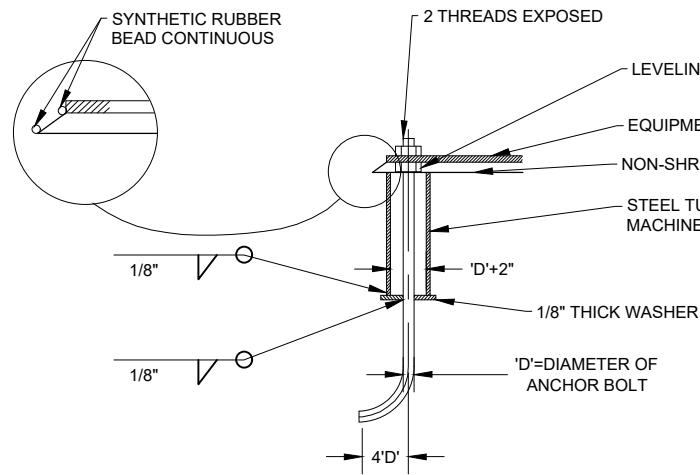


B EQUIPMENT ANCHOR
TYPICAL DETAIL


NOTE:
ANCHOR BOLT SIZE AND LENGTH AS
INDICATED ON THE DETAILED PLANS. IF SIZE
AND LENGTH ARE NOT SPECIFIED ANCHOR
BOLTS SHALL BE AS RECOMMENDED BY THE
EQUIPMENT MFR. WHERE ANCHOR BOLT
DEPTH CANNOT BE PROVIDED BECAUSE OF
CONCRETE SLAB OR BEAM THICKNESS
PROVIDE EXTRA THICKNESS IN SLAB OR
BEAM TO ACCOMMODATE ANCHOR BOLT.

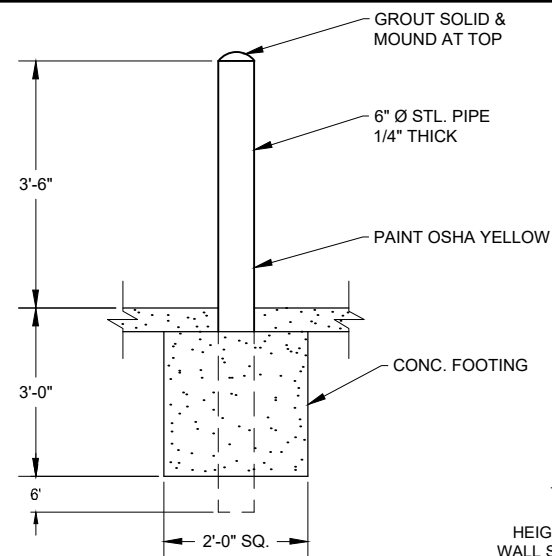


C BOLLARD AT PUMP STATION
TYPICAL DETAIL

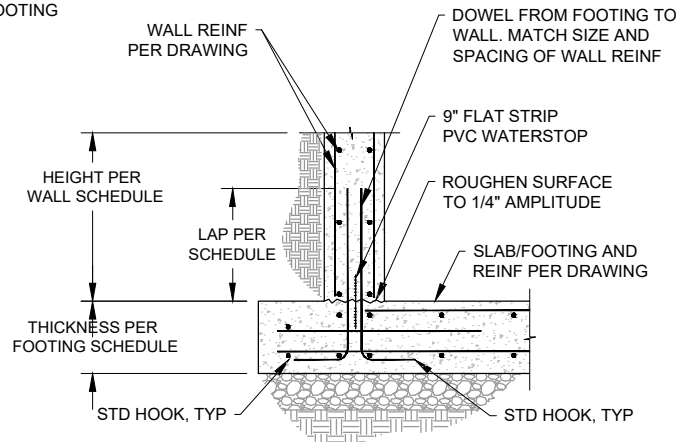

D WATERSTOP
TYPICAL DETAIL

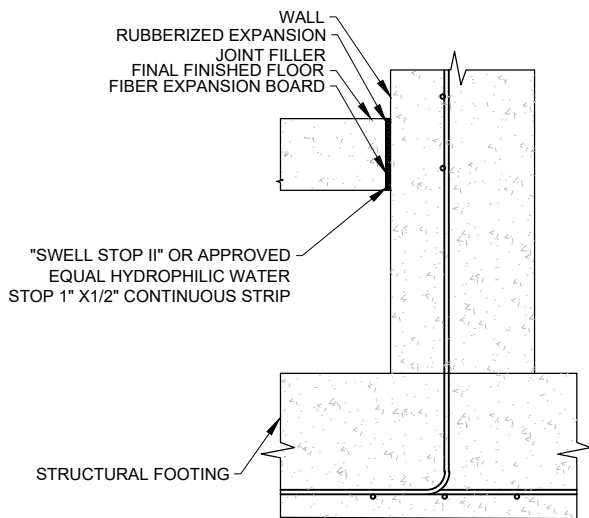

E EXPANSION JOINT
TYPICAL DETAIL

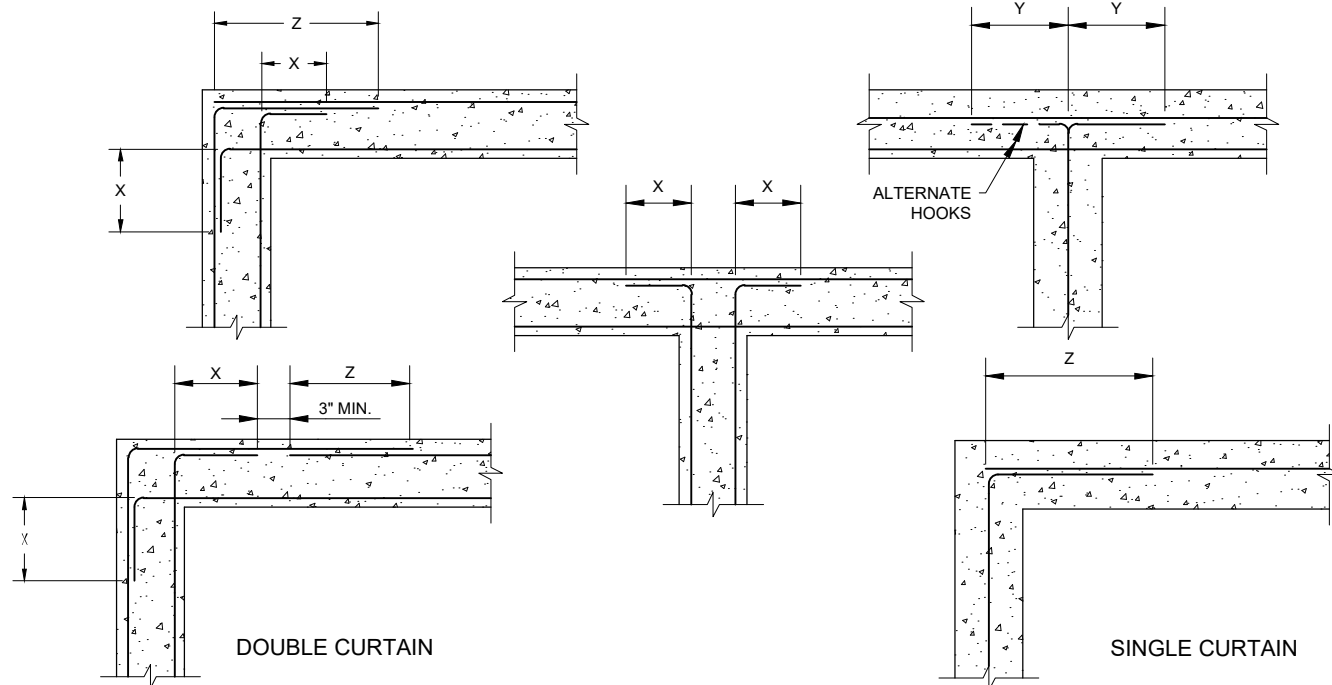


BAR SIZE	GRADE 40		GRADE 60		BAR SIZE	GRADE 40		GRADE 60	
	Y	Z	Y	Z		Y	Z	Y	Z
# 4	12"	20"	12"	20"	# 7	18"	31"	23"	39"
# 5	12"	20"	15"	26"	# 8	23"	39"	30"	51"
# 6	13"	22"	18"	31"	# 9	29"	49"	38"	65"

F HORIZ. REINF. AT WALL INTERSECTIONS
TYPICAL DETAIL


* THIS DETAIL TO BE USED ONLY WHEN NO OTHER DETAIL IS INDICATED ON THE DRAWINGS.

1. TOP BARS ARE HORIZ. BARS PLACED SUCH THAT MORE THAN 12" OF FRESH CONCRETE IS CAST IN MEMBER BELOW SPLICE
2. WHERE BARS OF UNEQUAL SIZE LAP ONE ANOTHER, USE TABULATED LAP LENGTH FOR SMALLER BAR U.N.O.
3. LAP SPLICE LENGTH PER SCHEDULE
4. CLEAR DISTANCE BETWEEN ADJACENT BARS OR SPLICES TO BE USED IN DETERMINING APPLICABLE LAP LENGTH FROM SCHEDULE
5. OPTIONAL OFFSET. SEE STANDARD REBAR BEND DETAILS FOR OFFSET REQUIREMENTS
6. FOR NON-CONTACT LAP SPLICES, MIN. CLEAR DISTANCE BETWEEN SPLICED BARS SHALL BE PER GENERAL STRUCTURAL NOTES. MAX. CLEAR DISTANCE SHALL BE 1/5 THE TABULATED LAP LENGTH OR (6" - "DB"), WHICHEVER IS LESS, WHERE "DB" = BAR DIA.

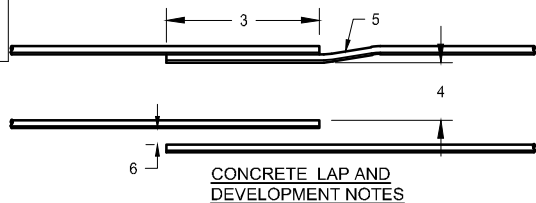

H STD. HOOK GEOMETRY
TYPICAL DETAIL


(1)- A STANDARD HOOK FOR DEFORMED BARS IN TENSION INCLUDES THE SPECIFIC INSIDE BEND DIAMETER AND STRAIGHT EXTENSION LENGTH. IT SHALL BE PERMITTED TO USE A LONGER STRAIGHT EXTENSION AT THE END OF A HOOK. A LONGER EXTENSION SHALL NOT BE CONSIDERED TO INCREASE THE ANCHORAGE CAPACITY OF THE HOOK.

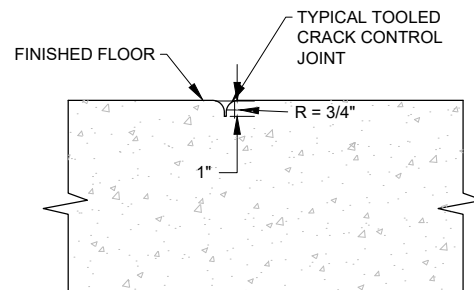


NOTE:
SPACE CONTROL & OR CONSTRUCTION JOINTS
@ 25'-0" O.C. MAX. EA. WAY U.N.O. ON PLANS.

G FLOOR CRACK CONTROL JOINT
TYPICAL DETAIL


REV. NO.	COMMENT	DATE
SUNRISE ENGINEERING 770 S WASHINGTON ST. AFTON, WYOMING 83110 TEL 307.885.8500 · FAX 307.885.8501 www.sunrise-eng.com		
GR-RS-SC JPWB		
CROSSROADS PUMP STATION		
MASONRY BUILDING DETAILS		
SEI NO. 07265	DESIGNED FDK	DRAWN BJ
CHECKED JUL	SHEET NO. 39 of 99	S5

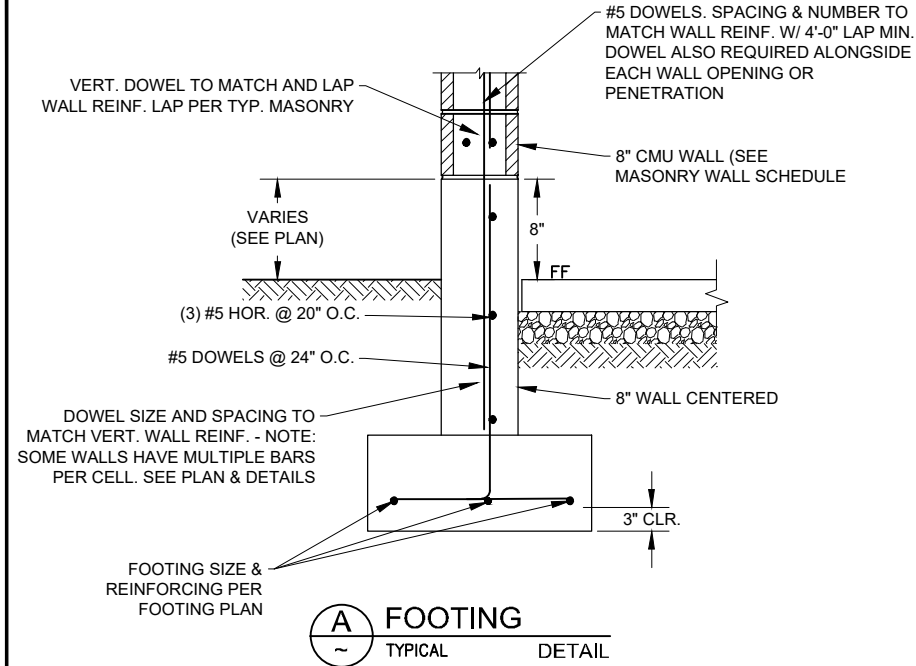


A FOOTING
TYPICAL DETAIL

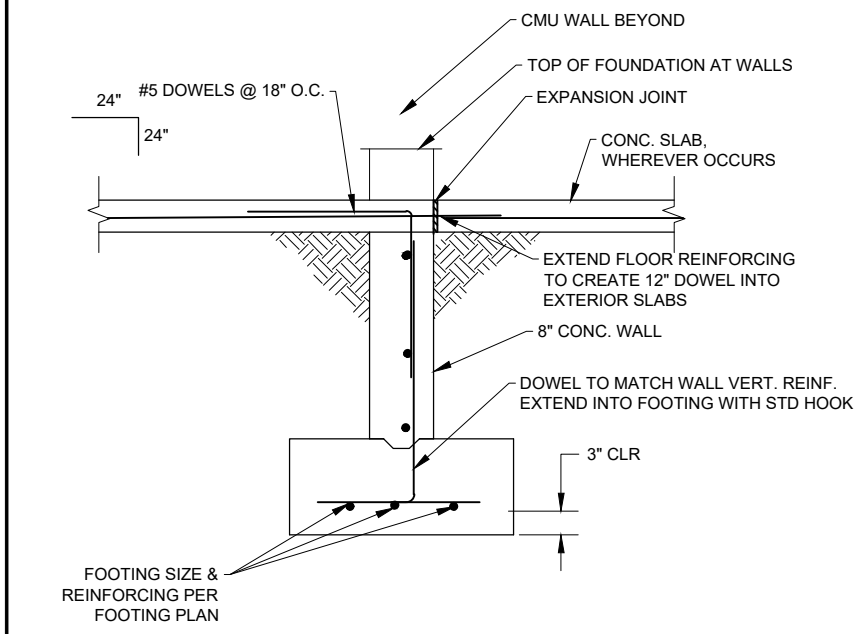


G FOUNDATION AT OPENING
TYPICAL DETAIL

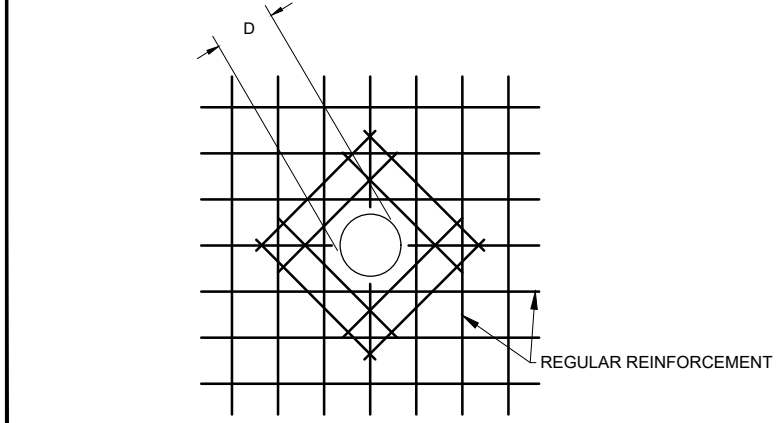


I EXTRA REINF. AT PIPE PENETRATIONS
TYPICAL DETAIL

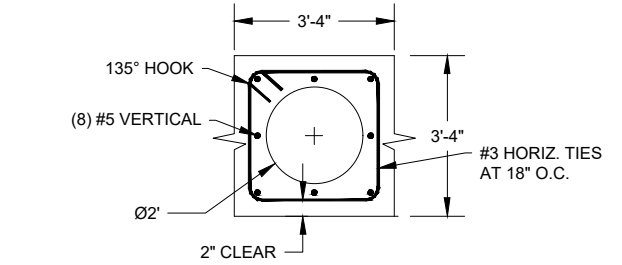


B CONCRETE PUMP CAN ENCASEMENT
TYPICAL PLAN VIEW

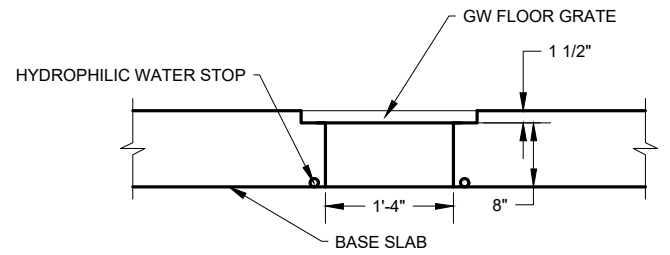


C TRENCH DRAIN
TYPICAL DETAIL

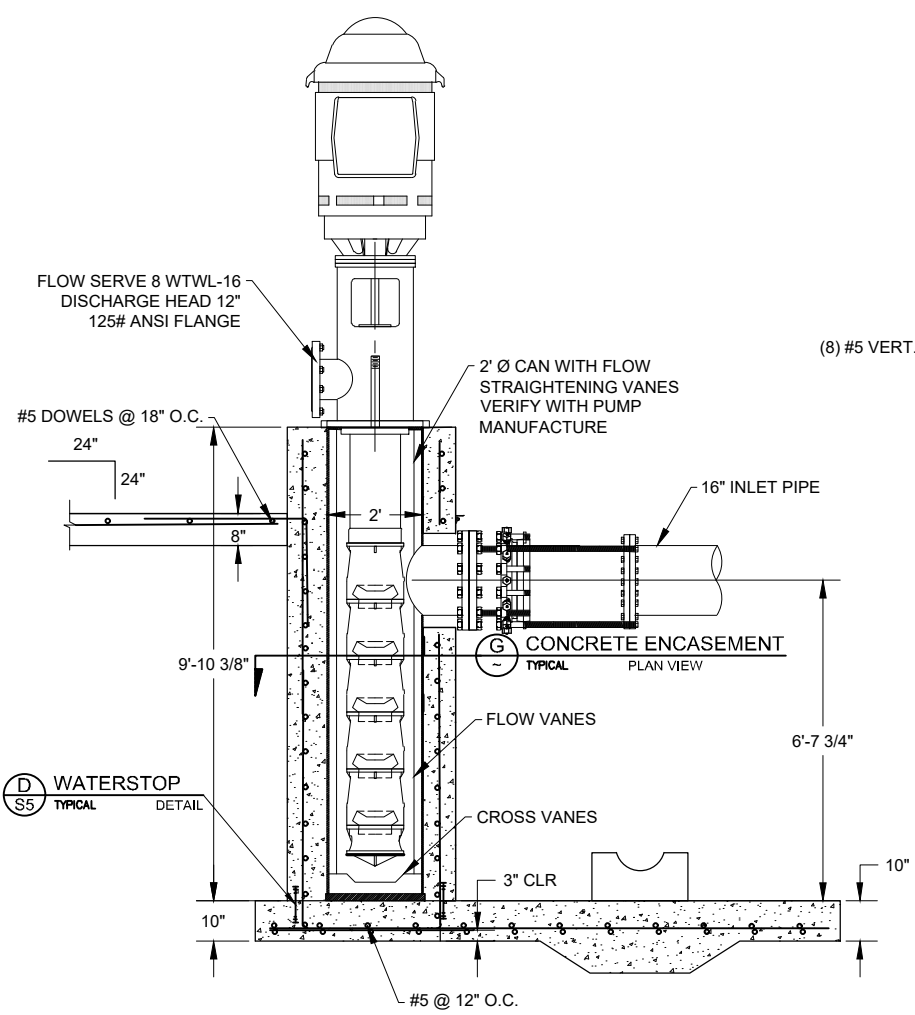


J CONCRETE ENCASEMENT AT BOOSTER PUMP
TYPICAL ELEVATION VIEW

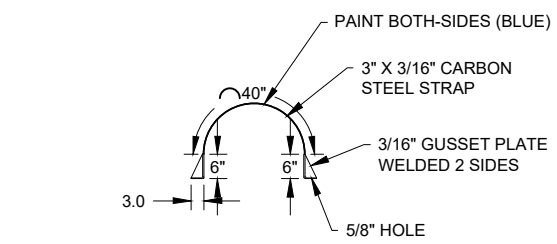


D PIPE HOLD DOWN STRAP
TYPICAL DETAIL

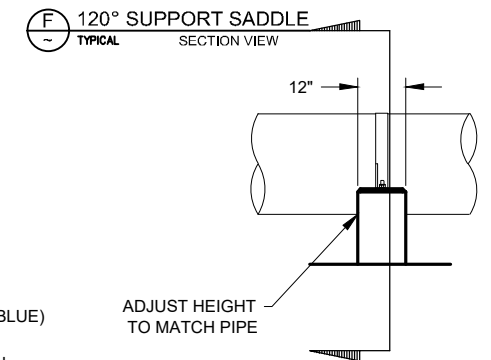


E 120° SUPPORT SADDLE
TYPICAL ELEVATION VIEW

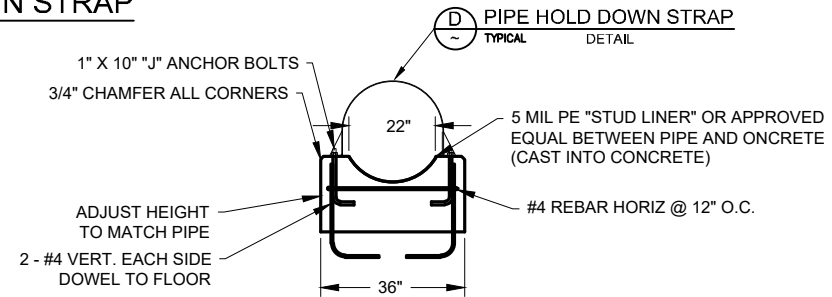

F 120° SUPPORT SADDLE
TYPICAL SECTION VIEW

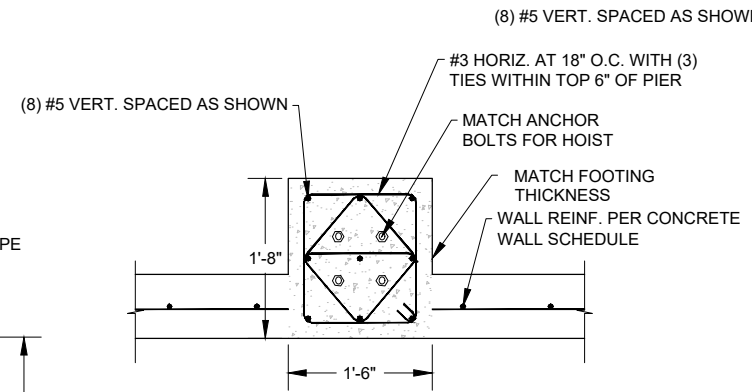

H FOUNDATION REINF. AT PILASTER
TYPICAL DETAIL

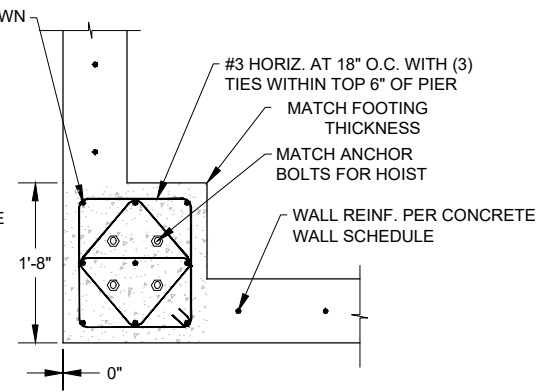


F 120° SUPPORT SADDLE
TYPICAL CORNER PLAN VIEW

REV. NO.	COMMENT	DATE
 SUNRISE ENGINEERING		
770 S WASHINGTON ST. AFTON, WYOMING 83110 TEL 307.885.8500 · FAX 307.885.8501 www.sunrise-eng.com		
GR-RS-SC JPWB		
CROSSROADS PUMP STATION		
MASONRY BUILDING DETAILS		
SEI NO. 07265	DESIGNED FDK	DRAWN BJ
CHECKED JUL	SHEET NO. 40 of 99	S6


P:\WDC GR-RS-SC JPWB Cross Roads Pump Station Level III (307265)\Dwg CSD\Pump Station\Details\Building Details.dwg Feb 13, 2026 9:39am bjenkins

MASONRY WALL SCHEDULE					
MARK	VERT SPACING	GROUTING	NOM CMU SIZE	HEIGHT	ANCHORS AT TOP OF WALL
MW1	#5 AT 16" O.C.	FILL REINF. CELL	8"	20.67'	5/8" DIA AT 24" O.C.
MW2	#5 AT 32" O.C.	FILL REINF. CELL	8"	12.0'	5/8" DIA AT 24" O.C.
ALL MASONRY WALLS REQUIRE HORIZ. BOND BEAM WITH #5 AT 48" O.C. PROVIDE (2) #5 AT TOP AND BOTTOM OF WALL AND (1) #5 AT INTERMEDIATE BOND BEAMS.					

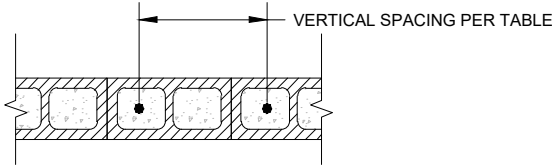


A MASONRY WALL SCHEDULE
TYPICAL DETAIL



MARK	JAMB REINF.	(L) LENGTH
MJ1	(8) #5	2'-8"
MJ2	(4) #5	1'-4"

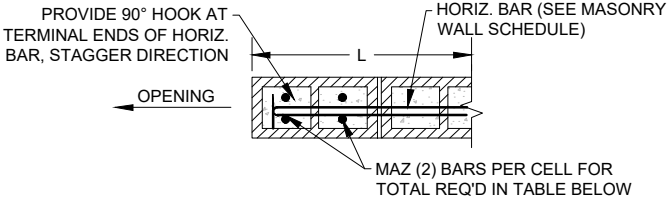


B REINF. AT CMU JAMB
TYPICAL DETAIL

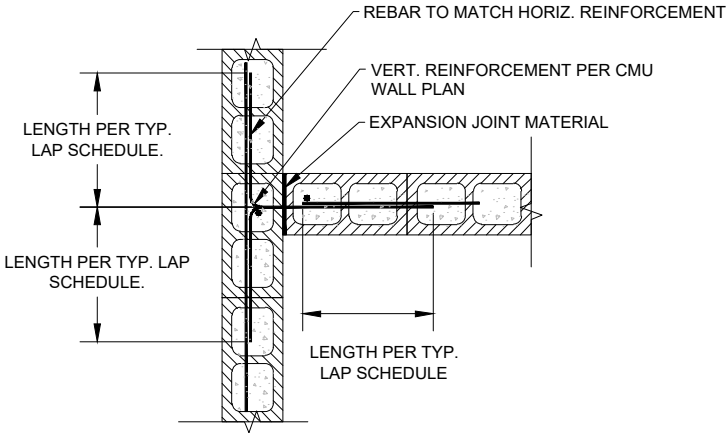


C HORIZ. REINF. AT MASONRY INTERSECTION
TYPICAL DETAIL

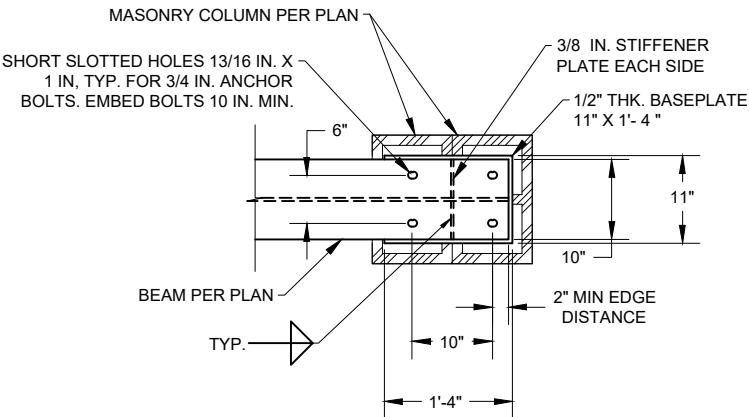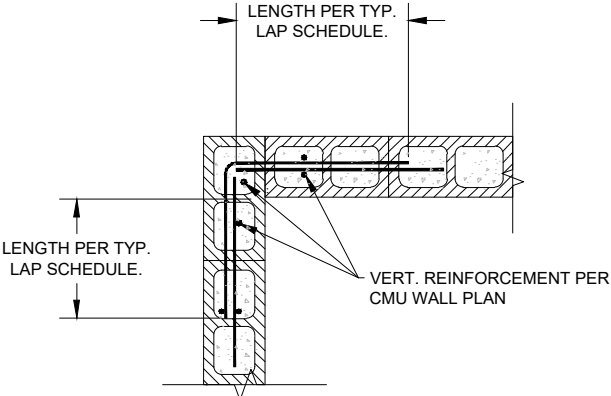


D HOIST GIRDER AT CONCRETE COLUMN
TYPICAL DETAIL

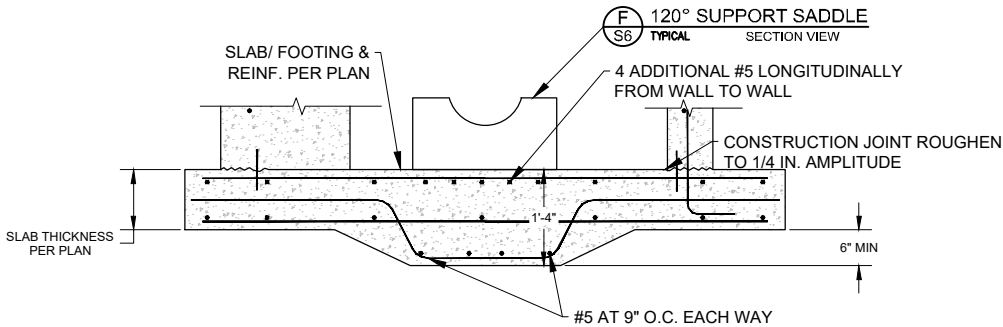

E SUCTION HEADER FOUNDATION
TYPICAL DETAIL

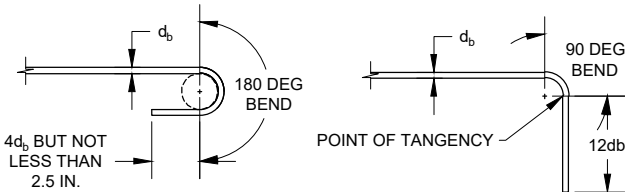

STANDARD HOOKS IN CMU

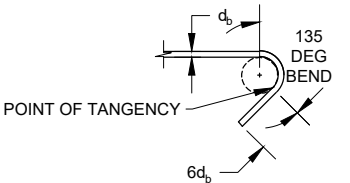

STANDARD HOOK FOR TIE ANCHORAGE IN CMU


F STANDARD HOOK IN MASONRY
TYPICAL DETAIL

* MASONRY REINFORCING SPLICE SCHEDULE
MIN. LAP SPLICE LENGTH, IN. BASED ON:


BAR SIZE	BAR CENTERED IN			1.5 IN. K= 2.0 IN	
	8 IN.	10 IN.	12 IN.		
3	16	16	16	19	16
4	21	21	21	34	26
5	26	26	26	53	40
6	43	40	40	99	74
7	60	46	46	134	101
8	NP	71	61	202	151

- K IS DEFINED AS THE MINIMUM OF:
- A) THE MIN MASONRY COVER
 - B) CLEAR SPACING BETWEEN ADJACENT REINFORCING SPLICES
 - C) 9db

G MASONRY REINFORCING SPLICE SCHEDULE
TYPICAL DETAIL

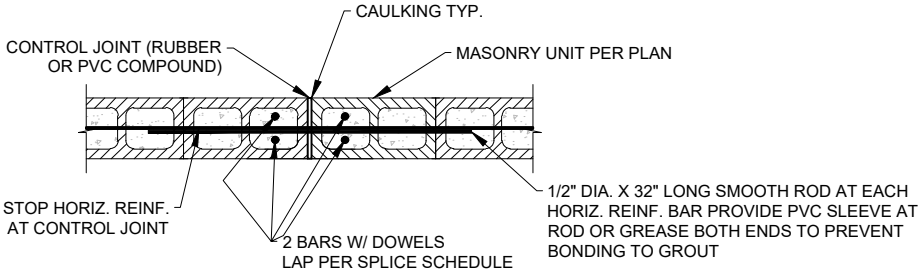


H MASONRY CONTROL JOINT
TYPICAL DETAIL

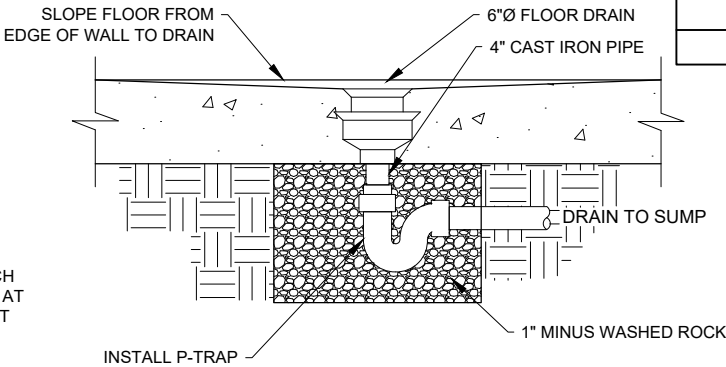


I FLOOR DRAIN
TYPICAL DETAIL

CONCRETE LAP AND DEVELOPMENT SCHEDULE				
F'C = 4000 PSI				
TENSION				
BAR SIZE #	LTE TOP (1)	LTE OTHER	LTS TOP (1)	LTS OTHER
#3	15	12	20	15
#4	20	16	26	20
#5	25	19	32	25
#6	30	23	39	30
#7	54	42	71	54
#8	62	48	81	62


REV NO.	COMMENT	DATE
 SUNRISE ENGINEERING 770 S WASHINGTON ST. AFTON, WYOMING 83110 TEL 307.885.8500 • FAX 307.885.8501 www.sunrise-eng.com		
GR-RS-SC JPWB		
CROSSROADS PUMP STATION		
MASONRY BUILDING DETAILS		
SEI NO. 07265	DESIGNED FDK	DRAWN BJ
CHECKED JUL	SHEET NO. 41 of 99	S7

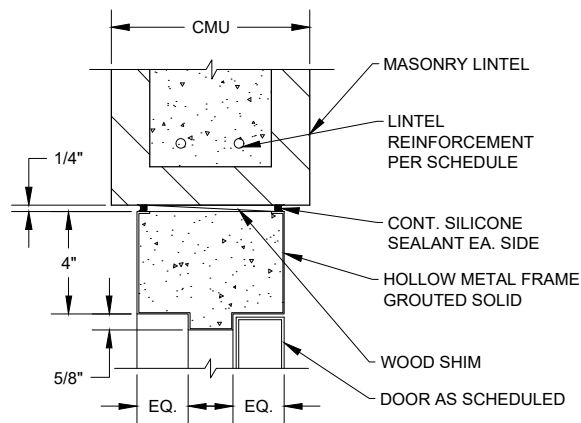


A HOLLOW METAL HEADER
TYPICAL DETAIL

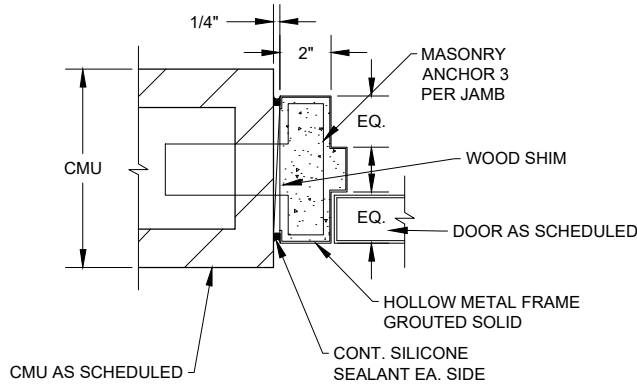


B HOLLOW METAL JAMB
TYPICAL DETAIL

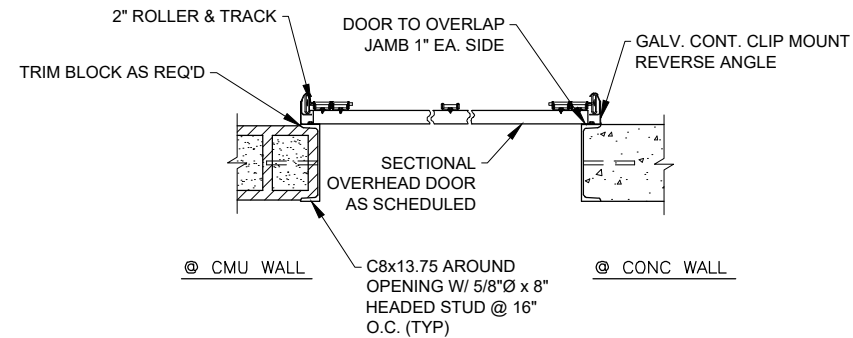


C OVERHEAD DOOR JAMB
TYPICAL DETAIL

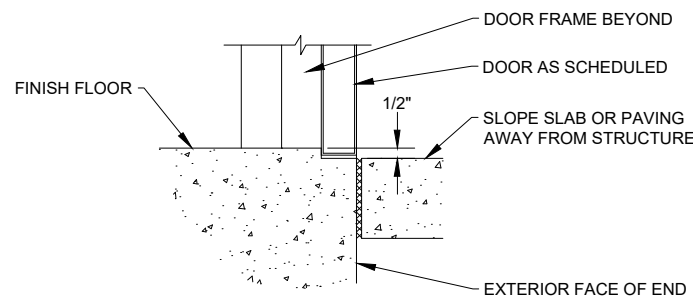


D STL. ANGLE THRESHOLD
S3 TYPICAL DETAIL

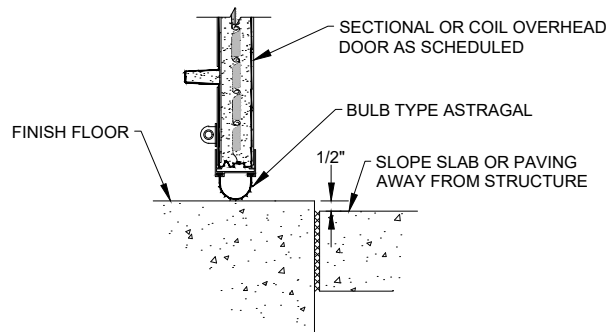


E OVERHEAD DOOR THRESHOLD
S3 TYPICAL DETAIL

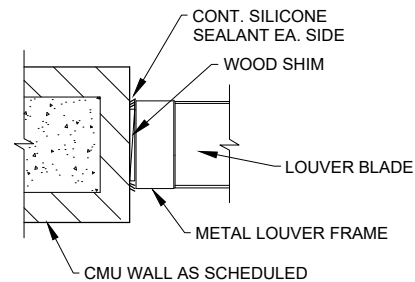


F LOUVER JAMB/HEAD
TYPICAL DETAIL

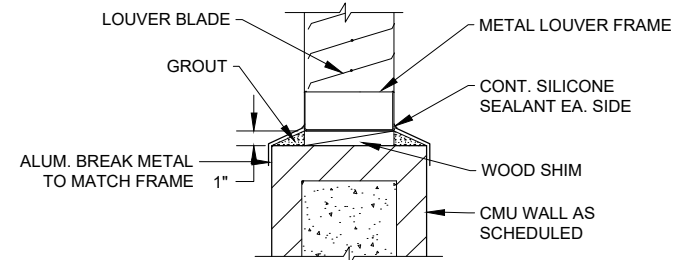

G LOUVER SILL
TYPICAL DETAIL

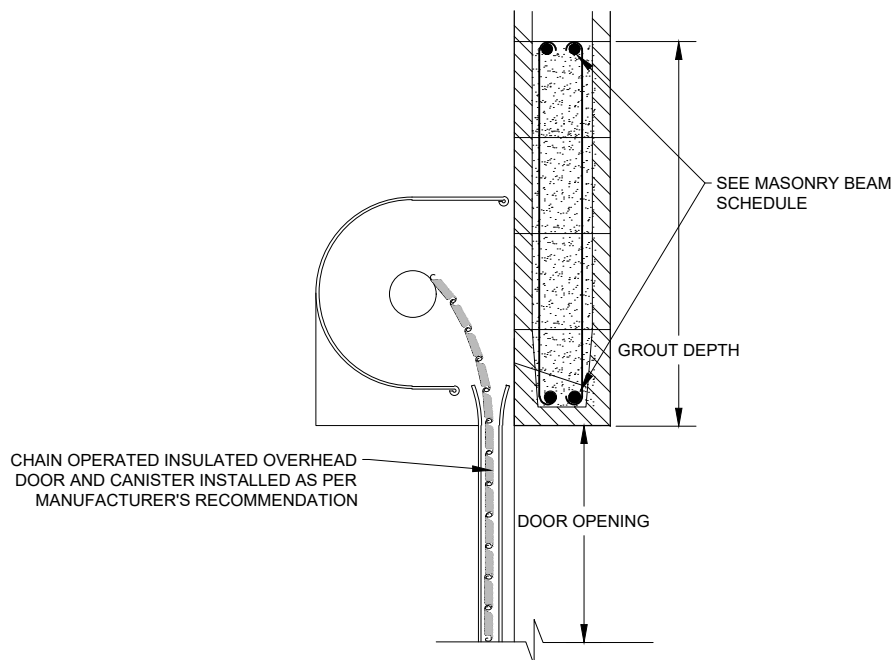

H OVERHEAD DOOR
S3 TYPICAL DETAIL

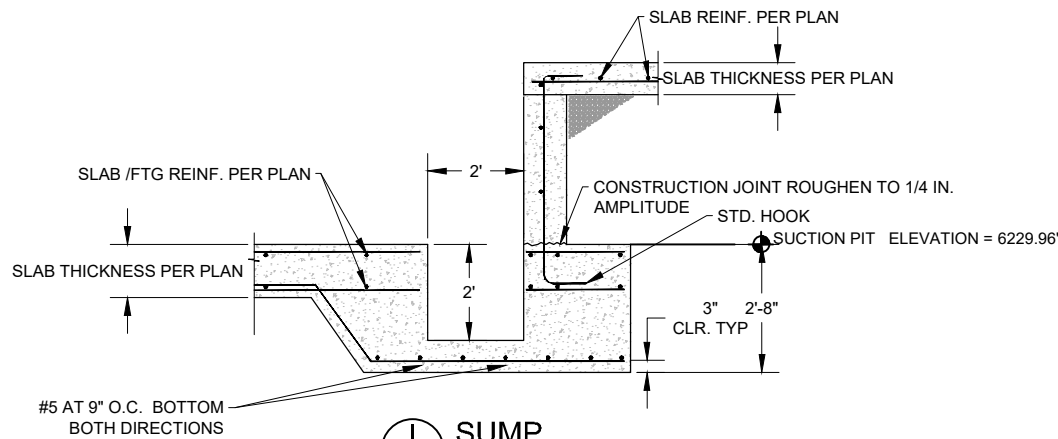


I SUMP
TYPICAL DETAIL


MASONRY LINTEL SCHEDULE						
MAX. SPAN	MIN. DEPTH	NOMINAL WIDTH	REINFORCING		STIRRUPS	REMARKS
			TOP	BOTTOM		
6'	24"	8"	(2) #4	(2) #5	N/A	
10'	32"	8"	(2) #4	(2) #5	N/A	

- HORIZONTAL BARS SHALL RUN 24" PAST EACH SIDE OF OPENING.
- VERTICAL WALL REINFORCING SHALL RUN THROUGH BEAM WITH 90° HOOK @ BOTTOM.
- STIRRUPS SHALL HAVE 180° HOOKS AT TOP & BOTTOM. HOOKS SHOULD LOOP OVER/UNDER TOP/BOTTOM BARS. STAGGER DIRECTION OF STIRRUP.




REV. NO.	COMMENT	DATE
 SUNRISE ENGINEERING 770 S WASHINGTON ST. AFTON, WYOMING 83110 TEL 307.885.8500 · FAX 307.885.8501 www.sunrise-eng.com		
GR-RS-SC JPWB		
CROSSROADS PUMP STATION		
MASONRY BUILDING DETAILS		
SEI NO. 07265	DESIGNED FDK	DRAWN BJ
CHECKED JUL	SHEET NO. 42 of 99	S8

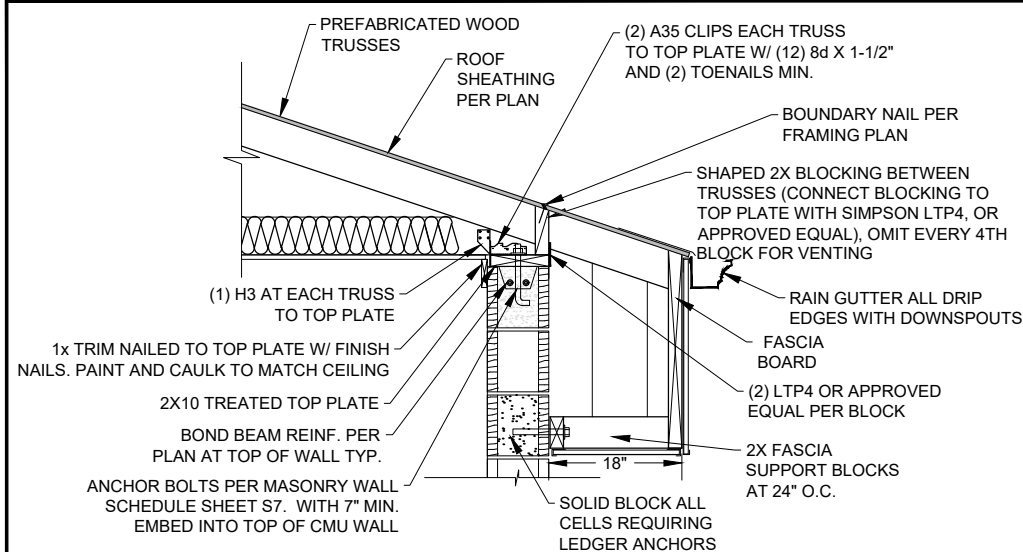


A WOOD TRUSS AT CMU WALL
TYPICAL DETAIL

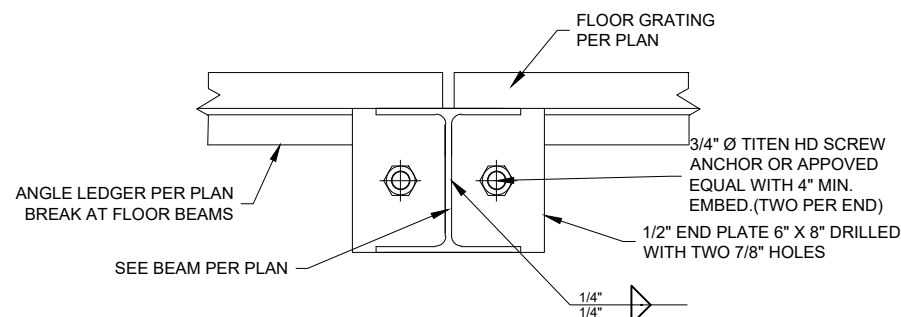


E GRATE SUPPORT
TYPICAL DETAIL

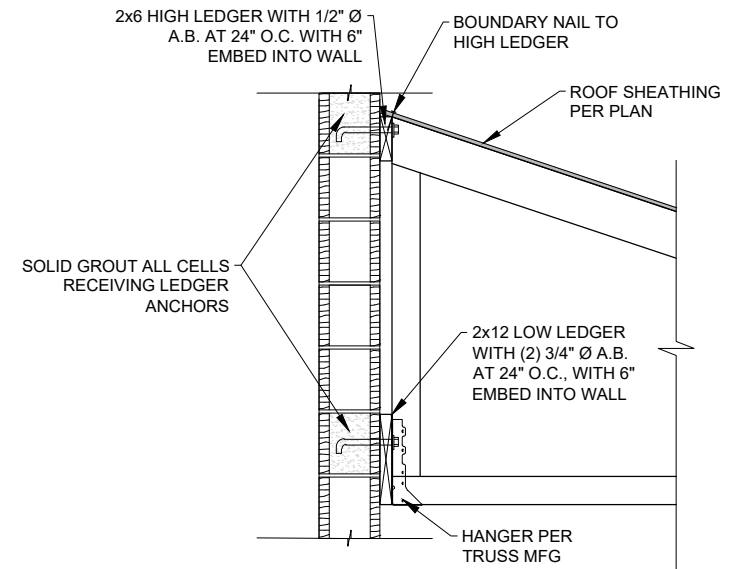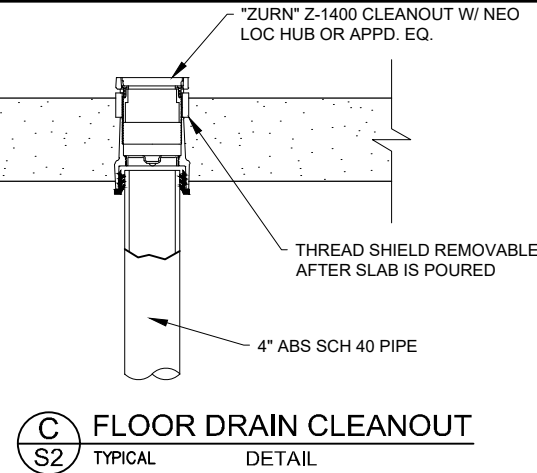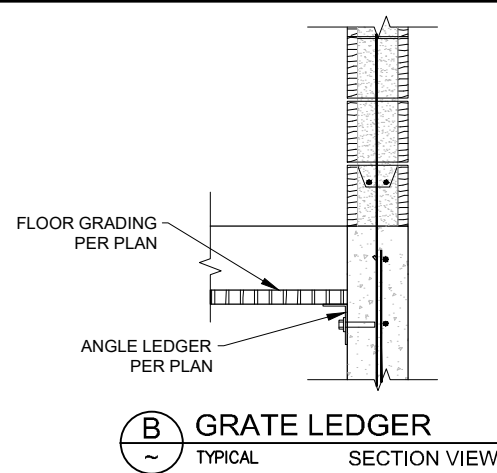


D WOOD TRUSS LEDGER
TYPICAL DETAIL

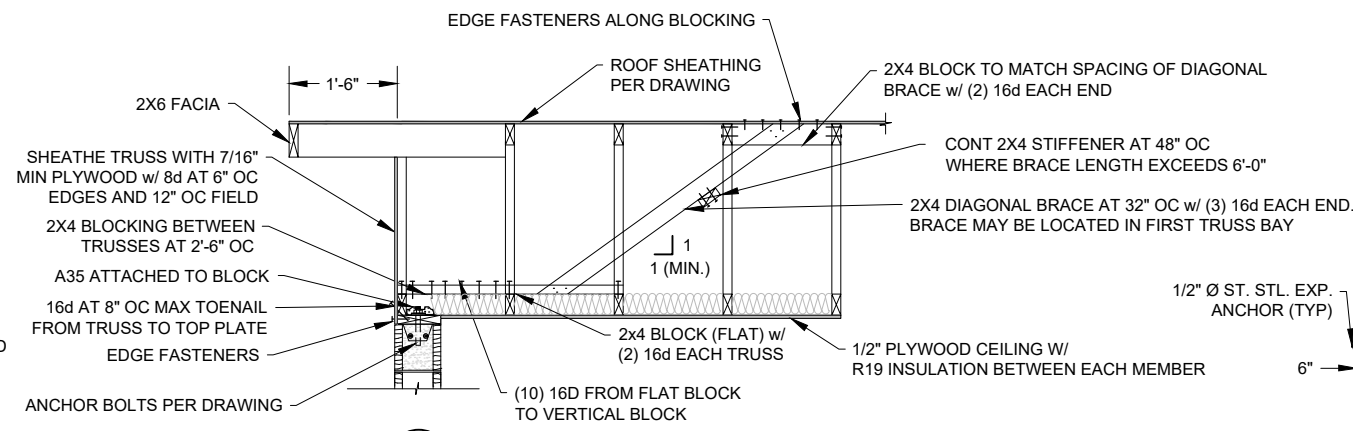


F GABLE TRUSS AT CMU WALL
TYPICAL DETAIL

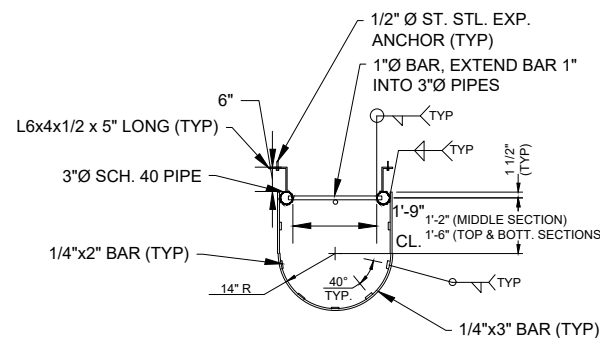

H LADDER
TYPICAL PLAN VIEW

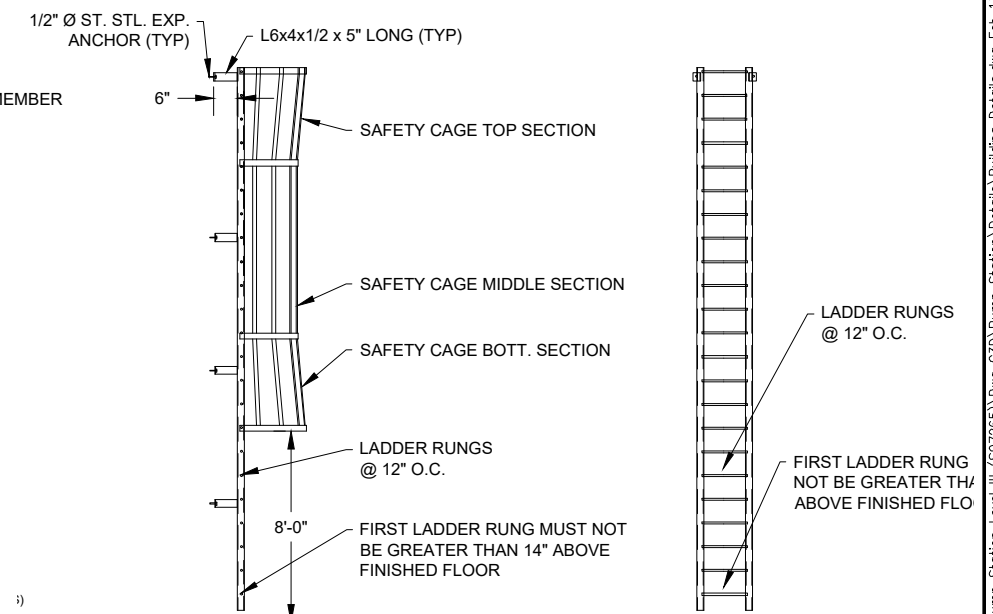

I LADDER
TYPICAL ELEVATION VIEW

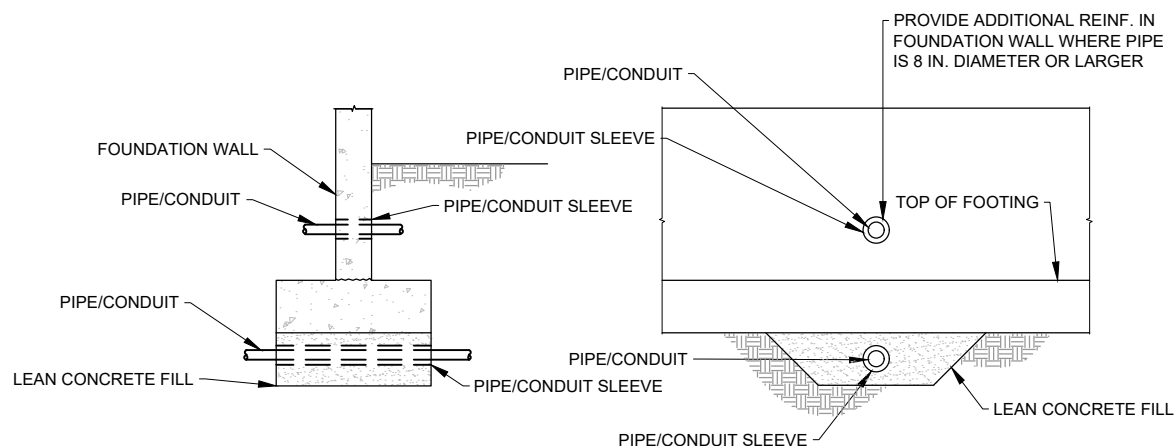


G PIPE/CONDUIT PENETRATIONS
TYPICAL DETAIL


LADDER NOTES:

1. ROOF HATCH SHALL BE 6"x4" 'BILCO' HATCH OR APPD. EQ. HINGED ON THE 6'-0" SIDE, MODIFIED TO OMIT INTERIOR AND EXTERIOR HANDLES, AND PROVIDED W/ CONCEALED PADLOCK HASP. ALL ST. STL. HARDWARE AND FULLY ENCLOSE CURB.
2. ROOF HATCH TO BE MANUFACTURED OF ALUMINUM.
3. ALL LADDER MATERIAL FOR PIPE SIDE RAILS, RUNGS, BRACKETS, AND BASE PLATES TO BE STAINLESS STEEL.
4. LADDER RUNGS TO BE SOLID RODS.
5. ALL WELDS TO BE 1/4" MIN.
6. ALL ALUM. IN CONTACT WITH CONCRETE MUST BE COATED WITH A HEAVY BITUMASTIC COATING OR EPOXY PAINT.
7. USE ST. STL. 316 FOR ALL BOLTS UNLESS NOTED OTHERWISE.
8. WHERE ST. STL. BOLTS ARE IN CONTACT WITH DISSIMILAR METALS, USE INSULATING SLEEVES AND PHENOLIC WASHERS TO ELECTRICALLY ISOLATE THE BOLTS.


REV. NO.	COMMENT	DATE
SUNRISE ENGINEERING 770 S WASHINGTON ST. AFTON, WYOMING 83110 TEL 307.885.8500 · FAX 307.885.8501 www.sunrise-eng.com		
GR-RS-SC JPWB		
CROSSROADS PUMP STATION		
MASONRY BUILDING DETAILS		
SEI NO. 07265	DESIGNED FDK	DRAWN BJ
CHECKED JUL	SHEET NO. 43 of 99	S9

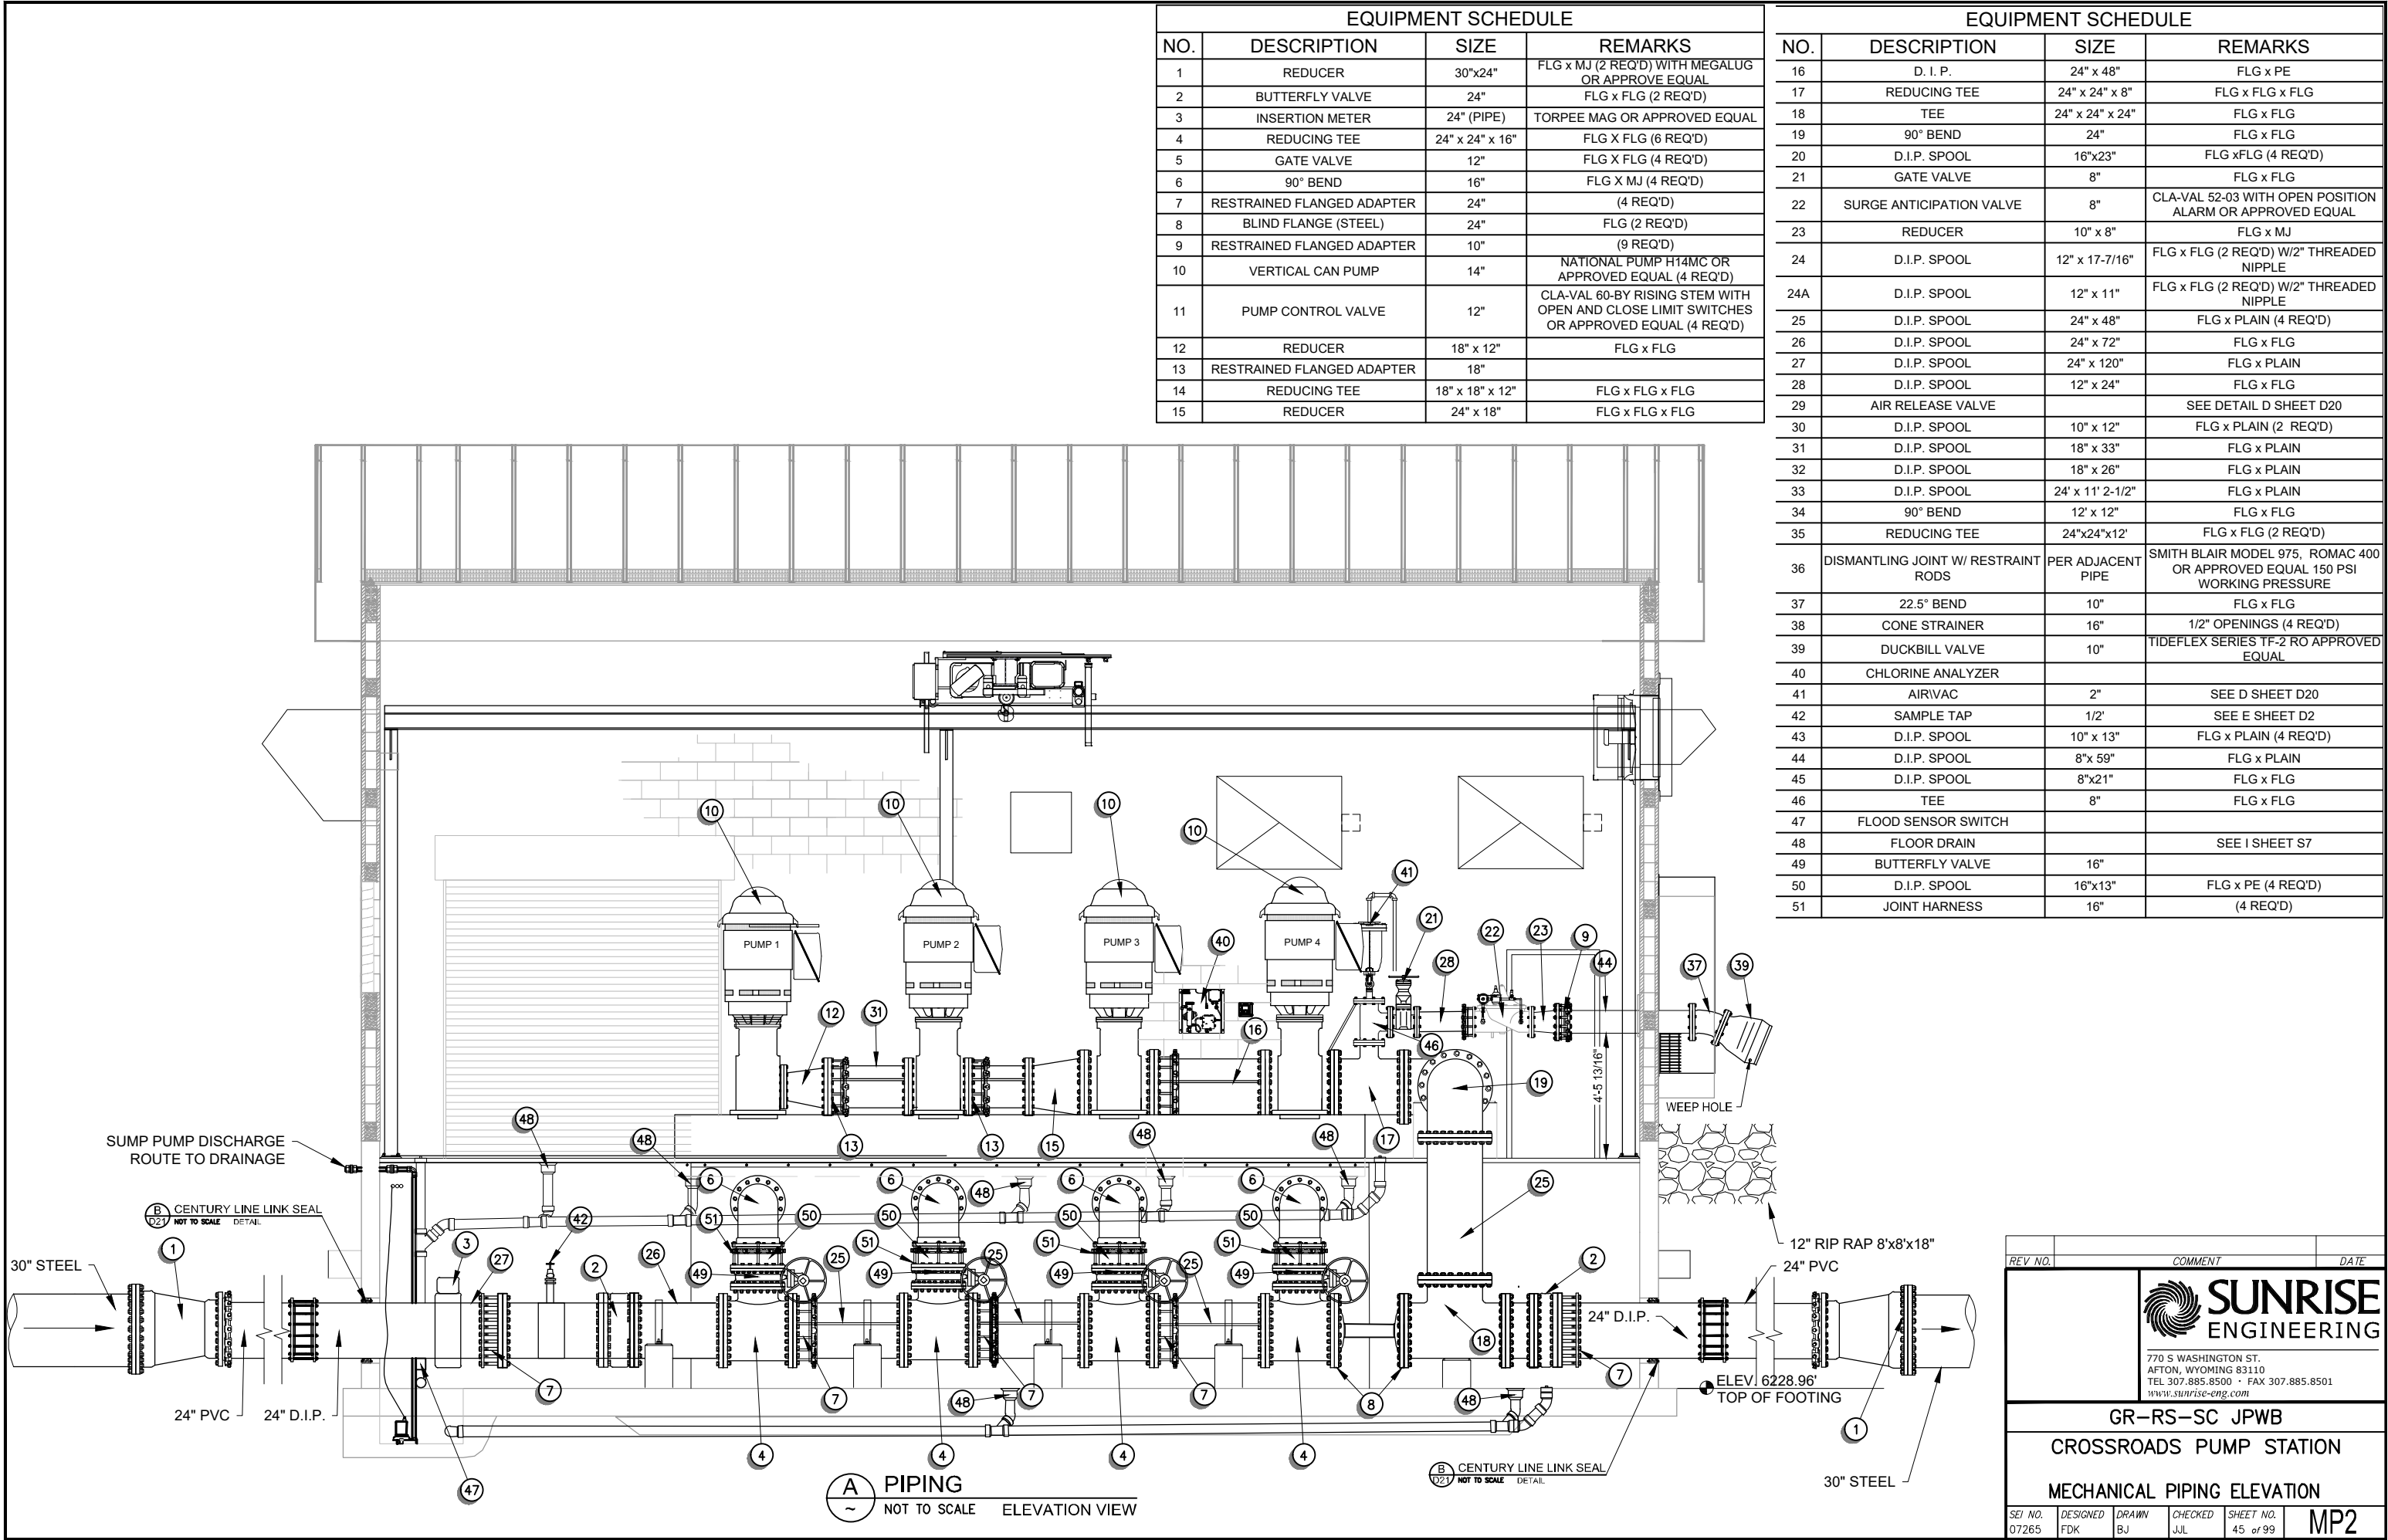

P:\WDOC GR-RS-SC JPWB Cross Roads Pump Station Level III (307265).Dwg C3D\Pump Station Details\Pump Station Layout.dwg Feb 13, 2026 9:40am bjenkins

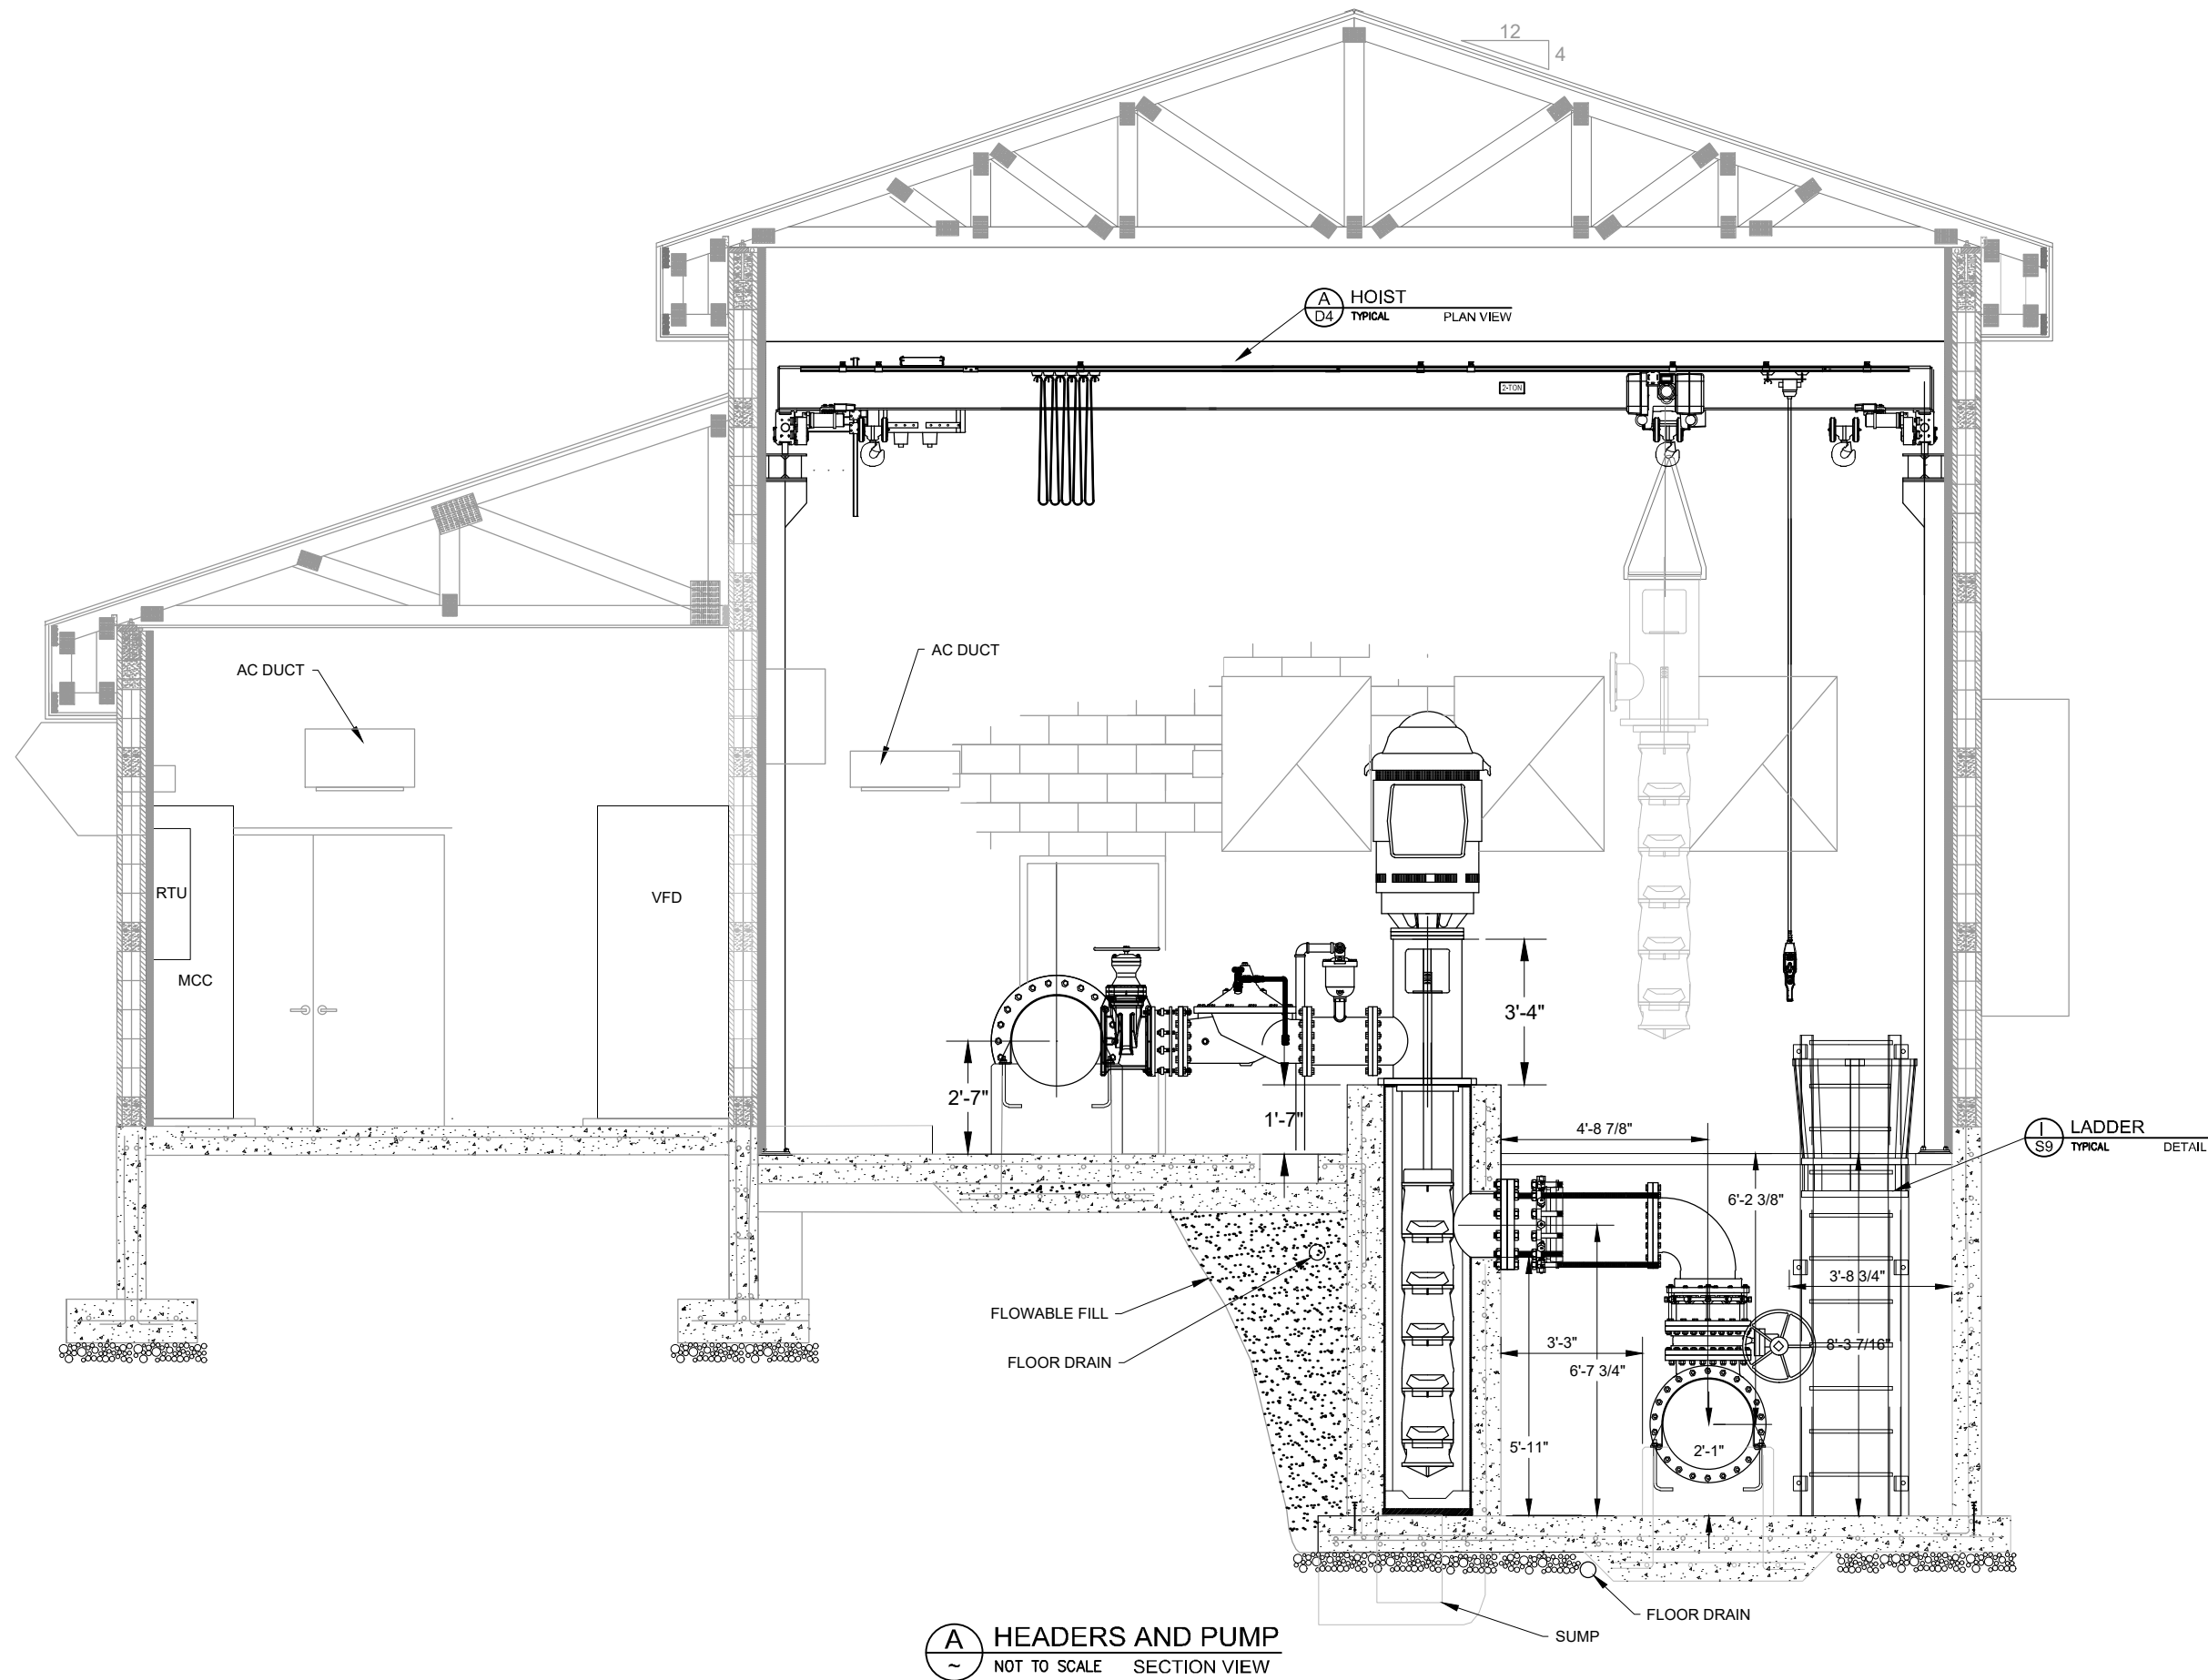

REV. NO.	COMMENT	DATE
 SUNRISE ENGINEERING 770 S WASHINGTON ST. AFTON, WYOMING 83110 TEL 307.885.8500 • FAX 307.885.8501 www.sunrise-eng.com		
GR-RS-SC JPWB		
CROSSROADS PUMP STATION		
MECHANICAL PIPING SECTION		
SEI NO. 07265	DESIGNED FDK	DRAWN BJ
CHECKED JUL	SHEET NO. 46 of 99	MP3

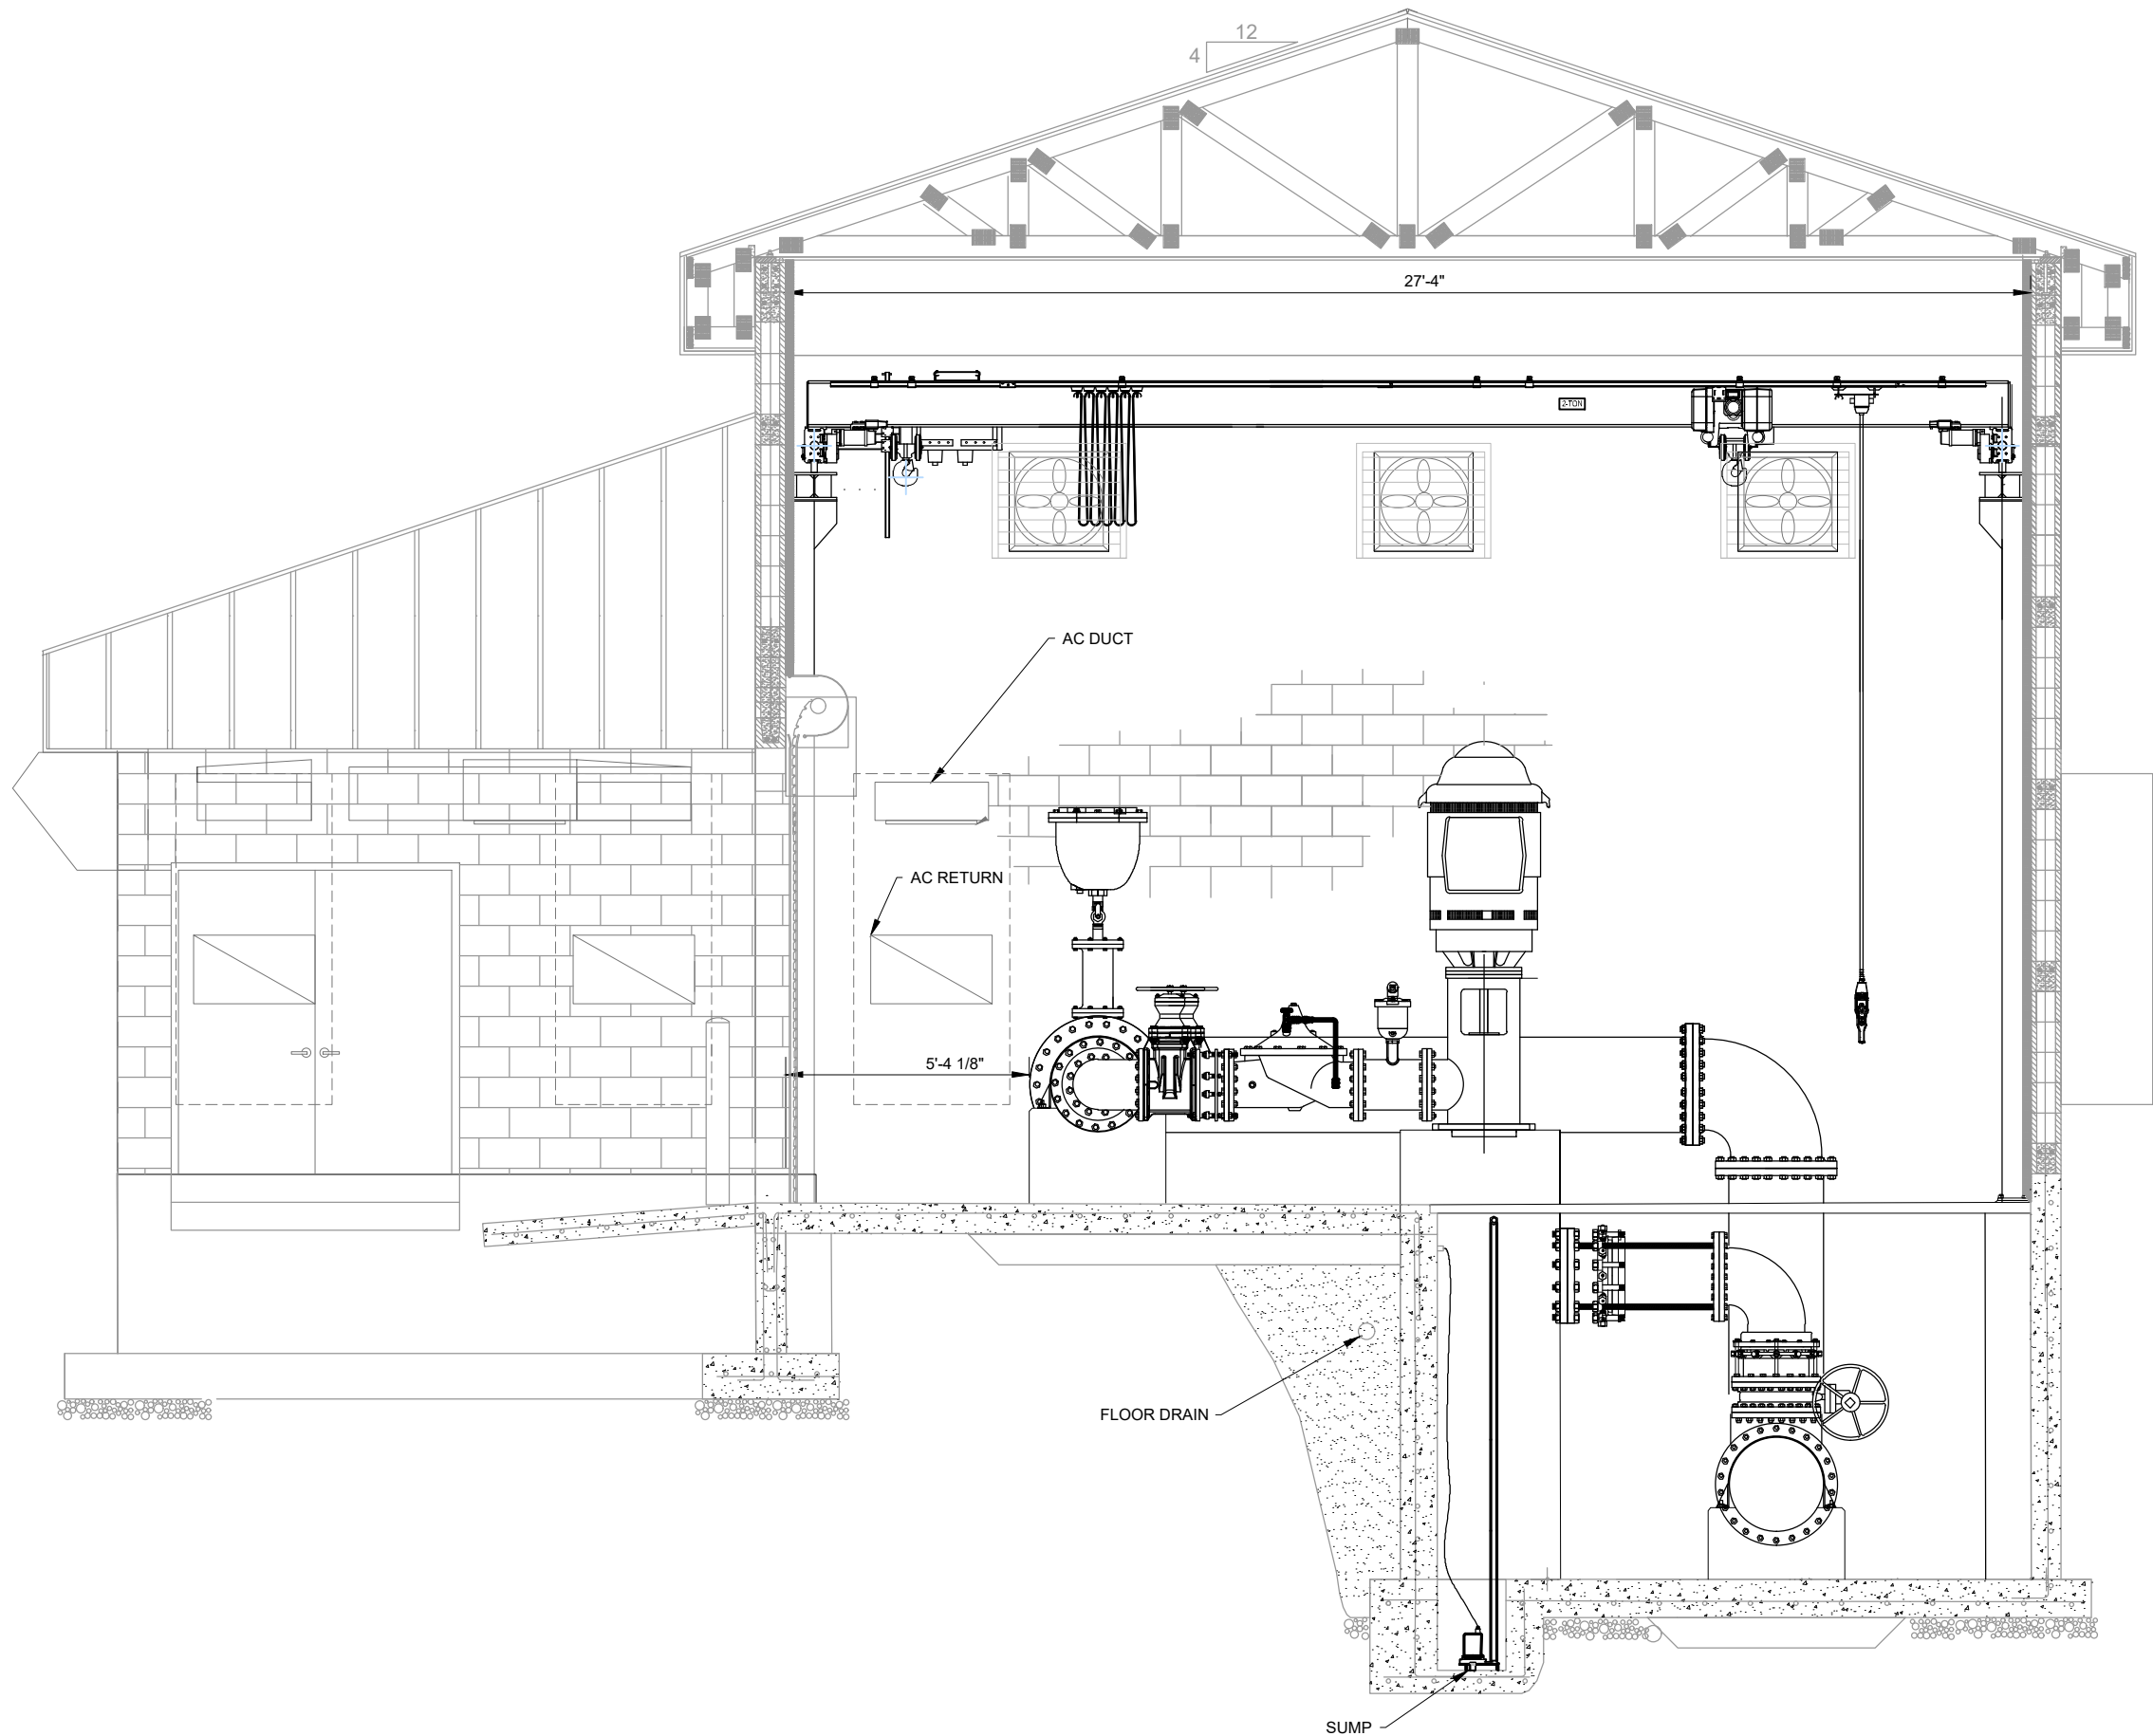

B TRAILER BAY
SECTION VIEW

REV. NO.	COMMENT	DATE
SUNRISE ENGINEERING 770 S WASHINGTON ST. AFTON, WYOMING 83110 TEL 307.885.8500 • FAX 307.885.8501 www.sunrise-eng.com		
GR-RS-SC JPWB		
CROSSROADS PUMP STATION		
MECHANICAL PIPING SECTION		
SEI NO. 07265	DESIGNED FDK	DRAWN BJ
CHECKED JUL	SHEET NO. 47 of 99	MP4

																																																																																																																																																																																																																																																																																																																																																																																																																																																																																																																																																																																																																																																																																																																																																																																																																																																																																																																																																																																																																																																																																																																																																																																																																		</	
--	--	----	--

1

2

3

4

5

6

7

8

9

10

11

12

13

AREA CLASSIFICATION AND MATERIAL DESIGNATIONS

LOCATION	AREA CLASSIFICATION	CONDUIT AND FITTING	FLEXIBLE TYPE	ENCLOSURE NEMA RATING	RACEWAY SUPPORTS	HARDWARE	NOTE
PUMP STATION PUMP ROOM	UNCLASSIFIED, WET	RGS	LFMC	NEMA 4X, SS	STAINLESS STEEL	STAINLESS STEEL	
INDOOR NON-PROCESS AREA	UNCLASSIFIED	RGS	FMC	NEMA 4X, SS	STAINLESS STEEL	STAINLESS STEEL	
OUTDOORS, NON-PROCESS AREA	UNCLASSIFIED, WET	RGS	LFMC	NEMA 4X, SS	STAINLESS STEEL	STAINLESS STEEL	
UNDERGROUND	UNCLASSIFIED, WET	PVC-ENCASED	LFMC	N/A	STAINLESS STEEL	STAINLESS STEEL	
ELECTRICAL ROOMS	UNCLASSIFIED, DRY	RGS	FMC	NEMA 1	GALVANIZED	GALVANIZED	

ANALOG CABLE / CONDUIT SIZES

CONDUIT DESCRIPTOR	WIRE/CONDUIT
A1	1-#16/2 TSP, 3/4"C
A2	2-#16/2 TSP, #18 GND, 3/4"C
A3	3-#16/2 TSP, #18 GND, 3/4"C
A4	4-#16/2 TSP, #18 GND, 1"C
A5	5-#16/2 TSP, #18 GND, 1"C
A6	6-#16/2 TSP, #18 GND, 1-1/4"C
A7	7-#16/2 TSP, #18 GND, 1-1/4"C
A8	8-#16/2 TSP, #18 GND, 1-1/4"C
A9	9-#16/2 TSP, #18 GND, 1-1/4"C
A10	10-#16/2 TSP, #18 GND, 1-1/4"C
A11	11-#16/2 TSP, #18 GND, 1-1/2"C
A12	12-#16/2 TSP, #18 GND, 1-1/2"C
A13	13-#16/2 TSP, #18 GND, 1-1/2"C
A14	14-#16/2 TSP, #18 GND, 2"C
A15	15-#16/2 TSP, #18 GND, 2"C
A16	16-#16/2 TSP, #18 GND, 2"C
A17	17-#16/2 TSP, #18 GND, 2"C
A18	18-#16/2 TSP, #18 GND, 2"C
A19	19-#16/2 TSP, #18 GND, 2"C
A20	20-#16/2 TSP, #18 GND, 2"C
A21	21-#16/2 TSP, #18 GND, 2"C
A22	22-#16/2 TSP, #18 GND, 2"C
A23	23-#16/2 TSP, #18 GND, 2-1/2"C
A24	24-#16/2 TSP, #18 GND, 2-1/2"C
A25	25-#16/2 TSP, #18 GND, 2-1/2"C

DISCRETE CABLE / CONDUIT SIZES

CONDUIT DESCRIPTOR	WIRE/CONDUIT
C1	NOT USED
C2	2-#14, 3/4"C
C3	3-#14, 3/4"C
C4	4-#14, 3/4"C
C5	5-#14, 3/4"C
C6	6-#14, 3/4"C
C7	7-#14, 3/4"C
C8	8-#14, 3/4"C
C9	9-#14, 3/4"C
C10	10-#14, 3/4"C
C11	11-#14, 3/4"C
C12	12-#14, 1"C
C13	13-#14, 1"C
C14	14-#14, 1"C
C15	15-#14, 1"C
C16	16-#14, 1"C
C17	17-#14, 1"C
C18	18-#14, 1"C
C19	19-#14, 1"C
C20	20-#14, 1-1/4"C
C21	21-#14, 1-1/4"C
C22	22-#14, 1-1/4"C
C23	23-#14, 1-1/4"C
C24	24-#14, 1-1/4"C
C25	25-#14, 1-1/4"C

MULTI-CONDUCTOR DISCRETE CABLE /
CONDUIT SIZES

CONDUIT DESCRIPTOR	WIRE/CONDUIT
M2	1-(2-#14), 3/4"C
M3	1-(3-#14), 3/4"C
M4	1-(4-#14), 3/4"C
M5	1-(5-#14), 3/4"C
M6	1-(6-#14), 3/4"C
M7	1-(7-#14), 3/4"C
M8	1-(8-#14), 3/4"C
M9	1-(9-#14), 1"C
M10	1-(10-#14), 1"C
M11	1-(11-#14), 1"C
M12	1-(12-#14), 1"C
M13	1-(13-#14), 1"C
M14	1-(14-#14), 1"C
M15	1-(15-#14), 1-1/4"C
M16	1-(16-#14), 1-1/4"C
M17	1-(17-#14), 1-1/4"C
M18	1-(18-#14), 1-1/4"C
M19	1-(19-#14), 1-1/4"C
M20	1-(20-#14), 1-1/4"C

NETWORK CABLE / CONDUIT
DESIGNATION

CONDUIT DESCRIPTOR	WIRE/CONDUIT
N1	1 - CAT 6 NETWORK, 3/4"C
N2	2 - CAT 6 NETWORK, 3/4"C
N3	3 - CAT 6 NETWORK, 1"C
N4	4 - CAT 6 NETWORK, 1"C
N5	1 - 6 STR MM FIBER, 1"C
N6	1 - 12 STR MM FIBER, 1"C
N7	1 - 24 STR MM FIBER, 1"C
N8	1 - 6 STR SM FIBER, 1"C
N9	1 - 12 STR SM FIBER, 1"C
N10	1 - 24 STR SM FIBER, 1"C

MOTOR WINDING RTDs

CONDUIT DESCRIPTOR	WIRE/CONDUIT
R1	1-(#16/3 TSP), 3/4"C
R2	2-(#16/3 TSP), 3/4"C
R3	3-(#16/3 TSP), 3/4"C
R4	4-(#16/3 TSP), 1"C
R5	5-(#16/3 TSP), 1"C
R6	6-(#16/3 TSP), 1-1/4"C
R8	8-(#16/3 TSP), 1-1/4"C

POWER CABLE / CONDUIT SIZES

CONDUIT DESCRIPTOR	WIRE/CONDUIT	CONDUIT DESCRIPTOR	WIRE/CONDUIT
P1*	2-#12, #12 GND, 3/4"C	P21	2 SETS - 3-300KCMIL, #1/0 GND, 2-1/2"C
P2*	3-#12, #12 GND, 3/4"C	P21N	2 SETS - 4-300KCMIL, #1/0 GND, 3"C
P3*	2-#10, #12 GND, 3/4"C	P22	3-350KCMIL, #2 GND, 2-1/2"C
P4*	3-#10, #12 GND, 3/4"C	P22N	4-350KCMIL, #2 GND, 3"C
P5*	2-#8, #10 GND, 3/4"C	P23	2 SETS - 3-350KCMIL, #1/0 GND, 2-1/2"C
P6*	3-#8, #10 GND, 1"C	P23N	2 SETS - 4-350KCMIL, #1/0 GND, 3"C
P7*	2-#6, #8 GND, 3/4"C	P24	3-500KCMIL, #2 GND, 4"C
P8*	3-#6, #8 GND, 1"C	P24N	4-500KCMIL, #2 GND, 4"C
P9*	2-#4, #8 GND, 3/4"C	P25	2 SETS - 3-500KCMIL, #1/0 GND, 4"C
P10*	3-#4, #8 GND, 1-1/4"C	P25N	2 SETS - 4-500KCMIL, #1/0 GND, 4"C
P11*	2-#2, #6 GND, 1"C	P26	3 SETS - 3-500KCMIL, #2/0 GND, 4"C
P12*	3-#2, #6 GND, 1-1/4"C	P26N	3 SETS - 4-500KCMIL, #2/0 GND, 4"C
P13*	2-#1/0, #6 GND, 1-1/4"C	P27	4 SETS - 3-500KCMIL, #4/0 GND, 4"C
P14*	3-#1/0, #6 GND, 1-1/2"C	P27N	4 SETS - 4-500KCMIL, #4/0 GND, 4"C
P15*	3-#2/0, #6 GND, 2"C	P28	5 SETS - 3-500KCMIL, 250KCMIL GND, 4"C
P16*	3-#3/0, #6 GND, 2"C	P28N	5 SETS - 4-500KCMIL, 250KCMIL GND, 4"C
P17*	3-#4/0, #4 GND, 2"C	P29	6 SETS - 3-500KCMIL, 350KCMIL GND, 4"C
P18	3-250KCMIL, #4 GND, 2"C	P29N	6 SETS - 4-500KCMIL, 350KCMIL GND, 4"C
P18N	4-250KCMIL, #4 GND, 2"C	P30	7 SETS - 3-500KCMIL, 500KCMIL GND, 4"C
P19	2 SETS - 3-250KCMIL, #4 GND, 2"C	P30N	7 SETS - 4-500KCMIL, 500KCMIL GND, 4"C
P19N	2 SETS - 4-250KCMIL, #4 GND, 2-1/2"C	P31	8 SETS - 3-500KCMIL, 500KCMIL GND, 4"C
P20	3-300KCMIL, #4 GND, 2-1/2"C	P31N	8 SETS - 4-500KCMIL, 500KCMIL GND, 4"C
P20N	4-300KCMIL, #4 GND, 2-1/2"C	P32	6 SETS - 3-600KCMIL, 250KCMIL GND, 4"C
		P32N	6 SETS - 4-600KCMIL, 250KCMIL GND, 4"C

VFD CABLE / CONDUIT SIZES

CONDUIT DESCRIPTOR	WIRE/CONDUIT	BELDEN #, OR EQUAL
V1	#12 VFD CABLE, 1"C	29502
V2	#10 VFD CABLE, 1-1/4"C	29503
V3	#8 VFD CABLE, 1-1/4"C	29504
V4	#6 VFD CABLE, 1-1/2"C	29505
V5	#4 VFD CABLE, 2"C	29506
V6	#2 VFD CABLE, 2"C	29507
V7	#1 VFD CABLE, 2"C	29528
V8	#1/0 VFD CABLE, 2"C	29529
V9	#2/0 VFD CABLE, 2-1/2"C	29530
V10	#3/0 VFD CABLE, 2-1/2"C	29531
V11	#4/0 VFD CABLE, 3"C	29532
V12	250KCMIL VFD CABLE, 3"C	29533
V13	350KCMIL VFD CABLE, 4"C	29534
V14	500KCMIL VFD CABLE, 4"C	29535

NOTE: WHERE "N" IS USED ON THE DRAWINGS APPENDED TO THE DESCRIPTORS SHOWN ABOVE AN ADDITIONAL CONDUCTOR EQUAL TO THE PHASE CONDUCTORS IS TO BE PROVIDED.

no. | date | by | ckd | description

0 | 02/12/26 | AMM | MAH | ISSUED FOR BID

PROFESSIONAL ENGINEER
MARK A. HOPKINS
1982
DATE: 02/12/2026
WYOMING

BURNS
McDONNELL

9191 S. JAMAICA STREET
ENGLEWOOD, CO 80112

Burns & McDonnell Engineering Co, Inc

Issue date
FEBUARY 2026

designed by
A. MORRONI

detailed by
A. BENSON

checked by
M. HOPKINS

SUNRISE
ENGINEERING

CROSSROADS PUMP STATION
ELECTRICAL

AREA CLASSIFICATIONS, MATERIALS, AND
CONDUIT SCHEDULES

project
124784

contract

drawing
00E-003

rev.
0

sheet
50

of
99

sheets

Millimeters

Inches

Scale For Microfilming

2/12/2026 1:33:21 PM

Autodesk Docs://124784_Crossroads/124784_CROSSROADS_MEP_R24.rvt

LUMINAIRE SCHEDULE								
LUMINAIRE TYPE	ACCEPTABLE MANUFACTURER	CATALOG NUMBER	CONSTRUCTION	TYPE OF FIXTURE	OPTICS	LAMP	DRIVER	ACCESSORIES/NOTES
A	HOLOPHANE OR APPROVED EQUAL	HZL1D L48 7000LM FST MVOLT 40K 80CRI MB	COLD ROLLED STEEL CONSTRUCTION WITH IRON PHOSPHATE PRETREATMENT AND HIGH-GLOSS WHITE BAKED ENAMEL FINISH WITH STANDARD DIFFUSE OPTICS	4' LINEAR	INDIRECT DIFFUSED ACRYLIC	LED, 7000 LUMENS 80 CRI, 4000K CCT	120-277V NON-DIMMING TYPE	1. TOTAL WATTAGE PER FIXTURE: 59 WATTS 2. SELF-CONTAINED EMERGENCY LED POWER PACK. (MIN. 10W BATTERY). E10WLCP
B	HOLOPHANE OR APPROVED EQUAL	HZL1D L48 5000LM FST MVOLT 40K 80CRI MB	COLD ROLLED STEEL CONSTRUCTION WITH IRON PHOSPHATE PRETREATMENT AND HIGH-GLOSS WHITE BAKED ENAMEL FINISH WITH STANDARD DIFFUSE OPTICS	4' LINEAR	INDIRECT DIFFUSED ACRYLIC	LED, 5000 LUMENS 80 CRI, 4000K	120-277V NON-DIMMING TYPE	1. TOTAL WATTAGE PER FIXTURE: 41 WATTS 2. SELF-CONTAINED EMERGENCY LED POWER PACK. (MIN. 10W BATTERY). E10WLCP
C	HOLOPHANE OR APPROVED EQUAL	WCNG P4 40K T3M MVOLT ZT 10KV BKSDP SCRW NPR ELSW	DIE-CAST ALUMINIUM FULLY GASKETED, WITH ZINC-INFUSED TGIC THERMOSET POWDER COAT FINISH	WALLPACK	GLASS REFRACTOR	LED, 8500 LUMENS 80 CRI, 4000K CCT	120-277V NON-DIMMING TYPE	1. TOTAL WATTAGE PER FIXTURE: 72 WATTS 2. SELF-CONTAINED EMERGENCY LED POWER PACK. (MIN. 10W BATTERY).
D	HOLOPHANE OR APPROVED EQUAL	WCNG P2 40K T3M MVOLT ZT 10KV BKSDP SCRW NPR ELSW	DIE-CAST ALUMINIUM FULLY GASKETED, WITH ZINC-INFUSED TGIC THERMOSET POWDER COAT FINISH	WALLPACK	GLASS REFRACTOR	LED, 4100 LUMENS 80 CRI, 4000K CCT	120-277V NON-DIMMING TYPE	1. TOTAL WATTAGE PER FIXTURE: 35 WATTS 2. SELF-CONTAINED EMERGENCY LED POWER PACK. (MIN. 10W BATTERY).
E	HOLOPHANE OR APPROVED EQUAL	HLWPC2 P20 40K AS T2M BKSDP 80CRI PE EM	HEAVY GRADE A360 CAST ALUMINIUM HOUSING WITH ZINC-INFUSED TGIC THERMOSET POWDER COAT FINISH	1' CUTOFF WALLPACK	FROSTED ACRYLIC	LED, 5600 LUMENS 80 CRI, 4000K CCT	120-277V NON-DIMMING TYPE	1. TOTAL WATTAGE PER FIXTURE: 47 WATTS 2. SELF-CONTAINED EMERGENCY LED POWER PACK. (MIN. 10W BATTERY) WHERE REQUIRED ON PLANS. 3. PROVIDE BUTTON STYLE PHOTOCONTROL FOR UNSWITCHED LIGHTS.
F	HOLOPHANE OR APPROVED EQUAL	DLTL W 1 R	WHITE, COMPACT, CONTEMPORARY DESIGN. ENGINEERING-GRADE THERMOPLASTIC HOUSEING IS IMPACT-RESISTANT, SCRATCH RESISTANT, AND CORROSION PROOF	EXIT LIGHT	PLASTIC	LED	120V NON-DIMMING TYPE	1. TOTAL WATTAGE PER FIXTURE: 5 WATTS 2. 24/7 OPERATION
G	ACUITY / HOLOPHANE OR ENGINEER APPROVED EQUAL	MGLED-P1-40K-MVOLT-FT-LT-SPA-DDB SD-NL-US	DIE-CAST ALUMINUM HOUSING, STAINLESS STEEL HARDWARE, 3G VIBRATION RATED, EPOXY PAINT BASECOAT, POLYESTER PAINT TOPCOAT	POLE	BOROSILICATE GLASS	LED, 35000 LUMEN, 4000K, 70 CRI	120V-277V NON-DIMMING TYPE	1. TOTAL WATTAGE PER LUMINAIRE: 246 WATTS
G-POLE	ACUITY / HOLOPHANE OR ENGINEER APPROVED EQUAL	SSA2566G-DDB-BAA	25'0" TALL, 6.0" X 0.188" STRAIGHT SQUARE ALLUMINUM POLE, 1.00" X 36" ANCHOR BOLTS @ 12.5" BOLT CIRCLE, MIN EFFECTIVE PROJECTED AREA AT 30" OFFSET 3.8 S.F. @ 110 MPH	POLE	N/A	N/A	N/A	1. PROVIDE MANUFACTURER SUPPLIED ANCHOR BOLTS.

no.	date	by	ckd	description
0	02/12/26	AMM	MAH	ISSUED FOR BID





Burns & McDonnell Engineering Co, Inc

Issue date FEBUARY 2026	detailed by A.BENSON
designed by A. MORRONI	checked by M. HOPKINS




CROSSROADS PUMP STATION ELECTRICAL LUMINAIRE SCHEDULE	
project 124784	contract
drawing 00E-010	rev. 0
sheet 51	of 99 sheets


2/12/2026 1:33:21 PM
Autodesk Docs://124784_Crossroads/124784_CROSSROADS_MEP_R24.rvt
Inches
Scale For Microfilming
Millimeters

ELECTRICAL EQUIPMENT	VOLTAGE (Y/V)	PHASE	WIRE	MAIN BUS (A)	MAIN BREAKER	MOUNTING	LOCATION	NEMA RATING	SHORT CIRCUIT (KAIC)	FED VIA		
SWBD-100	480	3	3	2000	2000	PAD MOUNT	INDOORS	NEMA 1G*	65	UTIL VIA...	* G = GASKETED	
LOAD DESCRIPTION	PHASE	RPM	ENCLOSURE	HP	VOLTS	CURRENT	KVA	LOAD TYPE	CONTINUOUS/ INTERMITTENT/ SPARE	STARTER TYPE	DEMAND FACTOR	DEMAND KVA
P-102 - POTABLE WATER PUMP 1	3	1800	EXTERNAL	350	480	414.00	329.9	M	C	VFD	100%	329.9
P-202 - POTABLE WATER PUMP 2	3	1800	EXTERNAL	350	480	414.00	329.9	M	C	VFD	100%	329.9
P-302 - POTABLE WATER PUMP 3	3	1800	EXTERNAL	350	480	414.00	329.9	M	C	VFD	100%	329.9
P-402 - POTABLE WATER PUMP 4	3	1800	EXTERNAL	350	480	414.00	329.9	M	S	VFD	0%	0.00
250A 480Y/277V PP-1			EXTERNAL		480	200.00	166.2	M	C	FEEDER	100%	166.2
ACTIVE HARMONIC FILTER (400A...	3	-	EXTERNAL	-	480	-		F		FEEDER	0%	0.0
LOAD TYPES:	RATIO ISC/IL:			22.9	TOTAL CONNECTED KVA:			1485.6	DEMAND AT PLANT OUTPUT (KVA):			1155.8
M = MOTOR	MAX CURRENT DISTORTION TDDi %:			8.0	TOTAL CONNECTED AMPS:			1856.0	FEEDER CALC NEC 215 (KVA):			1444.7
F = FEEDER	MAX VOLTAGE DISTORTION THDv %:			8.0	MIN BUS SIZE:			1737.7	FEEDER CALC NEC 430 (KVA):			1238.2
B = BRANCH	HARMONIC GEN. LOAD CURRENT...			1406.5	BUS SIZE:			2000	TOTAL FEEDER AMPS (A):			1737.7
C = CONTINUOUS	TDD HARMONICS (A):			482.0	TRANSFORMER Z, (%):			5.46% 1	DIVERSITY LOAD (A):			1442.0
I = INTERMITTENT	HARMONIC CORRECTION REC'D. (A):			353.5	MAXIMUM FAULT CURRENT...			36715.9	UTILITY TRANSFORMER SIZE (KVA):			1500
S = STANDBY	HARMONIC FILTER SIZE (A): (SEE NOTE BELOW)			400								


NOTE: ESTIMATION OF EXPECTED HARMONICS IS CALCULATED USING 3% LINE REACTORS. CONTRACTOR TO PROVIDE HARMONICS BASED ON EQUIPMENT PROVIDED.

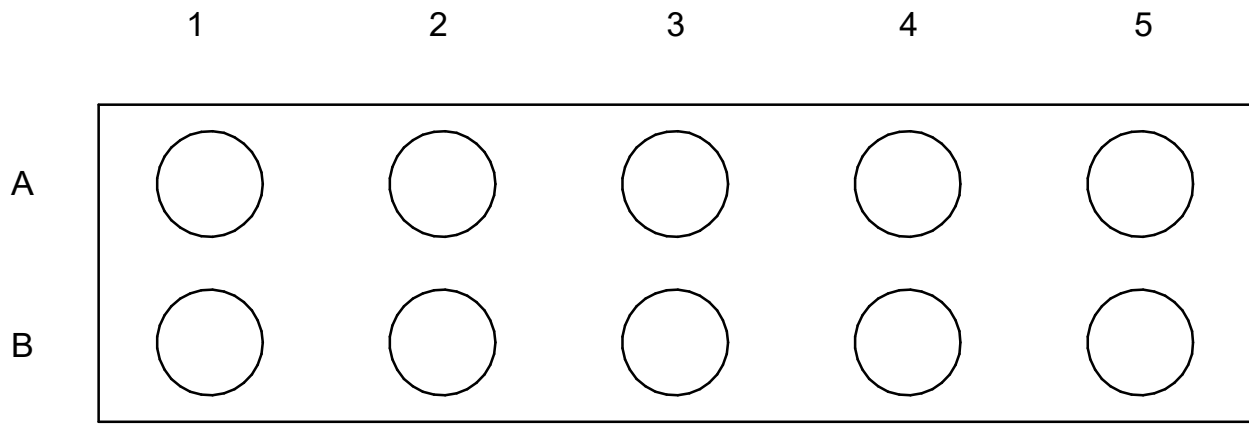

DUCT BANK A

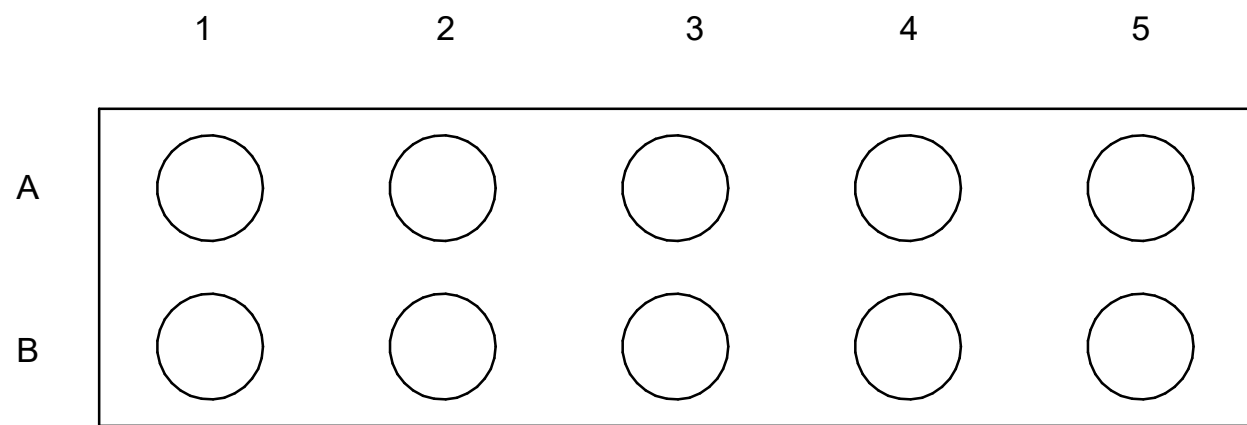

DUCT BANK B

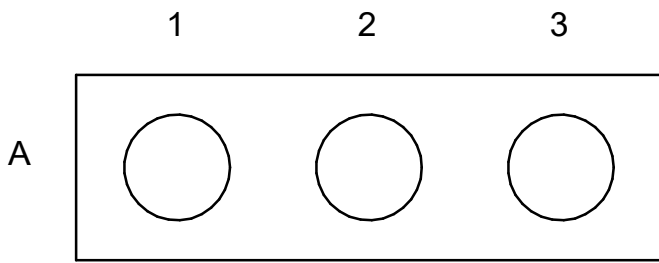

DUCT BANK C

DUCT SCHEDULE A				
DUCT ID	DUCT SIZE	CIRCUIT DESCRIPTION	ORIGIN	DESTINATION
A1	4	3-600KCMIL, 250KCMIL GND, 4"C	GEN-001	ATS-001
A2	4	3-600KCMIL, 250KCMIL GND, 4"C	GEN-001	ATS-001
A3	4	SPARE	GEN-001	ATS-001
A4	4	P12	GEN-001	LP-1
A5	4	3-600KCMIL, 250KCMIL GND, 4"C	GEN-001	ATS-001
B1	4	3-600KCMIL, 250KCMIL GND, 4"C	GEN-001	ATS-001
B2	4	SPARE	GEN-001	ATS-001
B3	4	SPARE	GEN-001	ATS-001
B4	4	3-600KCMIL, 250KCMIL GND, 4"C	GEN-001	ATS-001
B5	4	3-600KCMIL, 250KCMIL GND, 4"C	GEN-001	ATS-001

DUCT SCHEDULE B				
DUCT ID	DUCT SIZE	CIRCUIT DESCRIPTION	ORIGIN	DESTINATION
A1	4	3-600KCMIL, 250KCMIL GND, 4"C	UTILITY TRANSFORMER TX-001	ATS-001 VIA METERING CABINET
A2	4	3-600KCMIL, 250KCMIL GND, 4"C	UTILITY TRANSFORMER TX-001	ATS-001 VIA METERING CABINET
A3	4	SPARE	UTILITY TRANSFORMER TX-001	ATS-001 VIA METERING CABINET
A4	4	SPARE	UTILITY TRANSFORMER TX-001	ATS-001 VIA METERING CABINET
A5	4	3-600KCMIL, 250KCMIL GND, 4"C	UTILITY TRANSFORMER TX-001	ATS-001 VIA METERING CABINET
B1	4	3-600KCMIL, 250KCMIL GND, 4"C	UTILITY TRANSFORMER TX-001	ATS-001 VIA METERING CABINET
B2	4	SPARE	UTILITY TRANSFORMER TX-001	ATS-001 VIA METERING CABINET
B3	4	SPARE	UTILITY TRANSFORMER TX-001	ATS-001 VIA METERING CABINET
B4	4	3-600KCMIL, 250KCMIL GND, 4"C	UTILITY TRANSFORMER TX-001	ATS-001 VIA METERING CABINET
B5	4	3-600KCMIL, 250KCMIL GND, 4"C	UTILITY TRANSFORMER TX-001	ATS-001 VIA METERING CABINET


DUCT SCHEDULE C				
DUCT ID	DUCT SIZE	CIRCUIT DESCRIPTION	ORIGIN	DESTINATION
A1	2	SPARE	GEN-001	RTU
A2	2	C2	GEN-001	RTU
A3	2	N1	GEN-001	RTU

KEYED NOTES:



1. TRANSFORMER IMPEDANCE IS AN ASSUMED NUMBER. COORDINATE WITH THE UTILITY FOR FINAL VALUE.

no.	date	by	ckd	description
0	02/12/26	AMM	MAH	ISSUED FOR BID

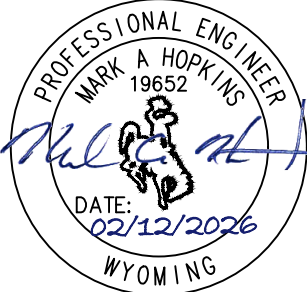


9191 S. JAMAICA STREET
ENGLEWOOD, CO 80112
Burns & McDonnell Engineering Co, Inc

Issue date FEBUARY 2026	detailed by A.BENSON
designed by A. MORRONI	checked by M. HOPKINS



CROSSROADS PUMP STATION
ELECTRICAL
LOAD AND DUCTBANK SCHEDULES

project 124784	contract
drawing 00E-100	rev. 0
sheet 52	of 99 sheets

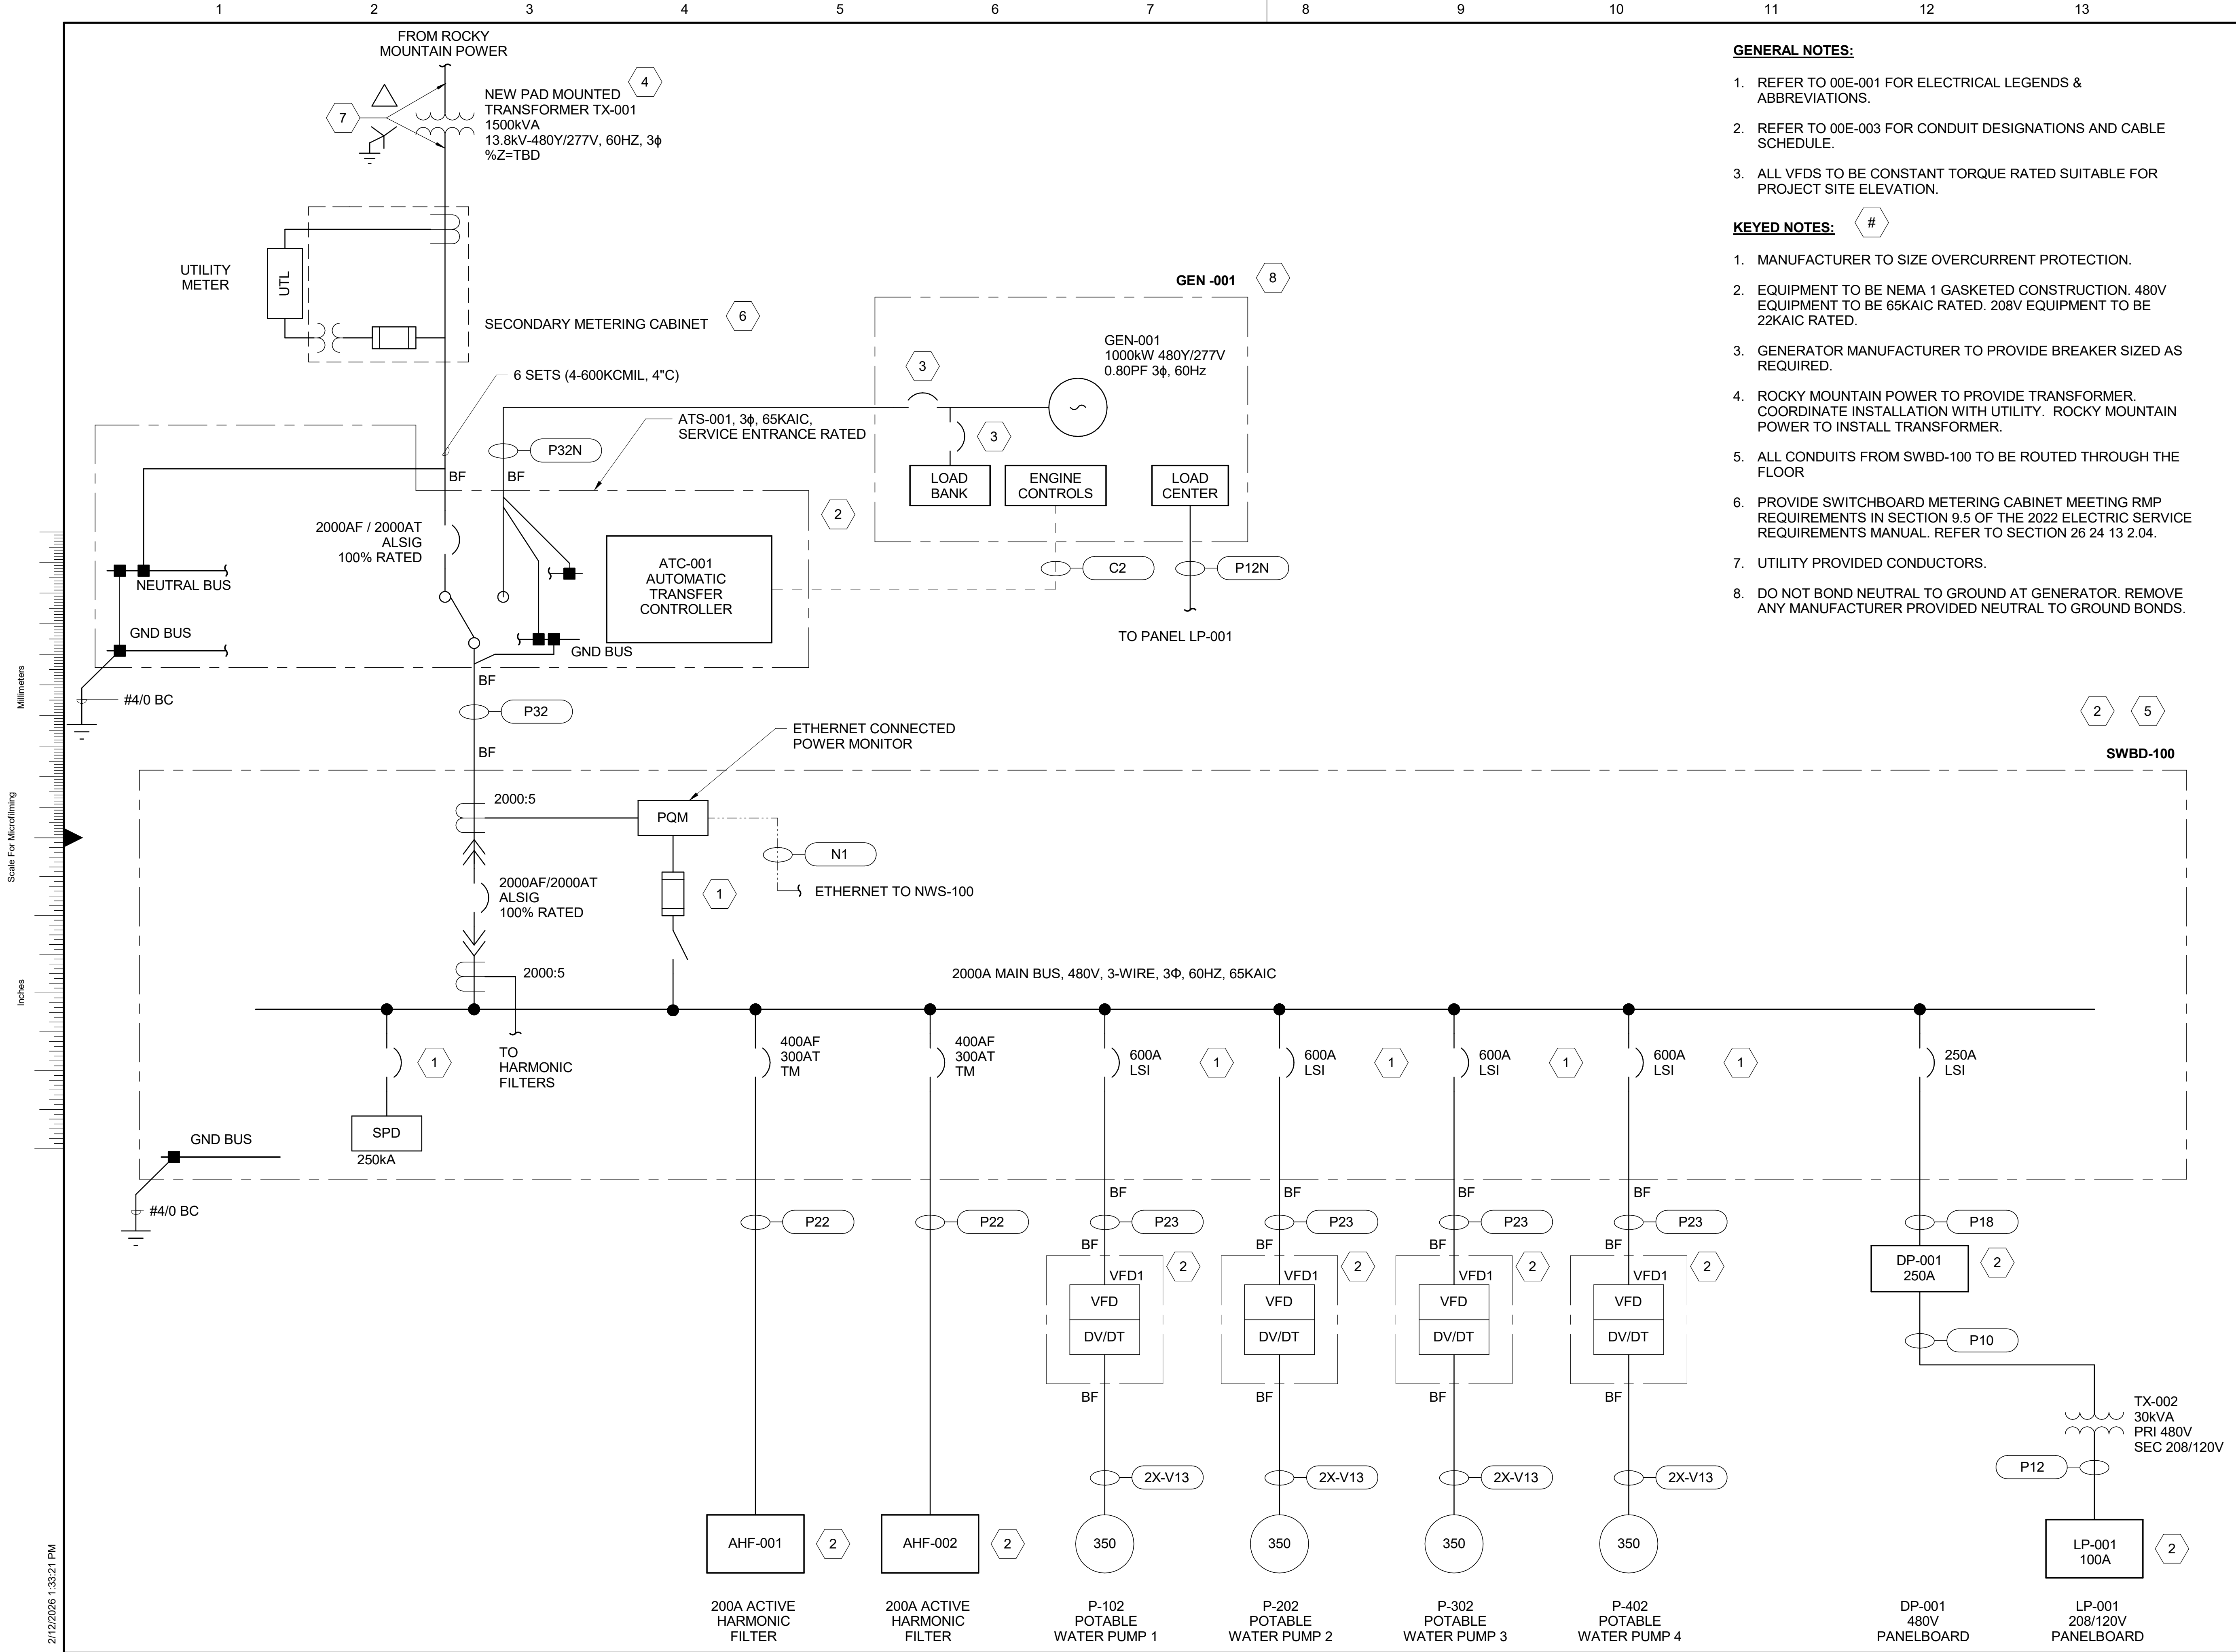

GENERAL NOTES:

- REFER TO 00E-001 FOR ELECTRICAL LEGENDS & ABBREVIATIONS.
- REFER TO 00E-003 FOR CONDUIT DESIGNATIONS AND CABLE SCHEDULE.
- ALL VFDS TO BE CONSTANT TORQUE RATED SUITABLE FOR PROJECT SITE ELEVATION.

KEYED NOTES:

- MANUFACTURER TO SIZE OVERCURRENT PROTECTION.
- EQUIPMENT TO BE NEMA 1 GASKETED CONSTRUCTION. 480V EQUIPMENT TO BE 65KAIC RATED. 208V EQUIPMENT TO BE 22KAIC RATED.
- GENERATOR MANUFACTURER TO PROVIDE BREAKER SIZED AS REQUIRED.
- ROCKY MOUNTAIN POWER TO PROVIDE TRANSFORMER. COORDINATE INSTALLATION WITH UTILITY. ROCKY MOUNTAIN POWER TO INSTALL TRANSFORMER.
- ALL CONDUITS FROM SWBD-100 TO BE ROUTED THROUGH THE FLOOR
- PROVIDE SWITCHBOARD METERING CABINET MEETING RMP REQUIREMENTS IN SECTION 9.5 OF THE 2022 ELECTRIC SERVICE REQUIREMENTS MANUAL. REFER TO SECTION 26 24 13 2.04.
- UTILITY PROVIDED CONDUCTORS.
- DO NOT BOND NEUTRAL TO GROUND AT GENERATOR. REMOVE ANY MANUFACTURER PROVIDED NEUTRAL TO GROUND BONDS.

no.	date	by	ckd	description
0	02/12/26	AMM	MAH	ISSUED FOR BID

Issue date FEBUARY 2026	detailed by A.BENSON
designed by A. MORRONI	checked by M. HOPKINS

CROSSROADS PUMP STATION ELECTRICAL ONE-LINE DIAGRAMS	
project 124784	contract
drawing 00E-110	rev. 0
sheet 53	of 99 sheets

PANELBOARD: DP-001				MAIN BUS: 250 A			MAIN BREAKER/MLO:			250 A				
VOLTS: 480Y/277				PHASE: 3			SYM. A.I.C. MIN.:			65KAIC				
FED FROM: SWBD-100				WIRE: 3			ENCLOSURE:			NEMA 1G				
LOCATION: ELECTRICAL ROOM							MOUNTING:			SURFACE				
DESCRIPTION	NO. POLES	TRIP AMPS	POLE NO.	LOAD - VA			POLE NO.	TRIP AMPS	NO. POLES	DESCRIPTION				
				A	B	C								
EXHAUST FAN EF-1	3	20	1	<--	500.00			2	20	3	AIR HANDLER AH-3			
					2576.00							-->		
			3	<--		500.00						4	2576.00	-->
							500.00							
EXHAUST FAN EF-2	3	20	7	<--	500.00			8	20	3	AIR HANDLER AH-4			
					2576.00								-->	
			9	<--		500.00						10	2576.00	-->
							500.00							
EXHAUST FAN EF-3	3	20	13	<--	500.00			14	20	3	AIR HANDLER AH-5			
					2576.00								-->	
			15	<--		500.00						16	2576.00	-->
							500.00							
EXHAUST FAN EF-4	3	20	19	<--	600.00			20	20	3	AIR HANDLER AH-6			
					2576.00								-->	
			21	<--		600.00						22	2576.00	-->
							600.00							
AIR HANDLER AH-1	3	20	25	<--	2176.00			26	20	3	AIR HANDLER AH-7			
					2576.00								-->	
			27	<--		2176.00						28	2576.00	-->
							2176.00							
AIR HANDLER AH-2	3	20	31	<--	2176.00			32	15	3	SPARE			
					0.00								-->	
			33	<--		2176.00						34	0.00	-->
							2176.00							
BRIDGE CRANE BC-1	3	25	37	<--	2483.00			38	15	3	SPARE			
					0.00								-->	
			39	<--		2483.00						40	0.00	-->
							2483.00							
OVERHEAD DOOR OHD-1	3	15	43	<--	497.00			44	15	3	SPARE			
					0.00								-->	
			45	<--		497.00						46	0.00	-->
							497.00							
SPD 50KA	3	30	49	<--	0.00			50	80	3	LP-1 VIA TX-002 30kVA			
					10000.00								-->	
			51	<--		0.00						52	10000.00	-->
							0.00							
Total kVA Per Phase Load (Including Existing)=					32.31	32.31	32.31	Demand Factor		100.0%				
Unbalance load					0.0%	0.0%	0.0%							
Maximum Unbalance load =							0.0%							
Total Connected Load								Est. Demand Load						
96.94 kVA					116.60 A			96.94 kVA		116.60				

PANELBOARD: LP-001				MAIN BUS: 100 A				MAIN BREAKER/MLO: 100 A				
VOLTS: 208Y/120V				PHASE: 3				SYM. A.I.C. MIN.: 22KAIC				
FED FROM: DP-001				WIRE: 4				ENCLOSURE: NEMA 1G				
LOCATION: ELECTRICAL ROOM								MOUNTING: SURFACE				
DESCRIPTION	NO. POLES	TRIP AMPS	POLE NO.	LOAD - VA			POLE NO.	TRIP AMPS	NO. POLES	DESCRIPTION		
				A	B	C						
LIGHTING - ELEC RM	1	20	1	<--	251.00			2	20	1	RECEPT - ELEC RM	
LIGHTING - PUMP RM	1	20	3	<--	540.00		-->	4	20	1	RECEPT - PIPE GALLERY	
LIGHTING - EXTERIOR	1	20	5	<--		964.00		6	20	1	RECEPT - PUMP RM	
LIGHTING - PIPE GALLERY	1	15	7	<--		720.00		8	20	1	RECEPT - EXTERIOR	
SPARE	1	15	9	<--			470.00	10	20	1	SPARE	
LOUVER L-1	1	15	11	<--			1260.00	12	20	1	PUMP STATION RTU	
LOUVER L-2	1	15	13	<--			187.00	14	100	2	GEN LOAD CENTER	
LOUVER L-3	1	15	15	<--			5000.00	16				
LOUVER L-4	1	15	17	<--			5000.00	18				
LOUVER L-5	1	15	19	<--			187.00	20	15	1	RECEPT - SUMP PUMP	
LOUVER L-6	1	15	21	<--			750.00	22	20	1	SPARE	
EXHAUST FAN EF-5	1	15	23	<--			0.00	24	20	1	SPARE	
SPARE	1	15	25	<--			187.00	26	20	1	SPARE	
SPARE	1	15	27	<--			0.00	28	20	1	SPARE	
SPARE	1	15	29	<--			0.00	30	20	1	SPARE	
SPARE	1	20	31	<--			0.00	32	20	1	SPARE	
SPARE	1	20	33	<--			0.00	34	20	2	SITE LIGHTING	
SPARE	1	20	35	<--			246.00	36				
SPARE	1	20	37	<--			246.00	38				
SPARE	1	20	39	<--			0.00	40	30	3	SPD 50KA	
SPARE	1	20	41	<--			0.00	42				
Total kVA Per Phase Load (Including Existing)=				6.99	7.30	4.29	Demand Factor				100.0%	
Unbalance load				12.9%	17.9%	30.8%						
Maximum Unbalance load =												
Total Connected Load				Est. Demand Load								
18.58 kVA				51.58 A				18.58 kVA				51.58

no.	date	by	ckd	description
0	02/12/26	AMM	MAH	ISSUED FOR BID



9191 S. JAMAICA STREET
ENGLEWOOD, CO 80112
Burns & McDonnell Engineering Co, Inc

Issue date	FEBUARY 2026
------------	--------------

detailed by
A.BENSON

designed by
A. MORRONI

checked by
M. HOPKINS





CROSSROADS PUMP STATION ELECTRICAL PANEL SCHEDULES

project	124784
---------	--------


contract

drawing	rev.
00E-120 —	0

sheet 54 of 99 sheets

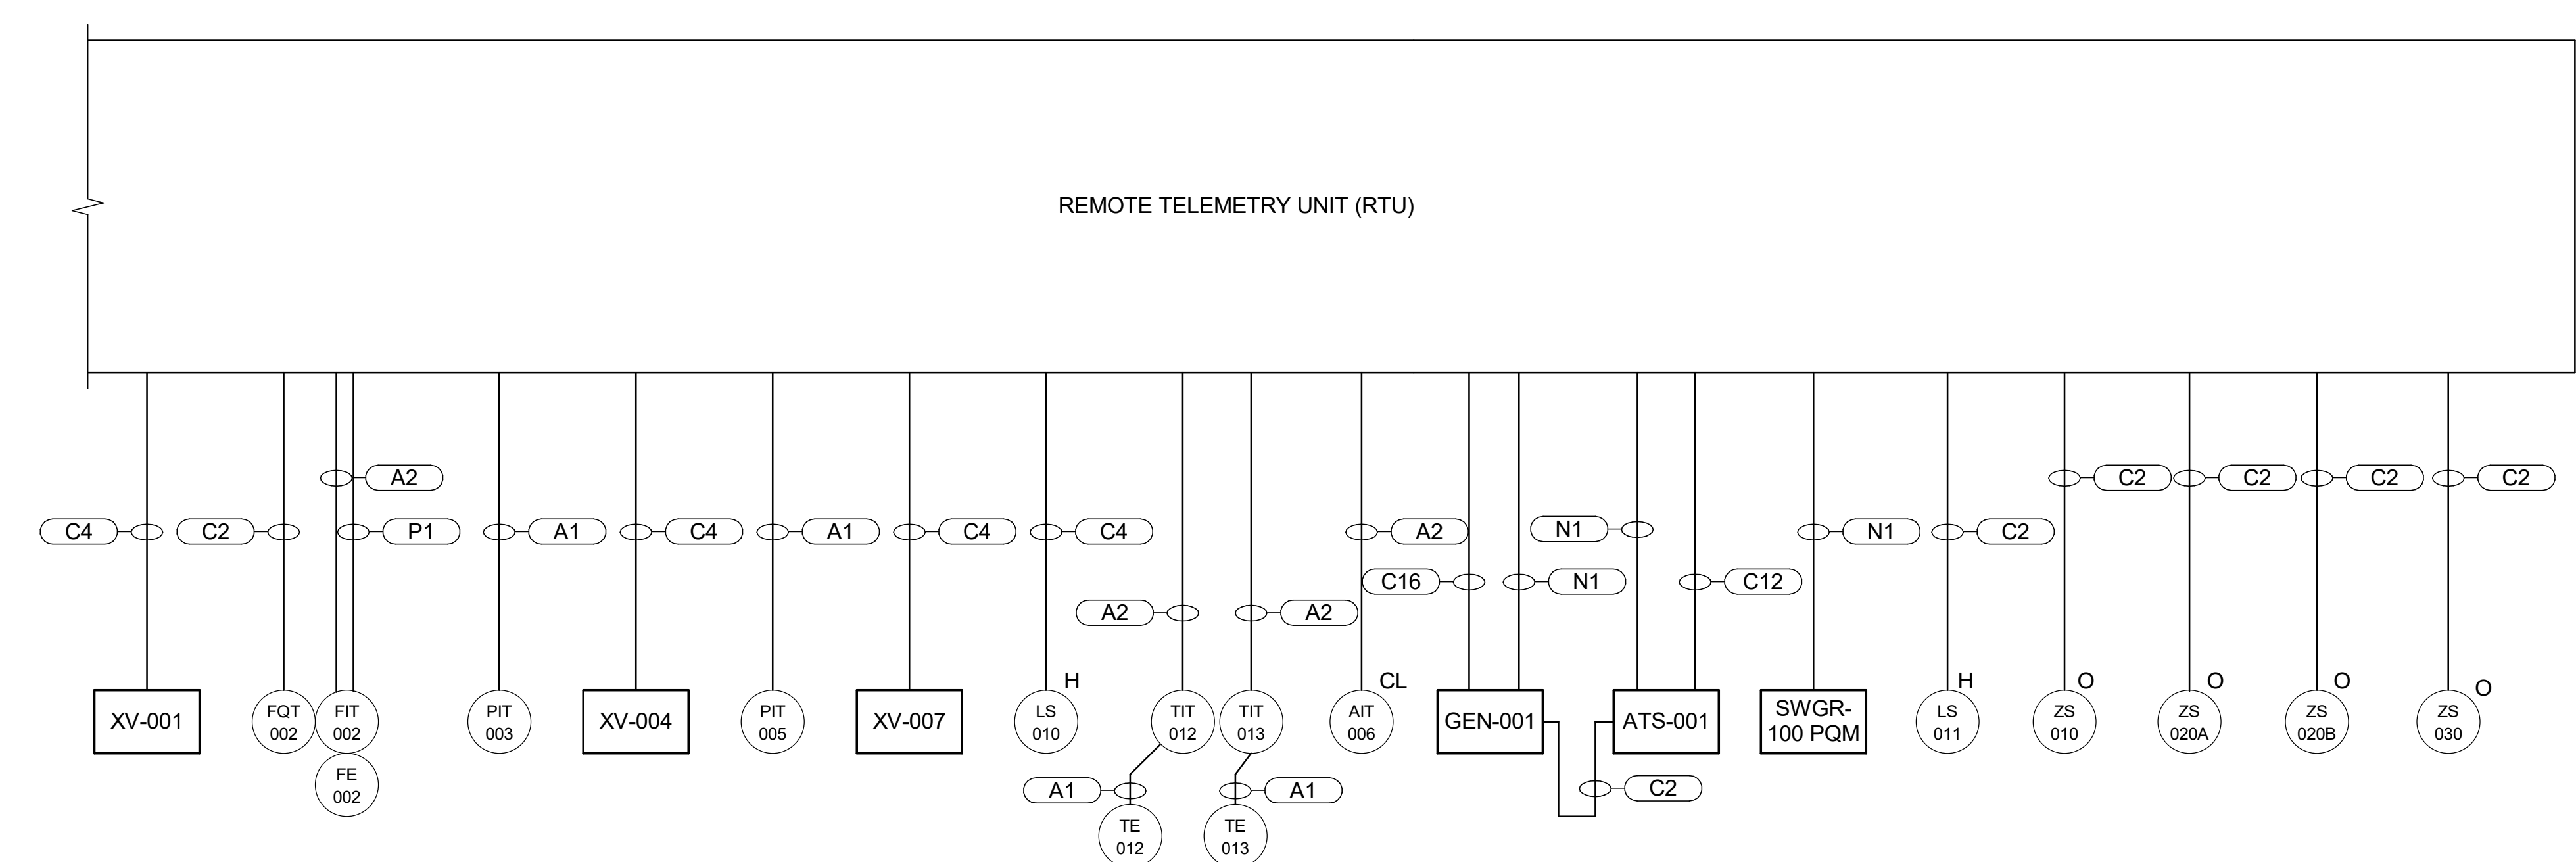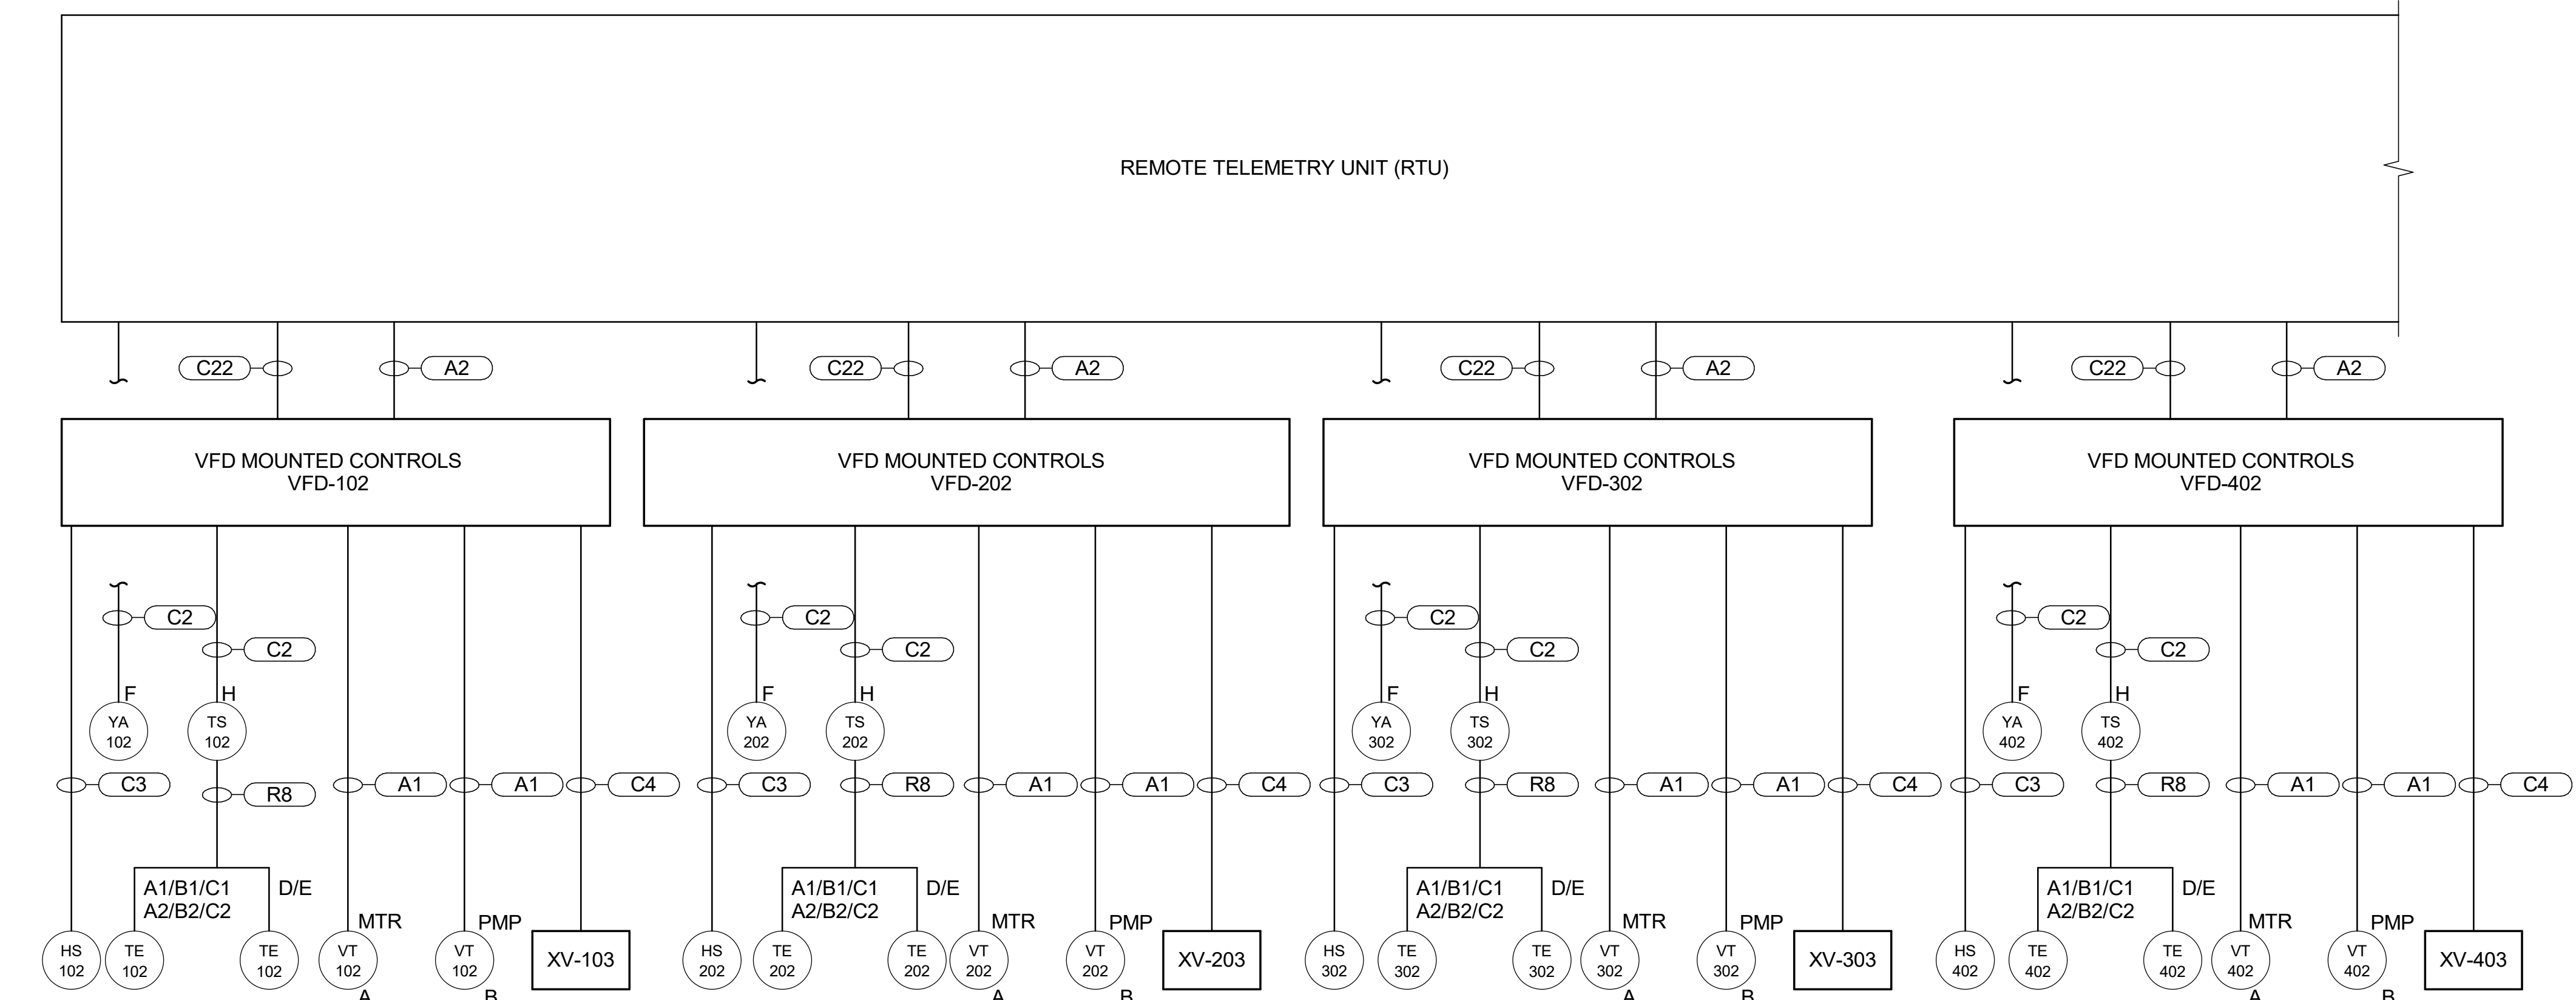

no.	date	by	ckd	description
0	02/12/26	AMM	MAH	ISSUED FOR BID

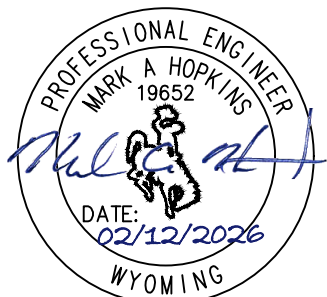



9191 S. JAMAICA STREET
ENGLEWOOD, CO 80112
Burns & McDonnell Engineering Co, Inc

Issue date FEBUARY 2026	detailed by A.BENSON
designed by A. MORRONI	checked by M. HOPKINS



CROSSROADS PUMP STATION ELECTRICAL CONNECTION DIAGRAM	
project 124784	contract
drawing 00E-150	rev. 0
sheet 55	of 99 sheets

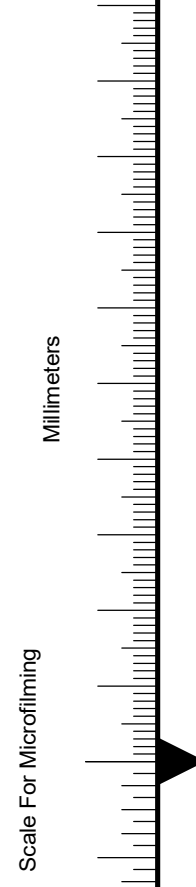


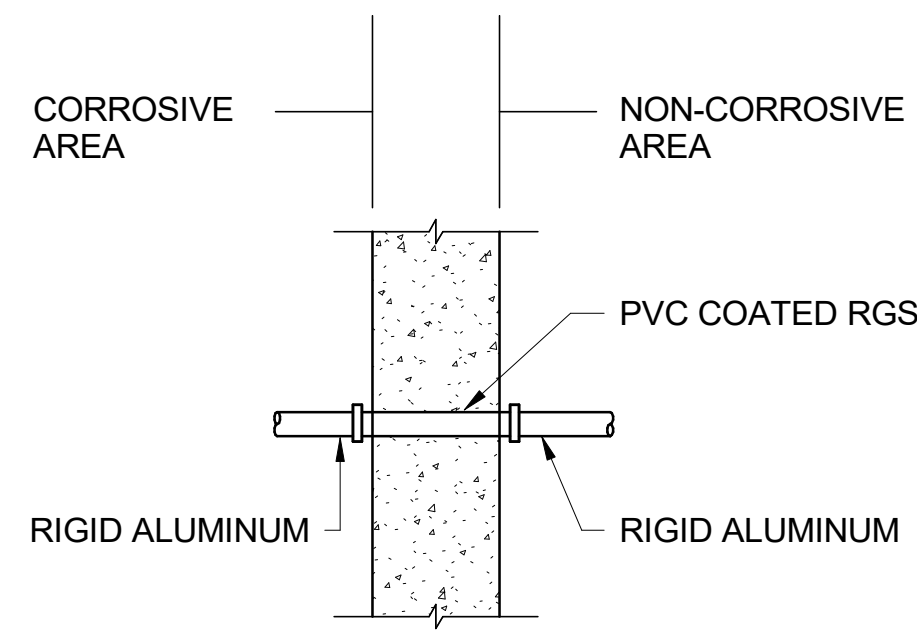

GENERAL NOTE:

1. TYPICAL INTERIOR (CORROSIVE AREAS) EXPOSED CONDUIT INSTALLATION THROUGH CONCRETE/CMU WALL DETAIL


INTERIOR EXPOSED CONDUIT
(CORROSIVE) THROUGH WALL
NOT TO SCALE

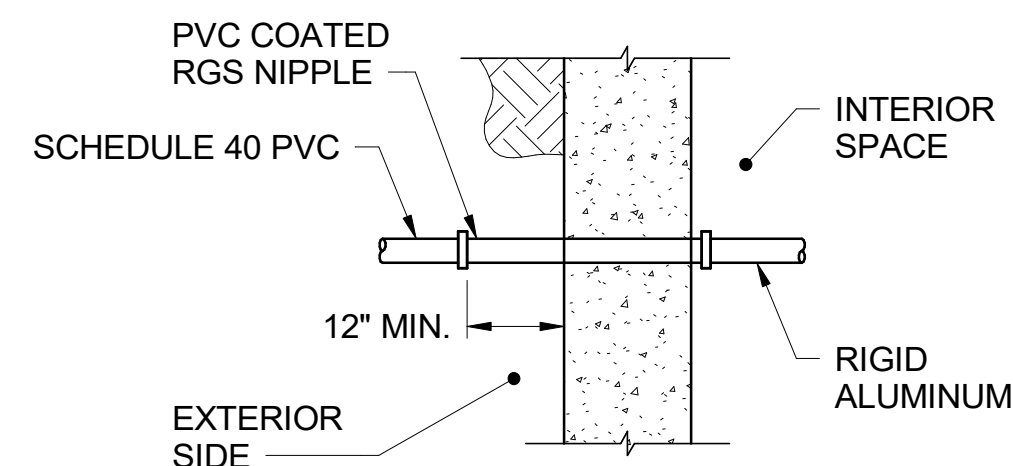

GENERAL NOTE:

- ### 1. TYPICAL BELOW GRADE CONDUIT THROUGH CONCRETE WALL DETAIL


BELOW GRADE CONDUIT CAST IN WALL
NOT TO SCALE

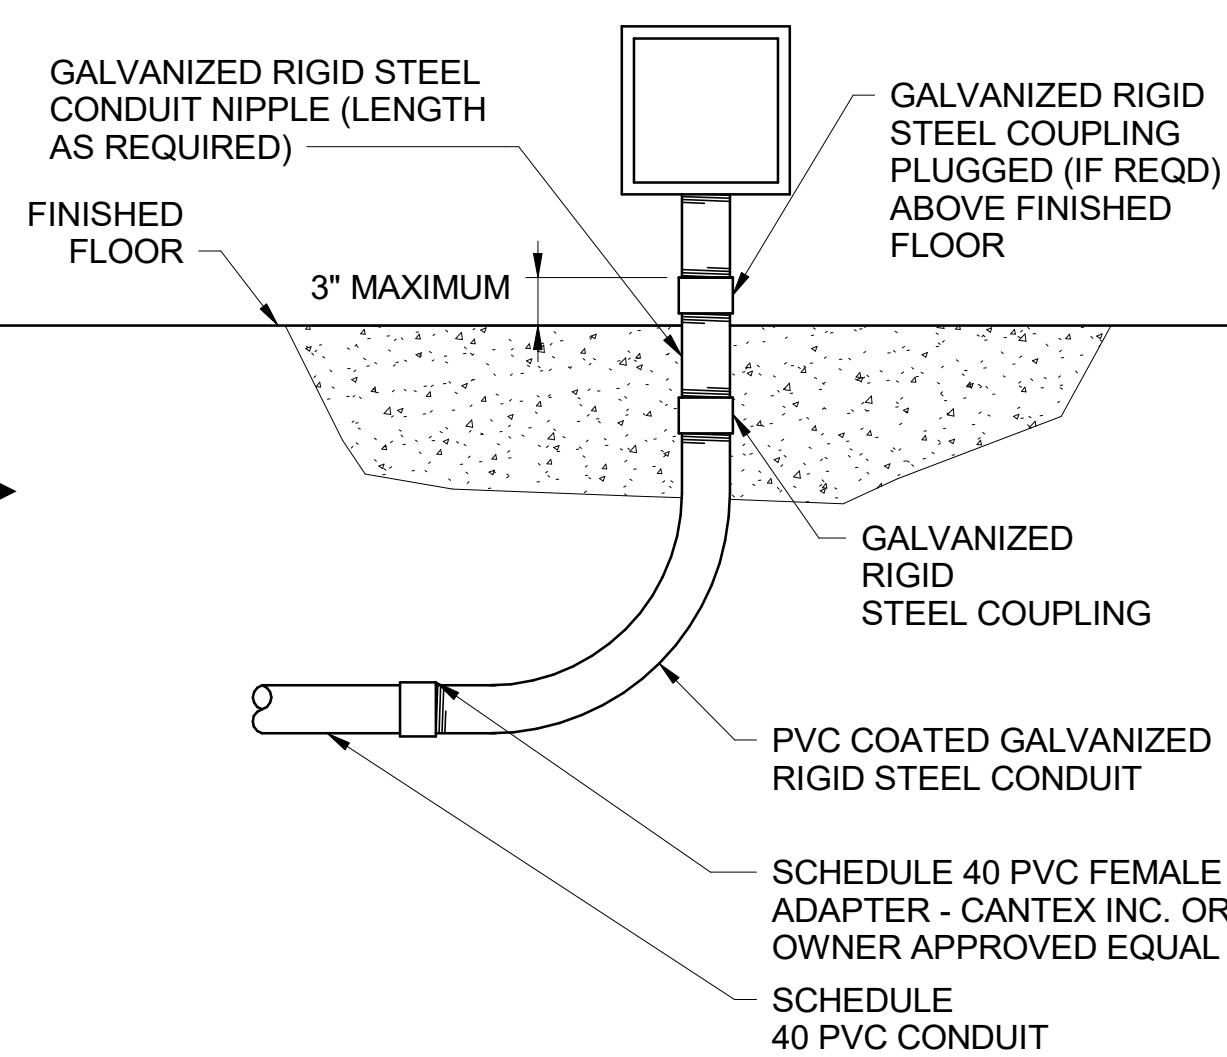

GENERAL NOTES:

1. BACKFILL -
 - A. OBTAIN BACKFILL MATERIALS FROM TRENCHES AND OTHER EXCAVATION IN THIS CONTRACT AND/OR FROM THE ON SITE BORROW AREAS AS DESIGNATED BY THE RESIDENT PROJECT REPRESENTATIVE.
 - B. BACKFILL MATERIALS INCLUDE MATERIAL THAT IS FREE OF DEBRIS, ROOTS, ORGANIC MATTER, REFUSE, CINDERS, FROZEN MATTER, AND ALSO FREE OF ROCK, WITH A DIMENSION GREATER THAN 2 INCHES.
2. COMPACTION -
 - A. PLACE BACKFILL MATERIAL IN LEVEL LAYERS NOT EXCEEDING 8 INCHES.
 - B. USE HAND METHODS TO A HORIZONTAL PLANE OF 12 INCHES ABOVE TOP OF CONDUIT.
 - C. USE APPROVED MECHANICAL METHODS WHERE HAND BACKFILL IS NOT REQUIRED.
 - D. FOR BACKFILL COMPACTION AND MOISTURE CONTENT REQUIREMENTS SEE SECTION 2A (SITE WORK PREPARATION AND EARTHWORK) OF SPECIFICATIONS.
3. DETAIL ALSO APPLIES TO MULTIPLE CONDUIT INSTALLATION AND DIRECT BURIED CABLE.
4. BACKFILL AND COMPACTION REQUIREMENTS ALSO APPLY TO ROADWAY LIGHTING FOUNDATIONS.


ONE CONDUIT RISER
NOT TO SCALE

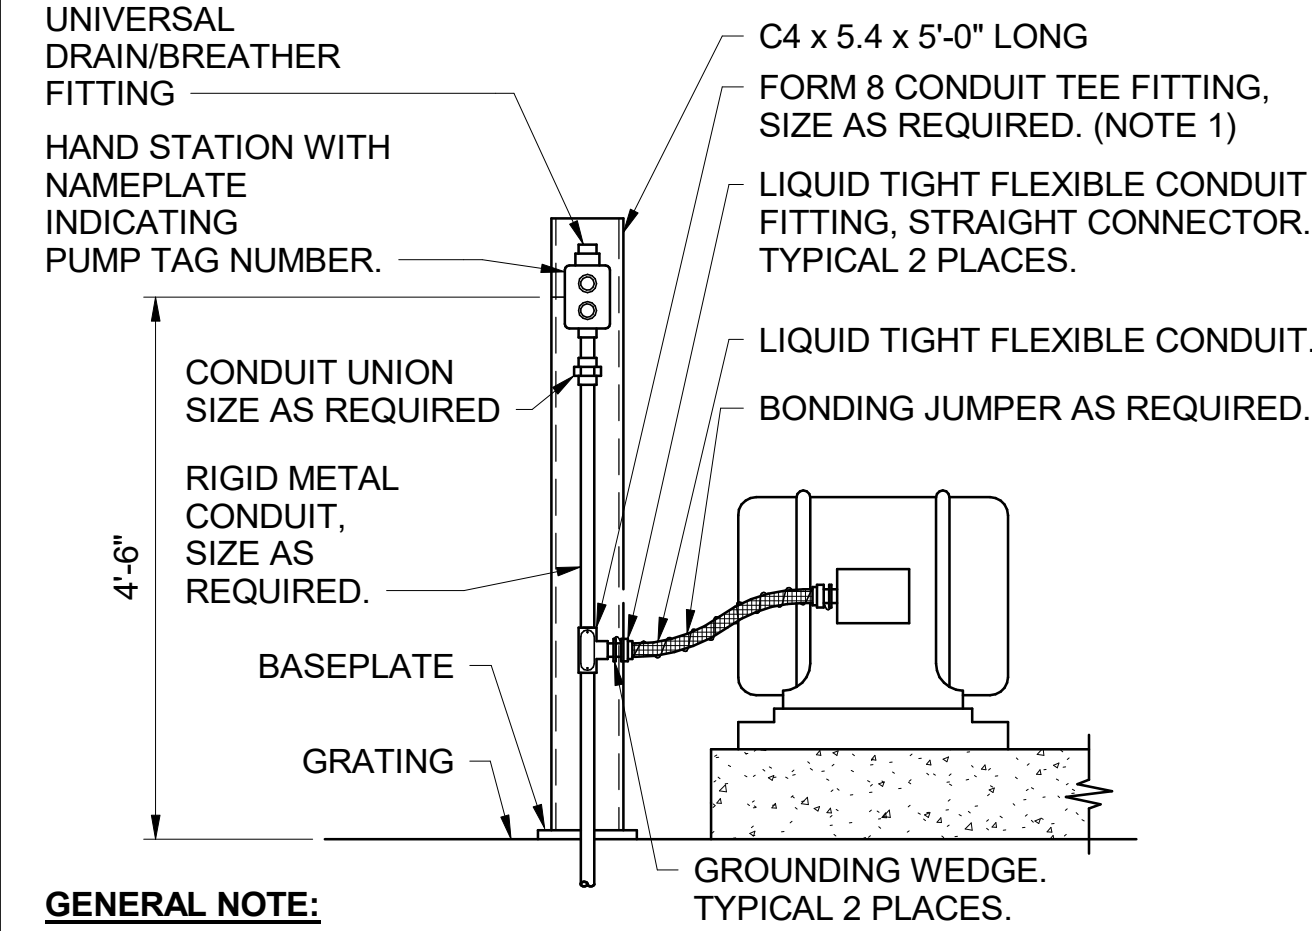


GENERAL NOTE:

1. LOCATE TEE FITTING BELOW ELEVATION OF MOTOR TERMINAL HOUSING TO ALLOW ANY ACCUMULATION OF MOISTURE TO FLOW TOWARD THE DRAIN.
2. MOTOR TERMINATION FOR MOTORS LESS THAN 60HP WITH FEEDER COMING FROM BELOW

FLOOR-FED MOTOR W/ CONTROL STATION
NOT TO SCALE

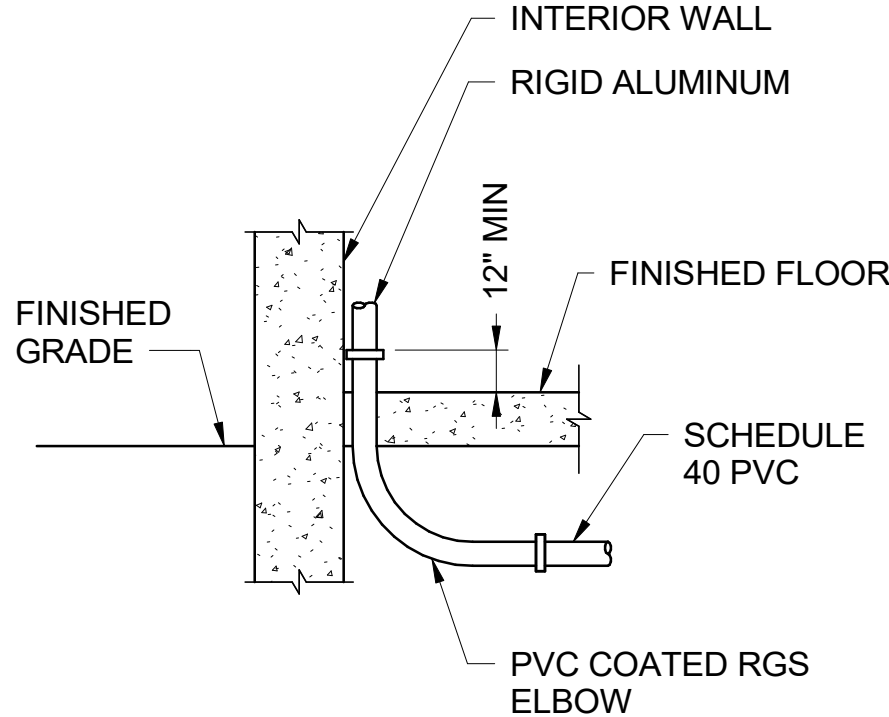


INTERIOR STUB-UP
NOT TO SCALE

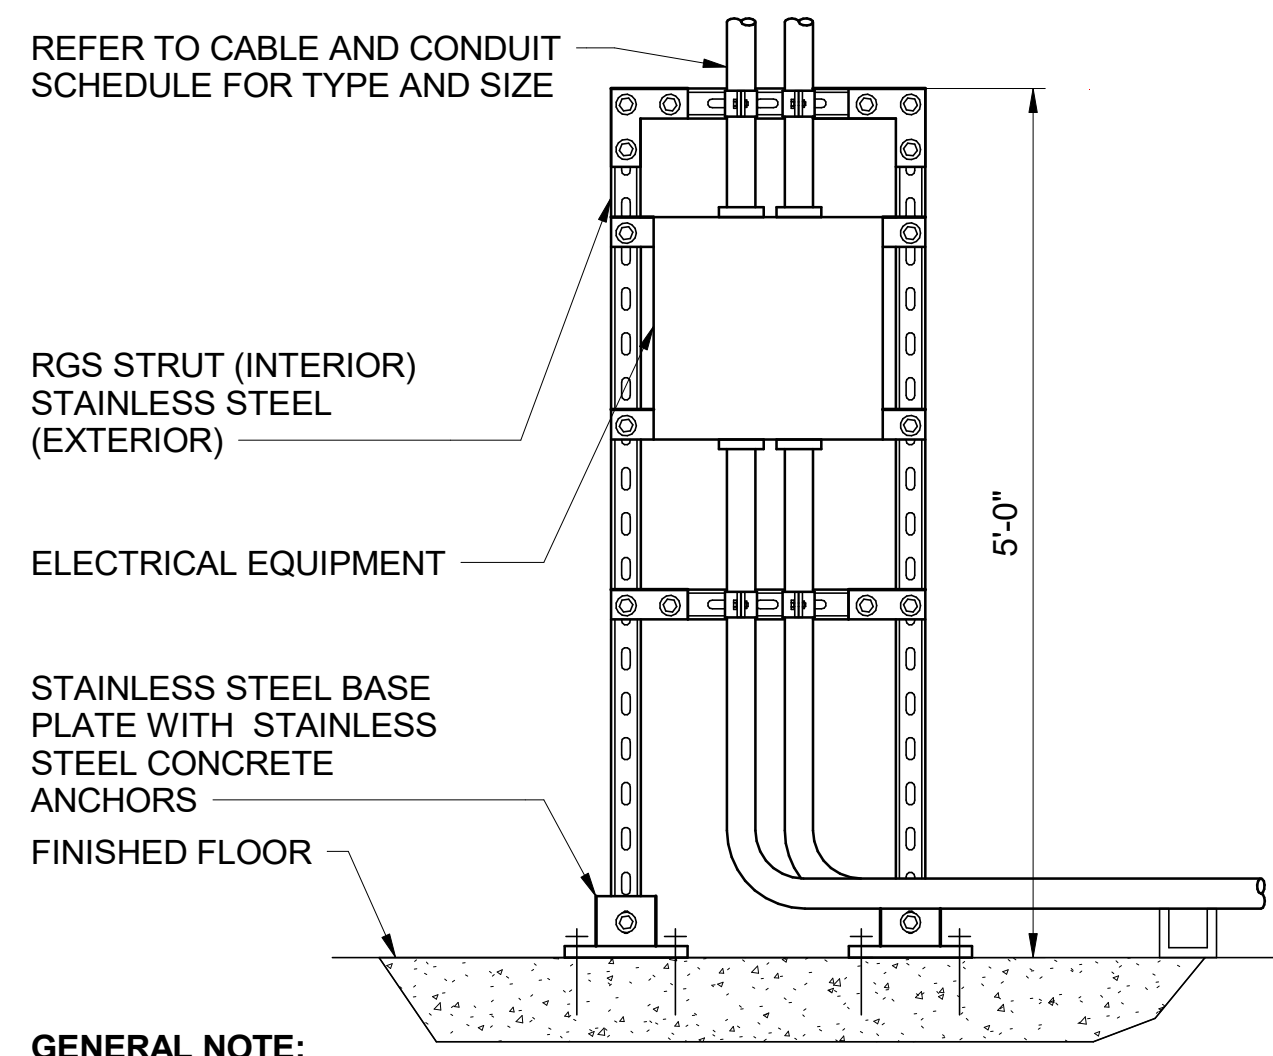

GENERAL NOTE:

1. RACK SIZE IS FOR INFORMATION PURPOSES ONLY. RACK SIZES SHALL BE SIZED TO SUPPORT EQUIPMENT SHOWN ON PLANS.


RACK ELEVATION
NOT TO SCALE

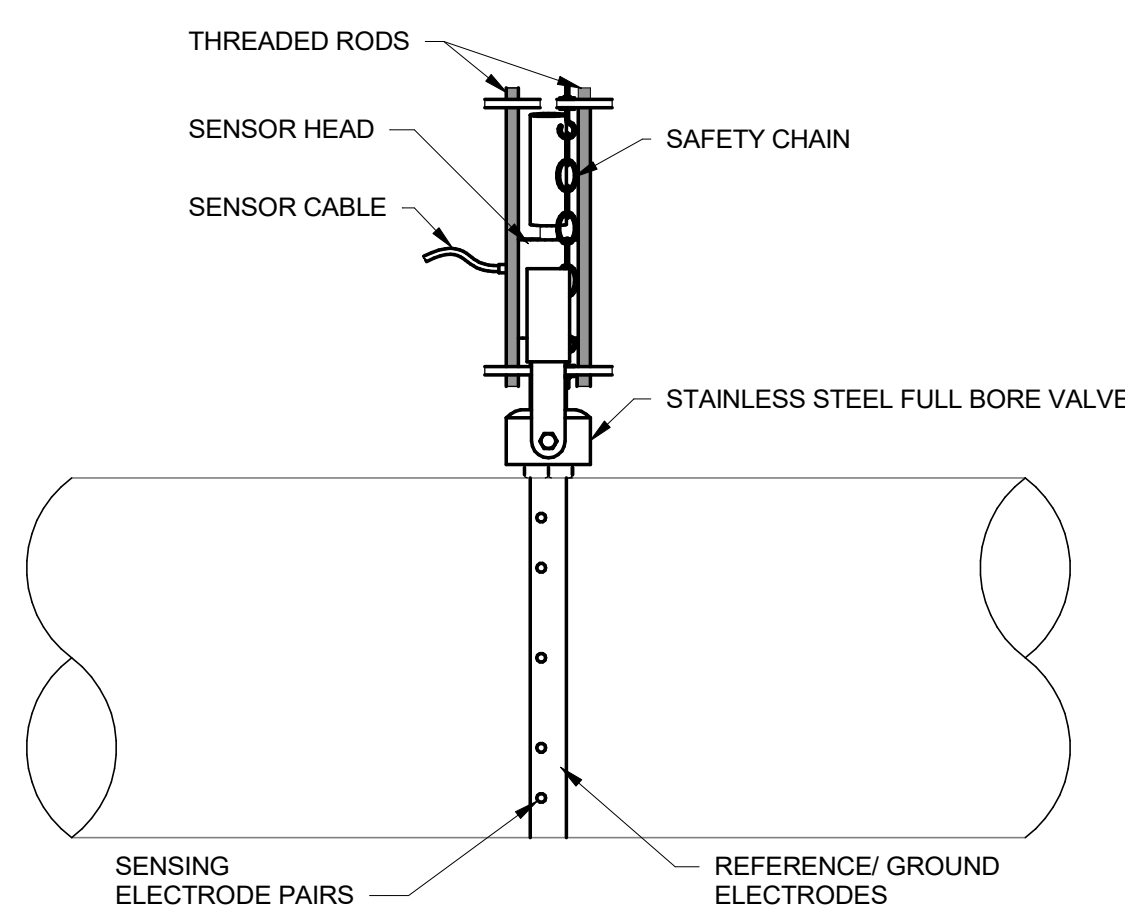

GENERAL NOTES:

1. COORDINATE HOLE AND TAP SIZE WITH MANUFACTURER.
2. CONTRACTOR TO VERIFY FLOW METER SIZING AND DIMENSIONS FOR PROJECT PIPE SIZE AND FLOW RATES.

INSERTION ELECTROMAGNETIC FLOW
METER
NOT TO SCALE

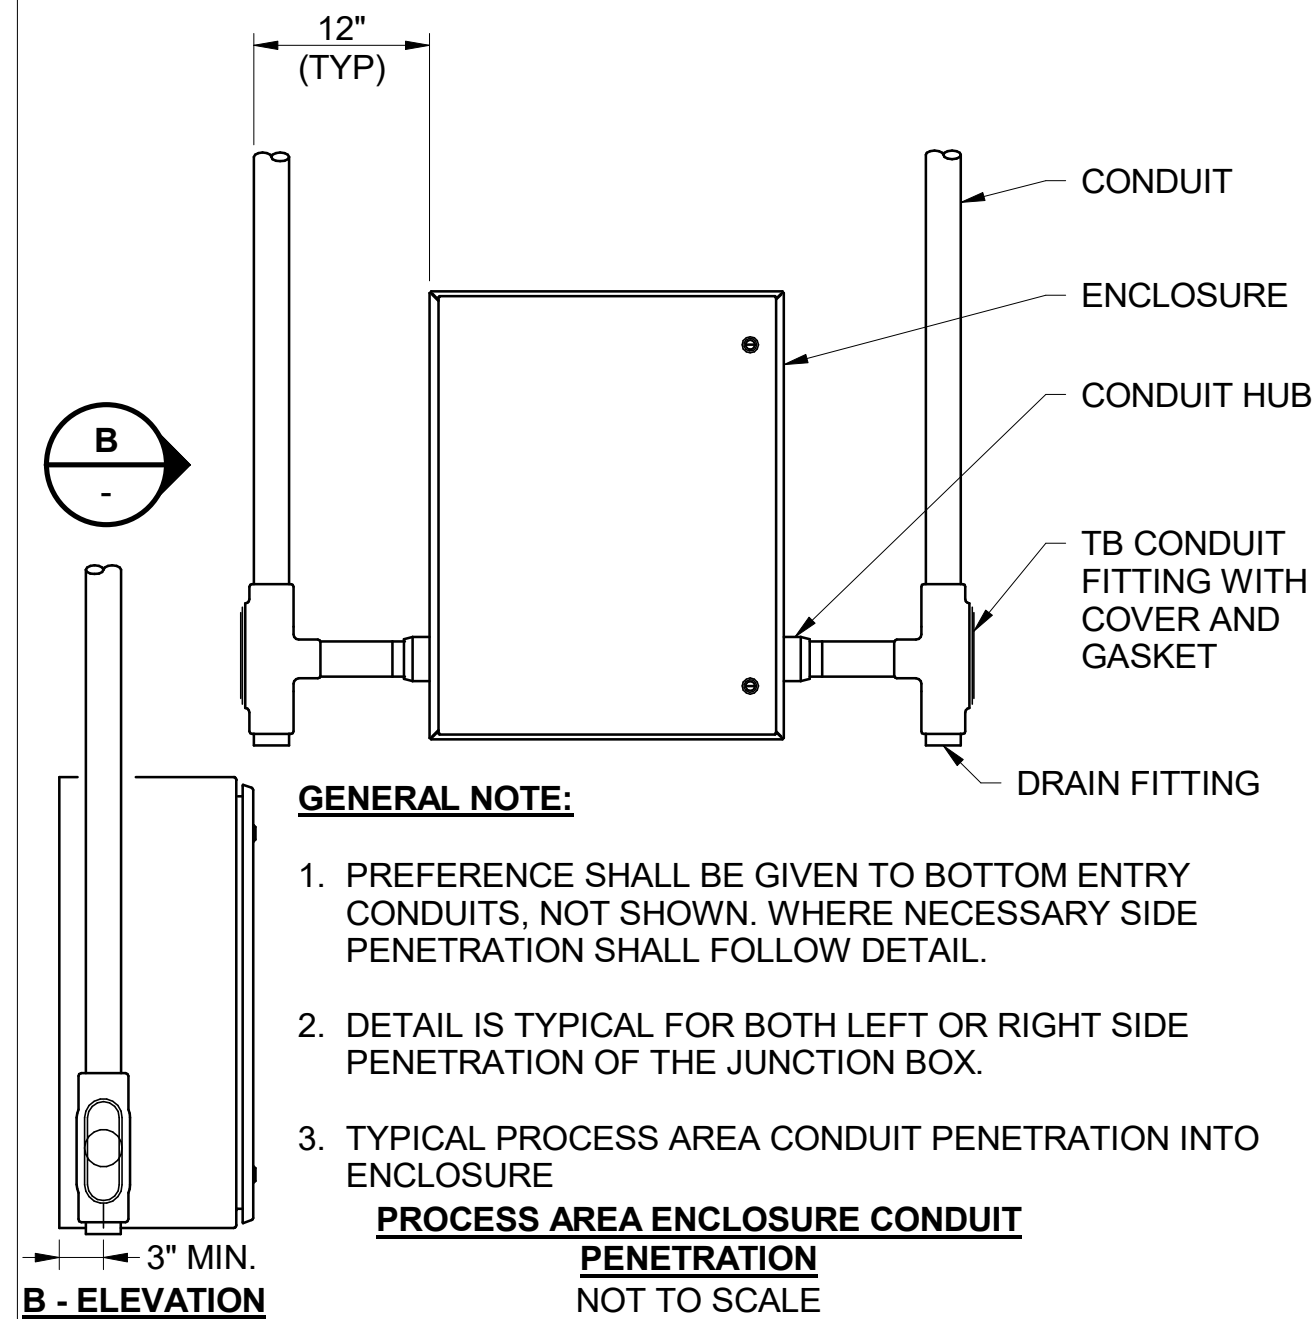

GENERAL NOTE:

1. PREFERENCE SHALL BE GIVEN TO BOTTOM ENTRY CONDUITS, NOT SHOWN. WHERE NECESSARY SIDE PENETRATION SHALL FOLLOW DETAIL.
2. DETAIL IS TYPICAL FOR BOTH LEFT OR RIGHT SIDE PENETRATION OF THE JUNCTION BOX.
3. TYPICAL PROCESS AREA CONDUIT PENETRATION INTO ENCLOSURE

PROCESS AREA ENCLOSURE CONDUIT
PENETRATION
NOT TO SCALE



9191 S. JAMAICA STREET
ENGLEWOOD, CO 80112

Burns & McDonnell Engineering Co, Inc

Issue date	FEBUARY 2026
------------	--------------

detailed by
A.BENSON

designed by
A. MORRONI

checked by
M. HOPKINS



CROSSROADS PUMP STATION

ELECTRICAL

DETAILS I


project	124784
---------	--------

contract


drawing	rev.
---------	------

00E-300 — 0


sheet 57 of 99 sheets

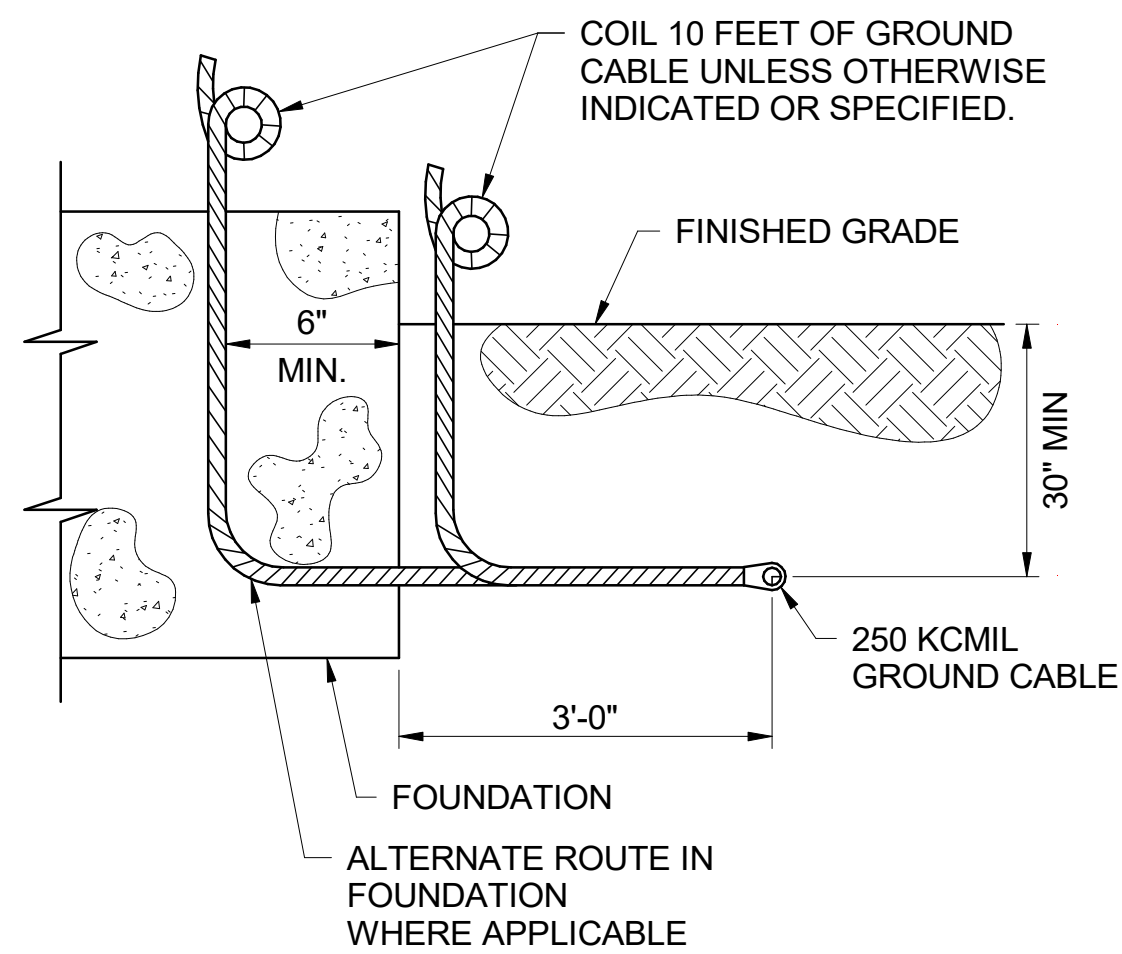


BURIED GROUND GRID
NOT TO SCALE

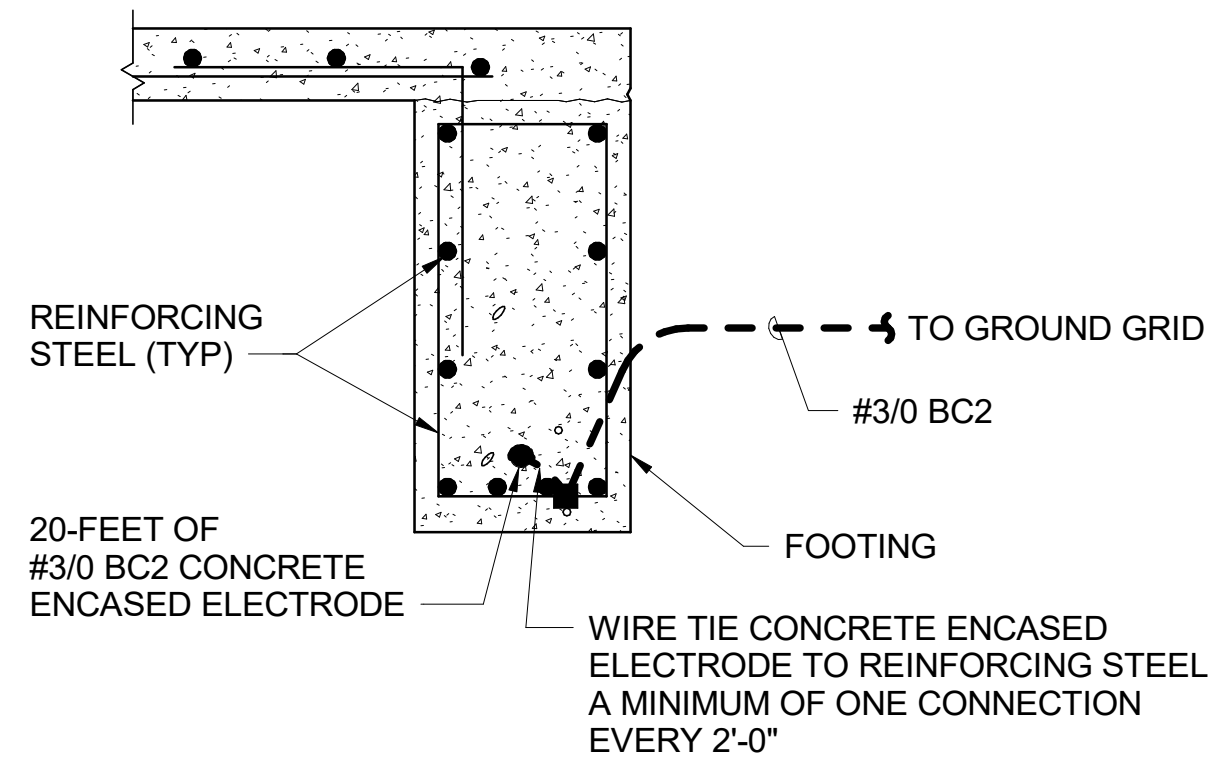


CONCRETE ENCASED ELECTRODE
(FOOTER)
NOT TO SCALE

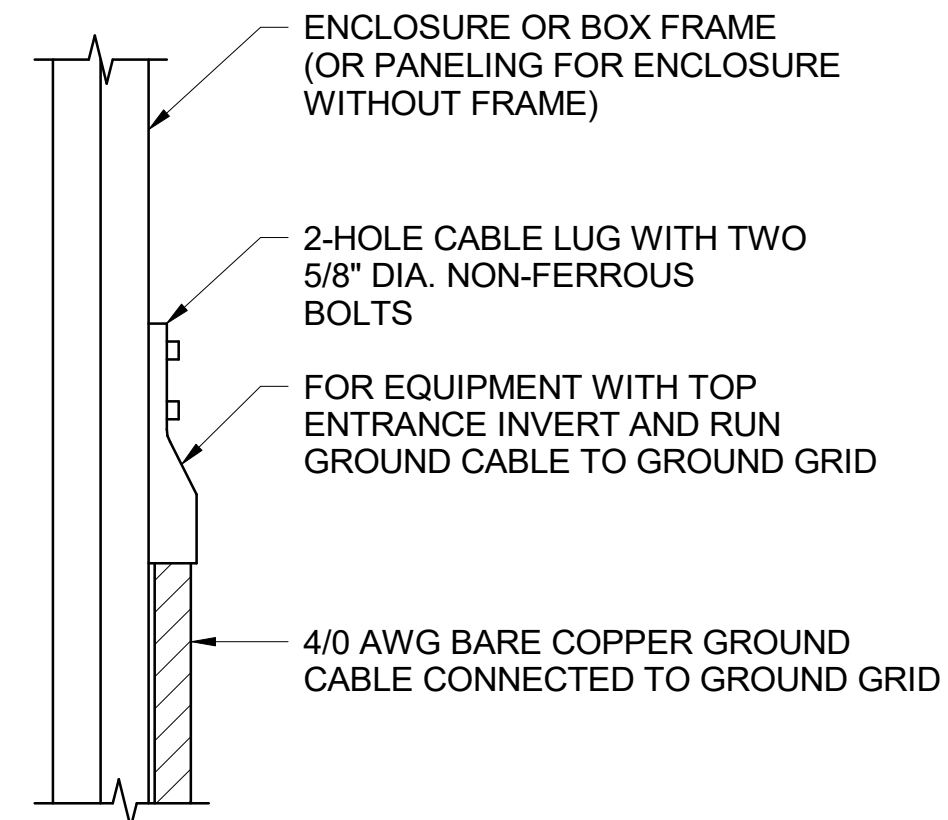


EQUIPMENT ENCLOSURE GROUNDING
NOT TO SCALE

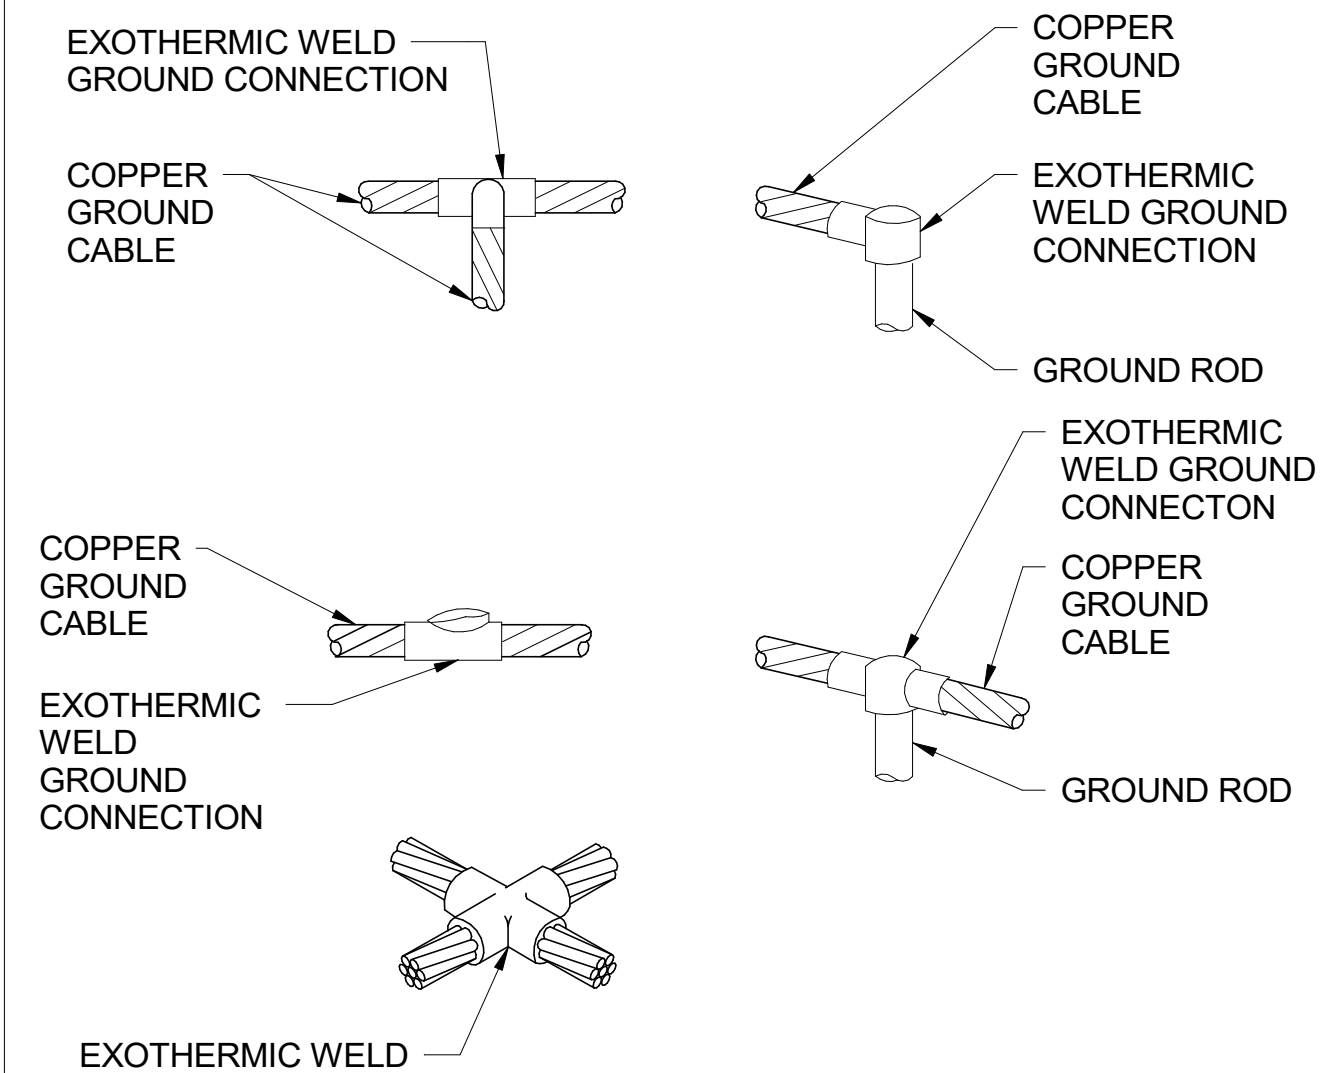


EXOTHERMIC WELDS
NOT TO SCALE

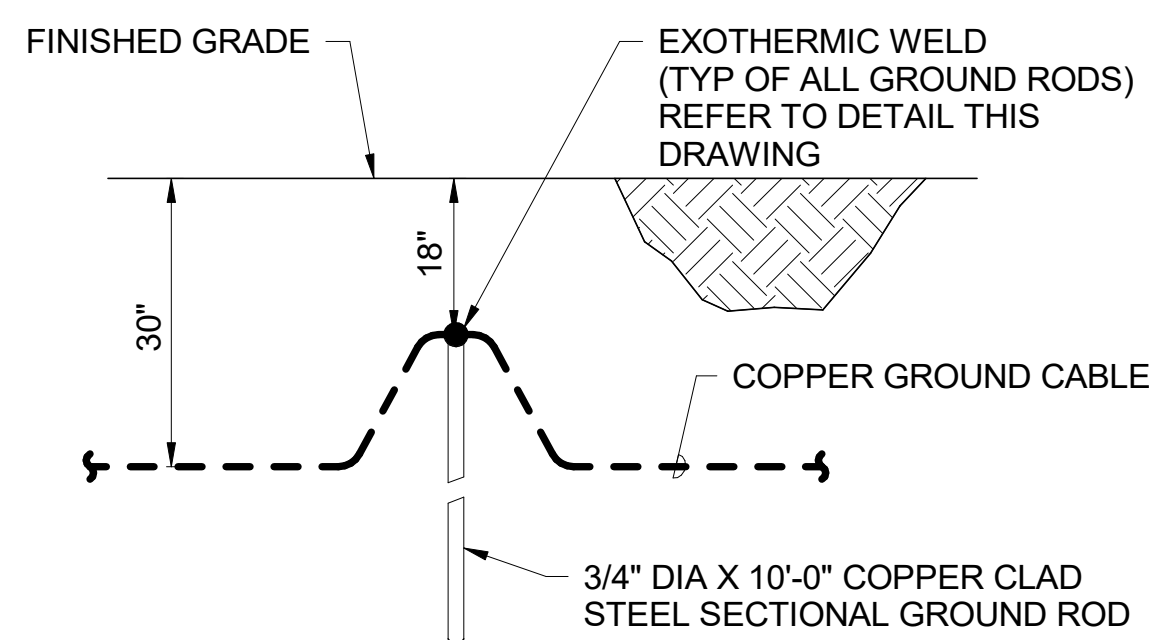

GROUND ROD INSTALLATION
NOT TO SCALE

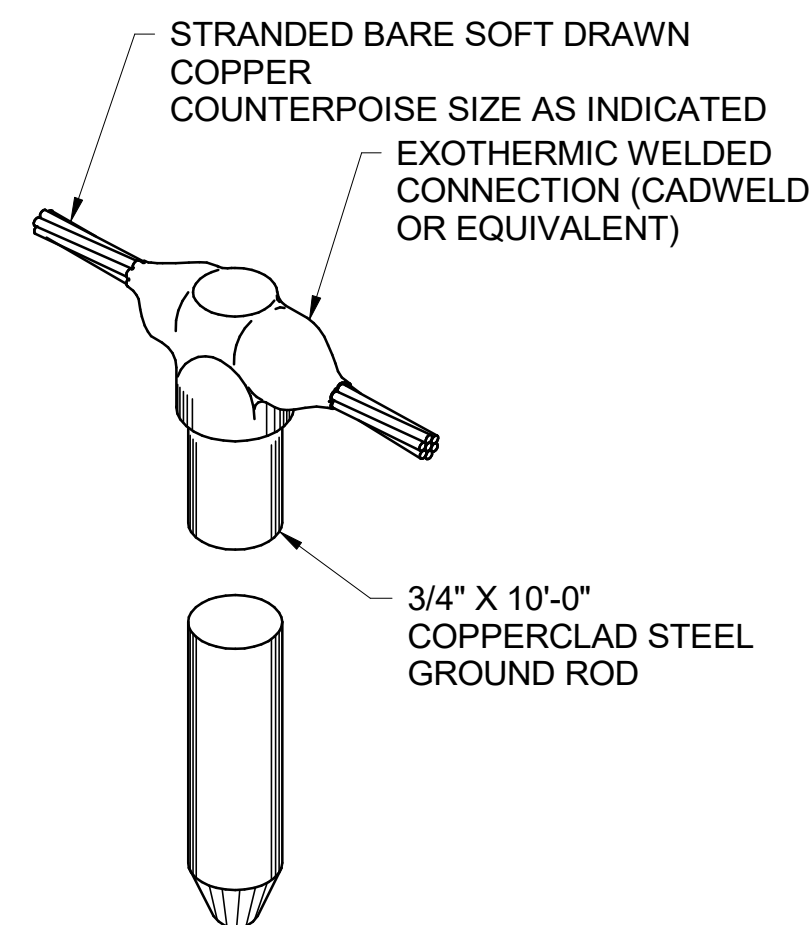


GROUND ROD WELD
NOT TO SCALE

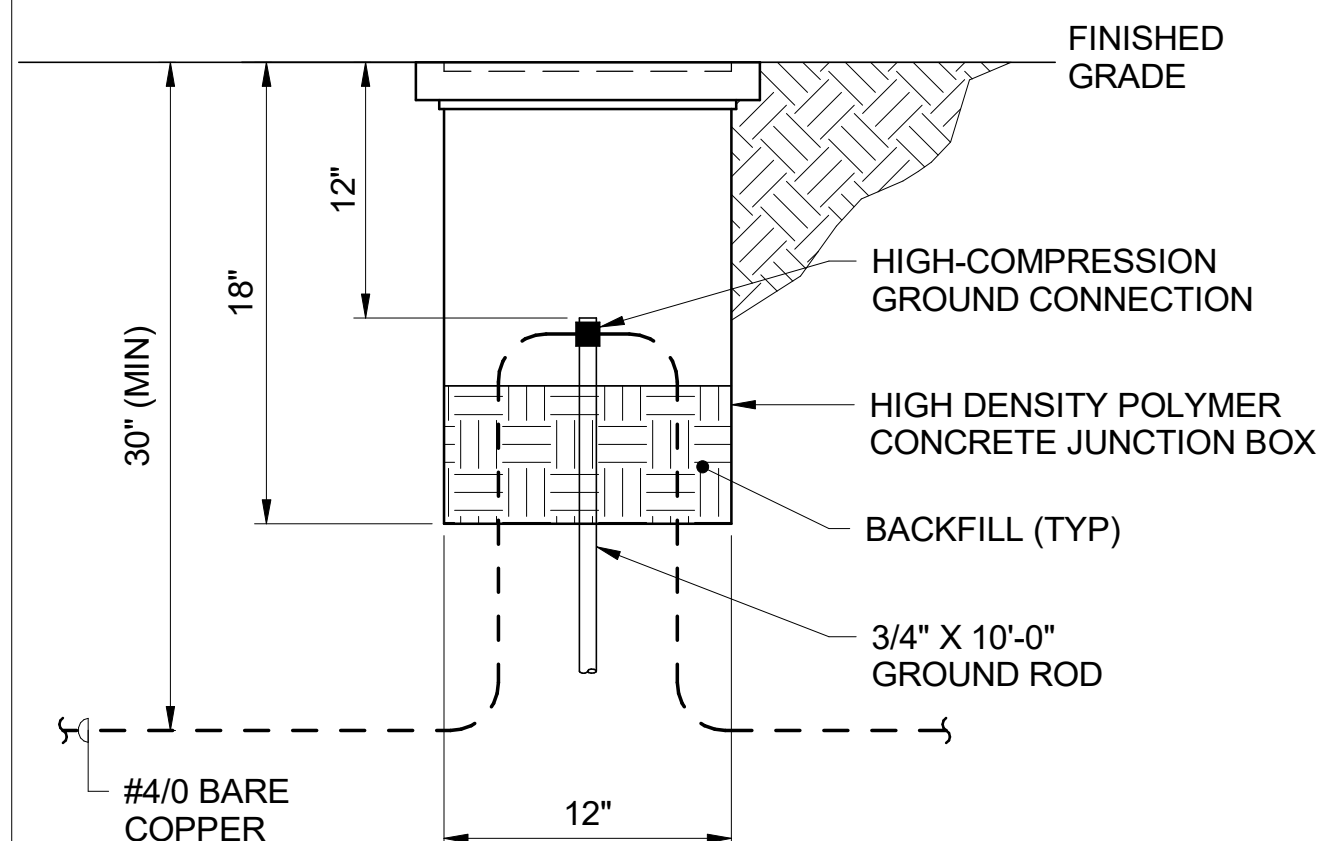


SECTION 


NOT TO SCALE

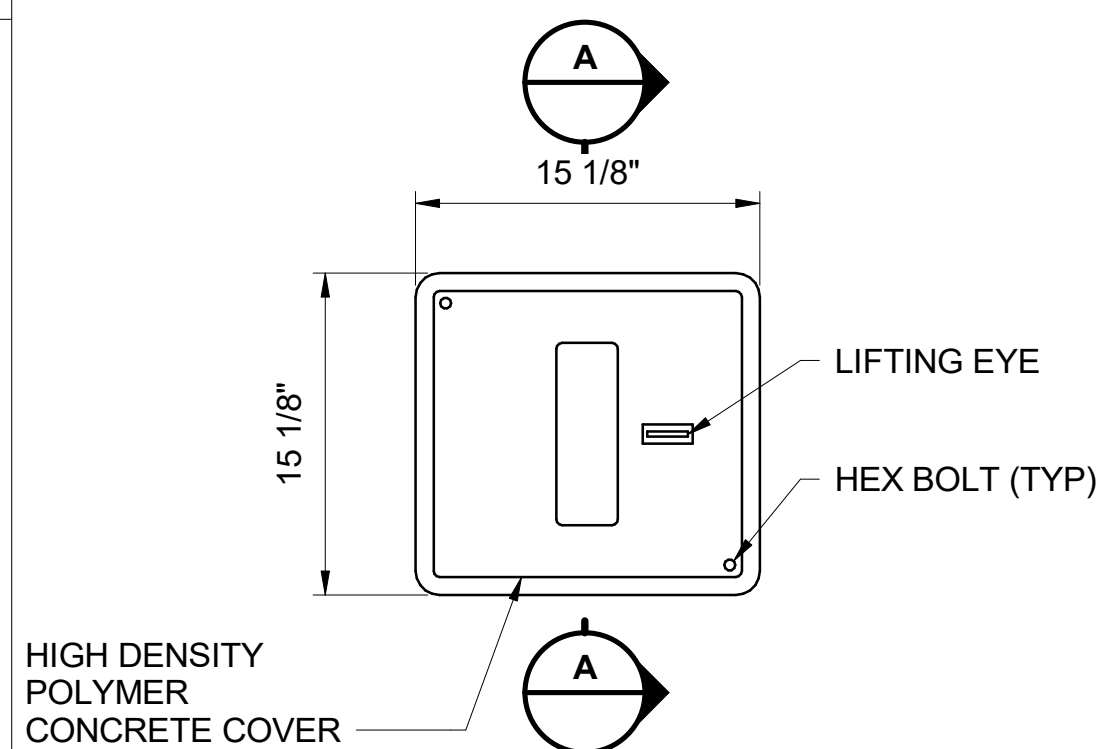


GROUND TEST WELL
NOT TO SCALE

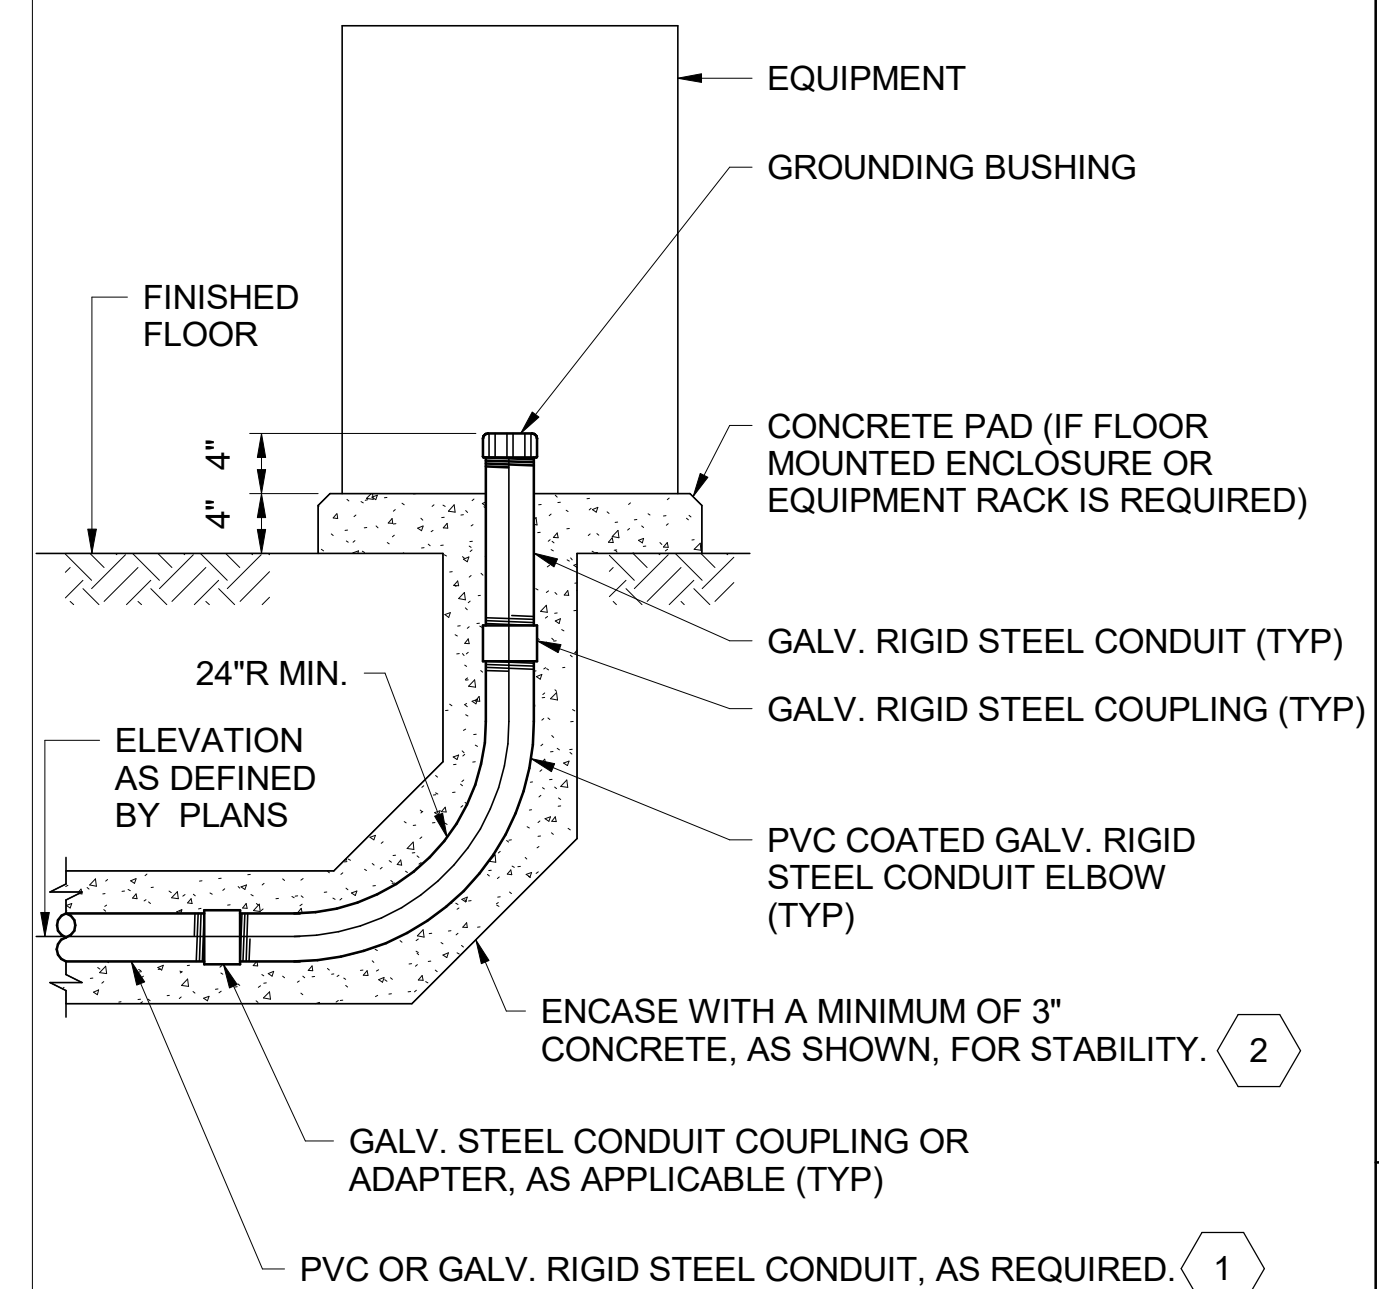


EXTERIOR DUCT BANK RISER
NOT TO SCALE

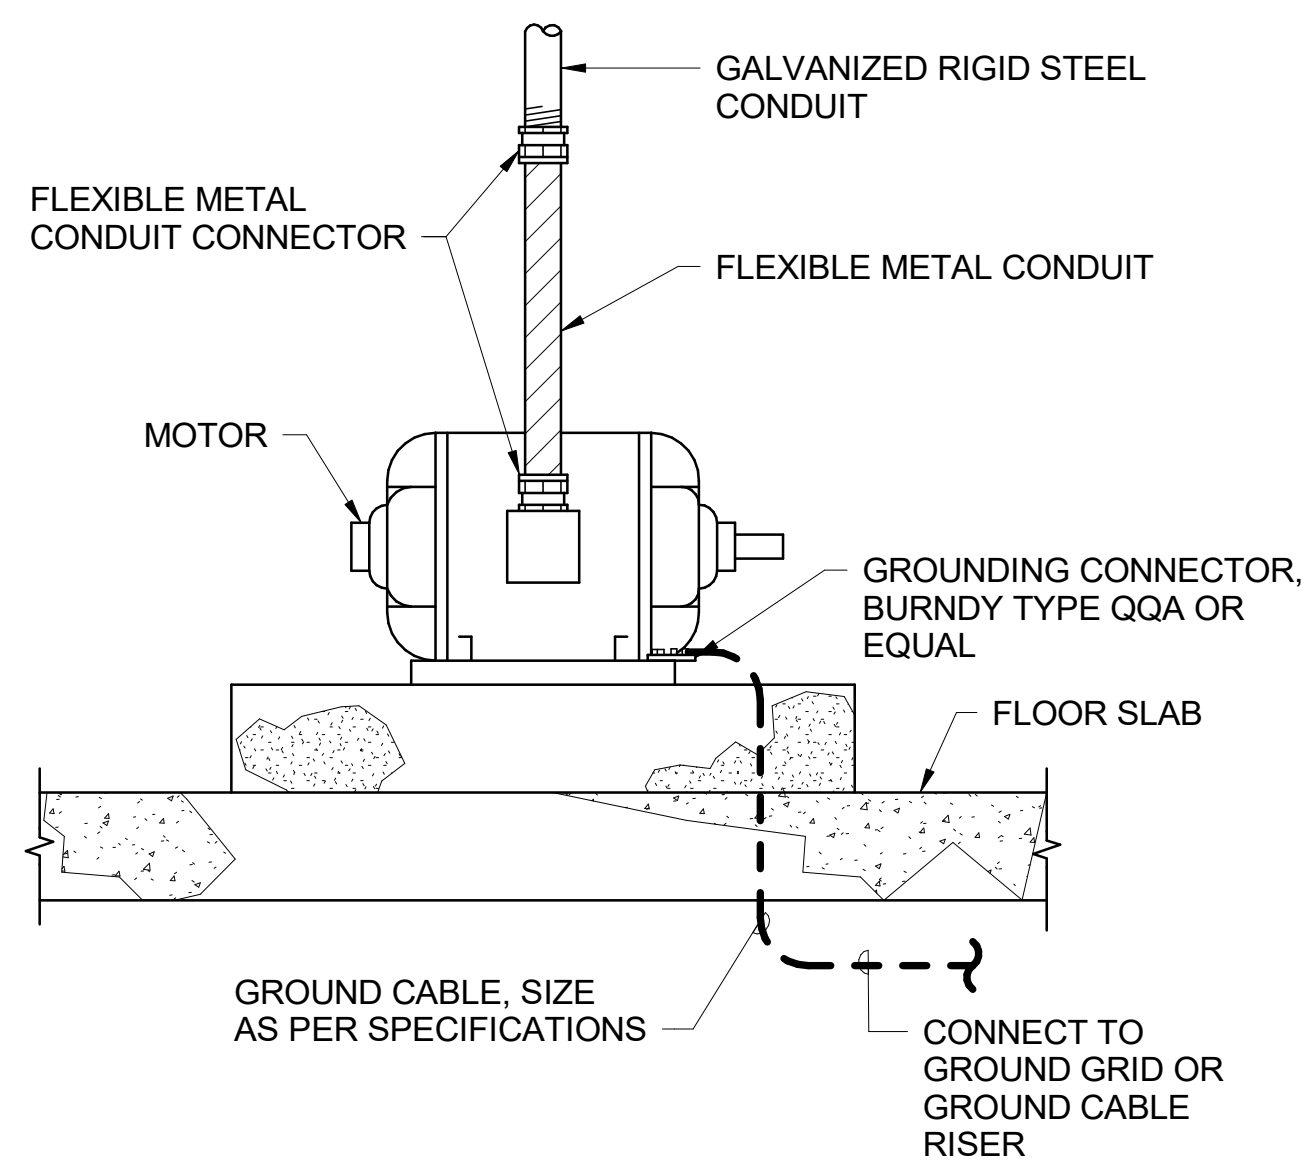


LARGE MOTOR GROUNDING
NOT TO SCALE

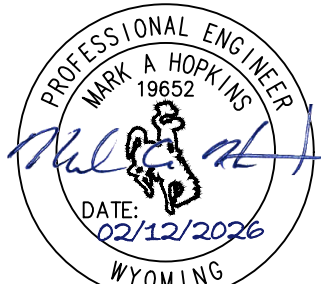
no.	date	by	ckd	description
0	02/12/26	AMM	MAH	ISSUED FOR BID
				
 BURNS MCDONNELL 9191 S. JAMAICA STREET ENGLEWOOD, CO 80112 Burns & McDonnell Engineering Co, Inc				
Issue date FEBRUARY 2026		detailed by A. BENSON		
designed by A. MORRONI		checked by M. HOPKINS		
 SUNRISE ENGINEERING				
CROSSROADS PUMP STATION ELECTRICAL DETAILS II				
project 124784		contract		
drawing 00E-301		rev. 0		
sheet 58		of 99 sheets		

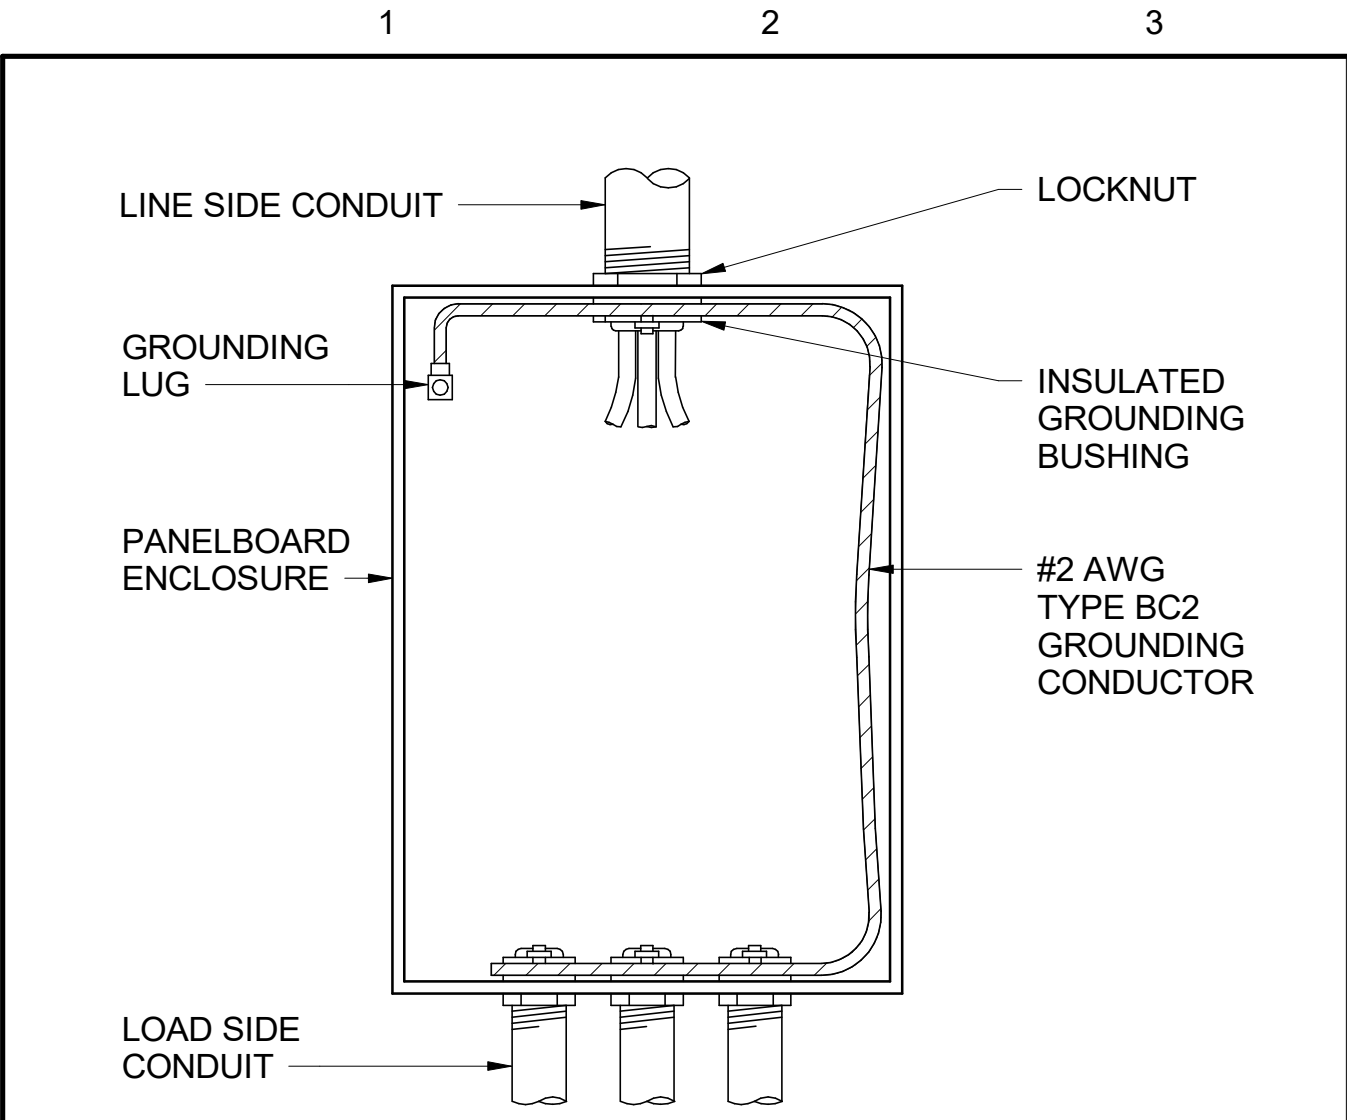


PANELBOARD GROUNDING
NOT TO SCALE

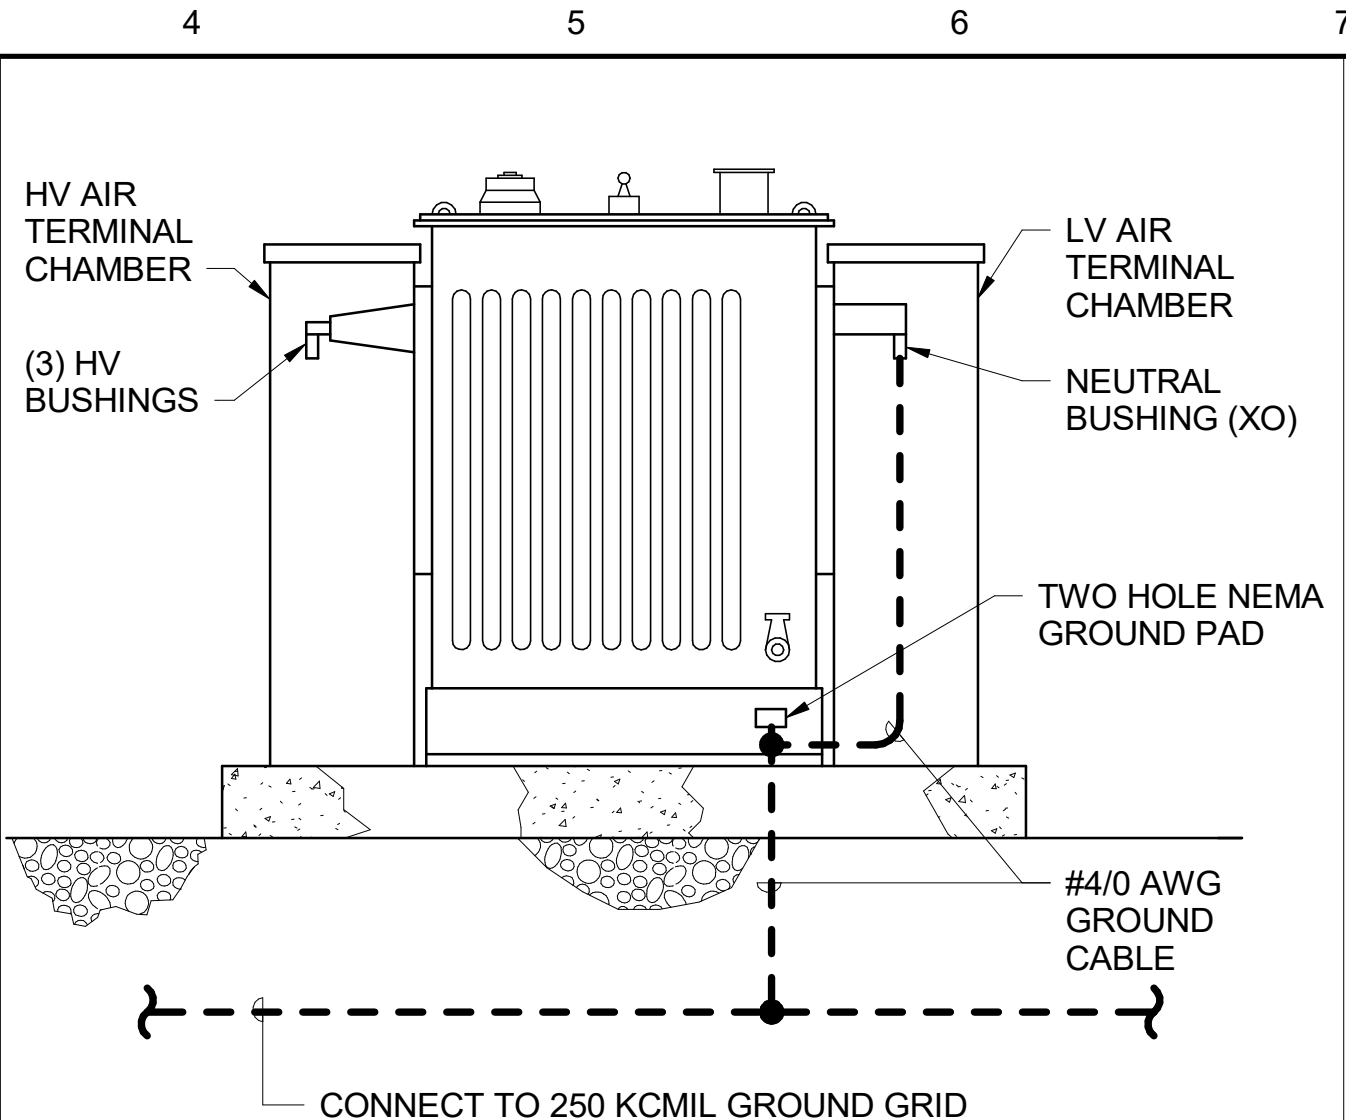


TRANSFORMER GROUNDING (ONE CONNECTION)
NOT TO SCALE

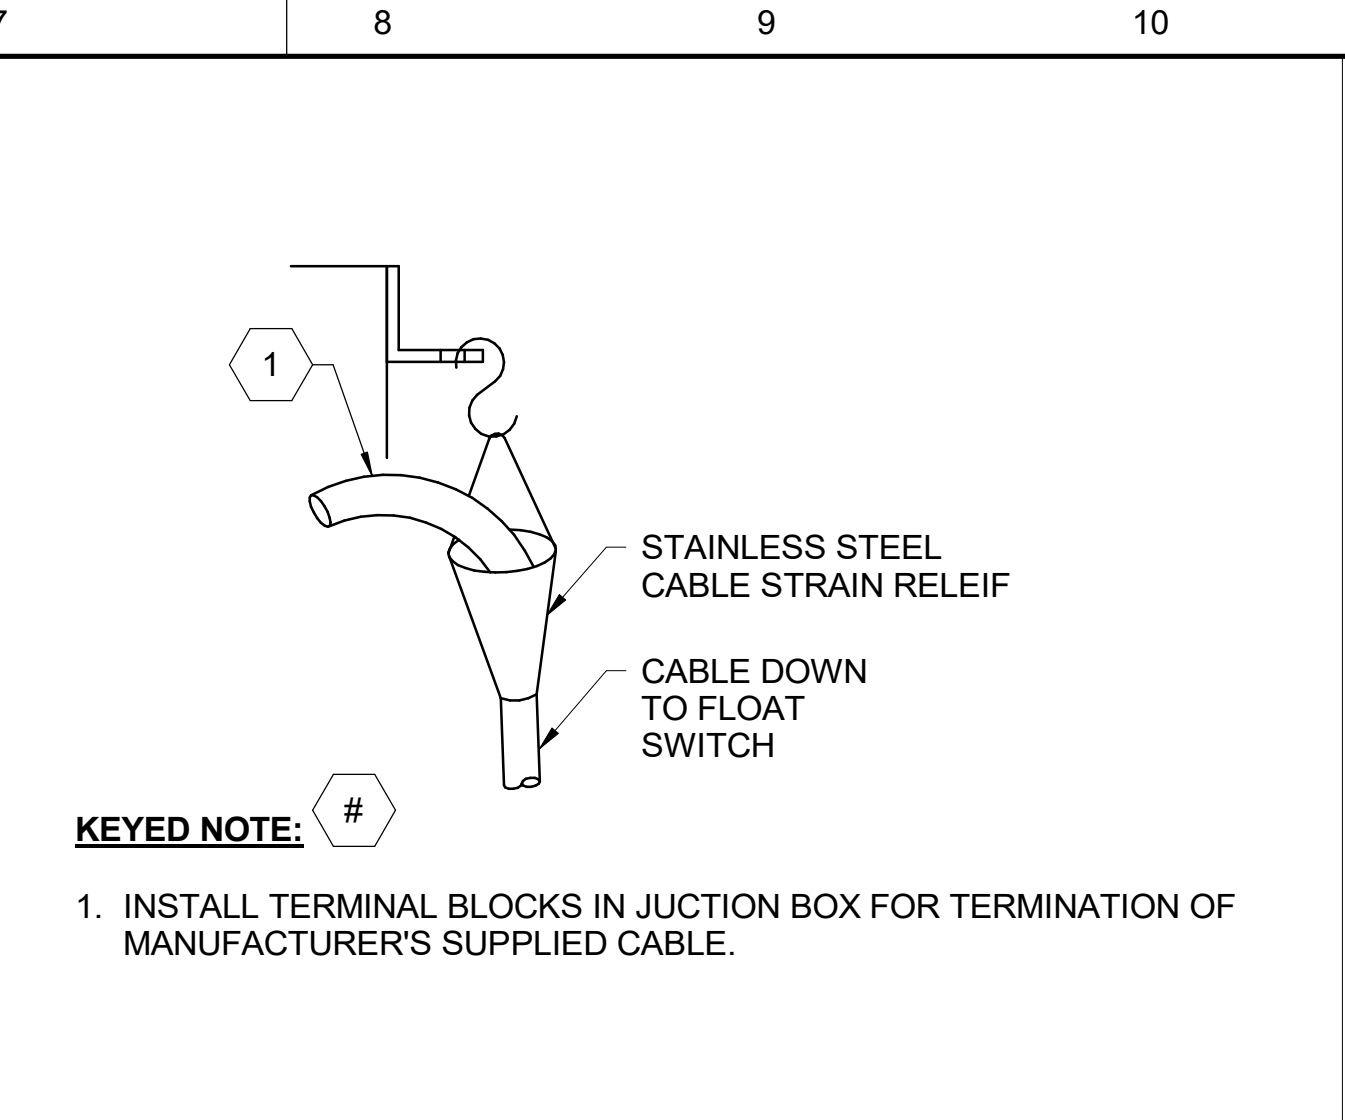


CABLE STRAIN RELEIF
NOT TO SCALE

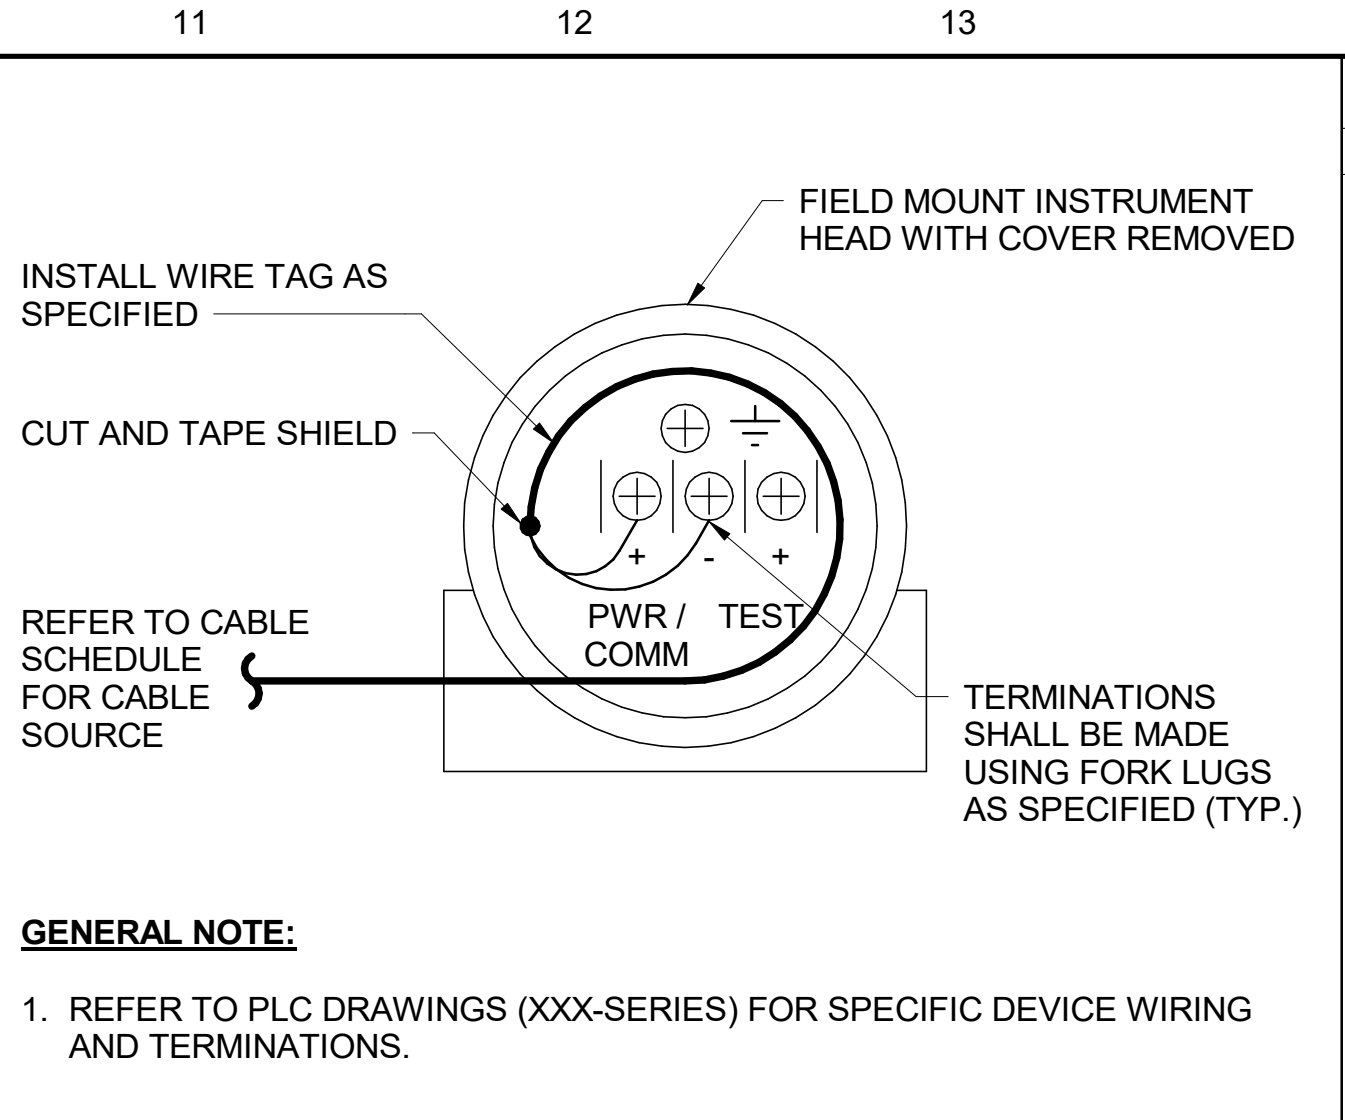

INSTRUMENT WIRING
NOT TO SCALE

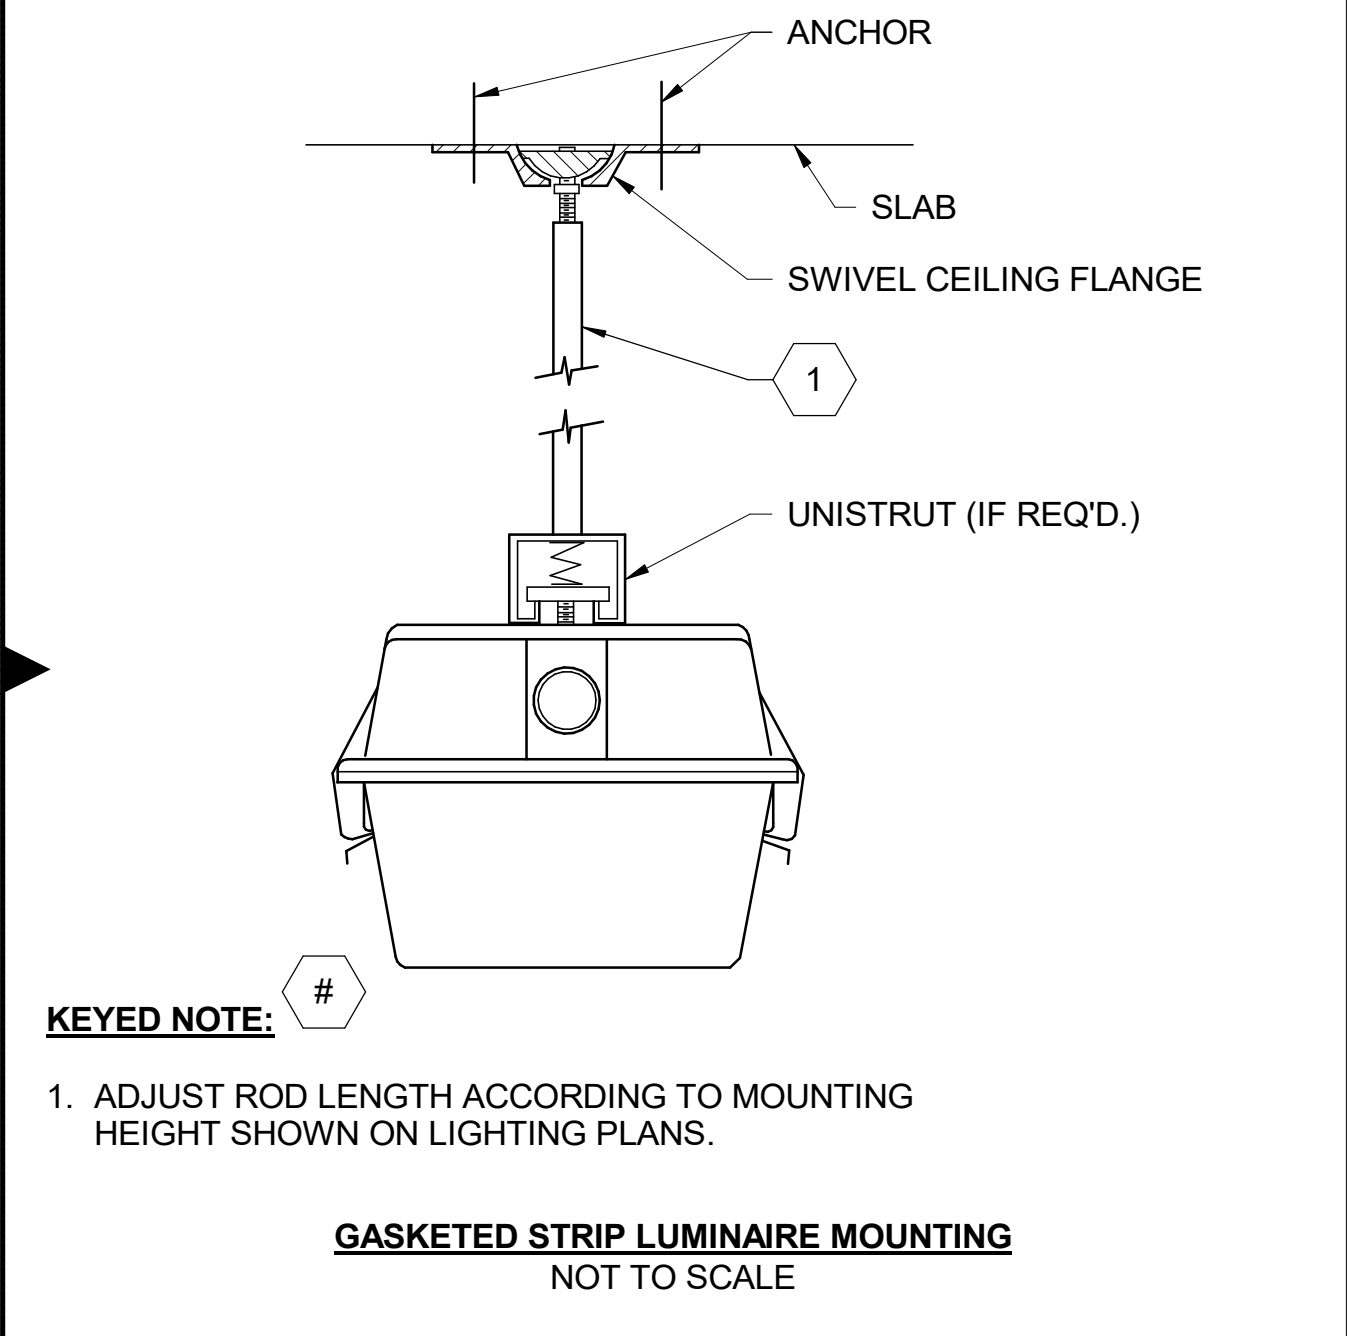

GASKETED STRIP LUMINAIRE MOUNTING
NOT TO SCALE

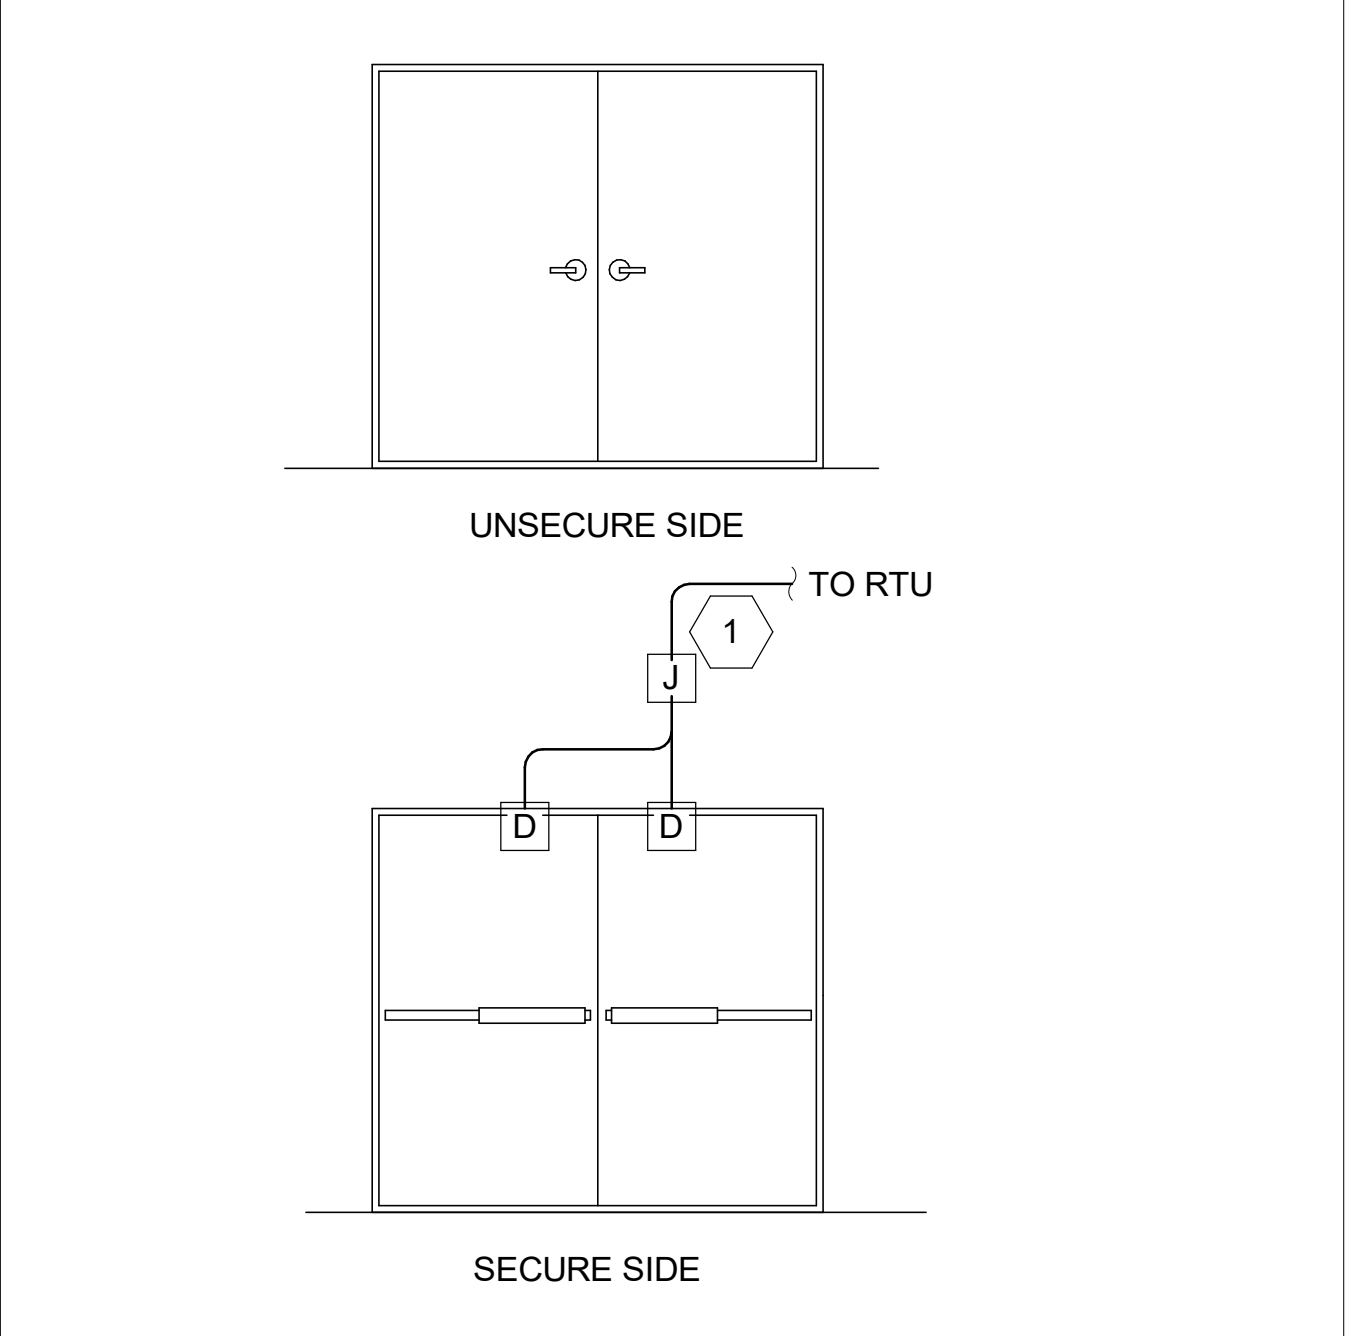


GENERAL NOTES:

1. ALL CONDUIT SHALL BE INSTALLED WITHIN WALL IF DEVICES ARE LOCATED IN A FINISHED AREA.
2. ALL CONDUIT SHALL BE 3/4-INCH UNLESS NOTED OTHERWISE.

KEYED NOTES:

1. JUNCTION BOX SHALL BE INSTALLED A MINIMUM OF 12-INCHES ABOVE CEILING.

DOUBLE DOOR, EXIT ONLY, CRASH BAR
NOT TO SCALE

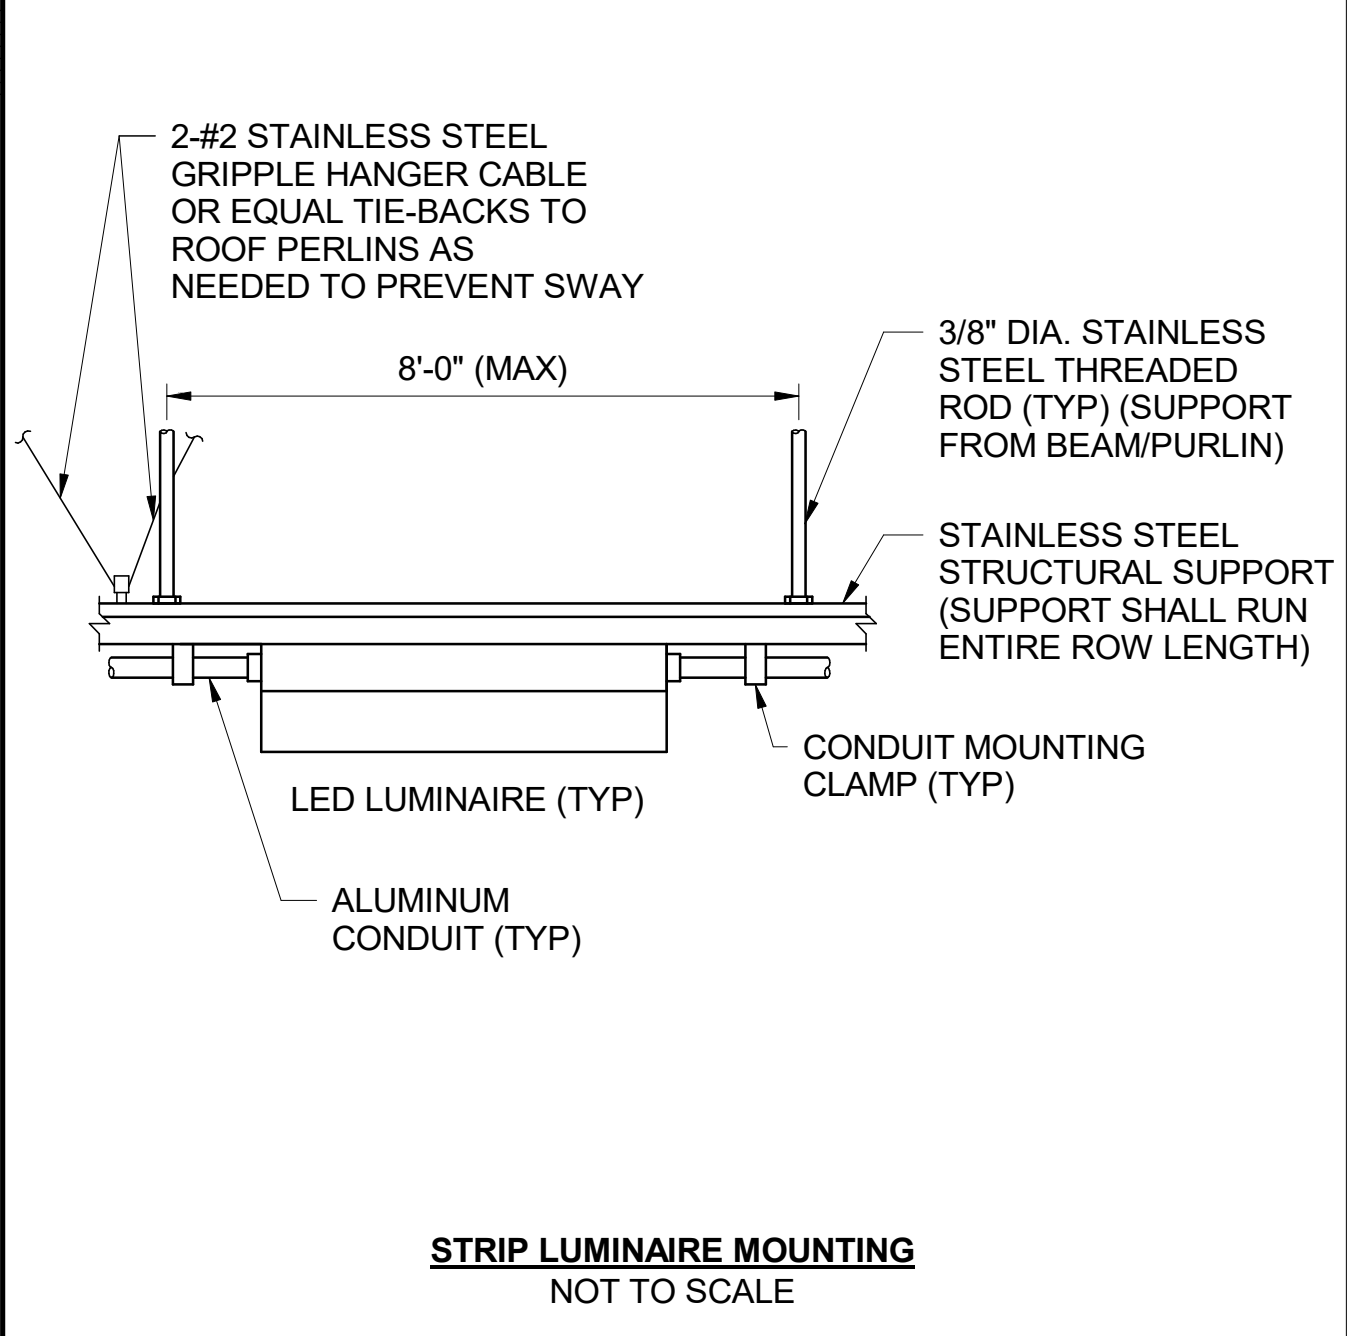


STRIP LUMINAIRE MOUNTING
NOT TO SCALE

no.	date	by	ckd	description
0	02/12/26	AMM	MAH	ISSUED FOR BID

Issue date FEBUARY 2026	detailed by A.BENSON
designed by A. MORRONI	checked by M. HOPKINS

CROSSROADS PUMP STATION ELECTRICAL DETAILS III	
project 124784	contract
drawing 00E-302	rev. 0
sheet 59	of 99 sheets

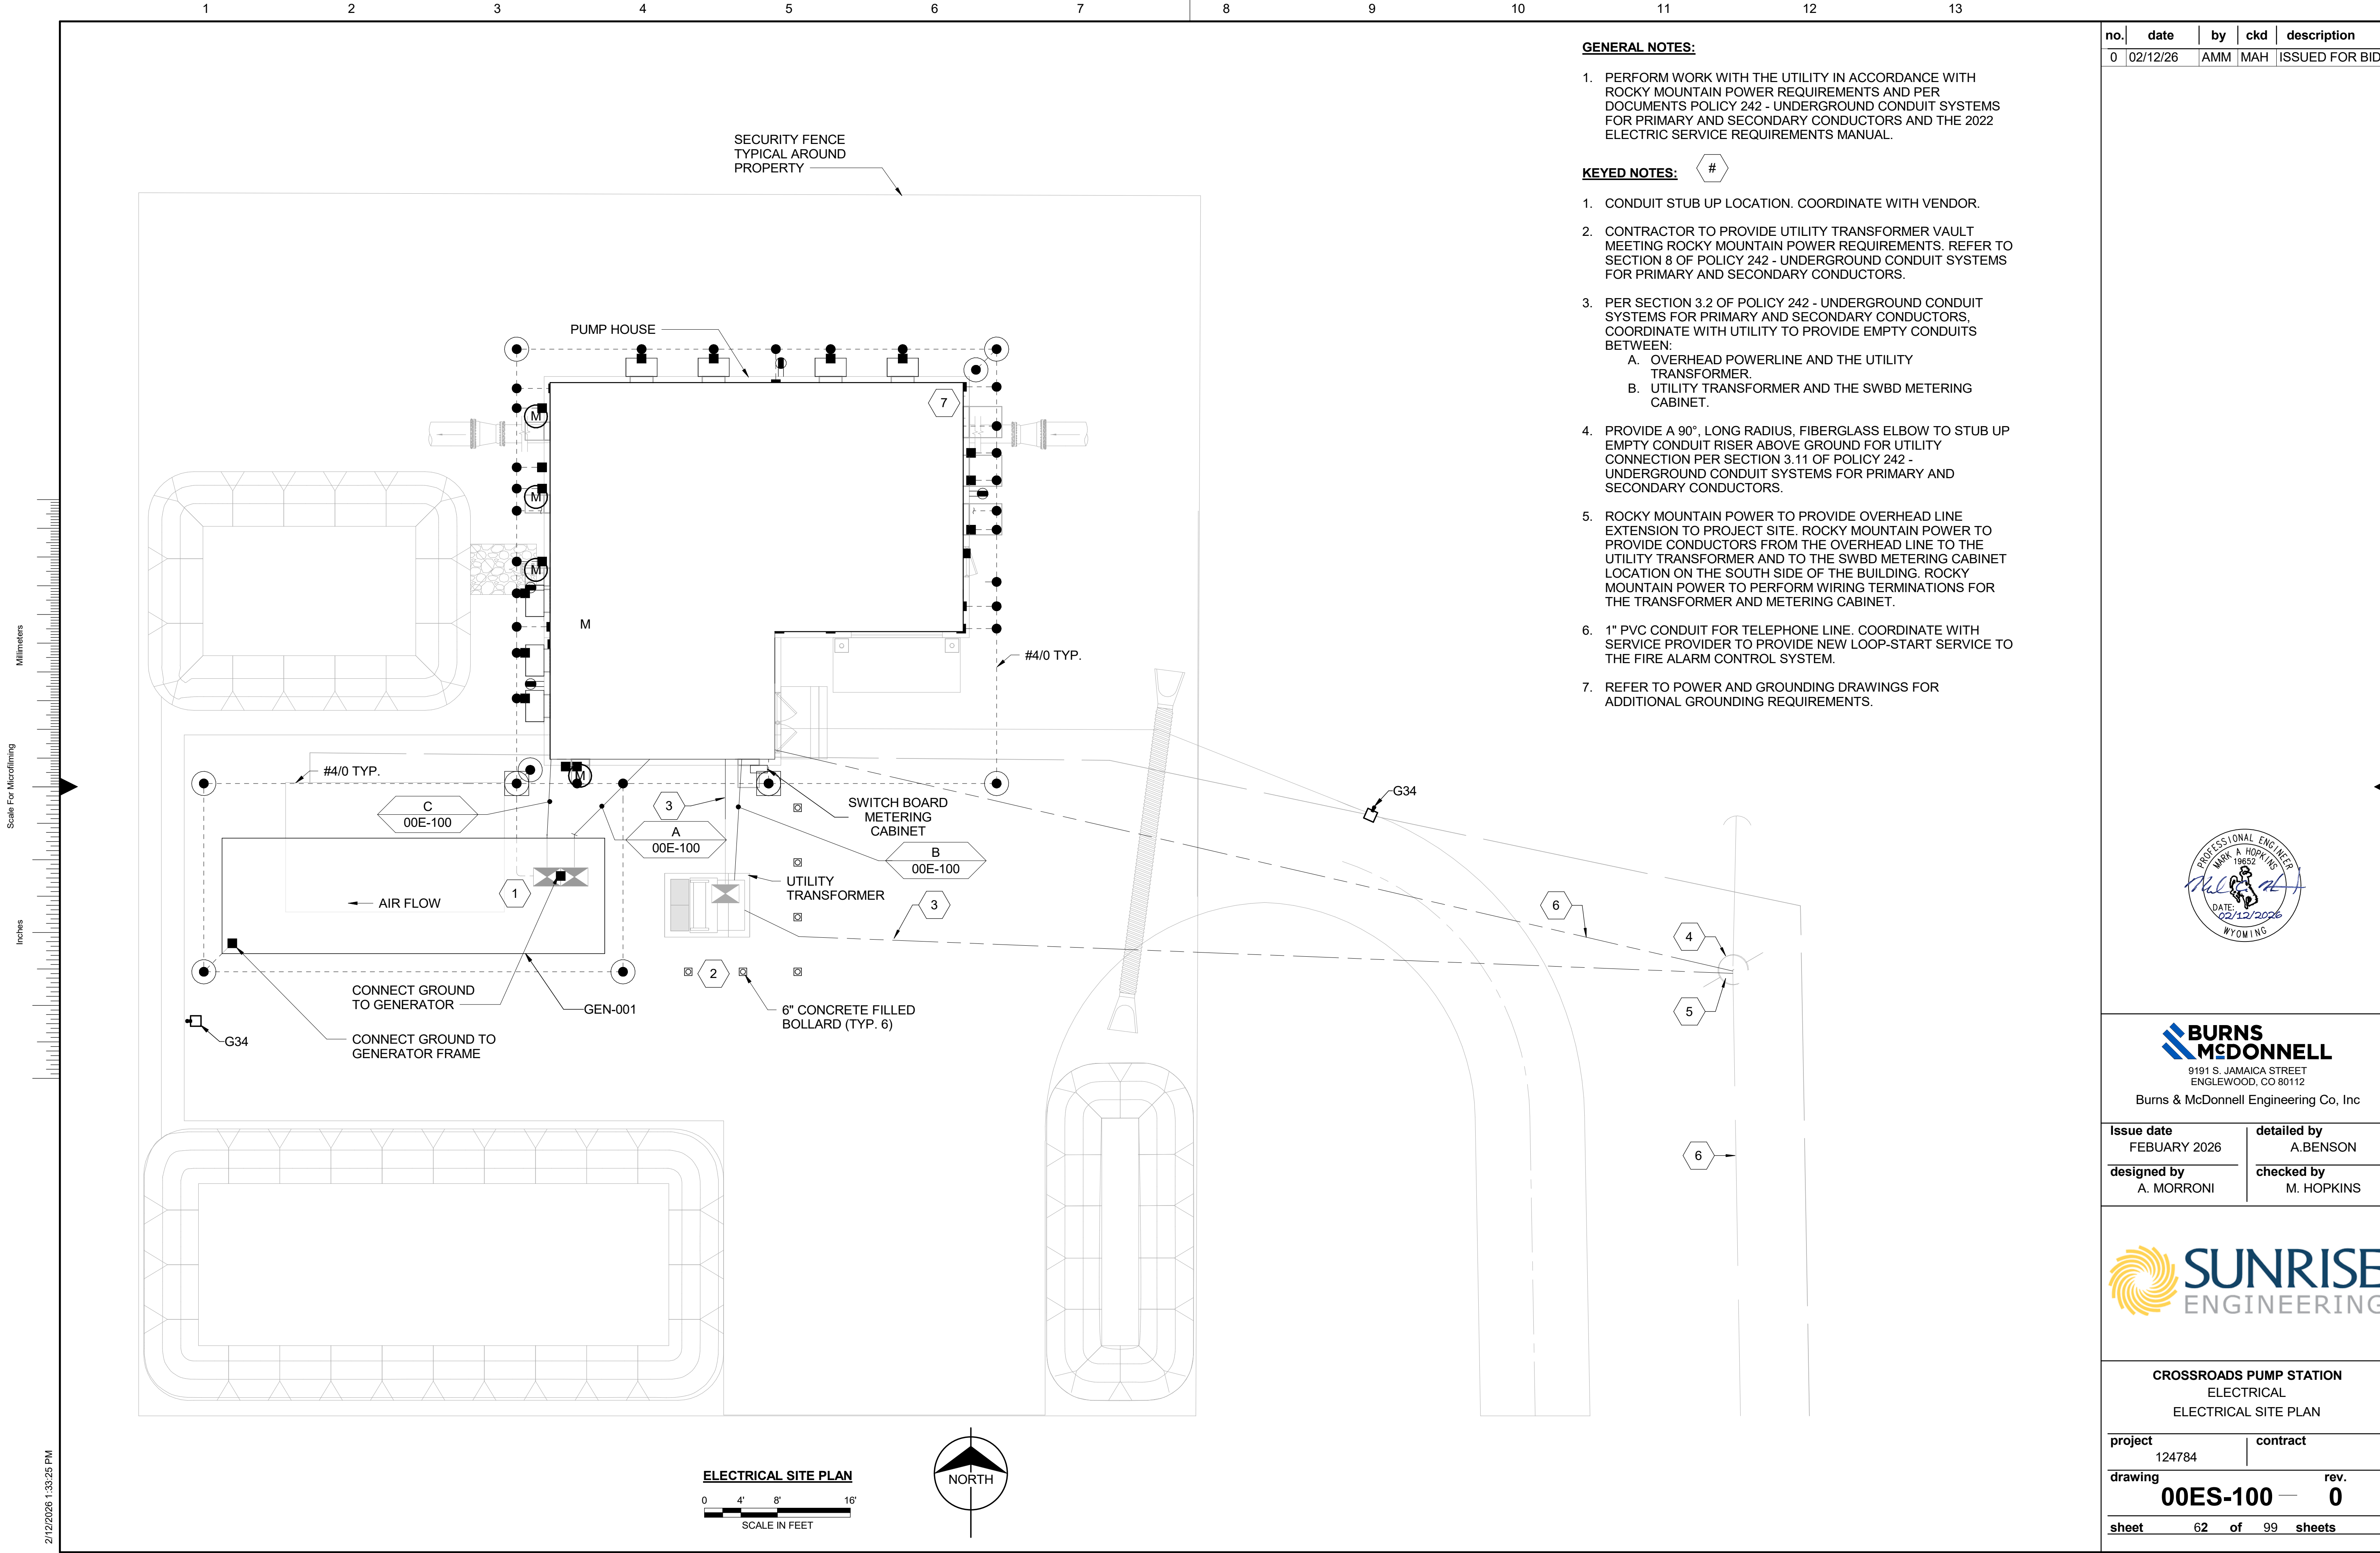

GENERAL NOTES:

- PERFORM WORK WITH THE UTILITY IN ACCORDANCE WITH ROCKY MOUNTAIN POWER REQUIREMENTS AND PER DOCUMENTS POLICY 242 - UNDERGROUND CONDUIT SYSTEMS FOR PRIMARY AND SECONDARY CONDUCTORS AND THE 2022 ELECTRIC SERVICE REQUIREMENTS MANUAL.
- CONDUIT STUB UP LOCATION. COORDINATE WITH VENDOR.
- CONTRACTOR TO PROVIDE UTILITY TRANSFORMER VAULT MEETING ROCKY MOUNTAIN POWER REQUIREMENTS. REFER TO SECTION 8 OF POLICY 242 - UNDERGROUND CONDUIT SYSTEMS FOR PRIMARY AND SECONDARY CONDUCTORS.
- PER SECTION 3.2 OF POLICY 242 - UNDERGROUND CONDUIT SYSTEMS FOR PRIMARY AND SECONDARY CONDUCTORS. COORDINATE WITH UTILITY TO PROVIDE EMPTY CONDUITS BETWEEN:
 - OVERHEAD POWERLINE AND THE UTILITY TRANSFORMER.
 - UTILITY TRANSFORMER AND THE SWBD METERING CABINET.
- PROVIDE A 90°, LONG RADIUS, FIBERGLASS ELBOW TO STUB UP EMPTY CONDUIT RISER ABOVE GROUND FOR UTILITY CONNECTION PER SECTION 3.11 OF POLICY 242 - UNDERGROUND CONDUIT SYSTEMS FOR PRIMARY AND SECONDARY CONDUCTORS.
- ROCKY MOUNTAIN POWER TO PROVIDE OVERHEAD LINE EXTENSION TO PROJECT SITE. ROCKY MOUNTAIN POWER TO PROVIDE CONDUCTORS FROM THE OVERHEAD LINE TO THE UTILITY TRANSFORMER AND TO THE SWBD METERING CABINET LOCATION ON THE SOUTH SIDE OF THE BUILDING. ROCKY MOUNTAIN POWER TO PERFORM WIRING TERMINATIONS FOR THE TRANSFORMER AND METERING CABINET.
- 1" PVC CONDUIT FOR TELEPHONE LINE. COORDINATE WITH SERVICE PROVIDER TO PROVIDE NEW LOOP-START SERVICE TO THE FIRE ALARM CONTROL SYSTEM.
- REFER TO POWER AND GROUNDING DRAWINGS FOR ADDITIONAL GROUNDING REQUIREMENTS.

KEYED NOTES:

#

no.	date	by	ckd	description
0	02/12/26	AMM	MAH	ISSUED FOR BID

PROFESSIONAL ENGINEER
MARK A. HOPKINS
1982
DATE: 02/12/2026
WYOMING


**BURNS
MCDONNELL**
9191 S. JAMAICA STREET
ENGLEWOOD, CO 80112
Burns & McDonnell Engineering Co, Inc

Issue date FEBUARY 2026	detailed by A.BENSON
designed by A. MORRONI	checked by M. HOPKINS

**SUNRISE
ENGINEERING**

CROSSROADS PUMP STATION ELECTRICAL ELECTRICAL SITE PLAN	
project 124784	contract
drawing 00ES-100	rev. 0
sheet 62	of 99 sheets

ELECTRICAL SITE PLAN
0 4' 8' 16'
SCALE IN FEET

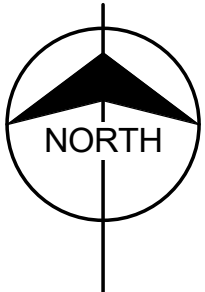


GENERAL NOTES:

- ALL HVAC EQUIPMENT (LOUVERS, EXHAUST FANS, AIR HANDLERS, ETC) ARE SUPPLIED BY OTHERS AND ARE SHOWN FOR REFERENCE. REFER TO HVAC DRAWINGS FOR INFORMATION ON DISCONNECTS.
- REFER TO DWG. 00E-001 FOR GENERAL NOTES, ABBREVIATIONS, AND LEGENDS.
- REFER TO 00E-003 FOR MATERIAL DESIGNATIONS AND CONDUIT DESCRIPTIONS.
- REFER TO 00E-110 FOR ONE-LINE DIAGRAM.
- REFER TO 00E-120 FOR PANELBOARD SCHEDULES.
- UNLESS REQUIRED BE NEC TO PROVIDE LARGER, PROVIDE #2 AWG GROUND CONNECTION TO:
 - HANDRAILS CENTERED EVERY 50'
 - HOISTS, HATCH FRAMES, AND LADDERS
 - EQUIPMENT RACKS
 - ELECTRICAL EQUIPMENT
 - METAL WATER PIPES ENTERING BUILDING.
 - INSTRUMENTS WHERE REQUIRED FOR PROPER OPERATION.
- CONTRACTOR TO RUN ALL REQUIRED HVAC POWER AND CONTROLS CONDUITS. COORDINATE WITH HVAC.

KEYED NOTES:

#

- CONTRACTOR TO PROVIDE LIGHTNING PROTECTION SYSTEM WITH UL MASTER LABEL. PROVIDE LIGHTNING PROTECTION SYSTEM DOWN CONDUCTOR AT EACH BUILDING CORNER AND EVERY 75' AROUND PERIMETER. CONNECT DOWN CONDUCTOR TO DEDICATED GROUND ROD AND BOND TO ELECTRICAL SYSTEM GROUND RING AT EACH BUILDING CORNER.
- BOND GROUND TO WATER PIPE IN PIPE TRENCH AND TO REINFORCING STEEL IN CONCRETE - MINIMUM LENGTH 20'.
- BOND GROUND RING TO REINFORCING STEEL EVERY 50' OF BUILDING PERIMETER.
- PROVIDE RTD MONITOR PANEL MOUNTED ON EQUIPMENT STAND ADJACENT TO MOTOR TERMINAL BOX.
- TIE IN ANTENNAE MAST TO THE LIGHTNING PROTECTION SYSTEM.
- CONTRACTOR TO CONFIRM DISCONNECT SIZE WITH VENDOR.

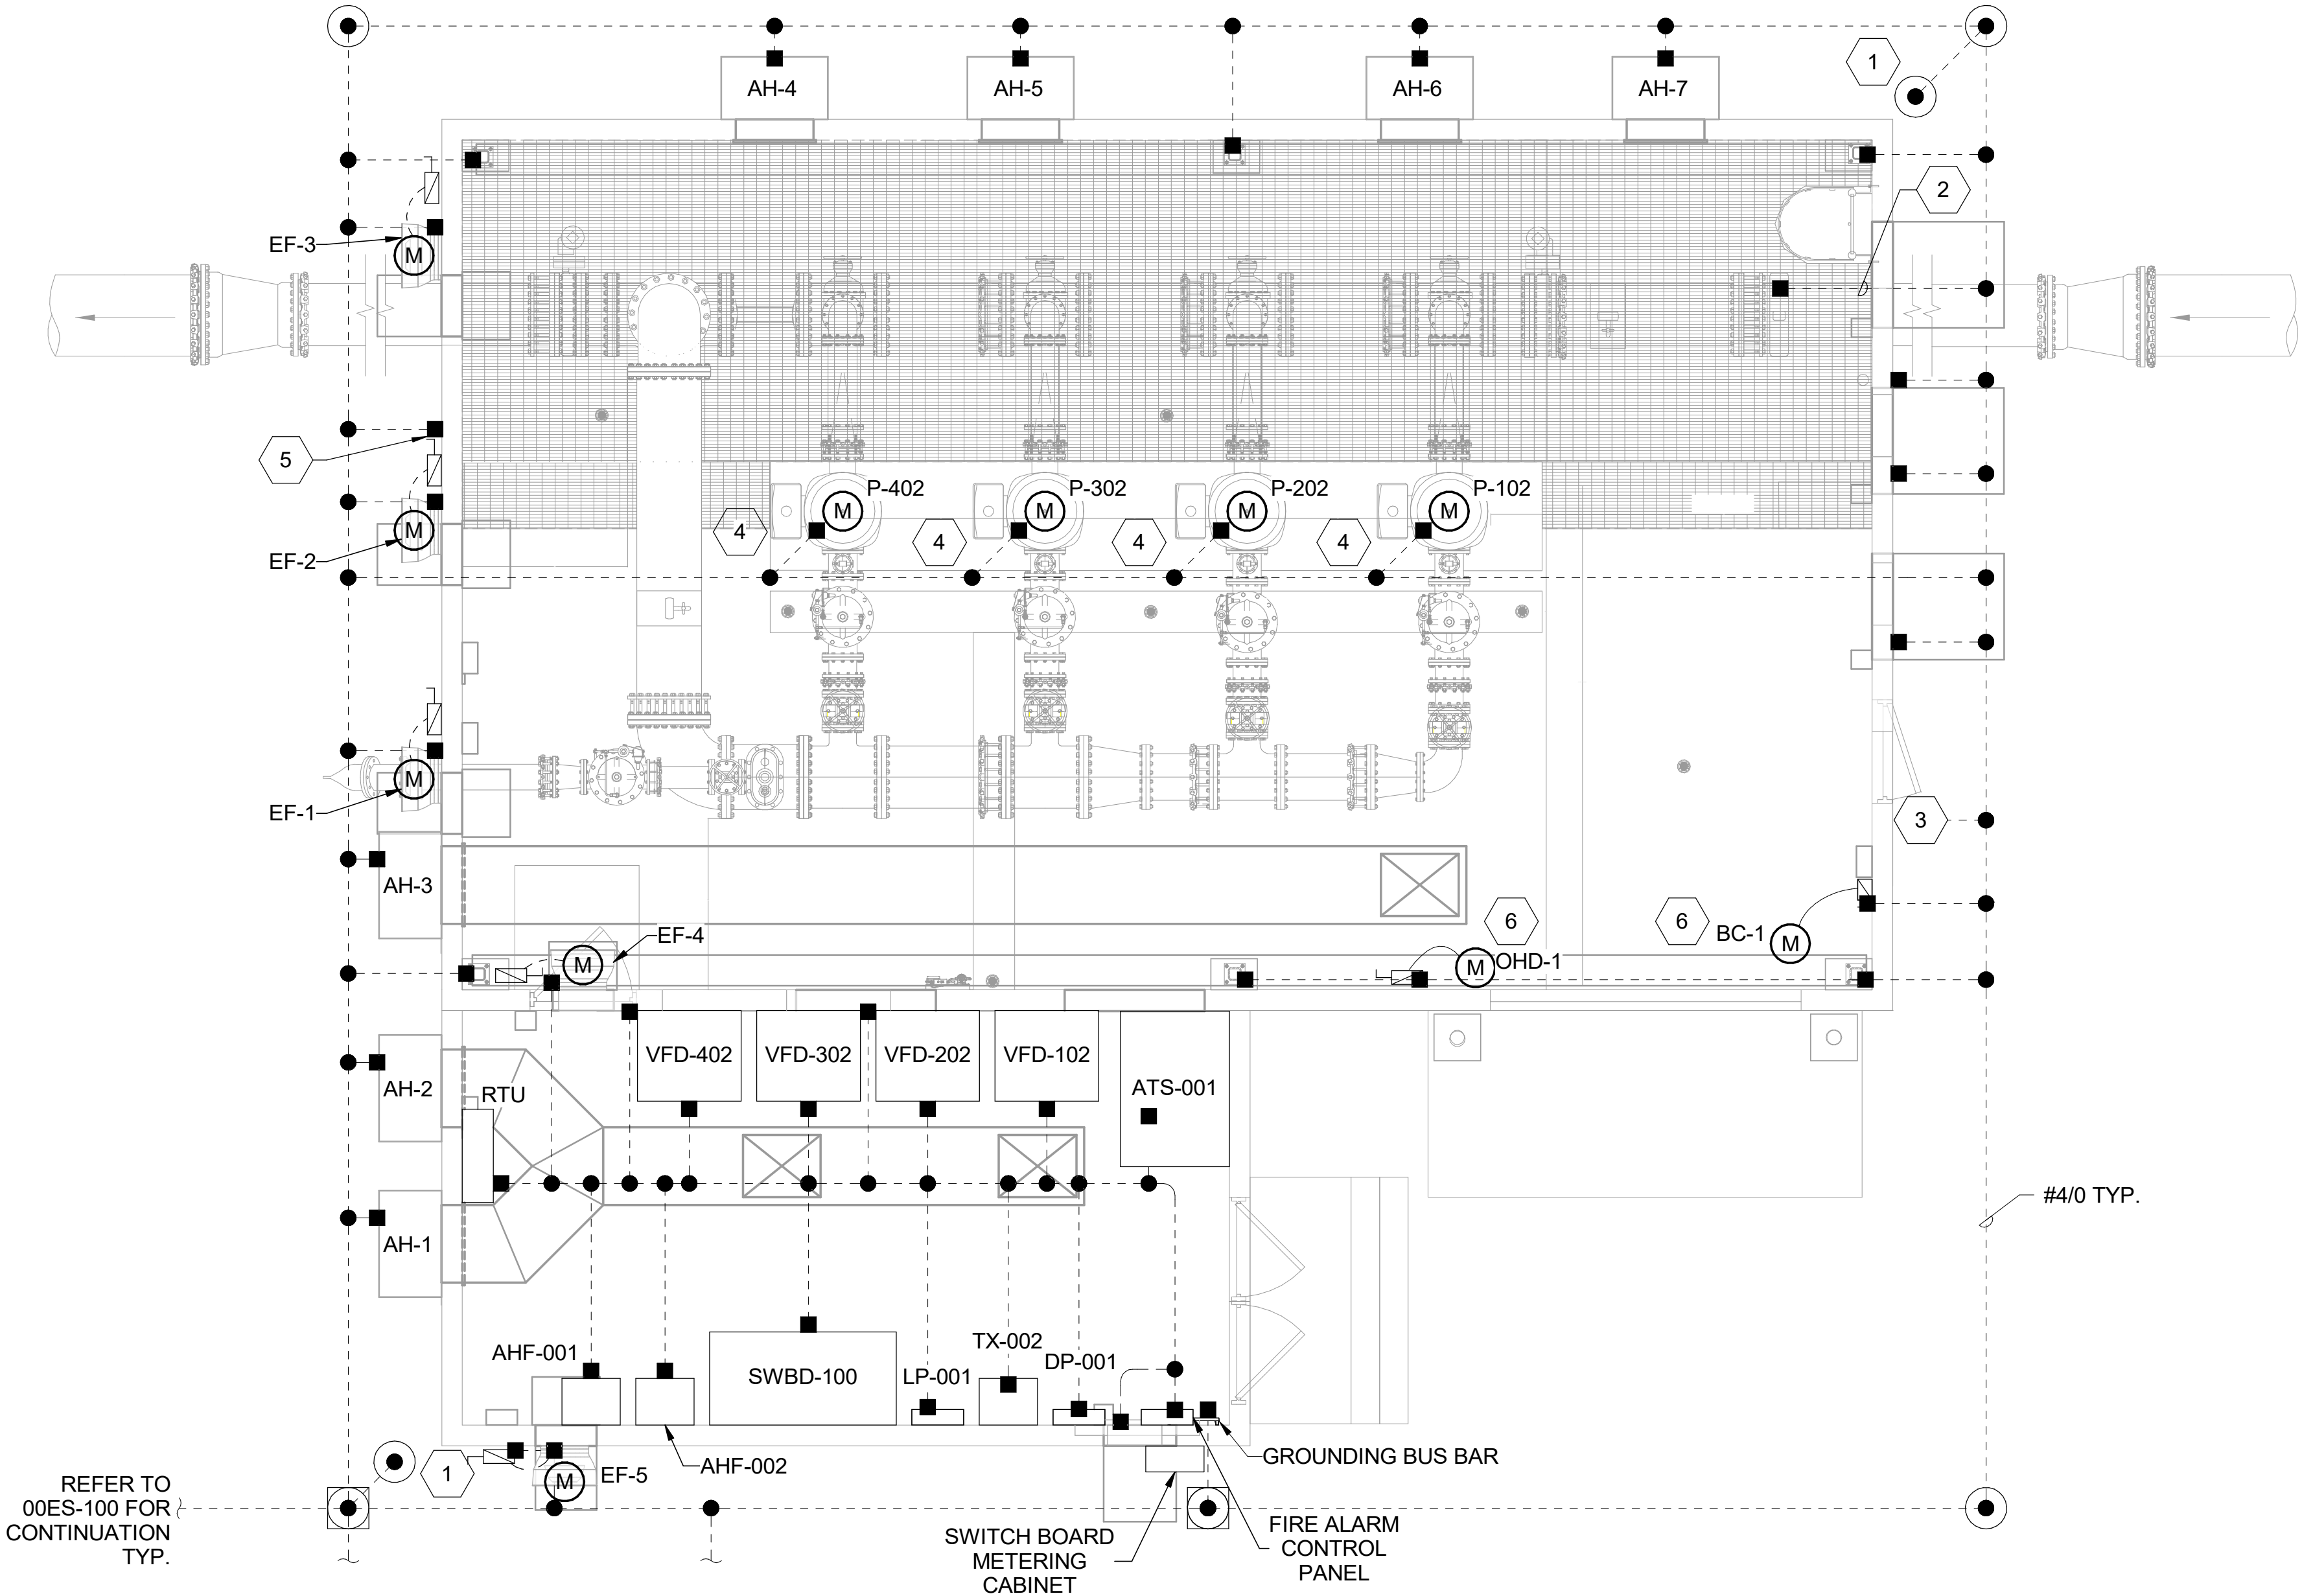

**BURNS
MCDONNELL**

9191 S. JAMAICA STREET
ENGLEWOOD, CO 80112

Burns & McDonnell Engineering Co, Inc

Issue date
FEBUARY 2026

detailed by
A.BENSON

designed by
A. MORRONI

checked by
M. HOPKINS



CROSSROADS PUMP STATION
ELECTRICAL
POWER AND GROUNDING PLAN

project
124784

contract

drawing
01EP-101

rev.

0

sheet 63 of 99 sheets

GENERAL NOTES:


- 1. REFER TO DWG. 00E-001 FOR GENERAL NOTES, ABBREVIATIONS, AND LEGENDS.
- 2. REFER TO 00E-003 FOR MATERIAL DESIGNATIONS AND CONDUIT DESCRIPTIONS.
- 3. REFER TO 00E-010 FOR LUMINAIRE SCHEDULE.
- 4. REFER TO 00E-110 FOR ONE-LINE DIAGRAM.
- 5. REFER TO 00E-120 FOR PANELBOARD SCHEDULES.

KEYED NOTES:

#

- 1. LIGHTS AND RECEPTACLES LOCATED IN PIPE GALLERY ARE TO BE UNDER THE GRATING.
- 2. 48" ABOVE GRATING AT GROUND FLOOR.

no.	date	by	ckd	description
0	02/12/26	AMM	MAH	ISSUED FOR BID

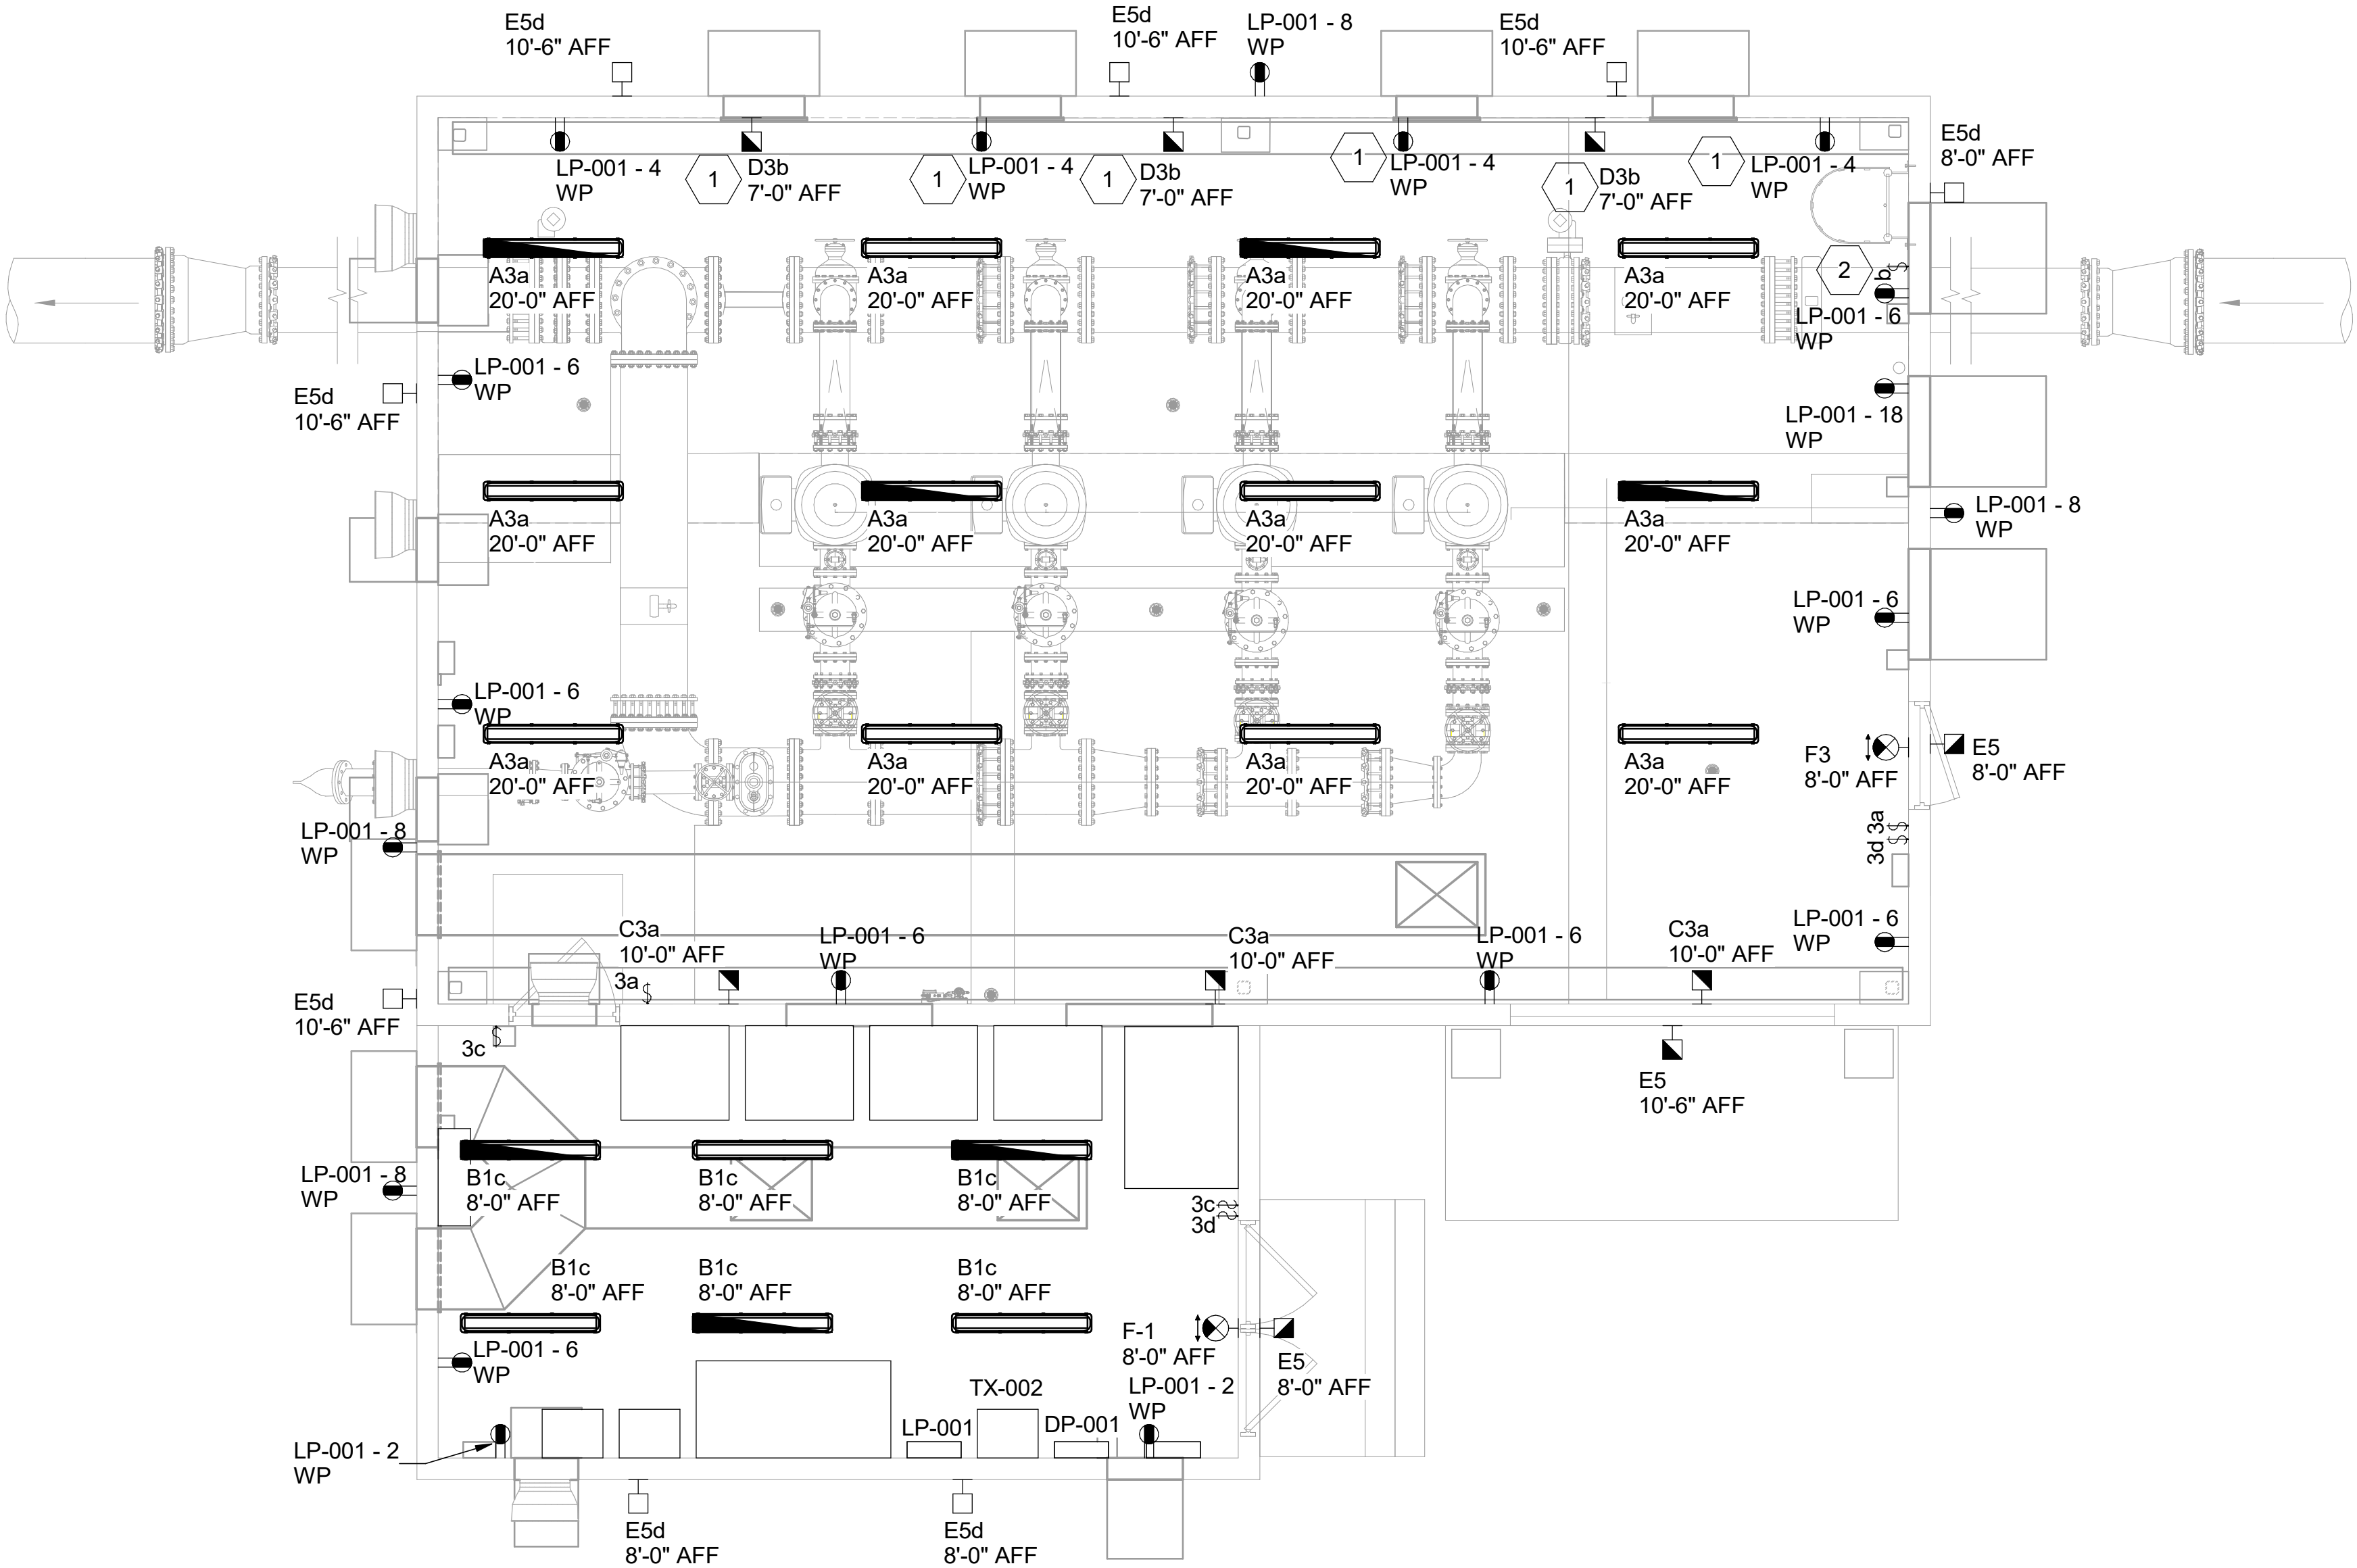

**BURNS
MCDONNELL**

9191 S. JAMAICA STREET
ENGLEWOOD, CO 80112

Burns & McDonnell Engineering Co, Inc

Issue date
FEBUARY 2026

detailed by
A.BENSON

designed by
A. MORRONI

checked by
M. HOPKINS



CROSSROADS PUMP STATION
ELECTRICAL
LIGHTING AND RECEPTACLES PLAN

project
124784

contract

drawing
01EL-101

rev.
0

sheet 64 of 99 sheets


GENERAL NOTES:

- REFER TO DWG. 00E-001 FOR GENERAL NOTES, ABBREVIATIONS, AND LEGENDS.
- REFER TO 00E-003 FOR MATERIAL DESIGNATIONS AND CONDUIT DESCRIPTIONS.
- REFER TO 00E-110 FOR ONE-LINE DIAGRAM.
- REFER TO 00E-120 FOR PANELBOARD SCHEDULES.
- REFER TO 28 31 00. CONTRACTOR TO PROVIDE COMPLETE FIRE ALARM SYSTEM.

KEYED NOTES:

#


- REFER TO P&IDS AND INSTRUMENT LIST FOR REQUIRED MOTOR PROTECTION, RTDS, AND VIBRATION MONITORING.
- COORDINATE WITH HVAC DRAWINGS FOR HVAC CONTROLS.
- INSTALL RADIO ANTENNA PER DETAIL FOUND ON 00E-303.
- PROVIDE RTD MONITOR PANEL MOUNTED ON EQUIPMENT STAND ADJACENT TO MOTOR TERMINAL BOX.

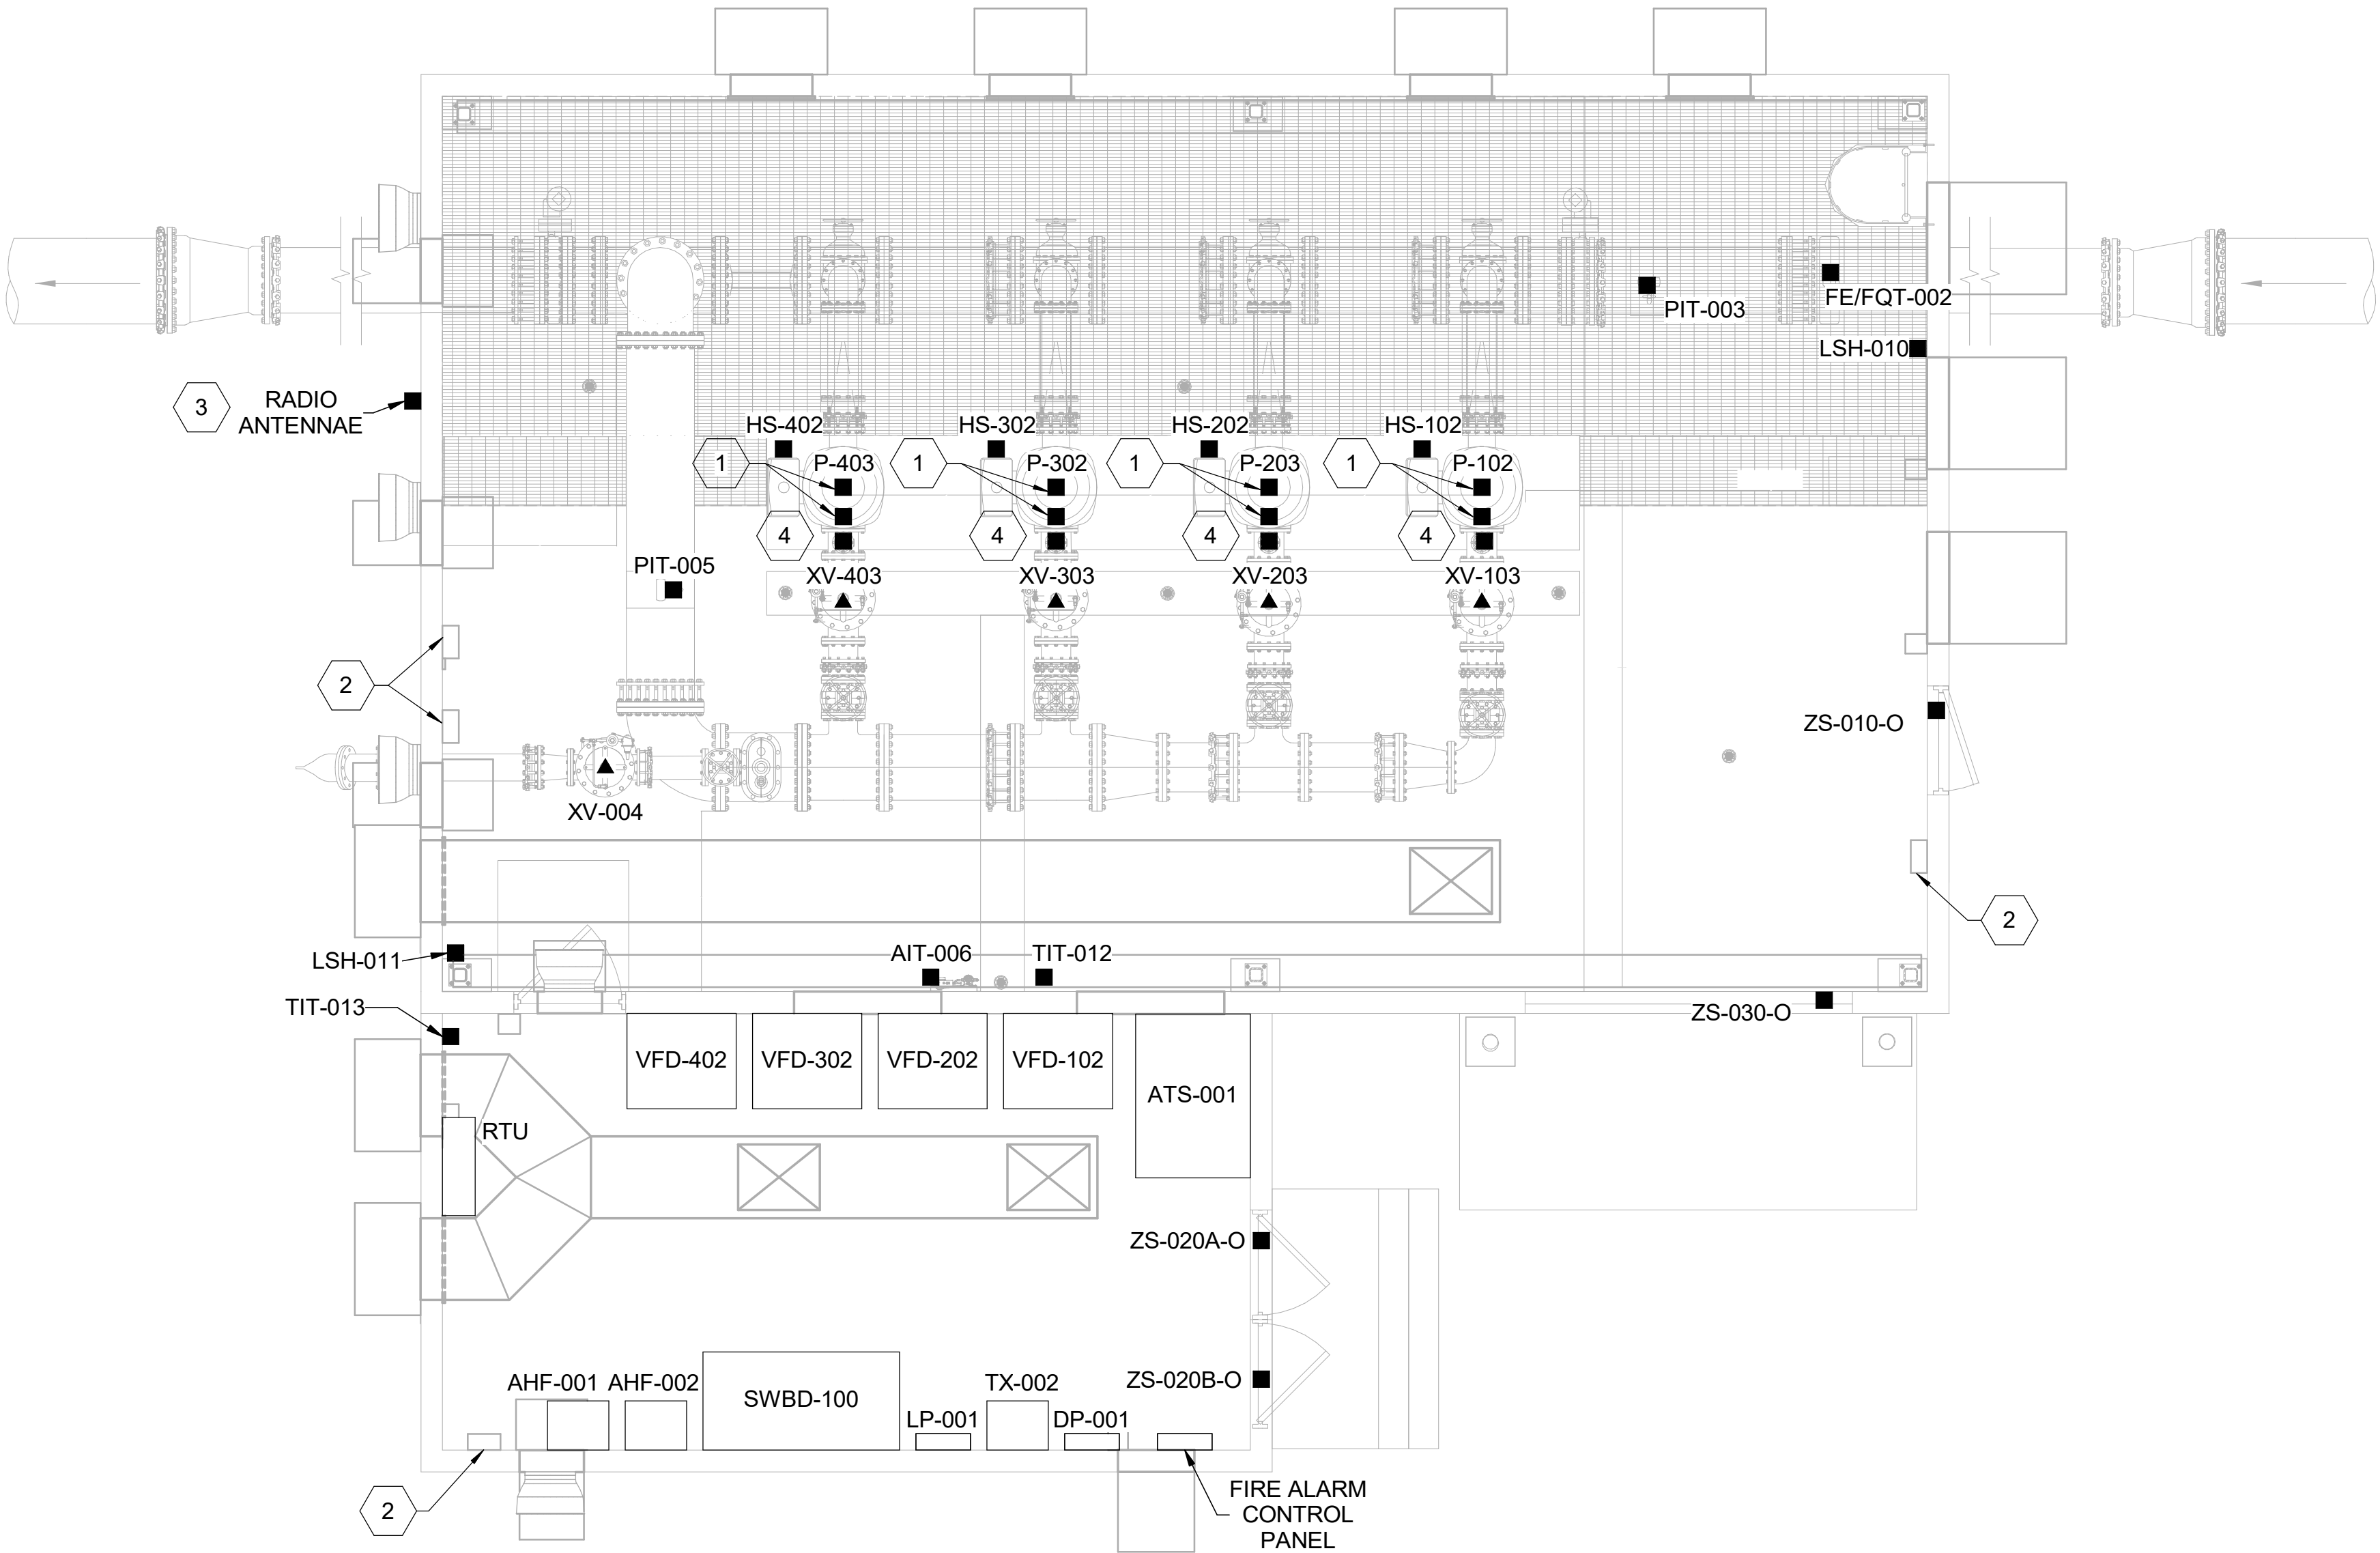

INSTRUMENTATION AND
CONTROLS PLAN

0 2' 4' 8'

SCALE IN FEET

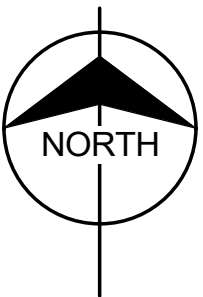

9191 S. JAMAICA STREET
ENGLEWOOD, CO 80112

Burns & McDonnell Engineering Co, Inc

Issue date
FEBUARY 2026

detailed by
A.BENSON

designed by
A. MORRONI

checked by
M. HOPKINS



CROSSROADS PUMP STATION
ELECTRICAL
INSTRUMENTATION AND CONTROLS PLAN

project
124784

contract

drawing
01EI-101

rev.
0

sheet 65 of 99 sheets

12/2/2025 3:46:00 PM

A__	-	ANALYZER
E__	-	VOLTAGE
F__	-	FLOW
H__	-	MANUAL PUSH BUTTON OR SWITCH
I__	-	CURRENT
J__	-	POWER (DIGITAL COMMAND OR OUTPUT)
L__	-	LEVEL
M__	-	MOISTURE
P__	-	PRESSURE
S__	-	SPEED
T__	-	TEMP
V__	-	VIBRATION
W__	-	TORQUE OR WEIGHT
X__	-	MISCELLANEOUS OR COMMON
Y__	-	EVENT
Z__	-	POSITION
A	-	ALARM
B	-	BUTTON
C	-	CONTROL (ANALOG DEMAND)
D	-	DIFFERENTIAL
E	-	PROBE OR DIRECT MEASUREMENT ELEMENT
G	-	GAUGE/GLASS
I	-	INDICATOR
Q	-	TOTALIZER
S	-	SWITCH OR SETPOINT
T	-	TRANSMITTER (ANALOG FEEDBACK)
Y	-	RELAY (IF DIGITAL) OR CALCULATION (IF ANALOG)
J	-	INDICATION (ANALOG FEEDBACK)
T	-	TRANSMITTER (ANALOG FEEDBACK)

<u>INPUT</u>	<u>OUTPUT</u>
1	1
2	4
3	9
4	16
5	25
6	36
7	49
8	64
9	81
10	100

KEY NOTES:

1. AN "A" IN THE TAG IDENTIFIER MEANS THE POINT IS PROGRAMMED AS AN ALARM, DISPLAYING ON THE GRAPHICS AND ON THE SYSTEM ALARM SCREENS. ALARM STATE SHALL BE AS DEFINED IN THE I/O LIST.

 SOFTWARE, DATA LINK, OR BUS
 MANUFACTURER'S CABLE
 PNEUMATIC TUBING


sheets

12/2/2025 3:46:00 PM

Scale For Microfilming

Inches

Millimeters

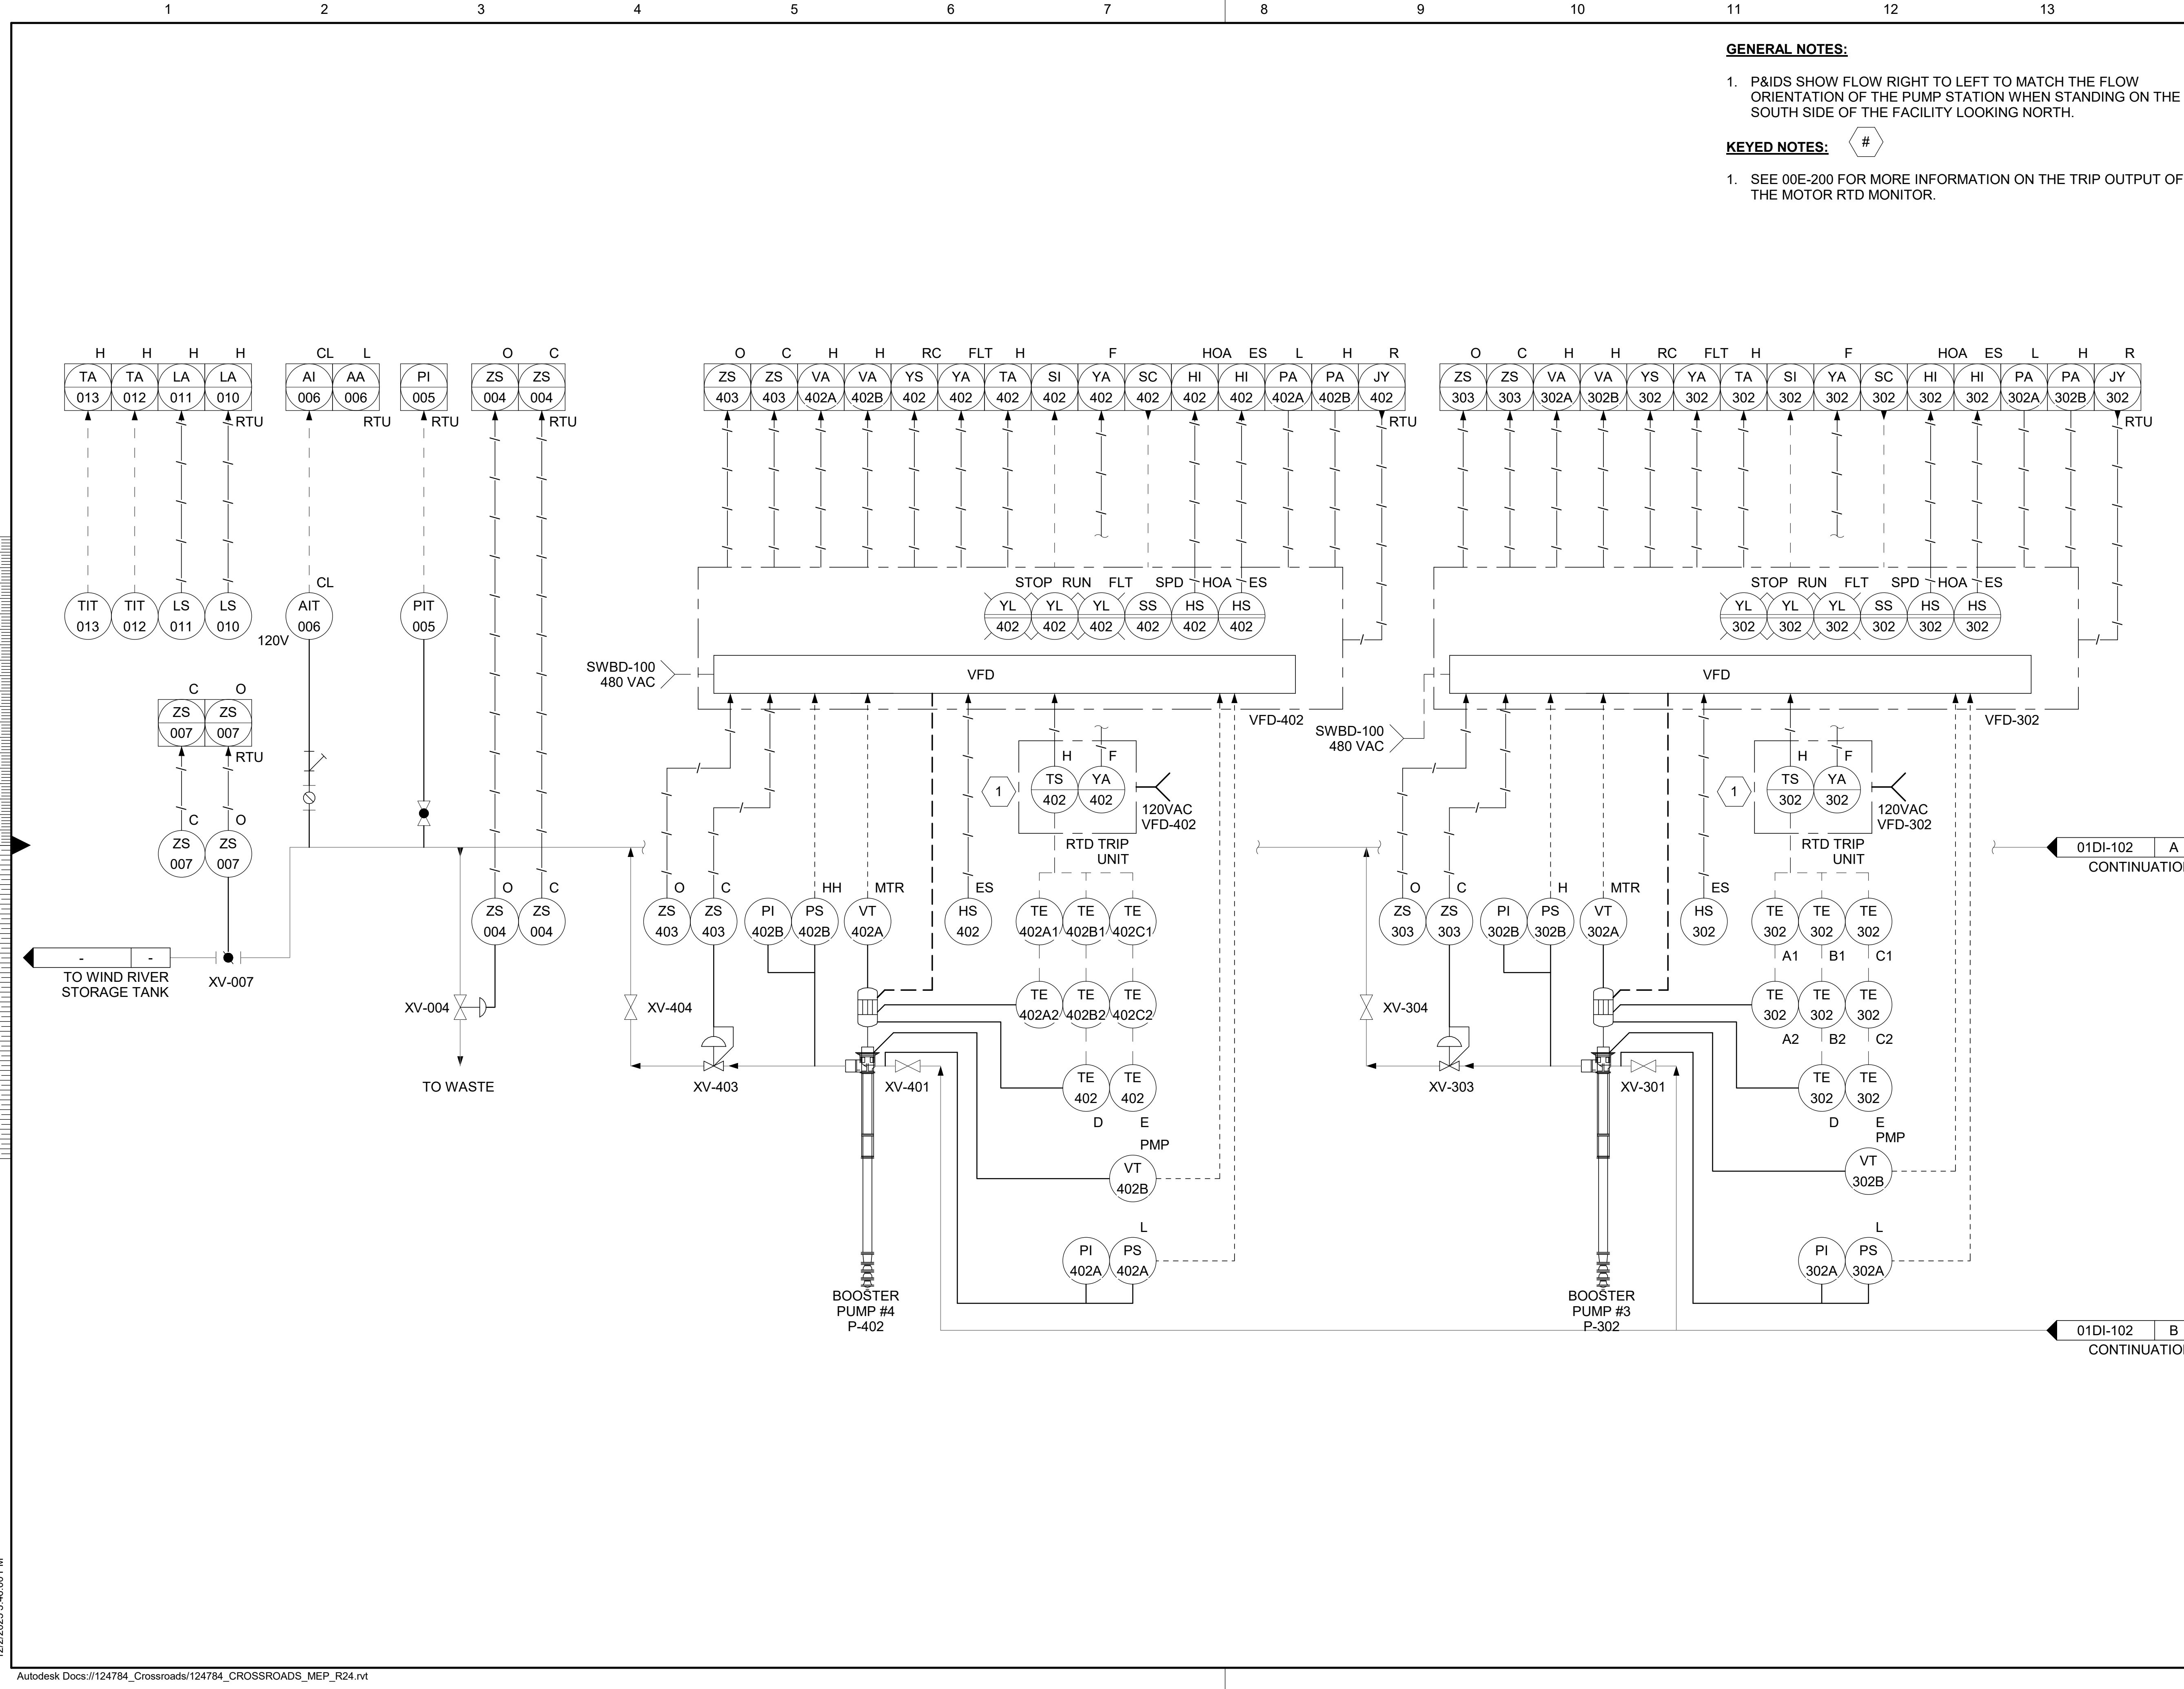

GENERAL NOTES:

- P&IDS SHOW FLOW RIGHT TO LEFT TO MATCH THE FLOW ORIENTATION OF THE PUMP STATION WHEN STANDING ON THE SOUTH SIDE OF THE FACILITY LOOKING NORTH.

KEYED NOTES:

#

- SEE 00E-200 FOR MORE INFORMATION ON THE TRIP OUTPUT OF THE MOTOR RTD MONITOR.

no.	date	by	ckd	description
0	09/30/25	AMM	MAH	ISSUED FOR PERMIT

Issue date SEPTEMBER 2025	detailed by A.BENSON
designed by A. MORRONI	checked by M. HOPKINS

CROSSROADS PUMP STATION ELECTRICAL BOOSTER PUMP P&ID I	
project 124784	contract
drawing 01DI-101	rev. 0
sheet 68	of 99
of 99	sheets

01DI-102 A
CONTINUATION


01DI-102 B
CONTINUATION

12/2/2025 3:46:00 PM

Scale For Microfilming

Inches

Millimeters

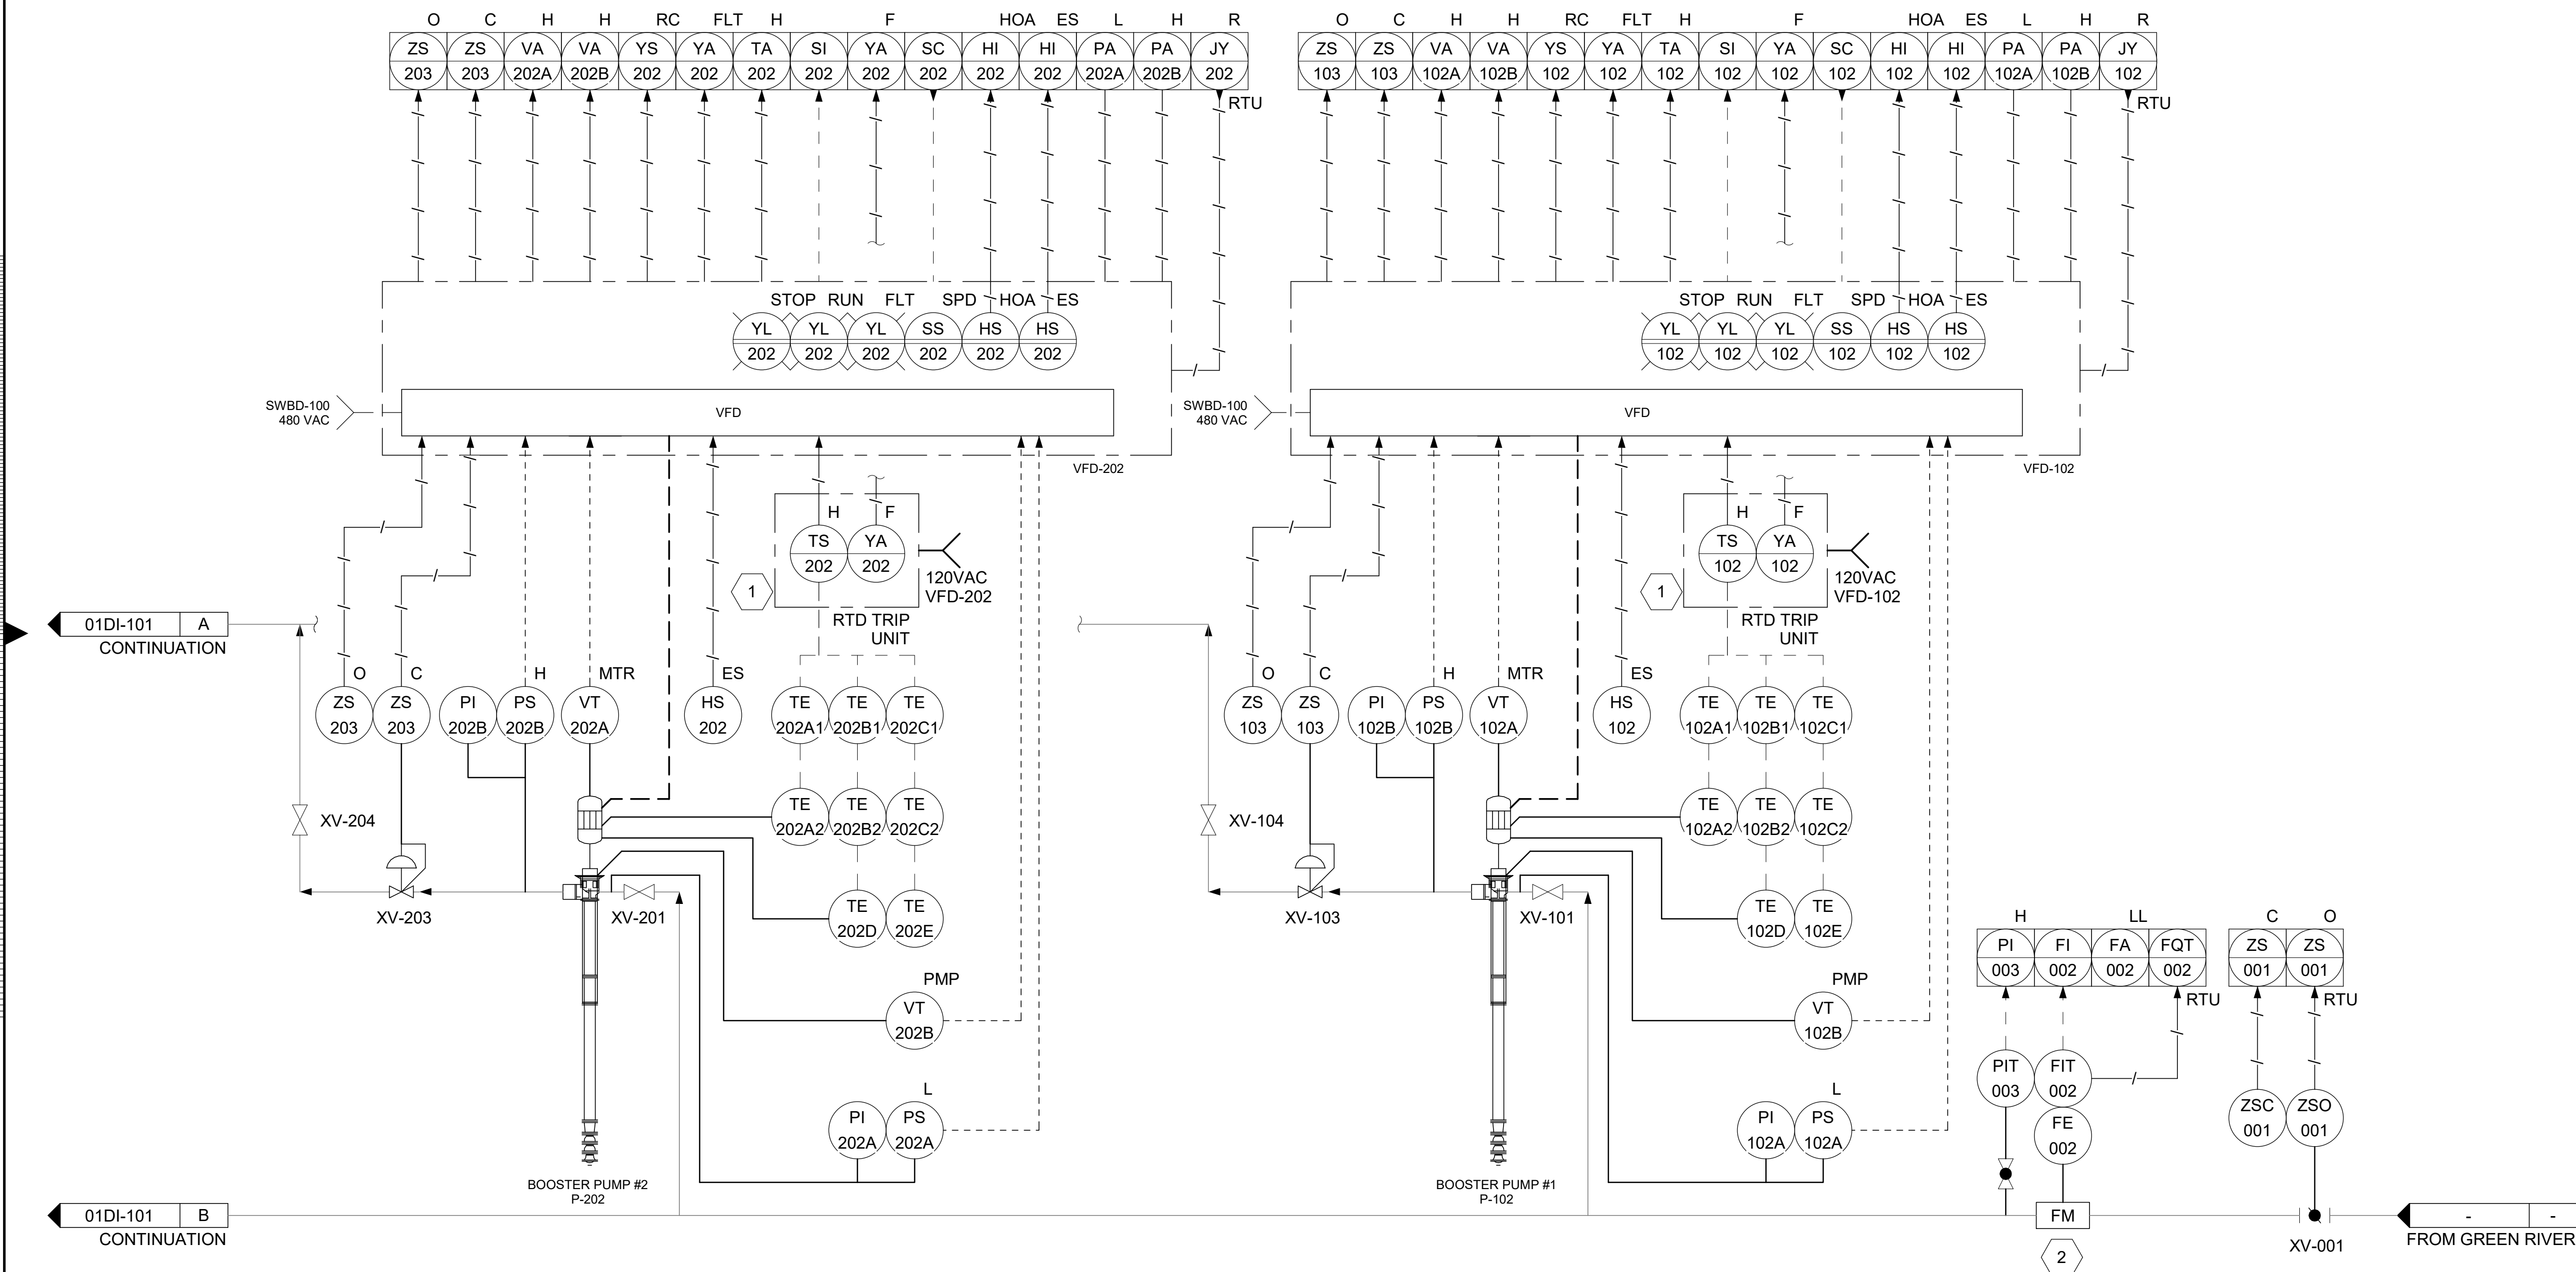

GENERAL NOTES:

1. P&IDS SHOW FLOW RIGHT TO LEFT TO MATCH THE FLOW ORIENTATION OF THE PUMP STATION WHEN STANDING ON THE SOUTH SIDE OF THE FACILITY LOOKING NORTH.

KEYED NOTES:




1. SEE 00E-200 FOR MORE INFORMATION ON THE TRIP OUTPUT OF THE MOTOR RTD MONITOR.
2. INSERTION TYPE FLOW METER. REFER TO SPECIFICATION SECTION 40 70 00.

no.	date	by	ckd	description
0	09/30/25	AMM	MAH	ISSUED FOR PERMIT

Issue date SEPTEMBER 2025	detailed by A. BENSON
designed by A. MORRONI	checked by M. HOPKINS

CROSSROADS PUMP STATION ELECTRICAL BOOSTER PUMP P&ID II	
project 124784	contract
drawing 01DI-102	rev. 0
sheet 69	of 99
sheets	

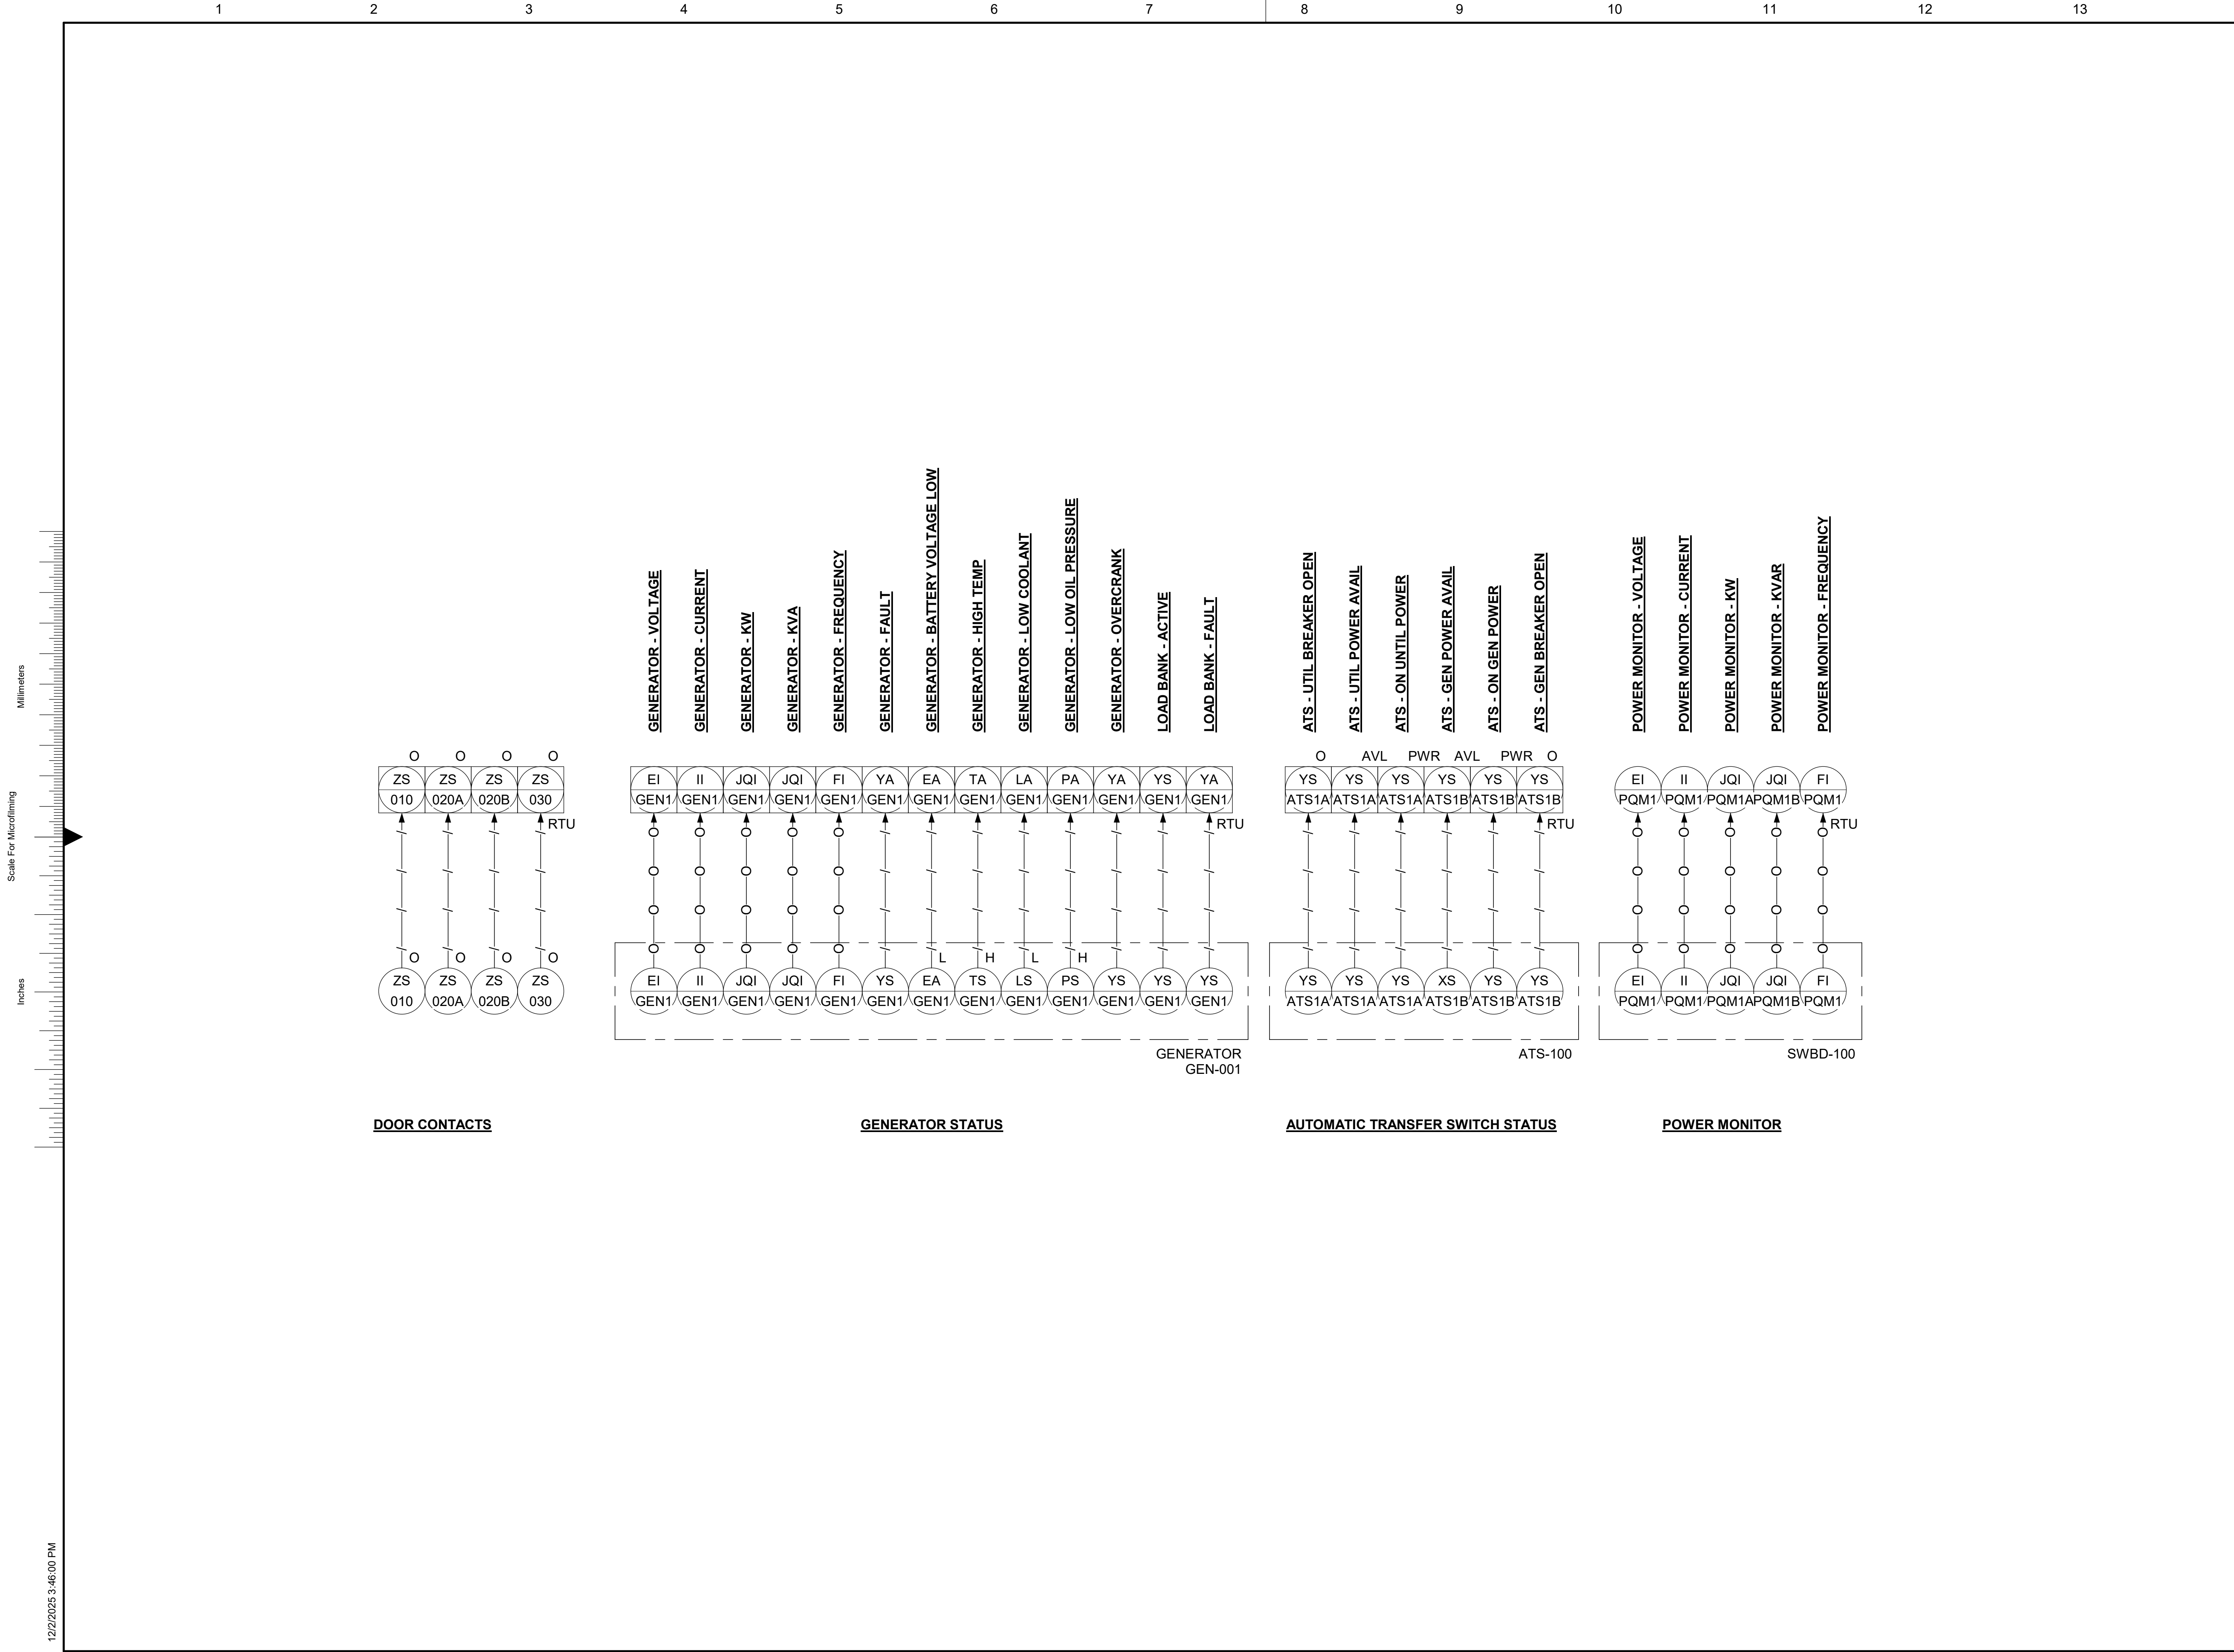

no.	date	by	ckd	description
0	09/30/25	AMM	MAH	ISSUED FOR PERMIT

9191 S. JAMAICA STREET
ENGLEWOOD, CO 80112

Burns & McDonnell Engineering Co, Inc

Issue date SEPTEMBER 2025	detailed by A.BENSON
designed by A. MORRONI	checked by M. HOPKINS

CROSSROADS PUMP STATION ELECTRICAL GENERATOR AND ATS P&ID	
project 124784	contract
drawing 01DI-103	rev. 0
sheet 70	of 99
sheets	

LEGEND OF MECHANICAL SYMBOLS AND ABBREVIATIONS

MECHANICAL

	POSITIVE PRESSURE DUCT - RISE	
	POSITIVE PRESSURE DUCT - DROP	
	NEGATIVE PRESSURE DUCT - RISE	
	NEGATIVE PRESSURE DUCT - DROP	
	ROUND DUCT - RISE	
	ROUND DUCT - DROP	
	TURNING VANES	
	FRESH AIR LOUVER	
	RELIEF AIR OR EXHAUST AIR LOUVER	
	FLEXIBLE DUCT CONNECTION	
	FLEXIBLE DUCT	
	RECTANGULAR DUCT WITH FREE AREA DIMENSIONS SHOWN IN INCHES.	
	ROUND DUCT WITH FREE AREA DIMENSIONS SHOWN IN INCHES.	
	INCLINED RISE INCLINED DROP	WITH RESPECT TO AIR FLOW 15° NOMINAL INCLINE WITH RADIUS TURNS=DEPTH OF DUCT.
	R/W=1. ROUND DUCT SIMILAR TO RECTANGULAR	
	RECTANGULAR TO RECTANGULAR OR ROUND TO ROUND DUCT TRANSFORMATION MAXIMUM 15° INCLUDED ANGLE EXCEPT WHERE SHOWN OTHERWISE.	
	RECTANGULAR TO ROUND DUCT TRANSFORMATION	
	HIGH EFFICIENCY FITTING	
	MANUAL VOLUME DAMPER	
	ATC DAMPER	
	UNIT HEATER	

SYMBOLS

	THERMOSTAT
	POINT OF CONNECTION
	SECTION TAG - TOP FIGURE IS SECTION NO. BOTTOM FIGURE IS SHEET NO.
	DETAIL TAG - TOP FIGURE IS DETAIL NO. BOTTOM FIGURE IS SHEET NO.
	EQUIPMENT IDENTIFICATION
	KEYED NOTE IDENTIFICATION

NOTE: THE HVAC SYSTEM DESIGN IS BASED ON THE MARVAIR, GREENHECK AND AIR-LITE BRANDS. OTHER ENGINEER APPROVED EQUIVALENT UNITS MAY BE USED PROVIDED THE CONTRACTOR FURNISHES ENGINEERED DESIGN OF THE EQUIVALENT UNITS AND RECEIVES ENGINEER APPROVAL BEFORE BIDDING.

AIR HANDLER SCHEDULE

ID	MANUFACTURER AND MODEL NUMBER	LOCATION	AIR			ELECTRICAL		PHYSICAL		NOTES
			SUPPLY AIRFLOW (CFM)	COOLING LOAD (BTU/H)	HEATING LOAD (KW)	SINGLE POINT VOLT/PH/Hz	MCA	CABINET LENGTH/ WIDTH/HEIGHT (IN)	WEIGHT (LB)	
AH-1	MARVAIR AVHA60ACD080CXA5---200	ELECTRICAL RM	1850	54000	6	460/3/60	13.6	23/42/86	540	(1)2(3)4(8)
AH-2	MARVAIR AVHA60ACD080CXA5---200	ELECTRICAL RM	1850	54000	6	460/3/60	13.6	23/42/86	540	(1)2(3)4(8)
AH-3	MARVAIR AVHA60ACD090CXA5---200	PUMP RM	1850	54000	9	460/3/60	16.1	23/42/86	540	(1)2(3)5(6)8
AH-4	MARVAIR AVHA60ACD090CXA5---200	PUMP RM	1850	54000	9	460/3/60	16.1	23/42/86	540	(1)2(3)5(6)7
AH-5	MARVAIR AVHA60ACD090CXA5---200	PUMP RM	1850	54000	9	460/3/60	16.1	23/42/86	540	(1)2(3)5(6)7
AH-6	MARVAIR AVHA60ACD090CXA5---200	PUMP RM	1850	54000	9	460/3/60	16.1	23/42/86	540	(1)2(3)5(6)7
AH-7	MARVAIR AVHA60ACD090CXA5---200	PUMP RM	1850	54000	9	460/3/60	16.1	23/42/86	540	(1)2(3)5(6)7

- (1) ELEVATION 6250 FT.
(2) UNIT COMPLETE WITH COMMSTAT 3 HVAC CONTROLLER TO CONTROL TWO REDUNDANT UNITS. ONE CONTROLLER SHALL CONTROL BOTH UNITS.
(3) DISCONNECT BY MANUFACTURER.
(4) COOLING CONDITIONS: INDOOR 75/63 DB/WB; OUTDOOR 95 DB. HEATING CONDITIONS: INDOOR 65 DB; OUTDOOR -20 DB.
(5) COOLING CONDITIONS: INDOOR 80/63 DB/WB; OUTDOOR 95 DB. HEATING CONDITIONS: INDOOR 65 DB; OUTDOOR -20 DB.
(6) PROVIDE (QTY 1) COMMSTAT 6 HVAC CONTROLLER TO CONTROL FIVE UNITS. THIS UNIT IS ONE OF THE FIVE UNITS.
(7) UNIT COMPLETE WITH FACTORY SUPPLIED SUPPLY AND RETURN AIR GRILLES AND WALL MOUNTING SLEEVES.
(8) UNIT COMPLETE WITH FACTORY SUPPLIED RETURN AIR GRILLE AND WALL MOUNTING SLEEVES.

GRILLES, REGISTERS AND DIFFUSERS

ID	MANUFACTURER	MODEL	SIZE	MAX CFM	MAX NC	DESCRIPTION
CD-1	EH PRICE	AMDA	30/24	2000	30	ALUMINUM DOUBLE DEFLECTION SUPPLY GRILLE. LOUVERED FACE DIRECTIONAL DIFFUSER. INDIVIDUALLY ADJUSTABLE VANES WITH 2S THROW PATTERN.

LOUVER SCHEDULE

ID	MANUFACTURER AND MODEL NUMBER	SERVICE	MIN. FREE AREA (SQ. FT.)	AIR		PHYSICAL	NOTES
				MAXIMUM AIRFLOW RATE (CFM)	STATIC PRESSURE (IN. WATER)		
L-1	AIROLITE K8206E	INLET	5.24	4440	0.1	41/48	(1)2(3)
L-2	AIROLITE K8206E	INLET	5.24	4440	0.1	41/48	(1)2(3)
L-3	AIROLITE K8206E	INLET	5.24	4440	0.1	41/48	(1)2(3)
L-4	AIROLITE K8206E	EXHAUST	5.24	4200	0.1	54/40	(2)3
L-5	AIROLITE K8206E	EXHAUST	5.24	4200	0.1	54/40	(2)3
L-6	AIROLITE K8206E	INLET	0.98	660	0.1	28/21	(1)2(3)

- (1) WITH BIRD SCREEN AND 45 DEGREE WEATHER HOOD.
(2) WITH 120V ELECTRIC MOTOR ACTUATOR IN THE SILL.
(3) INTERLOCK LOUVER WITH THE EXHAUST FAN. FULL OPEN WHEN EXHAUST FAN IS ON.

FAN SCHEDULE

ID	MANUFACTURER AND MODEL NUMBER	LOCATION	TYPE	AIR TYPE	AIR		FAN		ELECTRICAL				PHYSICAL		NOTES
					MAXIMUM AIRFLOW RATE (CFM)	STATIC PRESSURE (IN. WATER)	FAN SPEED (RPM)	STATIC EFFICIENCY (%)	MOTOR SIZE (HP)	MOTOR BHP	MOTOR SPEED (RPM)	VOLT/PH/Hz	LENGTH/ WIDTH/ HEIGHT (IN)	WEIGHT (LBS)	
EF-1	GREENHECK SBE-3H30-7	PUMP ROOM	SIDEWALL	EXHAUST	4,440	0.376	842	46	0.75	0.61	1725	460/3/60	38/44.25/44.25	297	(1)2(3)4(6)
EF-2	GREENHECK SBE-3H30-7	PUMP ROOM	SIDEWALL	EXHAUST	4,440	0.376	842	46	0.75	0.61	1725	460/3/60	38/44.25/44.25	297	(1)2(3)4(7)
EF-3	GREENHECK SBE-3H30-7	PUMP ROOM	SIDEWALL	EXHAUST	4,440	0.376	842	46	0.75	0.61	1725	460/3/60	38/44.25/44.25	297	(1)2(3)4(7)
EF-4	GREENHECK SBCR-30-10	PUMP ROOM	SIDEWALL	SUPPLY	8,400	0.25	1075	33	1	1.07	1725	460/3/60	26/38/38	115	(1)5(7)
EF-5	GREENHECK SBE-1H20-4	PUMP ROOM	SIDEWALL	EXHAUST	660	0.25	791	20	0.25	0.15	1725	115/1/60	17.55/26.13/26.13	125	(1)2(3)4(6)

- (1) 6250 FT ELEVATION.
(2) INTERLOCK INTAKE LOUVER DAMPER WITH EXHAUST FAN BY DIV 26.
(3) UNIT COMPLETE WITH WALL HOUSING, MOTOR GUARD, WEATHER HOOD, MOTORIZED BACKDRAFT DAMPER AND BIRD SCREEN.
(4) LOUVER TO FULL OPEN WHEN FAN IS ON.
(5) UNIT COMPLETE WITH FAN GUARD, WALL HOUSING AND MOTOR GUARD.
(6) CONTROLS: PROVIDE AND INSTALL A CONTROL TIMER FOR VENTILATION FANS SEE SEQUENCE OF OPERATION IN THE BUILDING AUTOMATION SYSTEM SECTION OF THE SPECIFICATIONS.
(7) CONTROLS: PROVIDE AND INSTALL A CONTROLLER FOR ECONOMIZING FANS SEE SEQUENCE OF OPERATION IN THE BUILDING AUTOMATION SYSTEM SECTION OF THE SPECIFICATIONS.

1

REV NO.

09-13-23

DATE

Professional Engineer (Mechanical)

Kim P. Harris

9087

WYOMING

SUNRISE ENGINEERING

47 EAST 4TH AVENUE

AFTON, WYOMING 83110

TEL 307.885.8500 · FAX 307.885.8501

www.sunrise-eng.com

GR-RS-SWC JPWB

CROSSROADS PUMP STATION

MECHANICAL SYMBOLS LEGEND & SCHEDULES

SEI NO.

DESIGNED

DRAWN

CHECKED

SHEET NO.

07265

JJ

DB

RV

71 of 99

M1


X:\20000\20376 Crossroads Pump Station\01_Cadd\WEP_Mechanical\20376_M1--dwg Sep 13, 2023 2:50pm jhall

CODE INFORMATION


- A. 2021 IBC, 2021 IRC, 2021 IFGC, 2021 IECC & THE STATE OF WYOMING AMENDMENTS. ALL SYSTEMS SHALL BE IN COMPLIANCE WITH THE ABOVE CODES AS ADOPTED BY THE STATE OF WYOMING.
- B. OUTDOOR AIR VENTILATION PROVIDED AND BASED ON WYOMING ADMINISTRATIVE CODE. VENTILATION RATE SHALL BE 12 AIR CHANGES PER HOUR FOR 10 MINUTES AT 30 MINUTE INTERVALS.
- C. EQUIPMENT AND APPLIANCES SHALL BE INSTALLED AS REQUIRED BY THE TERMS OF THEIR APPROVAL, IN ACCORDANCE WITH THE CONDITIONS OF THE LISTING, THE MANUFACTURER'S INSTALLATION INSTRUCTIONS, AND MANUFACTURER'S INSTALLATION INSTRUCTIONS SHALL BE AVAILABLE ON THE JOB SITE AT THE TIME OF INSPECTION.

2021 IECC COMPLIANCE NOTES


1. PROVIDE OWNER WITH COMPLETE OPERATION AND MAINTENANCE MANUALS FOR ALL EQUIPMENT AND CONTROLS INSTALLED. DOCUMENTATION MUST INCLUDE EQUIPMENT CAPACITY (INPUT & OUTPUT), REQUIRED MAINTENANCE ACTIONS, CONTROLS, AND CALIBRATION INFORMATION INCLUDING WIRING DIAGRAMS, CONTROL SEQUENCE DESCRIPTIONS, DESIRED OR FIELD-DETERMINED SETPOINTS, AND A COMPLETE NARRATIVE OF HOW EACH SYSTEM IS INTENDED TO OPERATE.

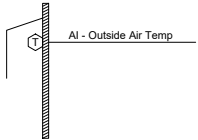


6 OUTSIDE AIR TEMPERATURE SENSOR
M2 NO SCALE

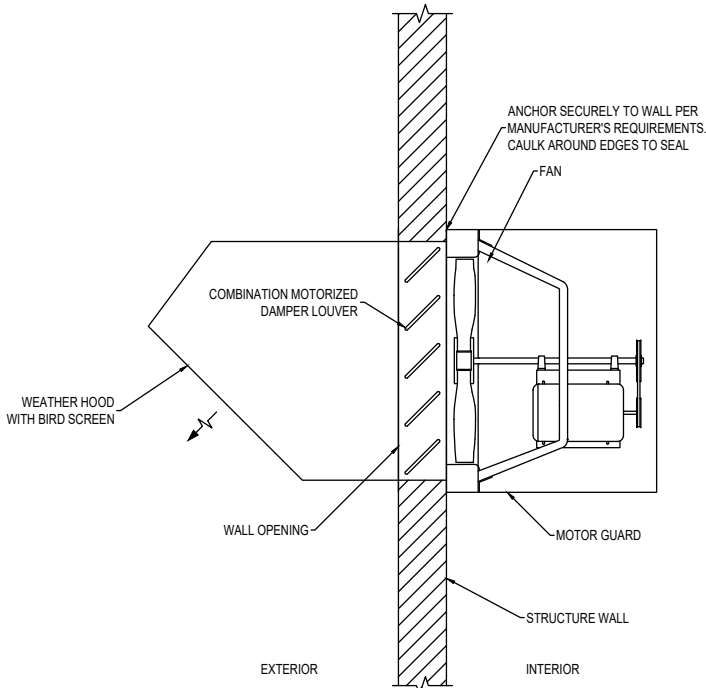

1 SIDE WALL VENTILATION FAN DETAIL
M2 NO SCALE

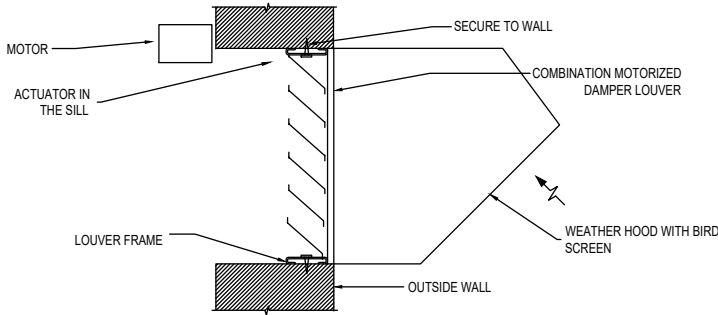

2 COMBINATION WALL LOUVER SECTION
M2 NO SCALE

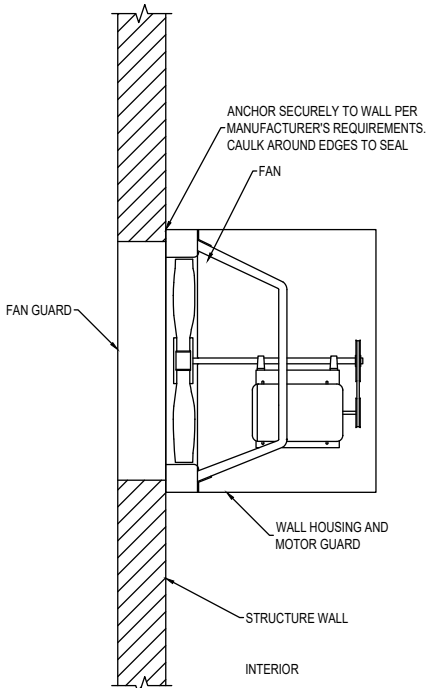

3 SIDE WALL FAN DETAIL
M2 NO SCALE

1		09-13-23
REV. NO.	COMMENT	DATE
Professional Engineer (Mechanical) Kip P. Harris 9087 Date WYOMING SUNRISE ENGINEERING 47 EAST 4TH AVENUE AFTON, WYOMING 83110 TEL 307.885.8500 · FAX 307.885.8501 www.sunrise-eng.com		
GR-RS-SWC JPWB		
CROSSROADS PUMP STATION		
MECHANICAL DETAILS		
SEI NO. 07265	DESIGNED JJ	DRAWN DB
CHECKED RV	SHEET NO. 72 of 99	M2

01–230050 HVAC DESIGN CRITERIA

- A.

WORK INCLUDED: FURNISH ALL LABOR, MATERIALS ,EQUIPMENT, APPLIANCES AND NECESSARY INCIDENTALS FOR THE COMPLETE INSTALLATION OF ALL HEATING AND VENTILATION AS SHOWN ON THE DRAWINGS AND AS SPECIFIED HEREIN.
- B.

RELATED WORK INCLUDED IN THIS SECTION:

1.

FURNISHING ELECTRICAL DEVICES NECESSARY FOR MECHANICAL WORK, EXCEPT DISCONNECTS UNLESS INDICATED OTHERWISE.

2.

LINE AND LOW VOLTAGE WIRING FOR MECHANICAL CONTROLS INCLUDING FINAL CONNECTIONS AS INDICATED ON WIRING DIAGRAMS.

3.

CONDUIT FOR LINE AND LOW VOLTAGE WIRING FOR MECHANICAL CONTROLS AS INDICATED ON WIRING DIAGRAMS.

4.

RESPONSIBILITY FOR OBTAINING CLARIFICATION OF DISCREPANCIES BETWEEN MECHANICAL AND ELECTRICAL WORK FROM ARCHITECT PRIOR TO PROCEEDING WITH THE WORK.

5.

RESPONSIBILITY FOR PROPER OPERATION OF AUTOMATIC ELECTRICAL CONTROLS AND EQUIPMENT, AND OF ELECTRIC POWER DRIVEN EQUIPMENT FURNISHED UNDER THIS SECTION.
- C.

RELATED WORK IN OTHER SECTIONS:

1.

ELECTRICAL WORK AS FOLLOWS WILL BE PROVIDED UNDER ELECTRICAL DIVISION:
- D.

CONDUIT FOR LINE VOLTAGE WIRING FOR EQUIPMENT AND DEVICES AS INDICATED OR SPECIFIED EXCEPT CONDUIT FOR LINE AND LOW VOLTAGE WIRING FOR MECHANICAL CONTROLS AS SPECIFIED UNDER DIVISION 23.
- E.

LINE VOLTAGE WIRING FOR EQUIPMENT AND DEVICES AS INDICATED OR SPECIFIED HEREIN EXCEPT LINE AND LOW VOLTAGE WIRING FOR MECHANICAL CONTROLS AS SPECIFIED UNDER DIVISION 23.
- F.

PROVIDING DISCONNECT SWITCHES.
- G.

INSTALLING ELECTRICAL DEVICES SUCH AS STARTERS AND DISCONNECTS, AND, WHEN INDICATED, FURNISHING ALL SUCH DEVICES.
- H.

CODES AND STANDARDS:

1.

IN ADDITION TO THE REQUIREMENTS OF ALL GOVERNING CODES, ORDINANCES, AND AGENCIES, CONFORM TO THE REQUIREMENTS OF THE FOLLOWING CODES AND STANDARDS:

2021 INTERNATIONAL MECHANICAL CODE.

2021 INTERNATIONAL BUILDING CODE.

2021 INTERNATIONAL PLUMBING CODE.

2021 INTERNATIONAL ENERGY CONSERVATION CODE.

2021 INTERNATIONAL FUEL AND GAS CODE.

ASHRAE 90.1.

2020 INTERNATIONAL ELECTRICAL CODE.

F.

DESIGN CONDITIONS

1.

OUTSIDE DESIGN CONDITIONS: THE FOLLOWING IS CLIMATE DATE FROM ASHRAE 2017 FUNDAMENTAL HANDBOOK 14 FOR ROCK SPRINGS, WYOMING

a.

SUMMER DESIGN DRY BULB TEMP. (ASHRAE 1%), 85°F

b.

SUMMER MEAN COINCIDENT WET BULB. (ASHRAE 1%), 54.4°F

c.

WINTER DESIGN DRY BULB TEMP. (ASHRAE 99%), 0.8°F

d.

EXTREME WINTER DRY BULB TEMP, (ASRAE) –20°F
- 01–230051 PRODUCT HANDLING
- A.

PROTECTION: TAKE ALL PRECAUTIONS NECESSARY TO PROTECT THE MATERIALS OF THIS SECTION BEFORE, DURING, AND AFTER INSTALLATION.

B.

REPLACEMENTS: IN THE EVENT OF DAMAGE, IMMEDIATELY REPAIR ALL DAMAGED AND DEFECTIVE WORK TO THE APPROVAL OF THE ENGINEER, AT NO ADDITIONAL COST TO THE OWNER.
- NOTE: THE HVAC SYSTEM DESIGN IS BASED ON THE MARVAIR, GREENHECK AND AIRLITE BRANDS. OTHER ENGINEER APPROVED EQUIVALENTS UNITS MAY BE USED PROVIDED THE CONTRACTOR FURNISHES ENGINEERED DESIGN OR THE EQUIVALENT UNITS AND RECEIVES ENGINEER APPROVAL BEFORE BIDDING.
- 01–230053 MISCELLANEOUS
- A.

PERMIT AND FEES: EXAMINATION, APPLY, PAY FOR ALL NECESSARY PERMITS, INSPECTIONS, EXAMINATIONS, AND FEES OR CHARGES REQUIRED BY PUBLIC AUTHORITIES HAVING JURISDICTION.

B.

LOCATIONS AND ACCESSIBILITY: CONTRACTOR SHALL FULLY INFORM HIS/HERSELF REGARDING PECULIARITIES AND LIMITATIONS OF SPACE AVAILABLE FOR INSTALLATION OF WORK UNDER THIS SECTION. VALVES, MOTORS, CONTROLS, AND OTHER DEVICES REQUIRING SERVICE, MAINTENANCE, ADJUSTMENT SHALL BE PLACED IN FULLY ACCESSIBLE POSITIONS AND LOCATIONS. PROVIDE ACCESS DOORS WHERE REQUIRED IN DUCTWORK AND/OR CONSTRUCTION WHETHER SPECIALLY DETAILED OR NOT, AND RENDER ALL SUCH DEVICES ACCESSIBLE.

C.

SCAFFOLDING: FURNISH ALL SCAFFOLDING, RIGGING, HOISTING AS REQUIRED FOR THE PROPER EXECUTION OF THE WORK.

D.

DRAWINGS: DRAWINGS INDICATE DESIRED LOCATION AND ARRANGEMENT OF EQUIPMENT AND OTHER ITEMS, AND ARE TO BE FOLLOWED AS CLOSELY AS POSSIBLE. ALL OFFSETS AND INTERFERENCES MAY NOT BE SHOWN BECAUSE OF THE SCALE OF DRAWINGS. ASSUME THE RESPONSIBILITY FOR COORDINATING THE WORK WITH ALL OTHER TRADES. WORK SPECIFIED AND NOT CLEARLY DEFINED BY THE DRAWINGS SHALL BE INSTALLED AND ARRANGED IN A MANNER SATISFACTORY TO THE ENGINEER. IN THE EVENT CHANGES IN INDICATED LOCATIONS AND ARRANGEMENTS ARE DEEMED NECESSARY BY ENGINEER, THEY SHALL BE MADE BY THIS CONTRACTOR WITHOUT ADDITIONAL CHARGES.

E.

ALL HVAC EQUIPMENT SHALL BE LABELED. INFORMATION ON LABELS SHALL INCLUDE: IDENTIFICATION NUMBER AND NAME SAME AS THE DRAWINGS, FLOW AND STATIC PRESSURE, AND THE AREA TO WHICH THE UNIT SERVES. LABELS SHALL BE BLACK FACED FORMICA WITH WHITE ENGRAVED LETTERING AT LEAST 3/16 INCH HIGH.
- 01–230550 SUBMITTALS AND O&M MANUALS
- A.

SHOP DRAWINGS: WITHIN 15 DAYS AFTER AWARD OF CONTRACT, AND BEFORE ANY OF THE MATERIALS OF THIS SECTION ARE FABRICATED AND DELIVERED TO THE JOBSITE, THE CONTRACTOR SHALL SUBMIT COMPLETE SHOP DRAWINGS AND EQUIPMENT SUBMITTALS FOR ENGINEER TO REVIEW IN ACCORDANCE WITH THESE SPECIFICATIONS. SHOW ALL DETAILS OF ALL DUCTWORK, AND EQUIPMENT PADS.

B.

PRODUCT DATA:

1.

SUBMIT ELECTRONIC COPIES OF ALL MANUFACTURER’S PRODUCT DATA SIMULTANEOUSLY WITH ALL SHOP DRAWING SUBMITTALS.

2.

PRODUCT DATA TO INCLUDE ALL AIR CONDITIONING EQUIPMENT, HANGERS, FANS, AND OTHER STANDARD ITEMS AS REQUIRED TO COMPLEMENT SHOP DRAWINGS FOR A SUBMITTAL INDICATING PRODUCTS TO BE USED ON THIS WORK.

3.

MANUFACTURERS AND SUPPLIERS OF EQUIPMENT SHALL PROVIDE ALL DATA NECESSARY FOR COMPLIANCE WITH THE STATE OF WYOMING ENERGY CONSERVATION STANDARDS. COMPLIANCE CERTIFICATION FOR ALL EQUIPMENT SHALL BE INCLUDED IN EQUIPMENT SUBMITTALS.

C.

RECORD DRAWINGS: MAINTAIN THROUGHOUT THE PROGRESS OF THE WORK PROJECT RECORD DRAWINGS AND SUBMIT TO THE OWNER.

D.

OPERATION AND MAINTENANCE MANUALS:

1.

PROVIDE 1 HARD COPY OF THE O&M MANUALS FOR USE BY OWNER.

2.

PROVIDE AN ELECTRONIC FILE OF THE COMPLETE O&M IN PDF FORMAT.

3.

PROVIDE BINDERS FOR SIZE 8 – ½ x 11 INCH SHEETS, 2 INCHES TO 3 – ½ INCHES AS REQUIRED BY THE PROJECT. THE FRONT COVER AND BACKBONE SHALL BE LABELED IN WHITE AS FOLLOWS:

OPERATING AND MAINTENANCE MANUAL FOR THE

(INSERT PROJECT NAME)

YEAR

VOLUME NO.()

(INSERT MECHANICAL ENGINEER)

MECHANICAL ENGINEER

(INSERT ARCHITECT)

ARCHITECT

4.

PROVIDE AN INDEX SHEET TYPED ON AICO GOLD–LINE INDEXES IN THE FRONT OF THE BINDER. THE MANUAL SHALL INCLUDE THE FOLLOWING.

a.

SYSTEM DESCRIPTIONS AND BASIS OF DESIGN

b.

START–UP PROCEDURE AND OPERATION OF SYSTEM

c.

MAINTENANCE AND LUBRICATION TABLE

d.

OPERATION AND MAINTENANCE BULLETINS

e.

EQUIPMENT START–UP CERTIFICATES

E.

GUARANTEES: IN ADDITION TO EQUIPMENT WARRANTIES, FURNISH A WRITTEN GUARANTEE AGAINST DEFECTS IN MATERIALS AND WORKMANSHIP FOR ONE YEAR. GUARANTEE SHALL INCLUDE REPAIR OF DAMAGE TO, OR REPLACEMENT OF, ANY PART OF EQUIPMENT OR PREMISES CAUSED BY LEAKS OR BREAKS IN PIPE OR EQUIPMENT PROVIDED UNDER THIS SECTION.

01–230553 HVAC EQUIPMENT IDENTIFICATION

EQUIPMENT IDENTIFICATION

1.

IDENTIFY ALL MECHANICAL EQUIPMENT AND ALL OTHER DEVICES WITH SIGNS MADE OF LAMINATED PLASTIC WITH ONE–EIGHT INCH (⅛”) OR LARGER ENGRAVED LETTERS. ATTACH SIGNS SECURELY WITH RUST PROOF SCREW OR SOME OTHER PERMANENT MEANS (NO ADHESIVES).

2.

INCLUDE THE FOLLOWING INFORMATION ON THE EQUIPMENT IDENTIFICATION SIGN: NAME OF EQUIPMENT, IDENTIFICATION ON PLANS AND SCHEDULES, DESIGN CAPACITY, AND ANY OTHER IMPORTANT DATA NO INCLUDED ON FACTORY ATTACHED NAME PLATE.

3.

ATTACH SIGNS TO EQUIPMENT SO THEY CAN BE EASILY READ. ATTACH USING SCREW OR RIVETS.

4.

A SAMPLE IDENTIFICATION SIGN FOR EQUIPMENT IS AS FOLLOWS:

"SUPPLY FAN –AUDITORIUM F–2

CAPACITY: 49,850 CFM @ 3.5” S.P. (AT 4775 FT. ELEV.)"

"HEATING HOT WATER PUMP

CLASSROOM AREA

156 GPM @ 57 FT.HEAD"

PART 2 – PRODUCTS

02–230529 HANGERS AND SUPPORTS FOR HVAC PIPING AND EQUIPMENT.

A.

PROVIDE RUST RESISTANT STEEL HANGERS, SUPPORTS, RODS AND ACCESSORIES.

B.

PROVIDE HANGERS TO ACCOMMODATE FULL SIZE INSULATION SYSTEM.

02–233400 HVAC FANS

A.

FANS OF SIZE AND CAPACITY SHOWN ON DRAWINGS SHALL BE FURNISHED AND INSTALLED. FANS SHALL BE DIRECT DRIVE OF RPM SHOWN AND SHALL BE COMPLETE WITH FAN HOUSING, INLET GRILLE, AND MOTOR. AIR QUANTITIES SHALL BE CERTIFIED BY AMCA.

B.

APPROVED MANUFACTURES ARE:

1.

LOREN–COOK

2.

GREEN–HECK

3.

TWIN–CITY

02–233113 METAL DUCTS

A.

PROVIDE DUCTS, PLENUMS, ACCESS DOORS, FRESH AIR INTAKES, AND EXHAUSTS AS INDICATED AND REQUIRED. ALL DUCTWORK SHALL BE CONSTRUCTED, ERECTED, AND TESTED IN ACCORDANCE WITH THE MOST RESTRICTIVE OF LOCAL REGULATIONS, PROCEDURES DETAILED IN THE ASHRAE HANDBOOK OF FUNDAMENTALS, OR THE APPLICABLE STANDARDS ADOPTED BY THE SHEET METAL AND AIR CONDITIONING CONTRACTORS NATIONAL ASSOCIATION. PROVIDE PREFABRICATED SPIRAL LOCKSEAM DUCTS AND FITTINGS AND RECTANGULAR DUCTS OF GALVANIZED STEEL. ALUMINUM FLEXIBLE DUCTWORK OR GYPSUM BOARD DUCTWORK IS NOT ACCEPTABLE.

B.

ALL CONNECTIONS TO MAIN DUCTS SHALL BE MADE WITH LOW LOSS FITTINGS.

C.

URNS SHALL BE MADE WITH A THROAT RADIUS OF NO LESS THAN THE DUCT WIDTH.

D.

TURNING VAINS SHALL BE INSTALLED IN ALL RECTANGULAR ELBOWS.

02–233300 AIR DUCT ACCESSORIES

A.

CONTROL DAMPERS: LOW LEAKAGE, HAT SHAPED 20 GA. GALVANIZED STEEL FRAME, MITERED AND WELDED CORNERS, 6” MAX BLADE WIDTH, PARALLEL BLADE, 20 GA. BLADES. DAMPERS SHALL BE SUBJECT TO COMPLIANCE WITH REQUIREMENTS, PROVIDE PRODUCTS BY ONE OF THE FOLLOWING MANUFACTURERS:

1.

GREENHECK

2.

POTTORFF

3.

RUSKIN

4.

YOUNG

5.

AIROLITE

6.

PROVIDE ACCESS FOR ALL DAMPERS.

1		09–13–23
REV NO.	COMMENT	DATE
Professional Engineer (Mechanical) Kim P. Harris 9087 Date WYOMING SUNRISE ENGINEERING 47 EAST 4TH AVENUE AFTON, WYOMING 83110 TEL 307.885.8500 · FAX 307.885.8501 www.sunrise-eng.com		
GR–RS–SWC JPWB		
CROSSROADS PUMP STATION		
MECHANICAL SPECIFICATIONS		
SEI NO.	DESIGNED	DRAWN
07265	JJ	DB
CHECKED	SHEET NO.	
RV	73 of 99	
M3		

X:\20000\20376 Crossroads Pump Station\01_Good\MEP\Mechanical\20376_M1–dwg Sep 13, 2023 2:51pm jhall

WALL MOUNTED AIR HANDLING UNIT.

- UNIT OF SIZE AND CAPACITY INDICATED. UNITS SHALL BE COMPLETELY ASSEMBLED AND TESTED AND READY TO OPERATE. TOTAL UNIT SHALL BE U.L. LISTED AND CARRY A U.L. LABEL.
- A. FURNISH AND INSTALL A SELF-CONTAINED WALL MOUNT AIR CONDITIONER SUITABLE FOR OUTDOOR USE. THE UNIT IS TO BE MANUFACTURED BY MARVAIR, DIVISION OF AIRXCEL, INC. THE WALL MOUNT UNIT SHALL BE COMPLETELY FACTORY ASSEMBLED AND TESTED, AND SHALL INCLUDE COMPRESSOR, INDOOR AND OUTDOOR COILS, FANS AND MOTORS AS REQUIRED, PREWIRED CONTROLS, INTERCONNECTING REFRIGERANT TUBING, WIRING, DISCONNECTS, AND OTHER NECESSARY COMPONENTS MOUNTED IN A CORROSION RESISTANT CABINET. UNIT SHALL BE SHIPPED FROM THE FACTORY WITH A FULL OPERATING REFRIGERANT AND OIL CHARGE. ALL FIELD WIRING SHALL BE IN ACCORDANCE WITH THE NATIONAL ELECTRIC CODE AND ALL LOCAL CODES.
- B. THE CABINET SHALL BE CONSTRUCTED OF 20 GAUGE ZINC-COATED, GALVANIZED G60 STEEL WITH SATIN BEIGE POLYESTER FINISH. THE FINISH SHALL BE HIGHLY RESISTANT TO ABRASION, METAL MARKING, STAINING, PRESSURE MOTTLING AND REQUIRE MINIMAL MAINTENANCE. THE CABINET SHALL INCLUDE A SLOPED TOP AND BUILT-IN MOUNTING FLANGES. THE CONDITIONED AIR SECTION SHALL BE INSULATED WITH 1/2 INCH, 2 POUND DUAL DENSITY FIBERGLASS.
- C. TWO INCH FILAMENT SPUN GLASS TYPE FILTER SHALL BE MOUNTED INTERNALLY, FACTORY SUPPLIED, AND ACCESSIBLE THROUGH AN EXTERNAL PANEL. FILTERS SHALL HAVE A MERV RATING OF 8
- D. THE COMPRESSOR SHALL BE A HERMETIC SCROLL TYPE. THE REFRIGERATION CIRCUIT SHALL CONTAIN A LIQUID FILTER DRYER, SUCTION AND LIQUID ACCESS VALVES. THE REFRIGERATION CIRCUIT SHALL INCLUDE A HIGH PRESSURE SWITCH AND A LOW PRESSURE SWITCH WITH A LOCKOUT RELAY. THE COMPRESSOR MOTOR SHALL BE PROTECTED BY AN INTERNAL LINE BREAK THERMOSTAT. ELECTRICAL WIRING CONNECTIONS AT THE COMPRESSOR SHALL BE PROTECTED BY RECEPTACLE HOUSING. REFRIGERANT SHALL BE R-410A.

OUTDOOR SECTION:

- 8.0 THE CONDENSER COIL SHALL BE CONSTRUCTED OF ALUMINUM PLATE FINS MECHANICALLY BONDED TO SEAMLESS COPPER TUBES. OUTDOOR FAN SHALL BE DIRECT DRIVEN, SLOW SPEED PROPELLER TYPE FOR QUIET OPERATION. THE OUTDOOR MOTOR SHALL BE EQUIPPED WITH A THERMAL PROTECTOR.

INDOOR SECTION

- 9.0 THE EVAPORATOR COIL SHALL BE CONSTRUCTED OF ALUMINUM PLATE FINS MECHANICALLY BONDED TO SEAMLESS COPPER TUBES. TWO DIRECT DRIVE INDOOR BLOWERS SHALL BE OF CENTRIFUGAL TYPE, FORWARD CURVED. THE INDOOR MOTOR SHALL BE EQUIPPED WITH A THERMAL PROTECTOR.

CONTROL CIRCUIT

- 10.0 THE INTERNAL CONTROL CIRCUIT SHALL CONSIST OF A CURRENT LIMITING TYPE TRANSFORMER TO GENERATE 24 VAC, SWITCHING DEVICES TO OPERATE THE COMPRESSOR, INDOOR FAN MOTOR, AND ELECTRICAL HEATER(S). THE CONTROL CIRCUIT SHALL INCORPORATE A MANUAL RESET SAFETY CIRCUIT TO RENDER THE REFRIGERANT SYSTEM (COMPRESSOR AND OUTDOOR FAN MOTOR) INOPERATIVE SHOULD THERE BE A HIGH OR LOW REFRIGERANT PRESSURE CONDITION. SYSTEM LOCKOUT CONDITION SHALL BE INDICATED BY CONTACT CLOSURE AVAILABLE AT LOW VOLTAGE TERMINAL BLOCK. THE SAFETY CIRCUIT SHALL BE RESETTABLE AT THE WALL THERMOSTAT. TO PREVENT COMPRESSOR MOTOR OVERHEATING AND TO DELAY START-UP OF COMPRESSOR ON A CALL FOR COOLING, AN AUTOMATIC RESETTING ADJUSTABLE TIME DELAY CIRCUIT SHALL ALSO BE FACTORY INSTALLED. A TIMED LOW PRESSURE BYPASS SWITCH FOR START-UP OF THE AIR CONDITIONER IN COOL AMBIENT TEMPERATURES SHALL BE FACTORY INSTALLED. A HIGH PRESSURE SWITCH (HPS) AND A LOW PRESSURE SWITCH (LPS) SHALL BE FACTORY INSTALLED. COMPAC AIR CONDITIONERS SHALL HAVE A FACTORY INSTALLED ELECTRONIC CIRCUIT BOARD. THE CONTROL BOARD SHALL INCORPORATE THE BLOWER RELAY, THE LOCKOUT RELAY, THE COMPRESSOR TIME DELAY AND THE TIMED LOW PRESSURE BYPASS. THE BOARD SHALL HAVE LED'S TO INDICATE STATUS AND FAULT CONDITIONS TO ASSIST THE SERVICE TECHNICIAN.

10.1 MODES OF OPERATION

NORMAL: UPON A CALL FOR COOLING AND WITH THE HIGH PRESSURE SWITCH (HPS) CLOSED, THE COOLING SYSTEM (COMPRESSOR, INDOOR BLOWER AND OUTDOOR FAN MOTOR) WILL BE ENERGIZED. (NOTE: SEE THE DELAY ON MAKE FEATURE.) THE COOLING SYSTEM WILL REMAIN ENERGIZED DURING THE 3 MINUTE TIMED LOW PRESSURE BY-PASS CYCLE. IF THE LOW PRESSURE SWITCH (LPS) IS OPEN AFTER THE THREE MINUTE BY-PASS, THE COOLING SYSTEM WILL DE-ENERGIZED.

LOCKOUT: IF EITHER OF THE FAULT CONDITIONS (LPS OR HPS) OPENS TWICE DURING THE SAME CALL FOR COOLING, THE CONTROL BOARD ENTERS INTO AND INDICATES THE LOCKOUT MODE. IN THE LOCKOUT MODE, THE COMPRESSOR IS TURNED OFF, THE ALARM OUTPUT IS ENERGIZED AND THE STATUS LED'S WILL BLINK TO INDICATE WHICH FAULT HAS OCCURRED. IF THERE IS A CALL FOR AIR FLOW, THE INDOOR BLOWER WILL REMAIN ENERGIZED. WHEN THE LOCKOUT CONDITION IS CLEARED, THE UNIT WILL RESET IF THE DEMAND OF THE MARVAIR THERMOSTAT IS REMOVED OR WHEN THE POWER IS RESET. THE COMPAC AIR CONDITIONERS SHALL BE FACTORY WIRED TO BE NORMALLY OPEN. THE USER SHALL BE ABLE TO HAVE NORMALLY CLOSED CONTACTS.

DELAY ON BREAK: IF THE COMPRESSOR IS DE-ENERGIZED DUE TO A LOSS OF A COOLING, OR THE FIRST FAULT, THE UNIT RE-START WILL BE DELAYED 3 MINUTES FROM THE TIME THE CONTACTOR IS DE-ENERGI ED. (NOTE: IHERE IS NO DELAY ON BREAK IF THE LOCKOUT CONDITION IS RFSET.)

DELAY ON MAKE: ON INIIIAL POWER UP ONLY, IIE UNIT WILL WAIT 0.0 TO 10 MINUTES FROM THE COOLING CALL BEFORE ALLOWING THE CONIACIOR IO ENERGIZE.

LOW PRESSURE BY-PASS TIME: WHILE RUNNING OR STARTING, THE UNIT WILL BY-PASS THE LOW PRESSURE SWITCH (LPS) FAULT CONDITION FOR 3 MINUTES BEFORE DE-ENERGIZING THE CONTACTOR.

POST PURGE: UPON A CALL FOR INDOOR AIRFLOW THE BLOWER WILL ENERGIZE IMMEDIATELY. WHEN IN THE COOLING MODE, THE BLOWER WILL REMAIN ENERGIZED FOR 10 TO 90 SECONDS (ADJUSTABLE) AFTER THE COMPRESSOR HAS BEEN DE-ENERGIZED.

WALL MOUNTED AIR HANDLING UNIT (CONTINUED).

ELECTRICAL CONTROL BOX

- 11.0 THE ELECTRICAL CONTROL BOX SHALL BE LOCATED BEHIND THE FRONT PANEL. THE ELECTRICAL CONTROL BOX, INCLUDING THE LOW VOLTAGE COMPARTMENT, SHALL BE ACCESSIBLE FROM THE FRONT OF THE AIR CONDITIONER. SIDE MOUNTED CONTROL BOXES SHALL NOT BE PERMITTED.

SUPPLY/RETURN GRILLE

- 12.0 THE SUPPLY GRILLE SHALL BE AN ADJUSTABLE ALUMINUM, DOUBLE DEFLECTION GRILLE, FACTORY PROVIDED. THE RETURN GRILLE SHALL BE AN ALUMINUM GRILLE, FACTORY PROVIDED.

ELECTRICAL DISCONNECT

- 13.0 THE AIR CONDITIONER SHALL HAVE A FACTORY INSTALLED DISCONNECT(S) ON ALL 60 HZ. MODELS. TO COMPLY WITH THE LATEST U.L. 1995 SAFETY STANDARD, ELECTRIC HEATING ELEMENTS SHALL BE ON A SEPARATE ELECTRICAL CIRCUIT(S).

COMMSTAT 3 CONTROLS

- 14.0 THE CONTROL OF THE TWO A/C UNITS SHALL BE THE MARVAIR COMMSTAT 3 LEAD LAG CONTROLLER. THE COMMSTAT 3 SHALL BE FACTORY PROGRAMMED WITH STANDARD INDUSTRY SET POINTS, BUT EACH OF THESE SET POINTS SHALL HAVE THE CAPABILITY TO BE CHANGED IN THE FIELD AFTER INSTALLATION. INSTRUCTIONS FOR PROGRAMMING THE CONTROLLER SHALL BE PRINTED ON THE FRONT OF THE CONTROLLER. TEMPERATURE DISPLAY SHALL BE EITHER IN FAHRENHEIT OR CELSIUS. THE LEAD LAG CHANGEOVER SHALL BE ADJUSTABLE FROM ½ DAY TO 7 DAYS IN ½ DAY INCREMENTS TO ENSURE EQUAL RUN TIME ON EACH AIR CONDITIONER. THE CONTROLLER SHALL ALLOW THE LAG UNIT TO ASSIST UPON DEMAND. THE COOLING RANGE SHALL BE ADJUSTABLE FROM 72°F TO 95°F (22°C TO 35°C). THE HEATING RANGE SHALL BE ADJUSTABLE FROM 50°F TO 80°F (10°C TO 27°C). THE ON/OFF DIFFERENTIAL OF EACH STAGE AND THE INTERSTAGE DIFFERENTIAL OF EACH STAGE SHALL BE ADJUSTABLE. THE CONTROLLER SHALL OPERATE ON 24 VAC AND SHALL BE INSENTIVE TO PHASING OF THE AIR CONDITIONERS. THE CONTROLLER SHALL HAVE LED'S TO INDICATE CONTROL POWER FROM EACH AIR CONDITIONER, FUNCTION (HEATING OR COOLING), THE LEAD UNIT AND HIGH OR LOW REFRIGERANT PRESSURE LOCKOUT. A COMFORT BUTTION SHALL BE READILY ACCESSIBLE ON THE FRONT OF THE CONTROLLER TO OVERRIDE THE COOLING AND HEATING SET POINTS FOR 90 MINUTES. THE TEMPERATURE DURING THE 90 MINUTES SHALL BE USER SELECTABLE – EITHER 72° F (22°C) OR 77° F (25° C). IF ONE OF THE AIR CONDITIONERS LOSES POWER, THE CONTROLLER SHALL AUTOMATICALLY ADVANCE THE OTHER UNIT TO LEAD CONTROL. THE CONTROLLER SHALL INDEFINITELY RETAIN ITS SETTINGS ON A POWER LOSS. THE CONTROLLER SHALL HAVE DRY CONTACTS TO PROVIDE REMOTE ALARM OR NOTIFICATION. THE RELAYS SHALL BE EITHER NORMALLY OPEN OR NORMALLY CLOSED. THE CONTROLLER SHALL HAVE ALARM RELAYS FOR: POWER TO INDICATE A LOSS OF POWER TO THE COMMSTAT 3 CONTROLLER, LOW BUILDING TEMPERATURE, HIGH BUILDING TEMPERATURE, REFRIGERANT PRESSURE LOCK OUT AND A SMOKE ALARM OUTPUT. THE CONTROLLER SHALL HAVE AN INPUT FOR A SMOKE DETECTOR (SMOKE DETECTOR PROVIDED BY OTHERS). THE ENCLOSURE OF THE CONTROLLER SHALL BE CONSTRUCTED OF A NON-CORRODING POLYCARBONATE MATERIAL.

DIFFUSERS AND GRILLES. AIR DISTRIBUTION EQUIPMENT SHALL BE OF SIZES AND CAPACITIES INDICATED:

- A. REGISTERS, GRILLES, AND DIFFUSERS OF THE SIZES SHOWN ON THE DRAWINGS AND DESCRIBED HEREIN SHALL BE FURNISHED AND INSTALLED. ALL GRILLES, DIFFUSERS, AND REGISTERS SHALL BE COMPLETE WITH FRAMES WITH RUBBER GASKETS SUITABLE FOR THE AREA AND WALL CONSTRUCTION WHERE SHOWN ON THE DRAWINGS.
- B. FINISH FOR ALL REGISTERS, DIFFUSERS, GRILLES, ETC., SHALL BE WHITE UNLESS OTHERWISE SELECTED BY THE OWNER. APPROVED MANUFACTURERS FOR ALL AIR DISTRIBUTION PRODUCTS SHALL BE PRICE INDUSTRIES, NAILOR, METAL AIR, TUTTLE & BAILEY, J&J, CARNES, HART AND COOLEY, OR ANEMOSTAT.

NOTE: THE HVAC SYSTEM DESIGN IS BASED ON THE MARVAIR, GREENHECK AND AIRLITE BRANDS. OTHER ENGINEER APPROVED EQUIVALENTS UNITS MAY BE USED PROVIDED THE CONTRACTOR FURNISHES ENGINEERED DESIGN OR THE EQUIVALENT UNITS AND RECEIVES ENGINEER APPROVAL BEFORE BIDDING.

PART 3 – EXECUTION

03-230500 COMMON WORK RESULTS FOR HVAC

- A. SCHEDULE A REPRESENTATIVE OF THE OWNER TO BE PRESENT WHEN TEST ON HVAC SYSTEMS ARE CONDUCTED.

03-230053 INSTALLATION REQUIREMENTS

- A. PROVIDE A MINIMUM CLEARANCE OF 30” OR MORE AT ALL EQUIPMENT. CODE REQUIRED CLEARANCE SHALL TAKE PRECEDENCE.
- B. INSTALL ALL EQUIPMENT WITH CLEARANCES TO PERMIT DISASSEMBLY FOR MAINTENANCE PURPOSES.
- C. INSTALL ALL SYSTEMS SUCH THAT NO EQUIPMENT, DUCTWORK, CONDUIT, ETC. IS REQUIRED TO BE REMOVED TO SERVICE, REPAIR OR REPLACE EQUIPMENT.
- D. SCHEDULE ALL UTILITY SHUTDOWNS 7 DAYS IN ADVANCE.

03-230054 DISCREPANCIES

- A. IN THE EVENT OF DISCREPANCY, IMMEDIATELY NOTIFY THE OWNER.
- B. DO NOT PROCEED WITH INSTALLATION IN AREAS OF DISCREPANCY UNTIL ALL SUCH DISCREPANCIES HAVE BEEN FULLY RESOLVED. SEE SECTION 2.

03-230055 EQUIPMENT IDENTIFICATION

ALL MAJOR EQUIPMENT SHALL BEAR FIRMLY ATTACHED METAL NAMEPLATES WHICH STATE NAME OF MANUFACTURER, MODEL NUMBER, AND ELECTRICAL DATA.

03-230056 INITIAL LUBRICATION, ADJUSTING, AND FILLING SYSTEMS

BEFORE OPERATING ANY MECHANICAL SYSTEMS, EQUIPMENT BEARINGS SHALL BE LUBRICATED AND BOLTS, PULLEYS, AND OTHER MOVING PARTS CHECKED FOR ALIGNMENT AND TOLERANCES IN ACCORDANCE WITH MANUFACTURER'S OPERATING INSTRUCTIONS. VIBRATIONS AND NOISE SHALL BE SUPPRESSED.

03-230057 CLEANING OF EQUIPMENT, MATERIALS, AND PREMISES

EQUIPMENT WILL BE SMOOTHLY PAINTED AND CLEAN, READY FOR PAINTERS. CLEAN ENTIRE PREMISES OF UNUSED MATERIALS, RUBBISH, DEBRIS, GREASE SPOTS, AND DIRT LEFT BY SUBCONTRACTOR.

03-20058 EQUIPMENT AND MATERIAL

INSTALL PER MANUFACTURER'S RECOMMENDATIONS.

03-230059 ACCESSIBILITY

INSTALL WORK READILY ACCESSIBLE FOR NORMAL OPERATION, READING OF INSTRUMENTS, ADJUSTMENT, SERVICE, INSPECTION,AND REPAIR. PROVIDE ACCESS PANELS WHERE INDICATED AND REQUIRED. ACCESS PANELS SHALL BE THE RESPONSIBILITY OF RESPECTIVE SUBCONTRACTORS.

03-230800 HVAC START-UP AND PERFORMANCE VERIFICATION.

- A. THE CONTRACTOR SHALL START-UP AND COMPLETELY VERIFY PERFORMANCE AND OPERATION PRIOR TO NOTIFYING THE ENGINEER OF SUBSTANTIAL COMPLETION.

03-230900 BUILDING AUTOMATION SYSTEM

THE AIR HANDLERS SHALL BE CONTROLLED BY THE FACTORY SUPPLIED COMMSTAT CONTROLS AND SHALL OPERATE BASED ON ONE TEMPERATURE SENSOR LOCATED IN THE ROOM. THE UNIT SHALL MODULATE TO MAINTAIN A MAXIMUM OF 75 DEG F IN COOLING AND A MINIMUM OF 55 DEG F IN HEATING MODE.

THE FANS SHALL BE CONNECTED TO AND CONTROLLED BY A CENTRAL STAND ALONE CONTROLLER THAT IS CAPABLE OF THE FOLLOWING SEQUENCES:

- A. THE PUMP ROOM ECONOMIZER FANS SHALL ENERGIZE AND THE ASSOCIATED MOTORIZED DAMPERS SHALL OPEN WHEN THE OUTSIDE AIR TEMPERATURE IS BETWEEN 50 DEGREES F AND 70 DEGREES F AND THE PUMP ROOM AIR TEMPERATURE IS ABOVE 72 DEGREES F. THE PUMP ROOM ECONOMIZER FANS SHALL DE-ENERGIZE AND THE ASSOCIATED MOTORIZED DAMPER SHALL CLOSE WHEN THE OUTSIDE AIR TEMPERATURE IS GREATER THAN 70 DEGREES F OR LESS THAN 50 DEGREES F OR THE PUMP ROOM AIR TEMPERATURE IS BELOW 65 DEGREES F.
- B. THE VENTILATION FANS SHALL RUN FOR 10 MINUTES EVERY HALF HOUR.

1		09-13-23
REV NO.	COMMENT	DATE
Professional Engineer (Mechanical) Kip P. Harris 9087 Date WYOMING SUNRISE ENGINEERING 47 EAST 4TH AVENUE AFTON, WYOMING 83110 TEL 307.885.8500 · FAX 307.885.8501 www.sunrise-eng.com		
GR-RS-SWC JPWB		
CROSSROADS PUMP STATION		
MECHANICAL SPECIFICATIONS		
SEE NO. 07265	DESIGNED JJ	DRAWN DB
CHECKED RV	SHEET NO. 74 of 99	M4

KEYED NOTES

1.

AH CONTROL PANEL LOCATION. SEE SPECIFICATIONS.

2.


OUTSIDE AIR TEMPERATURE SENSOR. PROVIDE AND INSTALL SUN SHADE.

3.

VENTILATION FAN TIMER.

4.

ECONOMIZER CONTROL LOCATION.

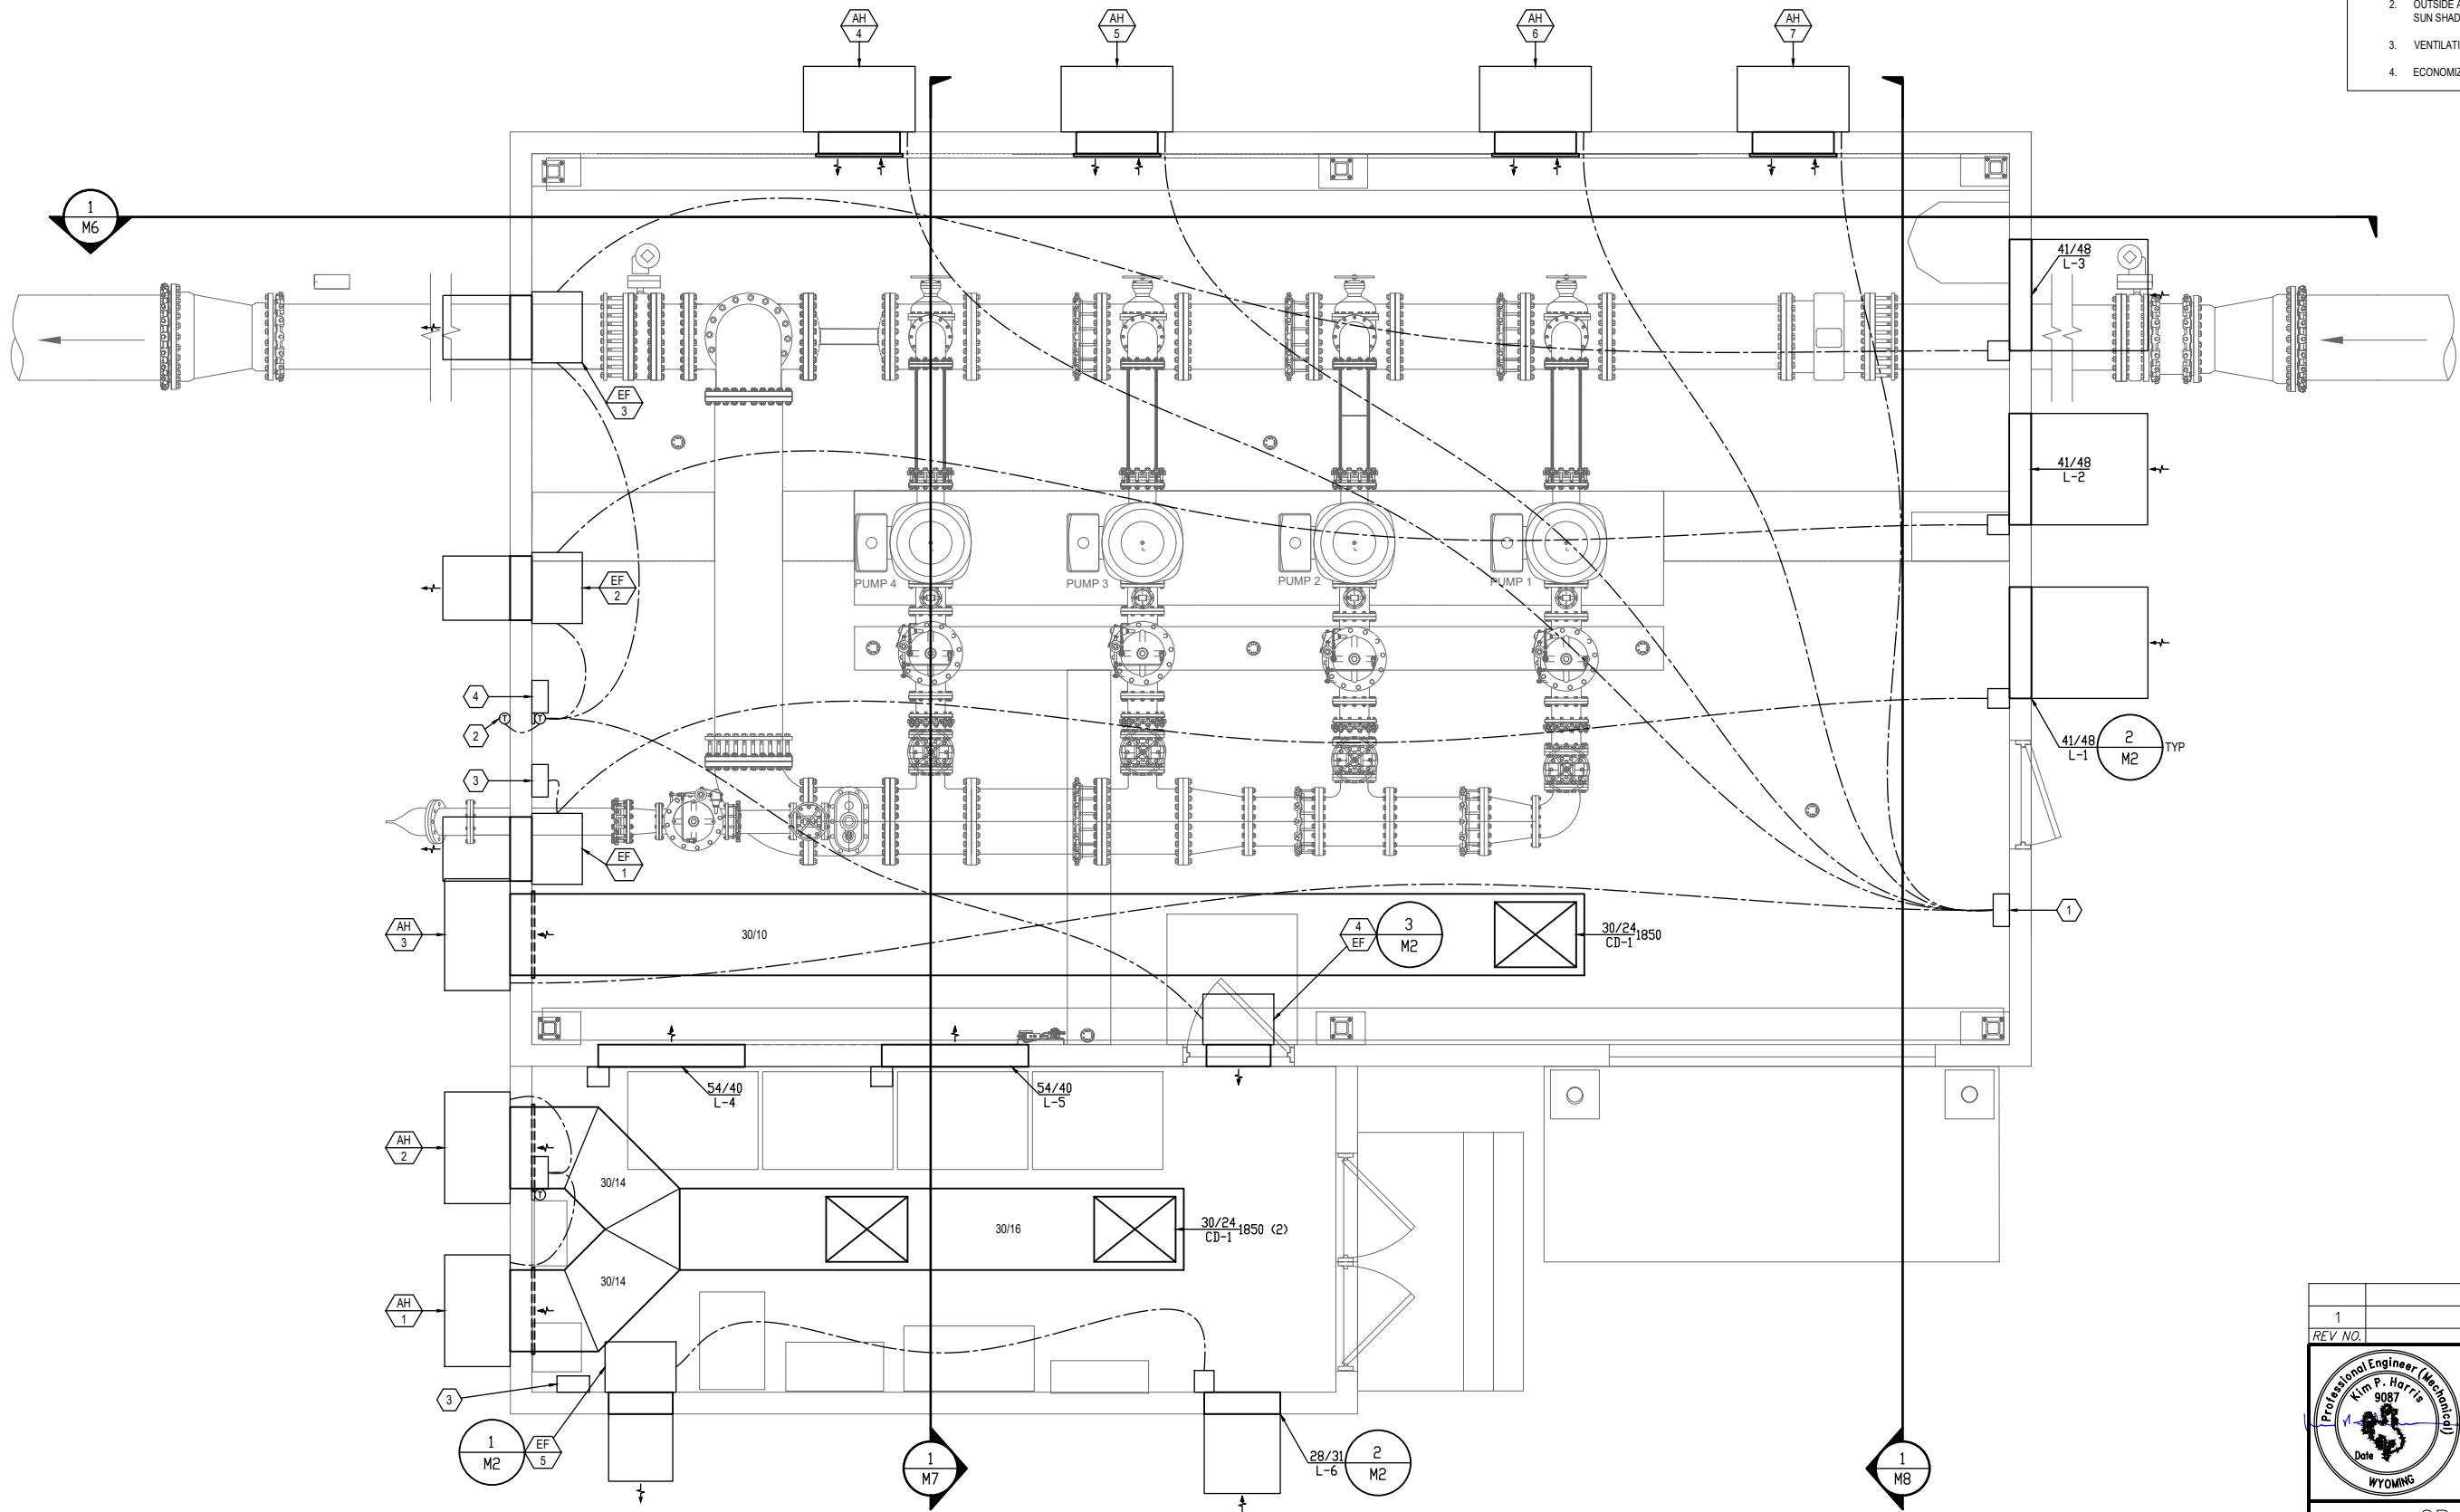

1


M5

MECHANICAL PLAN


3/8" = 1' - 0"


1		09-13-23
REV. NO.	COMMENT	DATE
Professional Engineer (Mechanical) Kim P. Harris 9087 WYOMING SUNRISE ENGINEERING 47 EAST 4TH AVENUE AFTON, WYOMING 83110 TEL 307.885.8500 · FAX 307.885.8501 www.sunrise-eng.com		
GR-RS-SWC JPWB		
CROSSROADS PUMP STATION		
MECHANICAL PLAN		
SEI NO.	DESIGNED	DRAWN
07265	JJ	DB
CHECKED	SHEET NO.	
RV	75 of 99	
		M5

X:\20000\20376 Crossroads Pump Station\01_Cadd\MEP_Mechanical\20376_M5--dwg Sep 13, 2023 2:51pm jfall

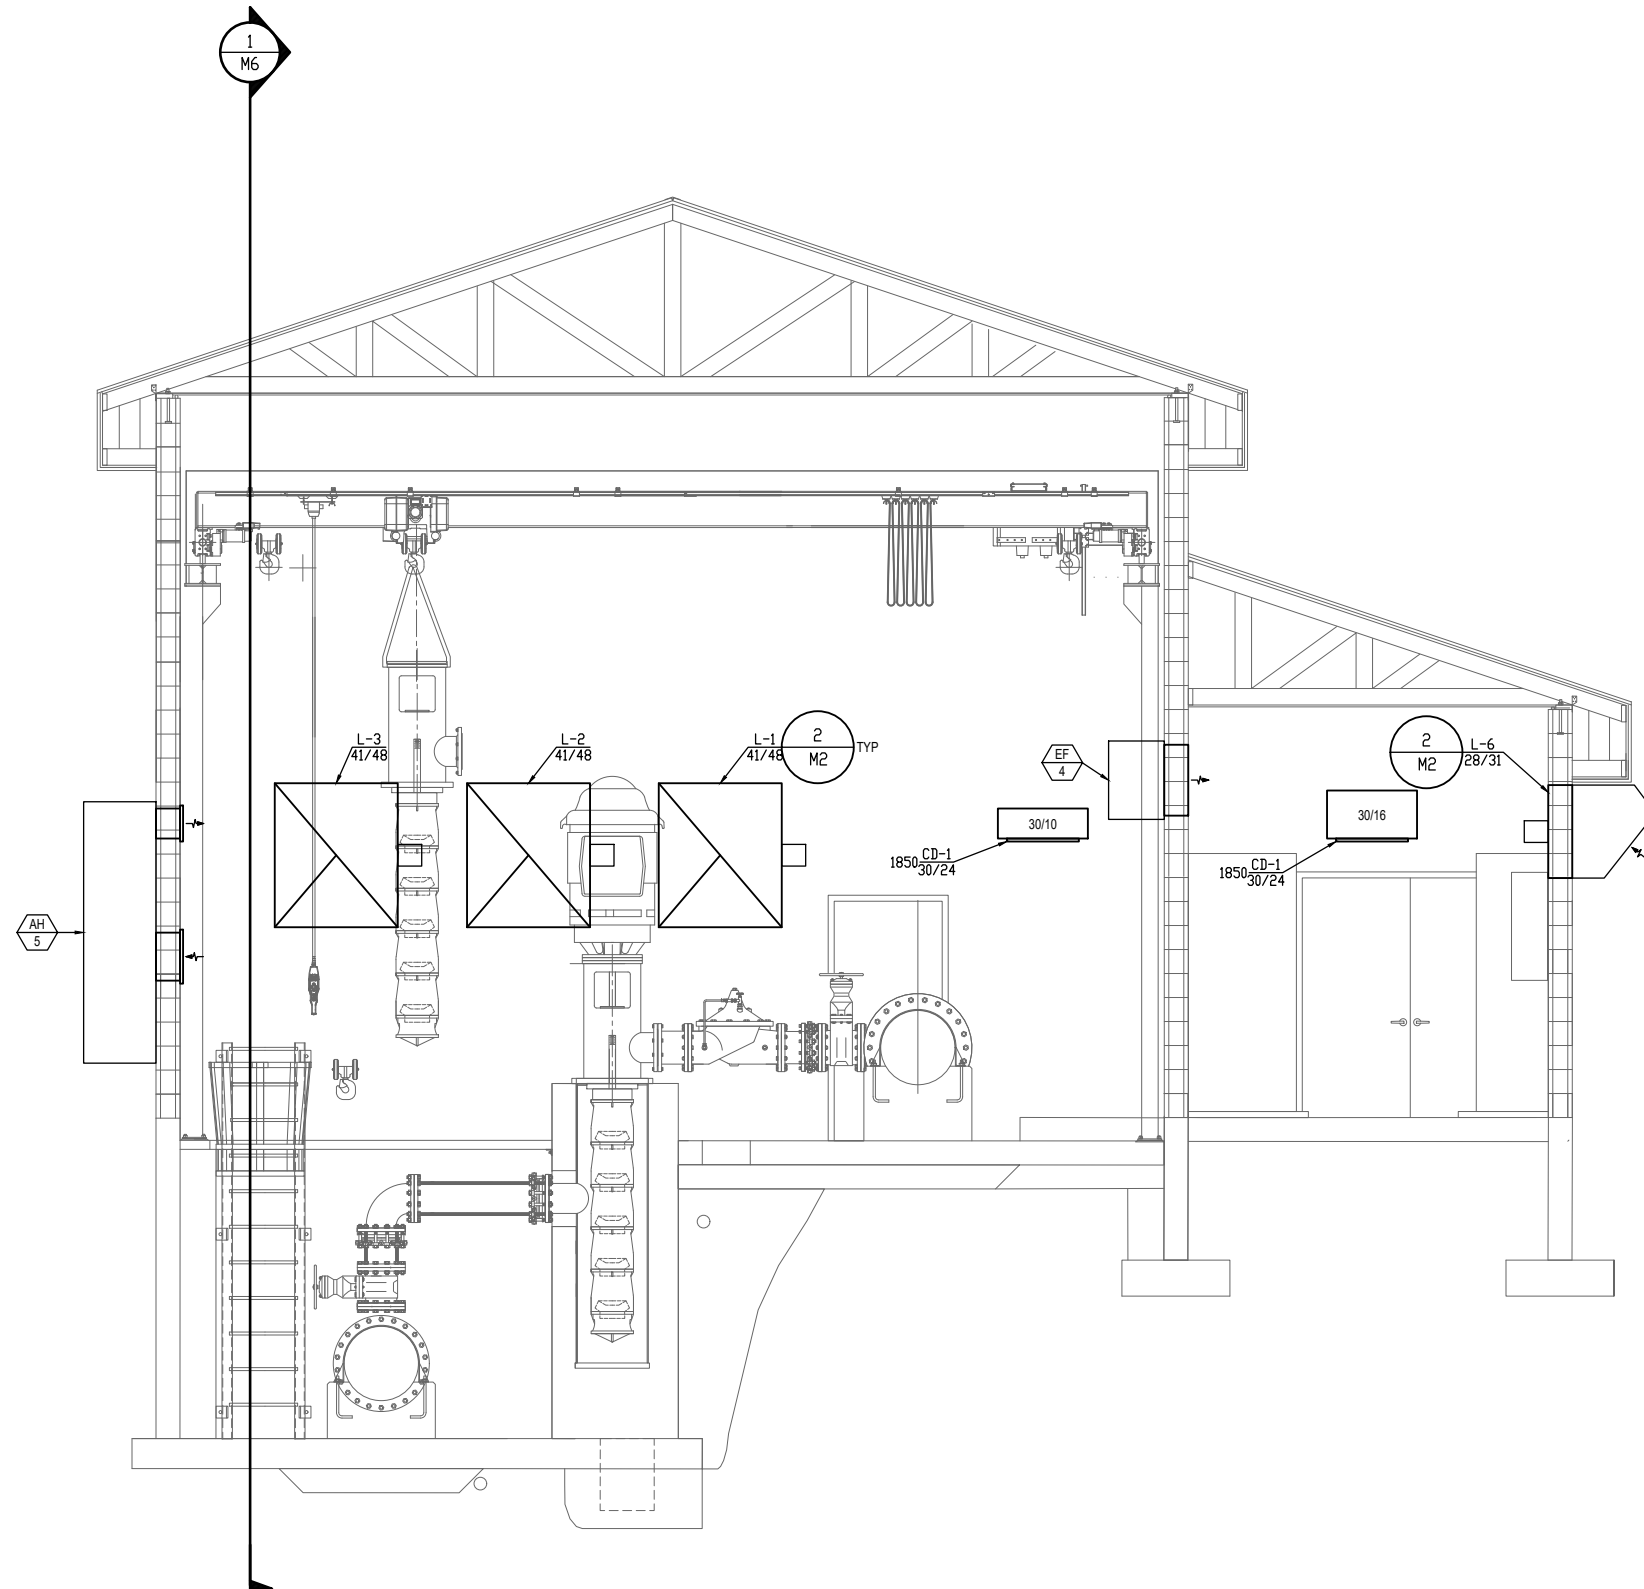


1 EAST MECHANICAL SECTION
3/8" = 1' - 0"

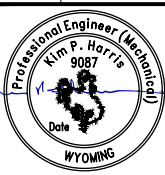
1					09-13-23
REV NO.		COMMENT			DATE
		 SUNRISE ENGINEERING			
		47 EAST 4TH AVENUE AFTON, WYOMING 83110 TEL 307.885.8500 · FAX 307.885.8501 www.sunrise-eng.com			
GR-RS-SWC JPWB					
CROSSROADS PUMP STATION					
MECHANICAL SECTION					
SEI NO. 07265	DESIGNED JJ	DRAWN DB	CHECKED RV	SHEET NO. 77 of 99	M7

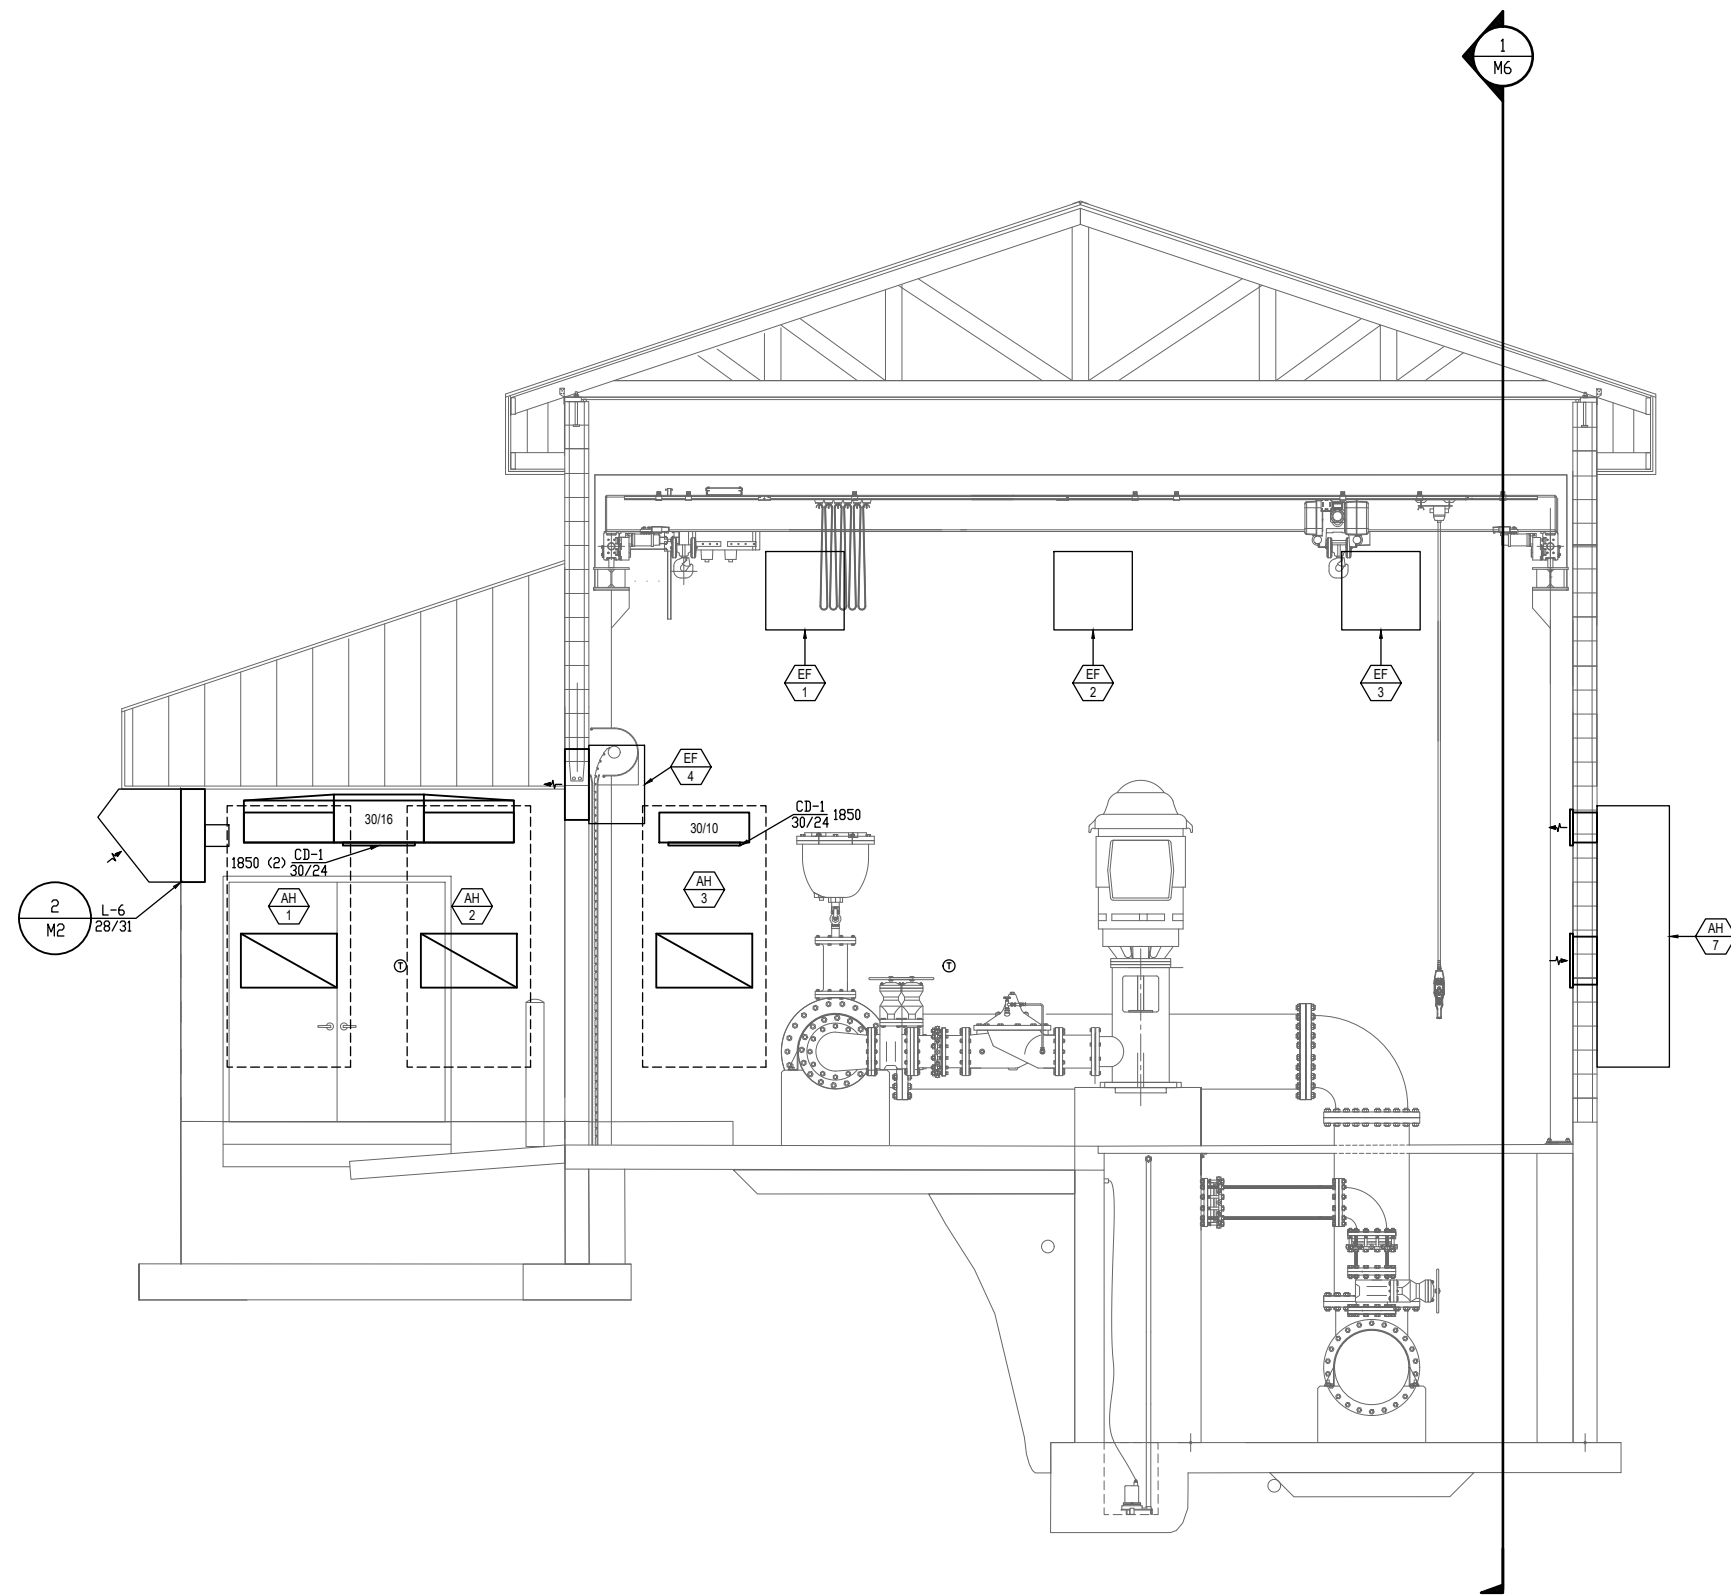

1 WEST MECHANICAL SECTION
M8 3/8" = 1' - 0"

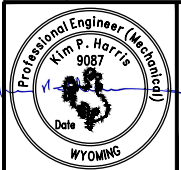1		09-13-23
REV. NO.	COMMENT	DATE
 SUNRISE ENGINEERING 47 EAST 4TH AVENUE AFTON, WYOMING 83110 TEL 307.885.8500 · FAX 307.885.8501 www.sunrise-eng.com GR-RS-SWC JPWB CROSSROADS PUMP STATION MECHANICAL SECTION		
SEI NO. 07265	DESIGNED JJ	DRAWN DB
CHECKED RV	SHEET NO. 78 of 99	M8


X:\20000\20376 Crossroads Pump Station\01_Cadd\MEP_Mechanical\20376_M5-.dwg Sep 13, 2023 2:51pm jfall

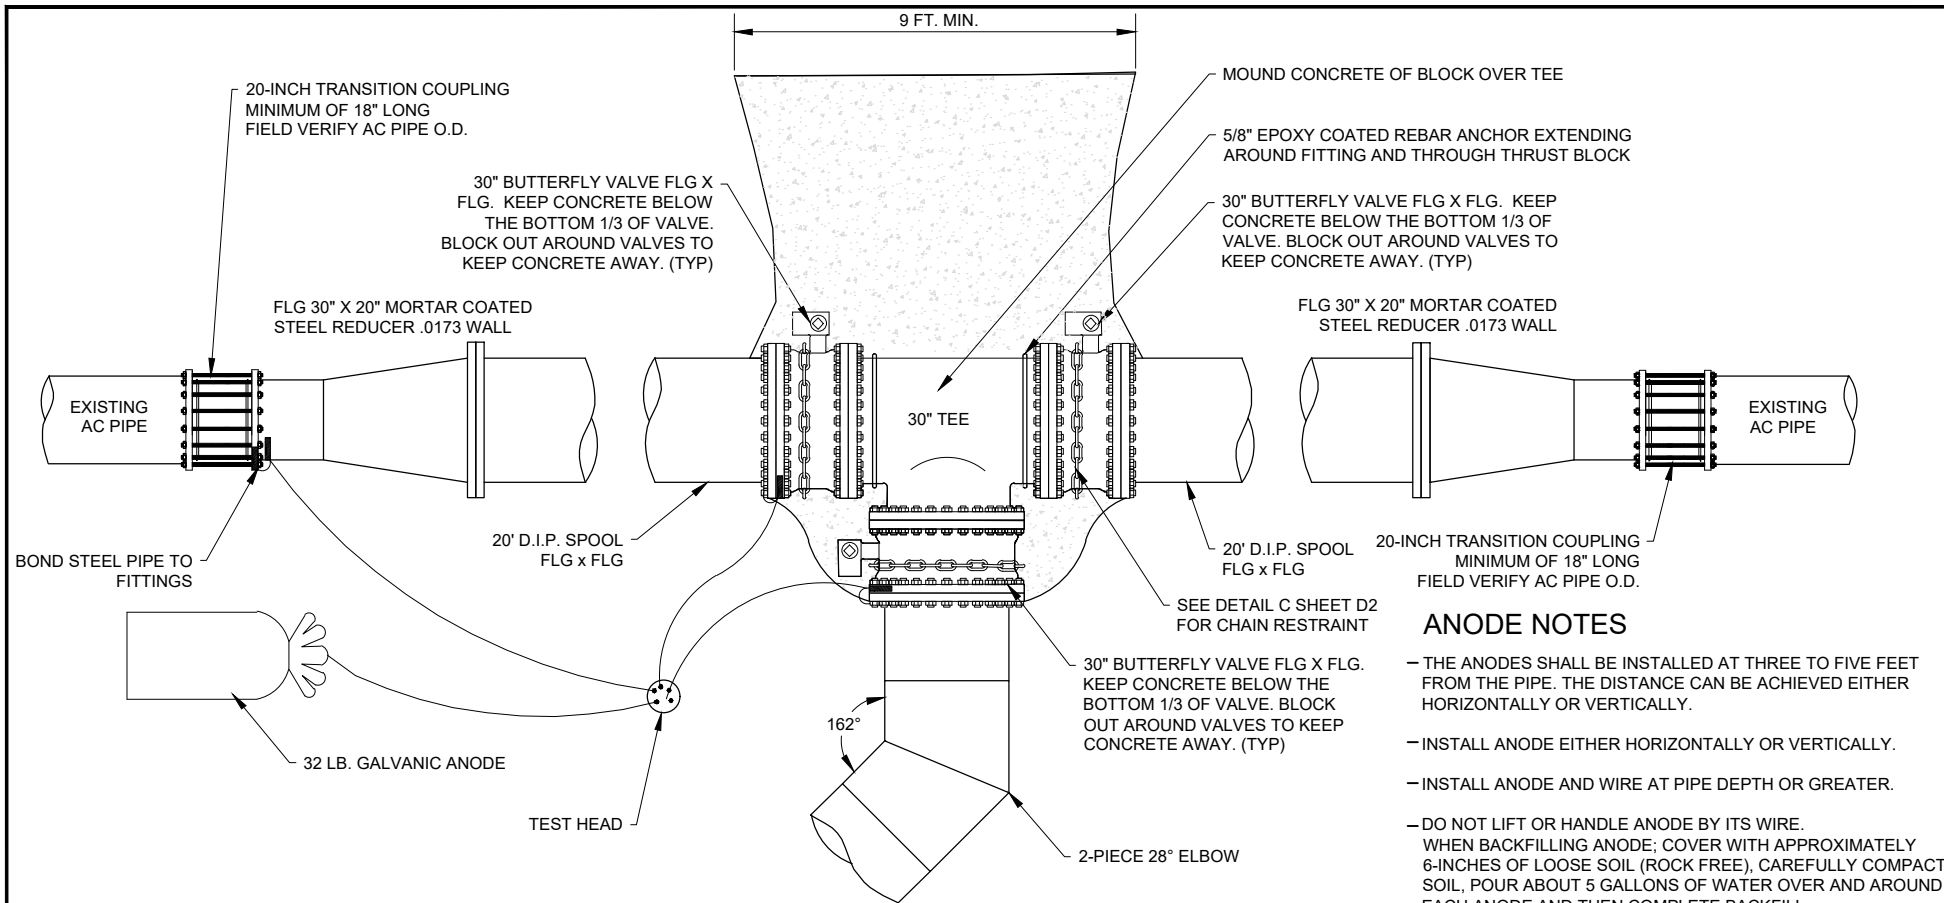

A TIE TO EXISTING 20" AC PIPE
TYPICAL DETAIL


THRUST BLOCK NOTES

- THRUST BLOCK SHALL EXTEND TO PROVIDE 70 SQUARE FEET OF BEARING AREA AGAINST VERTICAL PROJECTION OF TRENCH WALL.
- THRUST BLOCK SHALL EXTEND FULLY UNDER THE 30" TEE WITH A DEPTH OF AT LEAST 12" OVER UNDISTURBED EARTH.
- THRUST BLOCK SHALL EXTEND TO TOP OF TEE BEFORE RISING TO WARD THE TRENCH WALL.
- SIDES OF THRUST BLOCK SHALL BE FORMED TO CREATE VERTICAL SIDES.
- 70 SQ. FT. THRUST BLOCK AREA BASED ON 150 PSI. TEST PRESSURE AND 1500 PSF SOIL BEARING CAPACITY. EXTENDS 3 FT. BELOW PIPE AT TRENCH WALL INTO UNDISTURBED SOIL.
- THRUST BLOCK CONCRETE SHALL HAVE A MINIMUM DESIGN COMPRESSIVE STRENGTH OF 2,500 PSI.

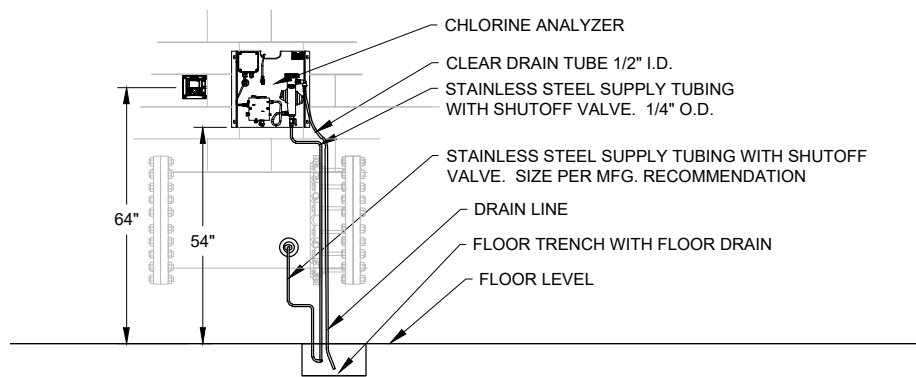


B CHLORINE ANALYZER MOUNT AND PIPING
TYPICAL DETAIL

NOTE:
ALL BURIED PIPELINE FITTINGS SHALL RECEIVE A PROTECTIVE TAPE WRAP OF WAX TAPE FOLLOWED BY A "GUARD WRAP" OVER THE WAX TAPE

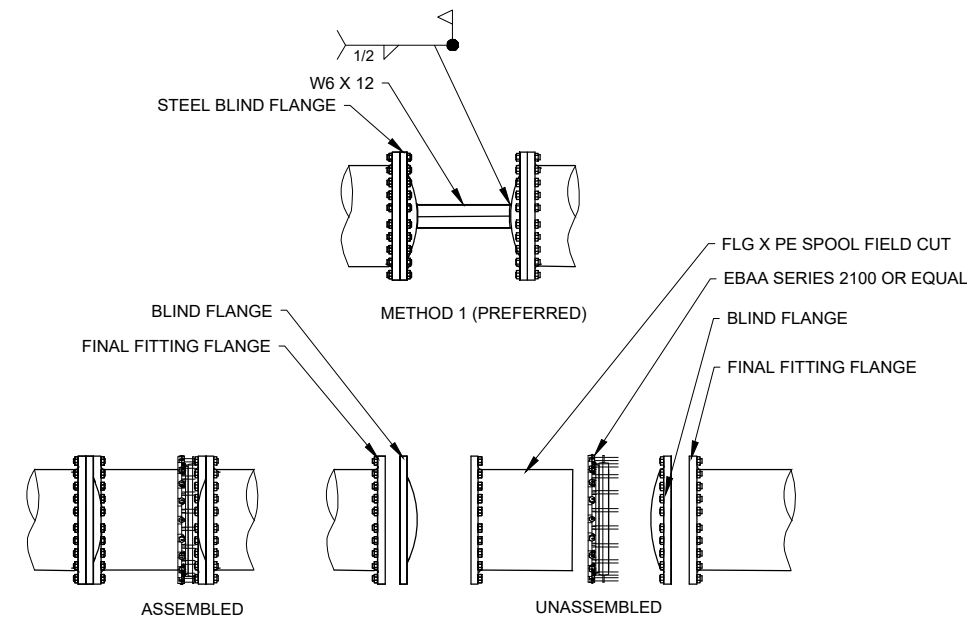


C BLIND FLANGE TO BLIND FLANGE RESTRAINT
TYPICAL DETAIL

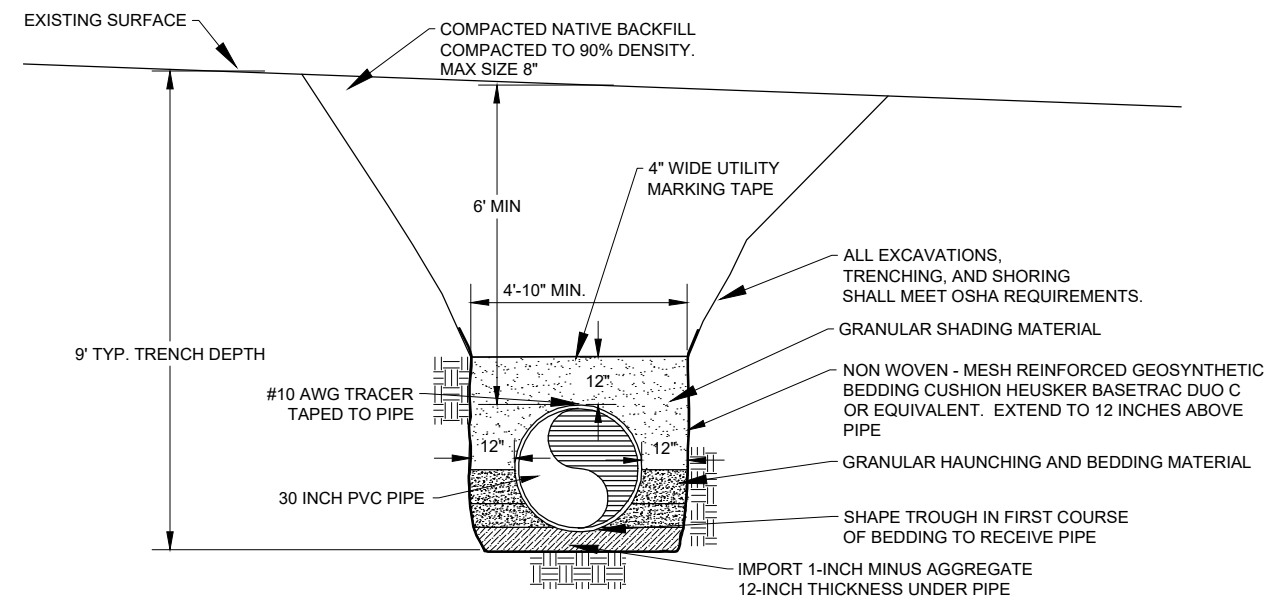

NOTE: THIS DETAIL IS ANTICIPATED TO BE REQUIRED AT THE FOLLOWING LOCATIONS:


STA. 18+50 TO 23+50
STA. 32+00 TO 35+00

E WEAK SOILS CROSSING
TYPICAL SECTION VIEW

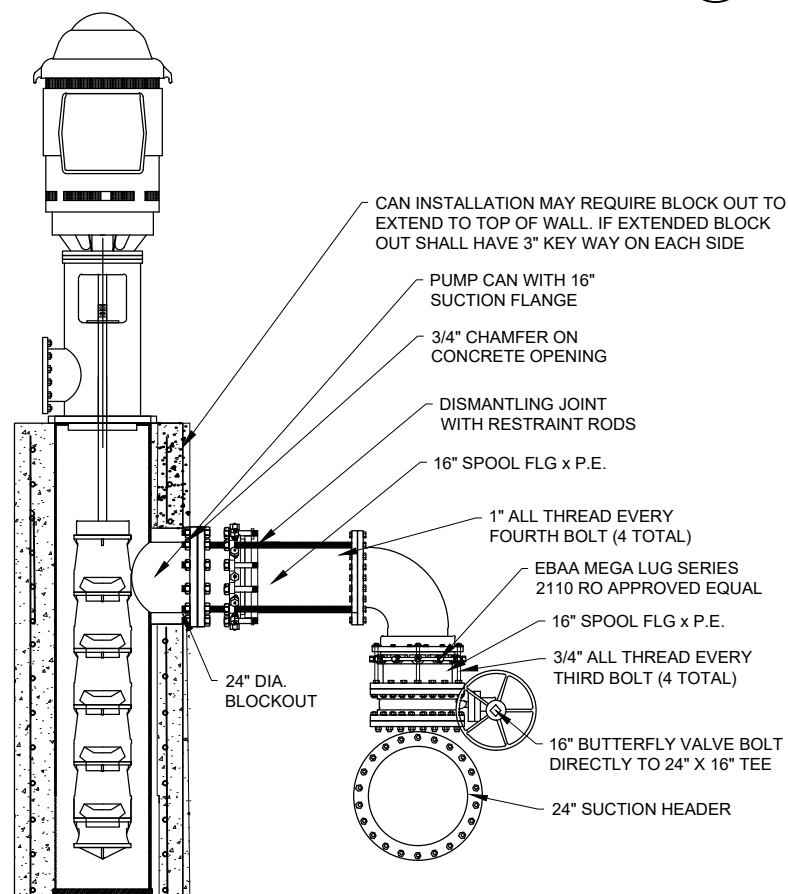

D SUCTION ELBOW RESTRAINT
TYPICAL ELEVATION VIEW

REV. NO.	COMMENT	DATE
SUNRISE ENGINEERING 770 S WASHINGTON ST. AFTON, WYOMING 83110 TEL 307.885.8500 · FAX 307.885.8501 www.sunrise-eng.com		
GR-RS-SC JPWB		
CROSSROADS PUMP STATION		
PIPING DETAILS		
SEI NO. 07265	DESIGNED FDK	DRAWN BJ
CHECKED JUL	SHEET NO. 79 of 99	D1

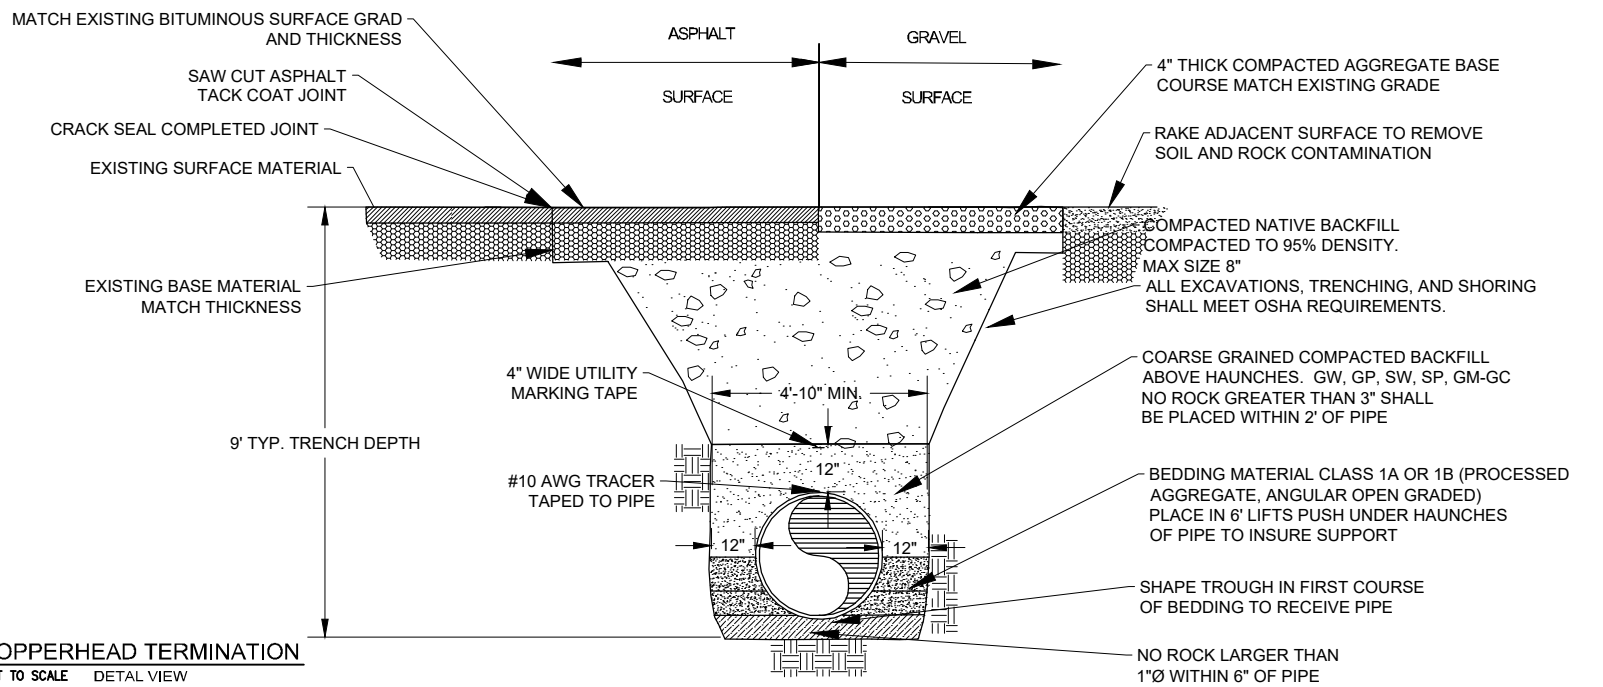

 COPPERHEAD TERMINATION
NOT TO SCALE DETAIL VIEW



NOTE:
1. ALL BOLTS SHALL BE STIANLESS STEEL

G VALVE COLLAR
D2 NOT TO SCALE PLAN V



2'-0"

SECTION - VALVE COLLAR

NOT TO SCALE

CONCRETE COLLAR

VALVE COLLAR
NOT TO SCALE PLAN VIEW

E SAMPLE TAP
~ TYPICAL DETAIL




- NOTES:
1. ALL TRACER WIRE TO BE IN 1-1/4" PVC CONDUIT ABOVE THE PIPE.
 2. TRACER WIRE SHALL BE 10 GAUGE COPPER WIRE WITH BLUE INSULATION RATED FOR DIRECT BURIAL. ALL WIRE CONNECTORS SHALL BE 3M DBR DIRECT BURY SPLICE OR CITY APPROVED EQUAL AND SHALL BE WATERTIGHT TO PROVIDE ELECTRICAL CONTINUITY.
 3. ALL TRACER WIRE SHALL BE TESTED FOR CONTINUITY IN THE PRESENCE OF A REPRESENTATIVE FROM CITY OF ROCK SPRINGS WATER PRIOR TO ASPHALT PLACEMENT. ANY TRACER WIRE FOUND NOT TO BE CONTINUOUS AFTER TESTING SHALL BE REPAIRED OR REPLACED AT THE CONTRACTOR'S EXPENSE PRIOR TO ASPHALT PLACEMENT.

REV NO.	COMMENT	DATE
 SUNRISE ENGINEERING		
770 S WASHINGTON ST. AFTON, WYOMING 83110 TEL 307.885.8500 - FAX 307.885.8501 www.sunrise-eng.com		
GR-RS-SC JPWB		
CROSSROADS PUMP STATION		
PIPING DETAILS		
SEI NO. 07265	DESIGNED FDK	DRAWN BJ
CHECKED JUL	SHEET NO. 80 of 99	D2

FOR THRUST RESTRAINT, CONTRACTOR SHALL USE EITHER "STARGRIP" AS MANUFACTURED BY STAR PIPE PRODUCTS OR MEGALUG AS MANUFACTURED BY EBAA IRON SALES INC, OR APPROVED EQUAL FOR THE ENTIRE PROJECT.

CONCRETE THRUST RESTRAINT SHOWN ON THIS SHEET ASSUMES THE FOLLOWING CONDITIONS:
SOIL TYPE: GM - SILTY GRAVEL, GRAVEL-SAND-SILT MIXTURE
BURIAL DEPTH: 4FT.
SAFETY FACTOR: 1.5
TEST PRESSURE: 150 PSI
TRENCH TYPE: PIPE BEDDED IN COMPACTED GRANULAR MATERIAL TO THE CENTER LINE OF PIPE, 4" MIN. UNDER PIPE. COMPACTED GRANULAR OR SELECT MATERIAL TO TOP OF PIPE. (APPROX. 90% STANDARD PROCTOR, AASHTO T-99)
THE CONTRACTOR IS RESPONSIBLE TO VERIFY THAT THESE CONDITION ARE MEET OR EXCEEDED. IN THE EVENT THE SOILS ARE WEAKER, THE BLOCK SIZE SHALL BE PROPORTIONATELY INCREASED.

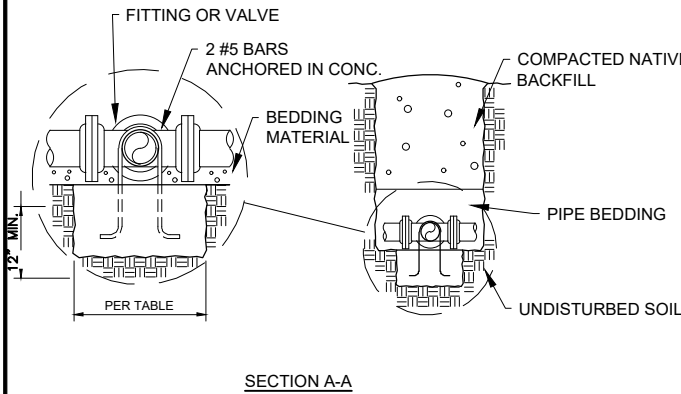

Bearing Pressure		1500	psi								
Test Pressure		200	psi								
Safety Factor		1.5	psi								
Thrust Block Areas		Cross	TEE	Wye	Dead End	Valve	90 deg bend	45 deg bend	22.5 deg bend	11.25 deg bend	
4	0.087266	2.4	1.7	1.7	1.7		2.4	1.3	1.0	1.0	
6	0.19635	5.4	3.8	3.8	3.8		5.4	2.9	1.5	1.0	
8	0.349066	9.5	6.8	6.8	6.8		9.5	5.2	2.6	1.3	
10	0.545415	14.9	10.6	10.6	10.6		14.9	8.1	4.1	2.1	
12	0.785398	21.5	15.2	15.2	15.2	15.2	21.5	11.6	5.9	3.0	
14	1.069014	29.2	20.7	20.7	20.7	20.7	29.2	15.8	8.1	4.1	
16	1.396263	38.2	27.0	27.0	27.0	27.0	38.2	20.7	10.5	5.3	
18	1.767146	48.3	34.2	34.2	34.2	34.2	48.3	26.2	13.3	6.7	
20	2.181662	59.7	42.2	42.2	42.2	42.2	59.7	31.7	16.5	8.3	
24	3.141593	85.9	60.8	60.8	60.8	60.8	85.9	46.5	23.7	11.9	
30	4.908739	134.2	95.0	95.0	95.0	95.0	134.2	72.7	37.0	18.7	
36	7.068583	193.2	136.8	136.8	136.8	136.8	193.2	104.6	53.3	26.9	
Bearing Pressure		2000	psi								
Test Pressure		150	psi								
Safety Factor		1.5	psi								
Thrust Block Areas		Cross	TEE	Wye	Dead End	Valve	90 deg bend	45 deg bend	22.5 deg bend	11.25 deg bend	
4	0.087266	1.3	1.0	1.0	1.0		1.3	0.7	1.0	1.0	
6	0.19635	3.0	2.1	2.1	2.1		3.0	1.6	0.8	1.0	
8	0.349066	5.4	3.8	3.8	3.8		5.4	2.9	1.5	0.7	
10	0.545415	8.4	5.9	5.9	5.9		8.4	4.5	2.3	1.2	
12	0.785398	12.1	8.6	8.6	8.6	8.6	12.1	6.5	3.3	1.7	
14	1.069014	16.4	11.6	11.6	11.6	11.6	16.4	8.9	4.5	2.3	
16	1.396263	21.5	15.2	15.2	15.2	15.2	21.5	11.6	5.9	3.0	
18	1.767146	27.2	19.2	19.2	19.2	19.2	27.2	14.7	7.5	3.8	
20	2.181662	33.5	23.8	23.8	23.8	23.8	33.5	18.2	9.3	4.7	
24	3.141593	48.3	34.2	34.2	34.2	34.2	48.3	26.2	13.3	6.7	
30	4.908739	75.5	53.4	53.4	53.4	53.4	75.5	40.9	20.8	10.5	
36	7.068583	108.7	77.0	77.0	77.0	77.0	108.7	58.9	30.0	15.1	

NOTE
FOR TWO WAY FLOW, SUCH AS FOUND IN DISTRIBUTION SYSTEMS, USE
L₁ ON BOTH SIDES OF FITTING.

NOTES:

1. ALL JOINTS WITHIN THE "L" DISTANCE SHALL BE RESTRAINED

* = FOR THIS CONDITION NEED ONLY RESTRAIN THE OUTLETS OF TEE

NOTES:

1. RESTRAIN THE THREE MECHANICAL JOINTS ON THE TEE.
2. ALL JOINTS WITHIN THE "L" DISTANCE ON THE BRANCH SIDE OF TEE SHALL BE RESTRAINED AND ALL JOINTS WITHIN 20' ON THE RUN SIDE OF THE TEE SHALL BE RESTRAINED.

NOTES:

1. ALL JOINTS WITHIN THE "L" DISTANCE SHALL BE RESTRAINED

NOTES:

1. ALL JOINTS WITHIN THE "L" DISTANCE SHALL BE RESTRAINED

NOTES:

1. ALL JOINTS WITHIN THE "L" DISTANCE SHALL BE RESTRAINED.

* = FOR THIS CONDITION NEED ONLY RESTRAIN THE OUTLETS OF TREE

NOTES:

 
 
 
 
 
1. RESTRAIN THE THREE MECHANICAL JOINTS ON THE TEE.
2. ALL JOINTS WITHIN THE "L" DISTANCE ON THE BRANCH SIDE OF TEE SHALL BE RESTRAINED AND ALL JOINTS WITHIN 18' ON THE RUN SIDE OF THE TEE SHALL BE RESTRAINED.

NOTES:


1. ALL JOINTS WITHIN THE "L" DISTANCE SHALL BE RESTRAINED

NOTES:


1. ALL JOINTS WITHIN THE "L" DISTANCE SHALL BE RESTRAINED




REV NO.	COMMENT			DATE
	 SUNRISE ENGINEERING			
	770 S WASHINGTON ST. AFTON, WYOMING 83110 TEL 307.885.8500 • FAX 307.885.8501 www.sunrise-eng.com			
GR-RS-SC JPWB				
CROSSROADS PUMP STATION				
PIPING DETAILS				
SET NO. 07265	DESIGNED FDK	DRAWN BJ	CHECKED JLL	SHEET NO. 81 of 99 D3

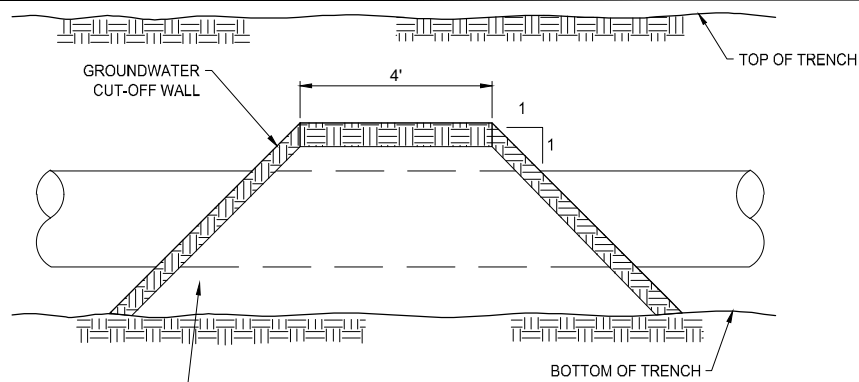

- NOTES:
1. CONSTRUCT 4' THICK CUTOFF WALL TO REPLACE PIPE ZONE AND BEDDING MATERIAL. MATERIAL TO BE CONTROLLED LOW STRENGTH MATERIAL (CLSM) OR SAND AND 20 LB BENTONITE CLAY PER CUBIC YARD OR COHESIVE SOIL WITH NO LESS THAN 20% PASSING A NO. 200 SIEVE AND HAVING A PLASTICITY INDEX GREATER THAN 10 OR APPROVED EQUAL.
 2. CUT OFF WALL TO EXTEND 1' WIDER THAN TRENCH WIDTH ON EACH SIDE.

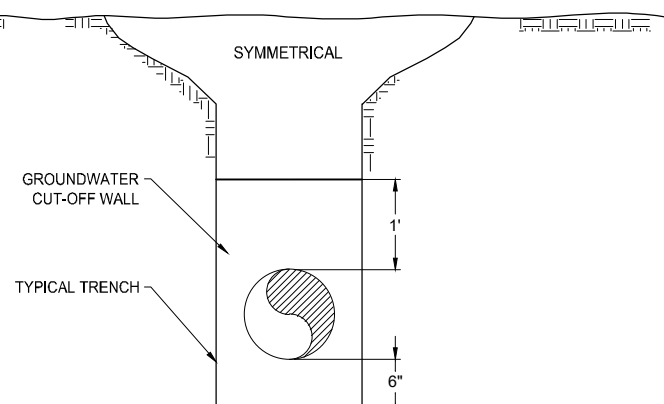


A CLAY CUT-OFF WALL
NOT TO SCALE DETAIL

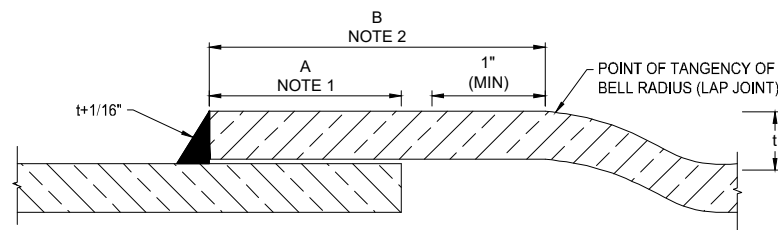


- NOTES:
1. DIMENSION "A" CORRESPONDS TO THE COMPLETED JOINT OVERLAP AFTER WELDING. DIMENSION "A" SHALL BE THE GREATER OF 1" OR 3t, MINIMUM.
 2. FOR STANDARD JOINTS, THE MINIMUM DIMENSION "B" SHALL BE AS REQUIRED TO PROVIDE THE MINIMUM OVERLAP DIMENSION "A" AND MAINTAIN THE INDICATED HOLDBACK FOR THE WELD.
 3. CLEARANCE BETWEEN FAYING SURFACES OF LAP JOINTS SHALL NOT EXCEED 1/8 IN AT ANY LOCATION FOR FILLET WELDS ON PIPE HAVING WALL THICKNESS LESS THAN OR EQUAL TO 5/16 IN, AND CLEARANCE BETWEEN FAYING SURFACES OF LAP JOINTS SHALL NOT EXCEED 3/16 IN AT ANY LOCATION FOR FILLET WELDS ON PIPE HAVING WALL THICKNESS GREATER THAN 5/16 IN.
 4. FILLET WELDS FOR BELL AND SPIGOT LAP JOINTS SHOWN. FILLET WELDS ON OTHER JOINTS ARE SIMILAR.
 5. THE JOINTS SHALL BE FABRICATED AND INSTALLED TO BE WITHIN THE TOLERANCES INDICATED. THE TOLERANCE REQUIREMENTS SHALL APPLY TO BOTH WELDS AND TO BOTH STRAIGHT AND DEFLECTION JOINTS.

B SINGLE-WELDED LAP JOINT - I
NOT TO SCALE DETAIL

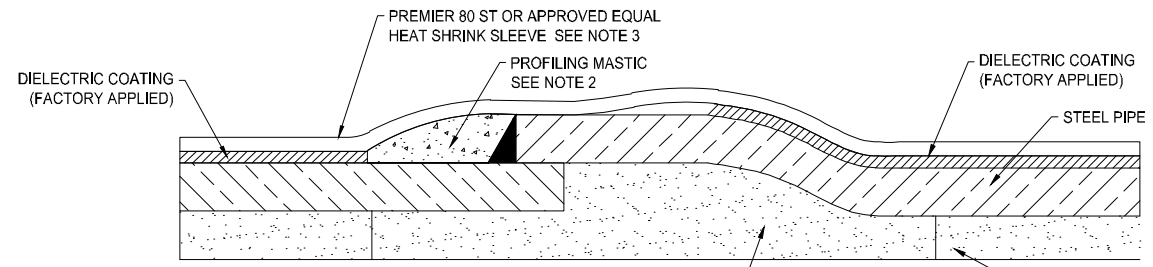

- NOTES:
1. SHOP APPLIED CEMENT MORTAR LINING SHOWN. MINIMUM LINING THICKNESS SHALL BE 3/8".
 2. FILL PRO PM-GP PROFILING MASTIC, OR APPROVED EQUAL
 3. HEAT SHRINK SLEEVE SHALL EXTEND 3" ONTO FACTORY COATING.

C SINGLE-WELDED LAP JOINT COATING TREATMENT
NOT TO SCALE DETAIL

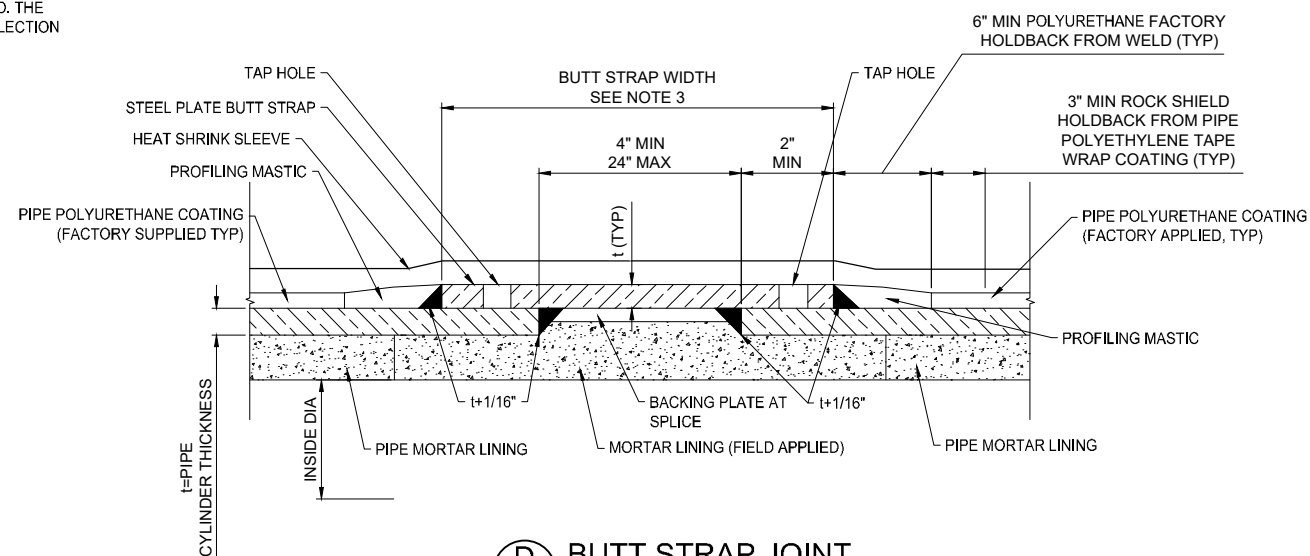


D BUTT STRAP JOINT
NOT TO SCALE DETAIL

- NOTES:
1. CONTRACTOR SHALL CONDUCT AN AIR/SOAP SOLUTION LEAK TEST AT 40 PSI AIR PRESSURE IN ADDITION TO DYE PENETRANT OR MAGNETIC PARTICLE TESTING PERFORMED BY THE CONSTRUCTION MANAGER. IF LEAKS ARE DETECTED, REPAIR AND RETEST THE WELDS UNTIL THERE ARE NO DEFECTS. PLUG HOLES WITH A WELDED PLUG AT COMPLETION OF TEST AND COAT AS SHOWN. TAP HOLES MAY BE ON INSIDE OR OUTSIDE OF JOINT.
 2. UNLESS OTHERWISE NOTED, BUTT STRAP WIDTH SHALL BE A MINIMUM OF 6".
 3. PROFILING MASTIC SHALL BE FILL PRO PM-GP OR APPROVED EQUAL.

C COPPERHEAD TERMINATION
NOT TO SCALE DETAL VIEW




G VALVE COLLAR
NOT TO SCALE PLAN VIEW

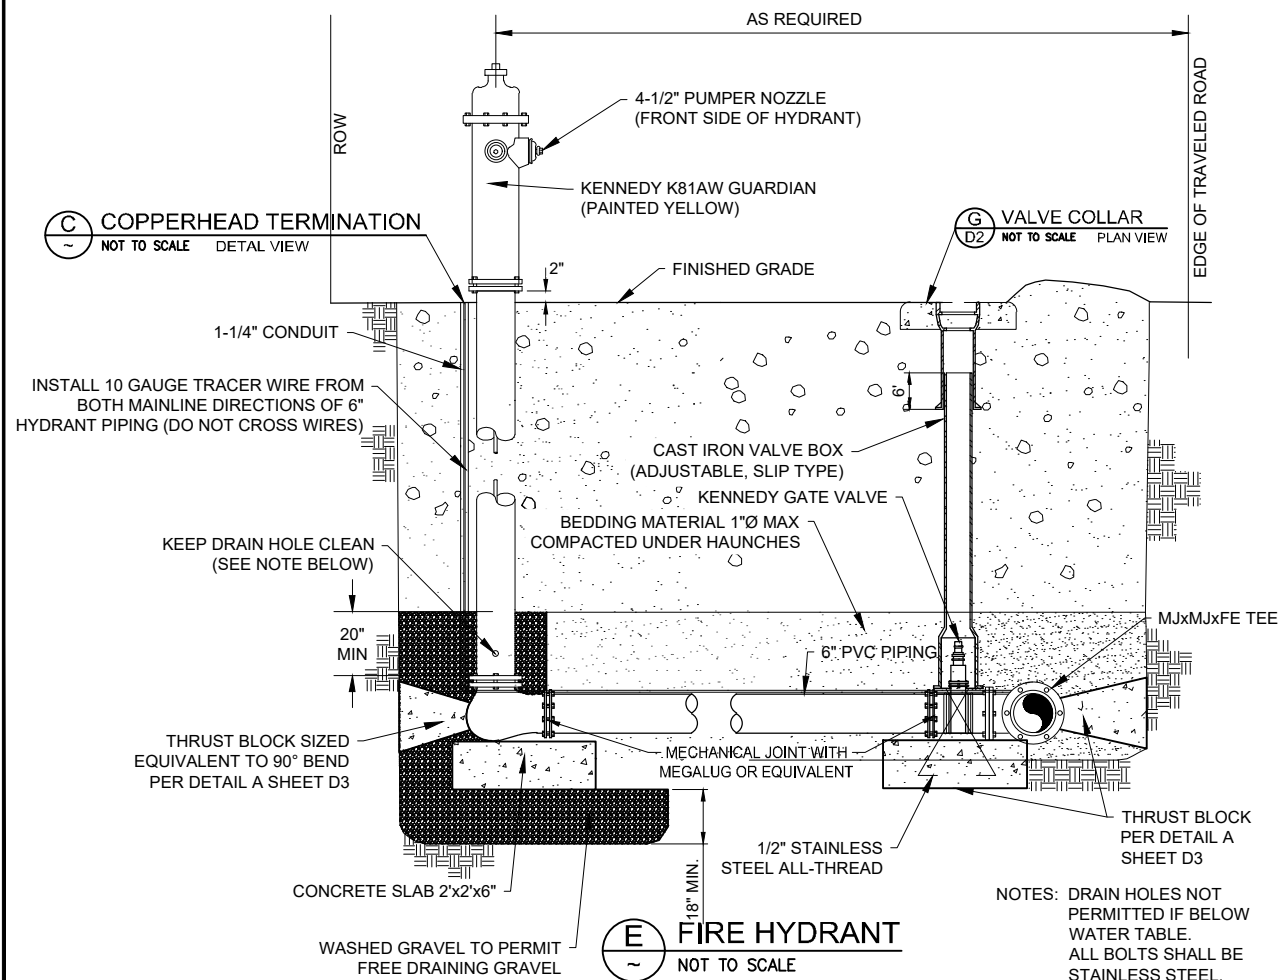

E FIRE HYDRANT
NOT TO SCALE

- NOTES: DRAIN HOLES NOT PERMITTED IF BELOW WATER TABLE. ALL BOLTS SHALL BE STAINLESS STEEL.

REV. NO.	COMMENT	DATE
SUNRISE ENGINEERING 770 S WASHINGTON ST. AFTON, WYOMING 83110 TEL 307.885.8500 · FAX 307.885.8501 www.sunrise-eng.com		
GR-RS-SC JPWB		
CROSSROADS PUMP STATION		
PIPING DETAILS		
SEI NO. 07265	DESIGNED FDK	DRAWN BJ
CHECKED JUL	SHEET NO. 83 of 99	D5

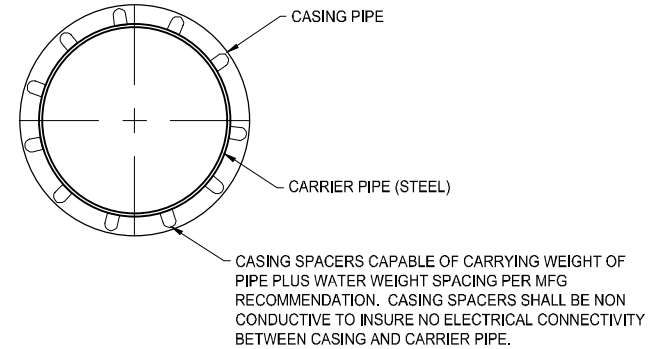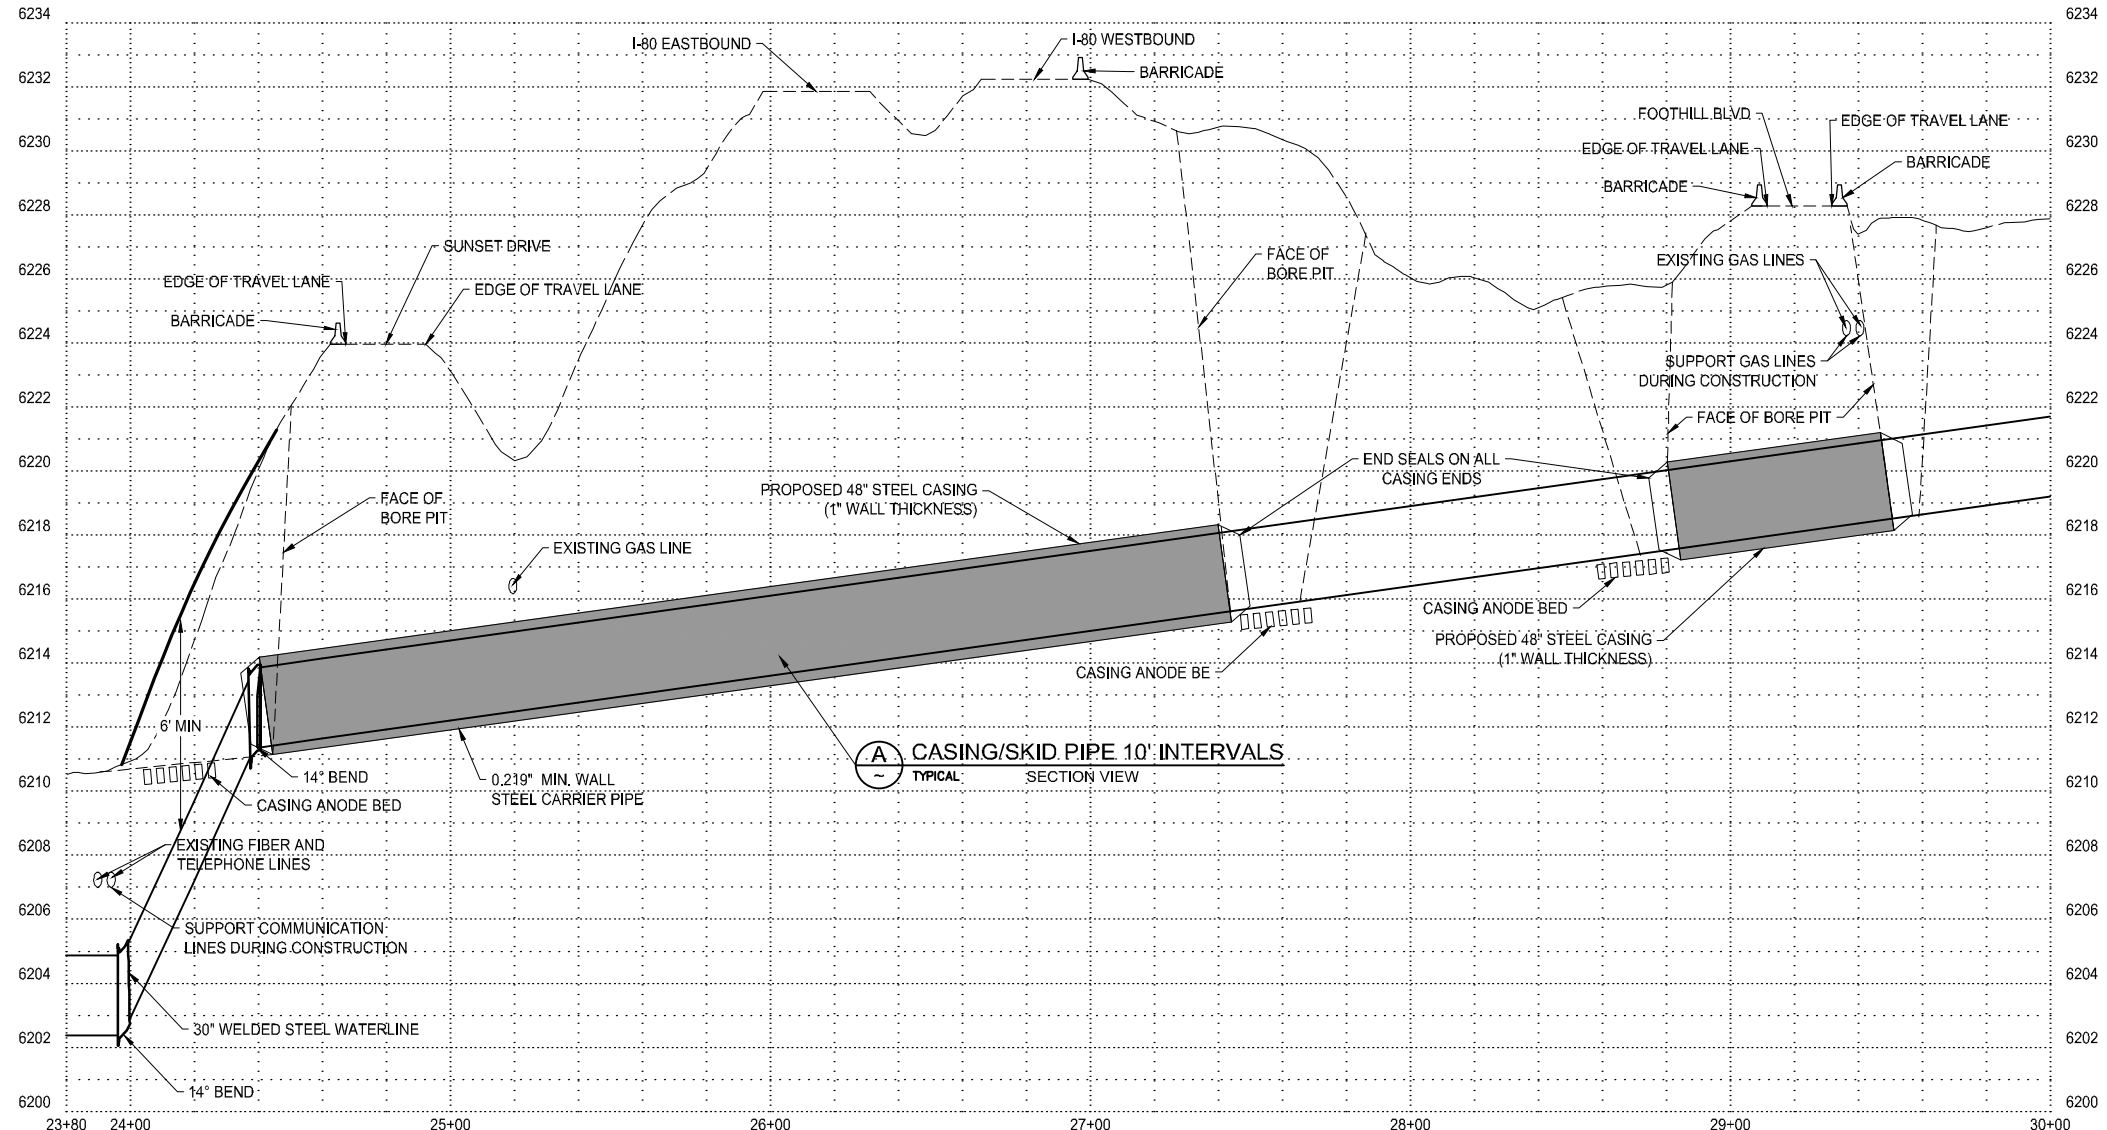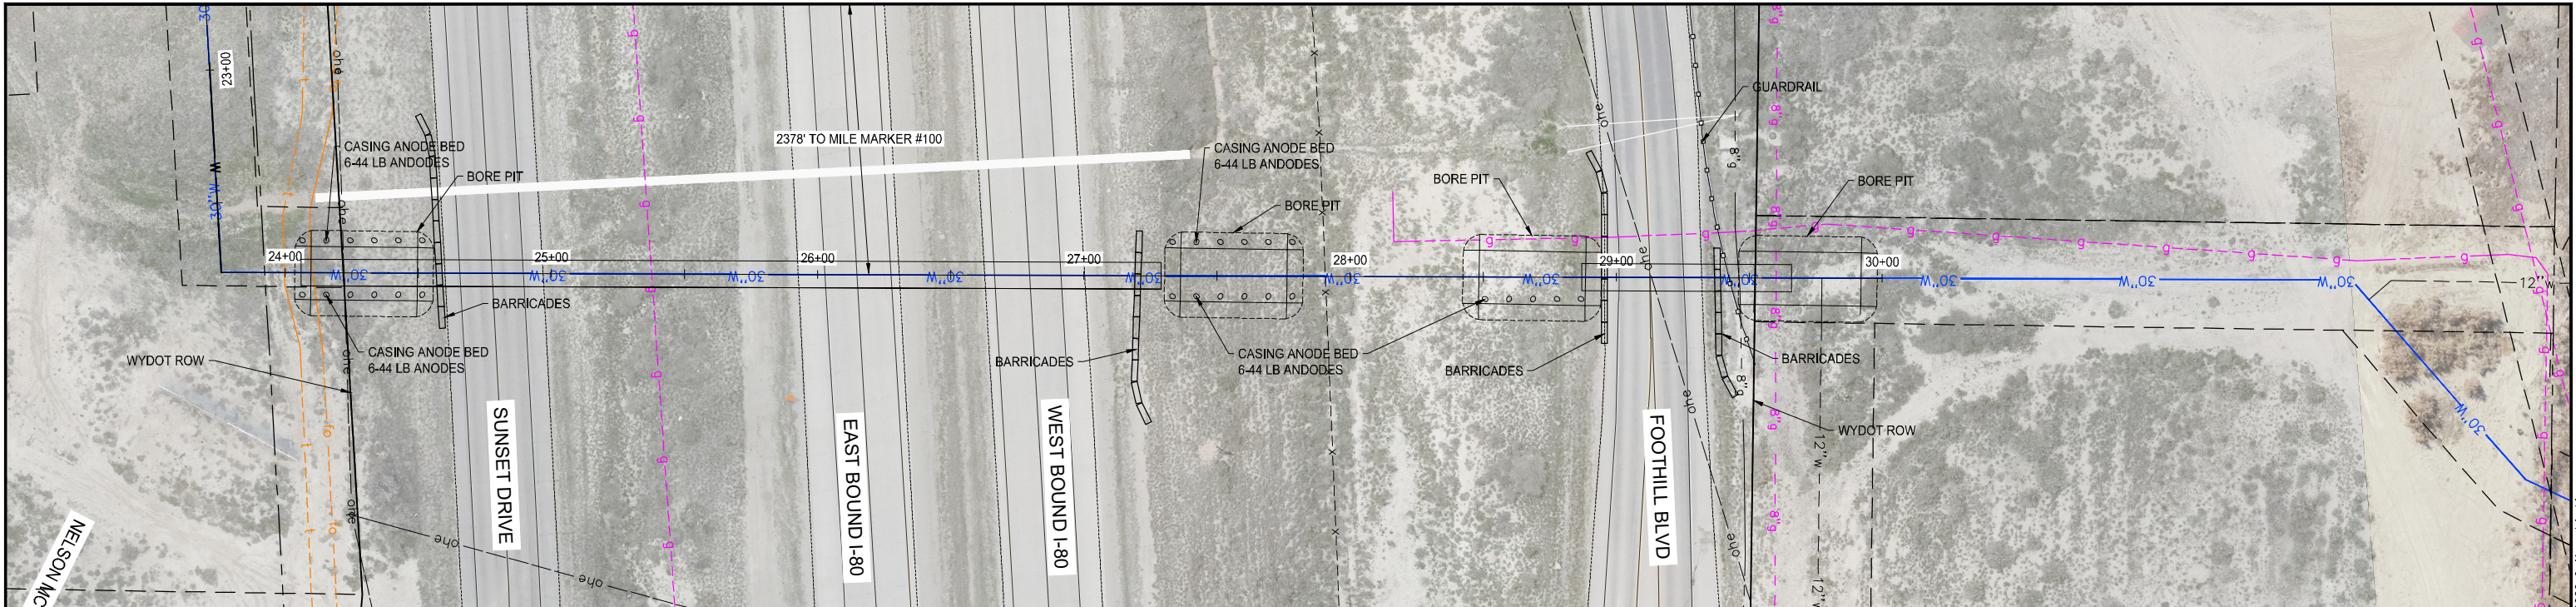

A CASING/SKID PIPE 10' INTERVALS
TYPICAL SECTION VIEW


NOTE:
1. ALL WORK SHALL COMPLY WITH WYDOT ROW LICENSE INCLUDED IN PROJECT DOCUMENTS

SCALE
0 30' 60'
HORIZ: 1" = 60'

811 Know what's below.
Call before you dig.
1-800-849-2476

REV. NO.	COMMENT	DATE
 SUNRISE ENGINEERING		
770 S WASHINGTON ST. AFTON, WYOMING 83110 TEL 307.885.8500 · FAX 307.885.8501 www.sunrise-eng.com		
GR-RS-SC JPWB		
CROSSROADS PUMP STATION I-80 PIPELINE CROSSING PLAN AND PROFILE		
SEI NO. 07265	DESIGNED FDK	DRAWN BJ
CHECKED JUL	SHEET NO. 84 of 99	D6

P:\VWDC GR-RS-SC JPWB Cross Roads Pump Station Level III (S07265)\Dwg CSD\Civil\Waterline\Plan & Profile.dwg Feb 13, 2026 9:41am bjenkins

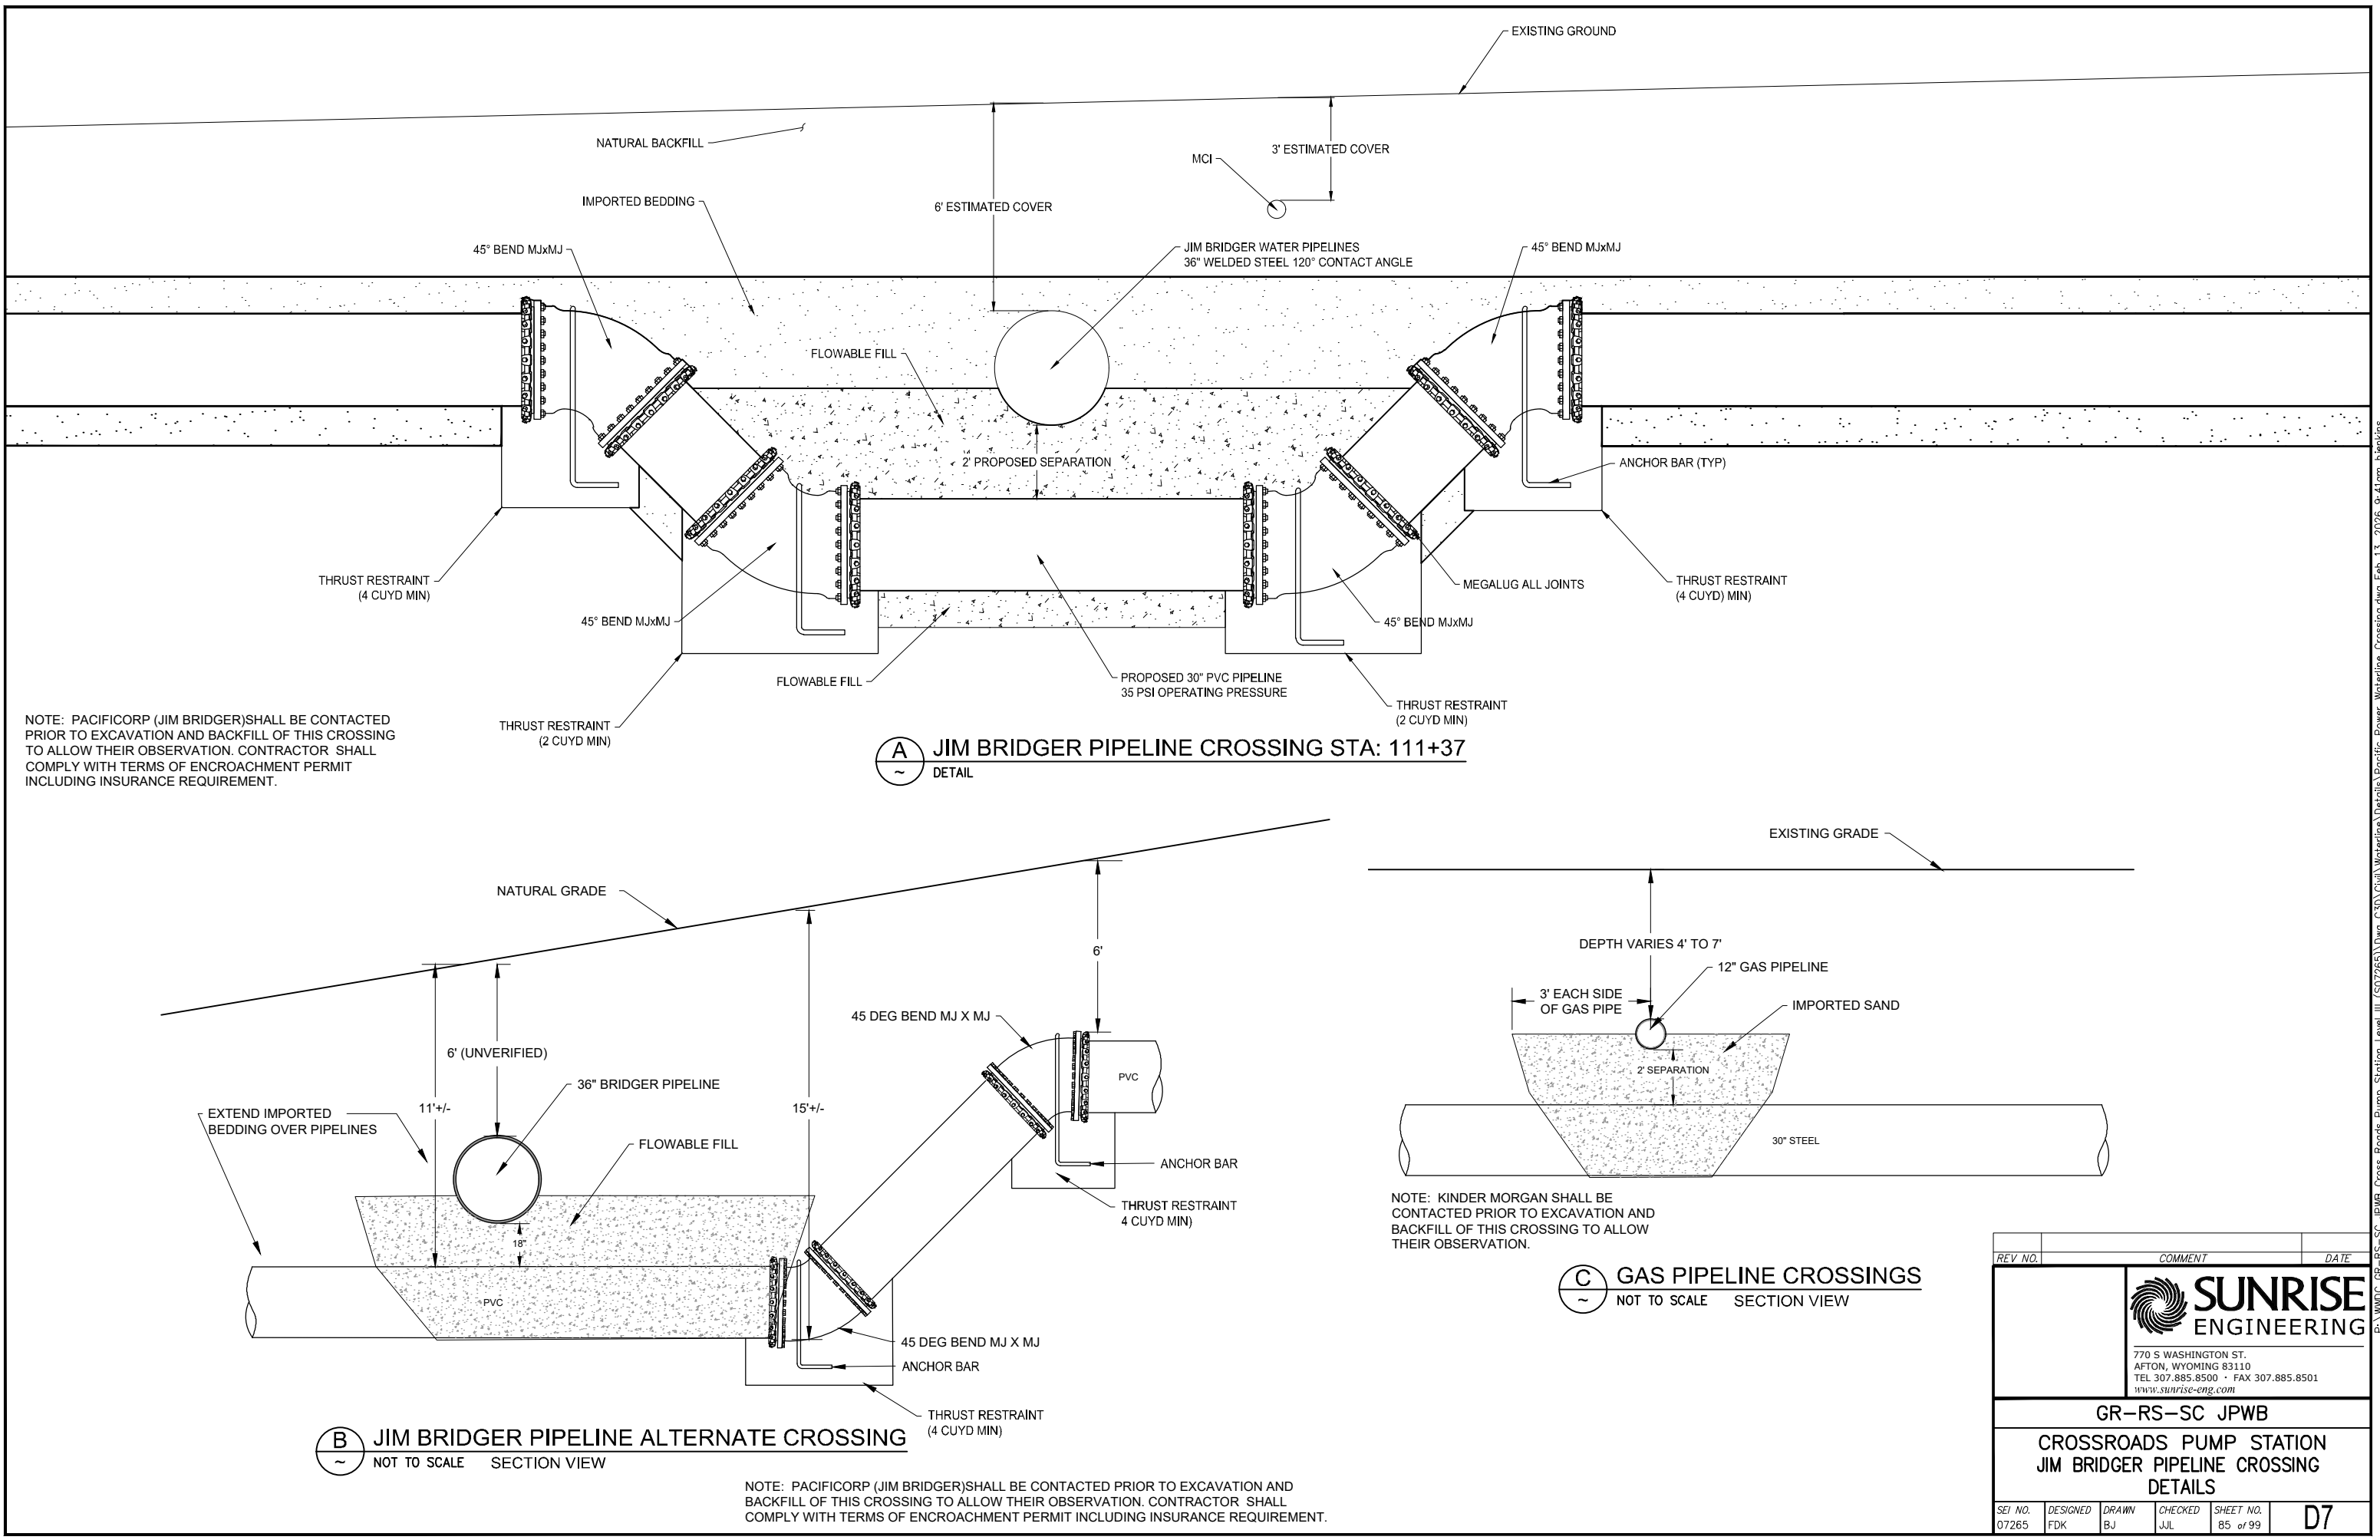

NOTE: PACIFICORP (JIM BRIDGER) SHALL BE CONTACTED PRIOR TO EXCAVATION AND BACKFILL OF THIS CROSSING TO ALLOW THEIR OBSERVATION. CONTRACTOR SHALL COMPLY WITH TERMS OF ENCROACHMENT PERMIT INCLUDING INSURANCE REQUIREMENT.

A JIM BRIDGER PIPELINE CROSSING STA: 111+37
~
DETAIL


B JIM BRIDGER PIPELINE ALTERNATE CROSSING
~
NOT TO SCALE SECTION VIEW

NOTE: PACIFICORP (JIM BRIDGER) SHALL BE CONTACTED PRIOR TO EXCAVATION AND BACKFILL OF THIS CROSSING TO ALLOW THEIR OBSERVATION. CONTRACTOR SHALL COMPLY WITH TERMS OF ENCROACHMENT PERMIT INCLUDING INSURANCE REQUIREMENT.


C GAS PIPELINE CROSSINGS
~
NOT TO SCALE SECTION VIEW

NOTE: KINDER MORGAN SHALL BE CONTACTED PRIOR TO EXCAVATION AND BACKFILL OF THIS CROSSING TO ALLOW THEIR OBSERVATION.


REV. NO.	COMMENT	DATE
SUNRISE ENGINEERING 770 S WASHINGTON ST. AFTON, WYOMING 83110 TEL 307.885.8500 • FAX 307.885.8501 www.sunrise-eng.com		
GR-RS-SC JPWB		
CROSSROADS PUMP STATION JIM BRIDGER PIPELINE CROSSING DETAILS		
SEI NO. 07265	DESIGNED FDK	DRAWN BJ
CHECKED JUL	SHEET NO. 85 of 99	D7

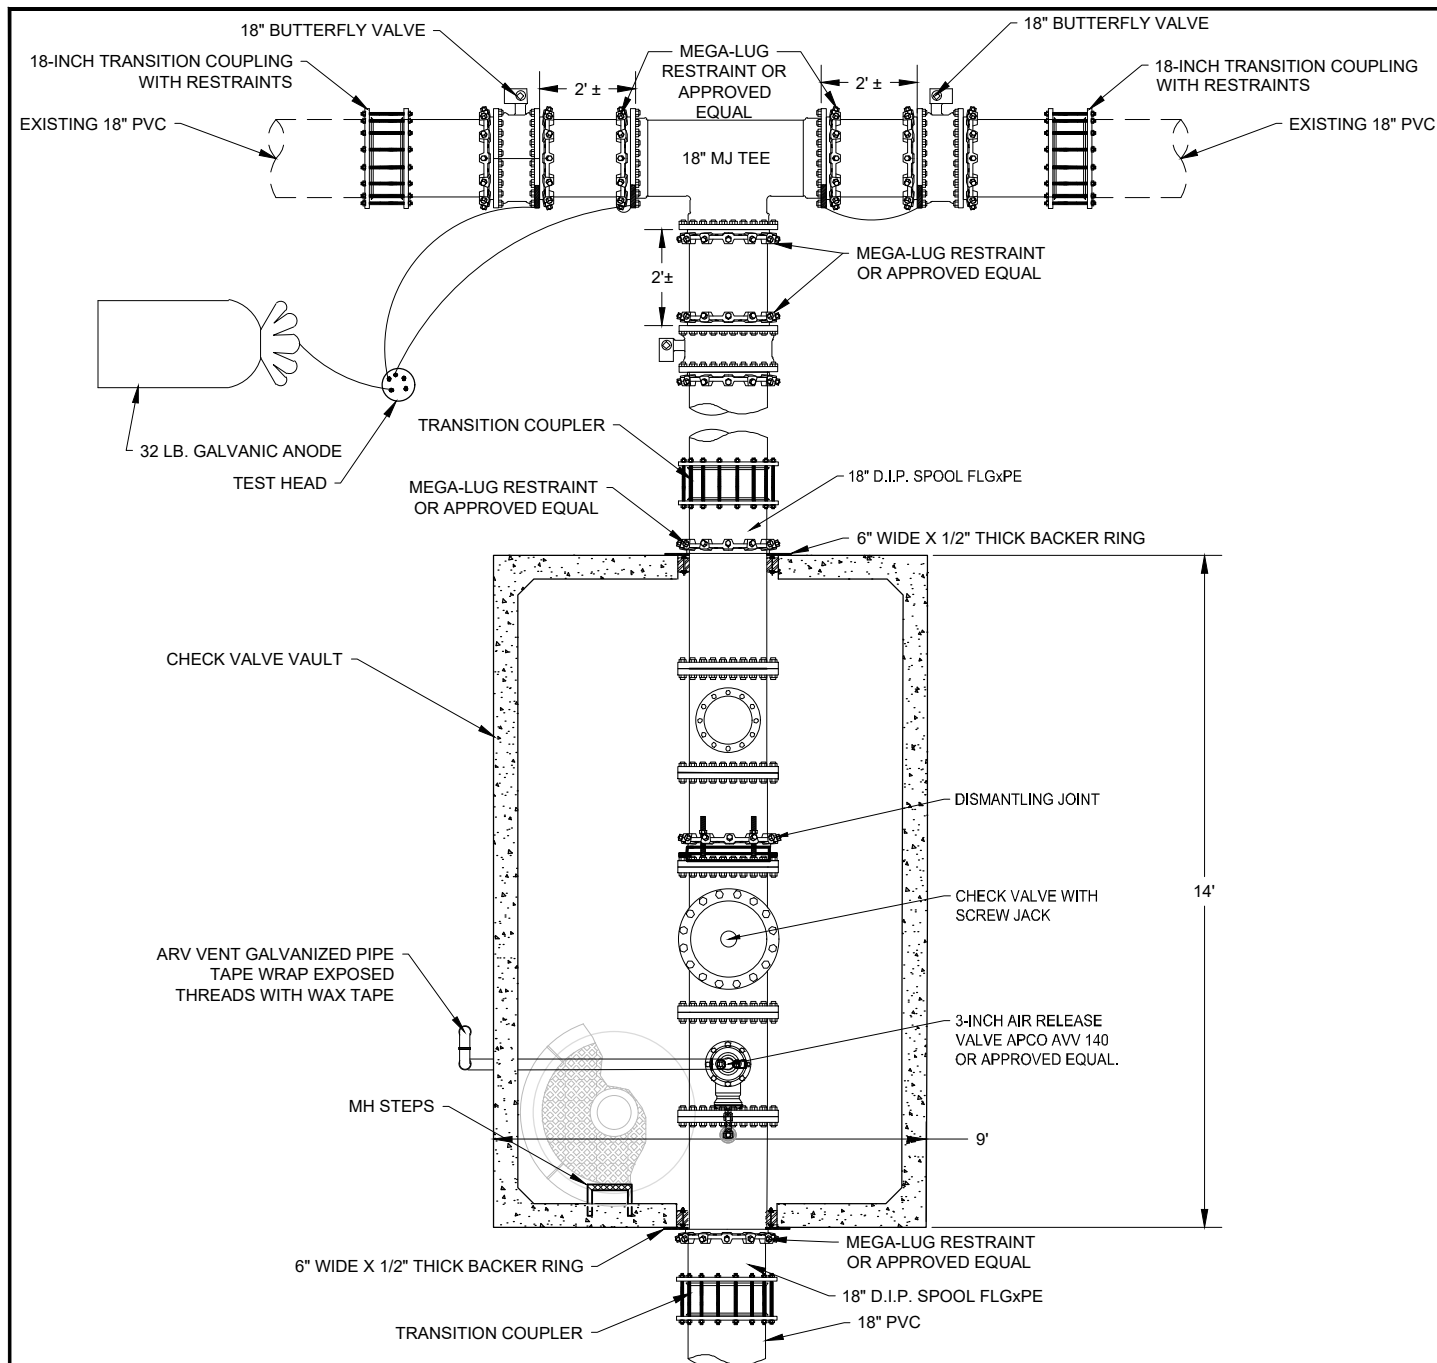

A 18"x18" CONNECTION NEAR WATER TANK (STA: 145+40 & 146+26)
NOT TO SCALE PLAN VIEW

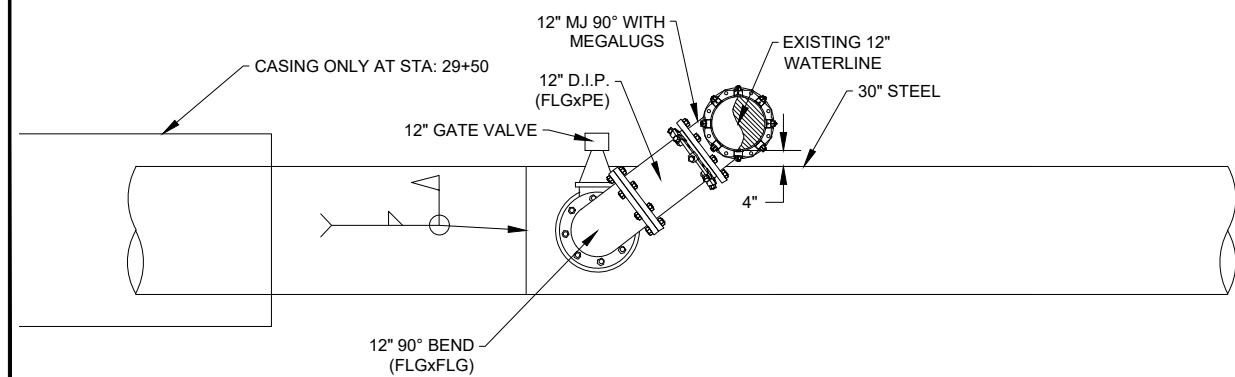


C 30"x12" CONNECTION (STA: 29+40 & 31+49)
TYPICAL ELEVATION VIEW

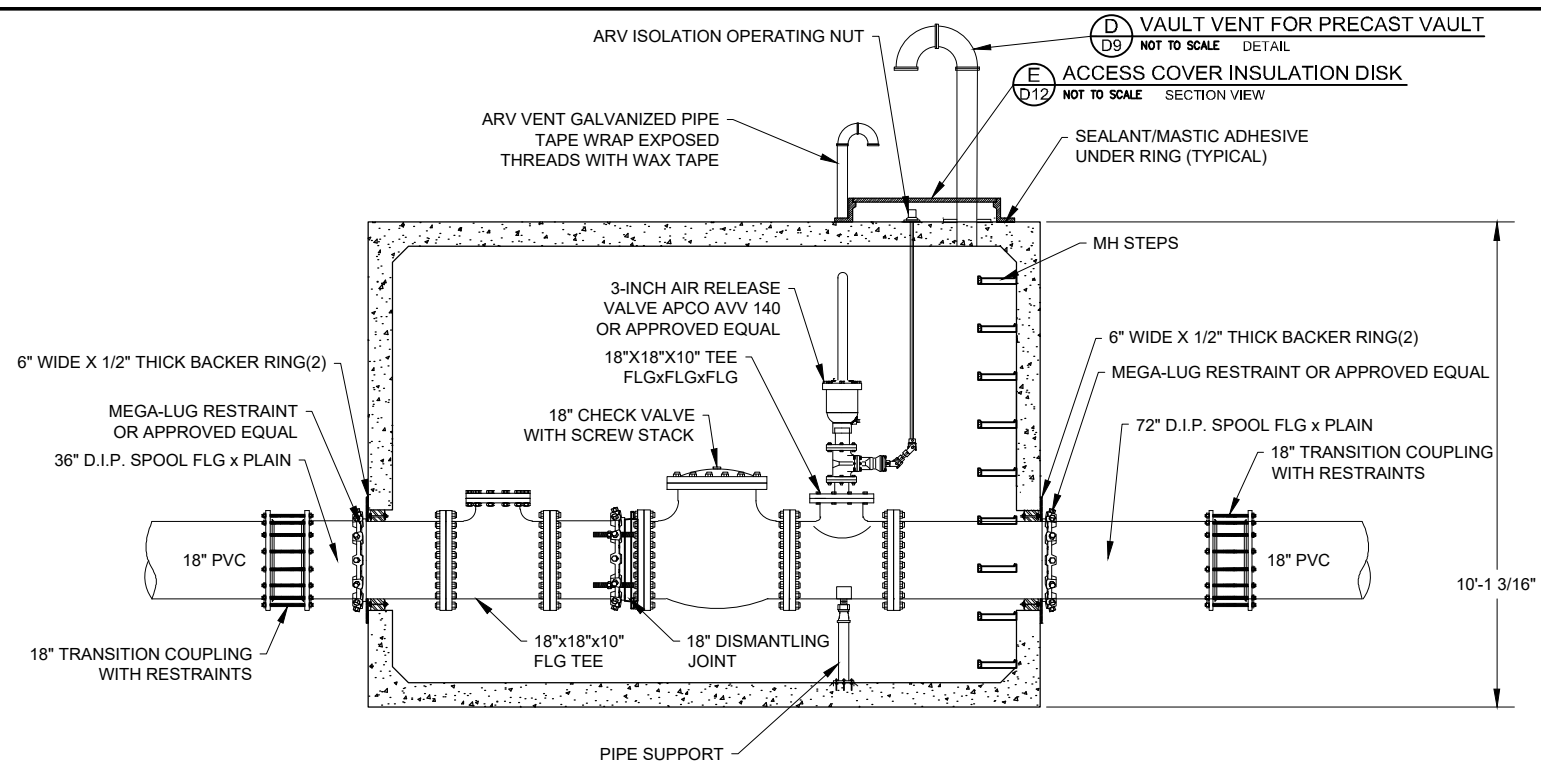

B 18"x18" CHECK VALVE NEAR STA: 145+40
NOT TO SCALE ELEVATION VIEW



NOTE: ON ALL STRUCTURES, PLACE BOLLARDS ACCORDING TO DETAIL C SHEET D20 AND ASSOCIATED TABLE

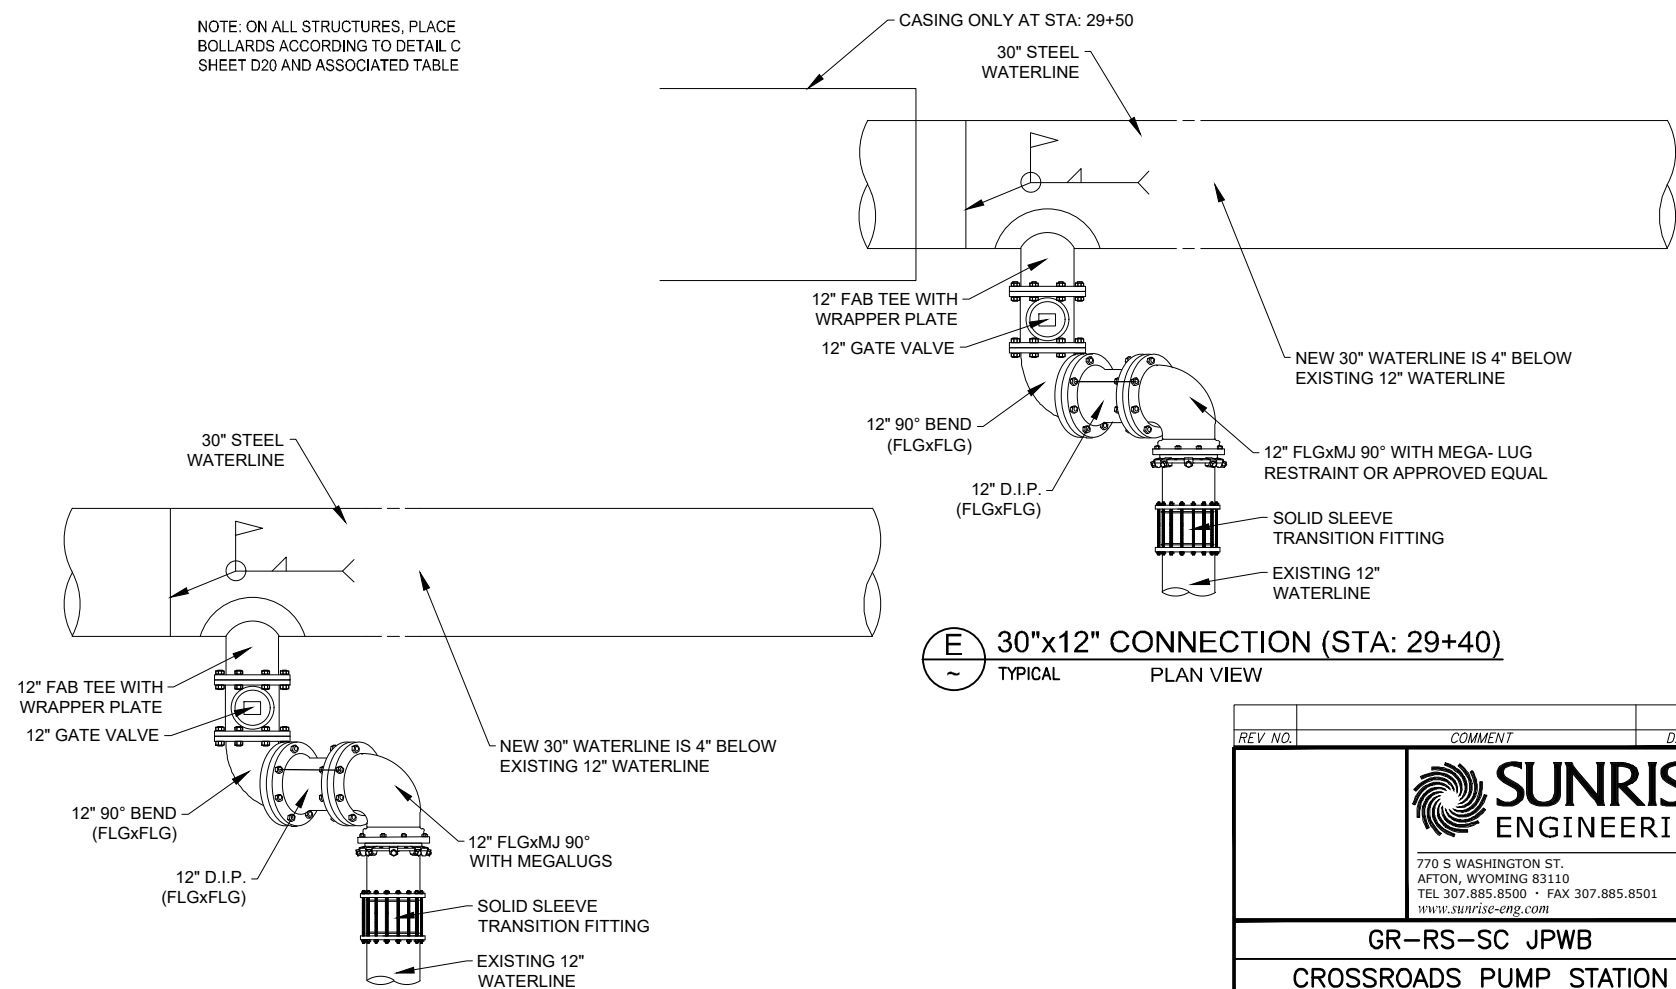



D 30"x12" CONNECTION (STA: 31+49)
TYPICAL PLAN VIEW

E 30"x12" CONNECTION (STA: 29+40)
TYPICAL PLAN VIEW





REV. NO.	COMMENT	DATE
SUNRISE ENGINEERING 770 S WASHINGTON ST. AFTON, WYOMING 83110 TEL 307.885.8500 · FAX 307.885.8501 www.sunrise-eng.com		
GR-RS-SC JPWB		
CROSSROADS PUMP STATION		
WATERLINE CONNECTION DETAILS		
SEI NO. 07265	DESIGNED FDK	DRAWN BJ
CHECKED JUL	SHEET NO. 86 of 99	D8

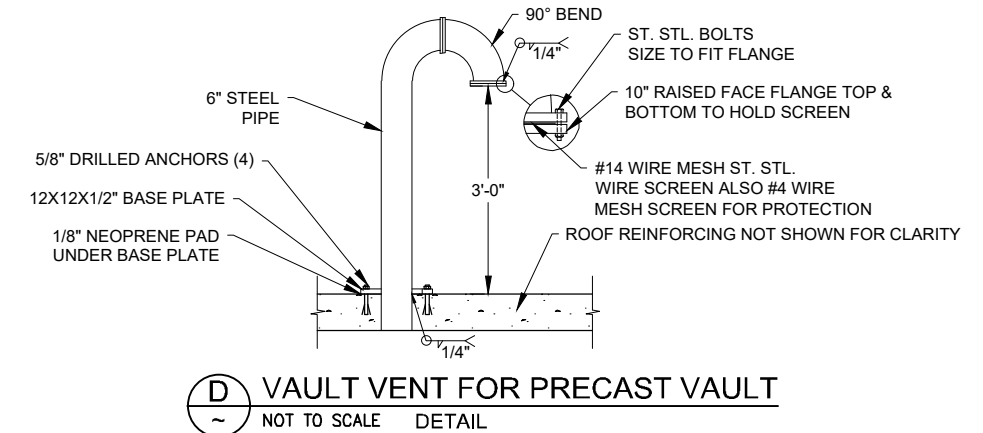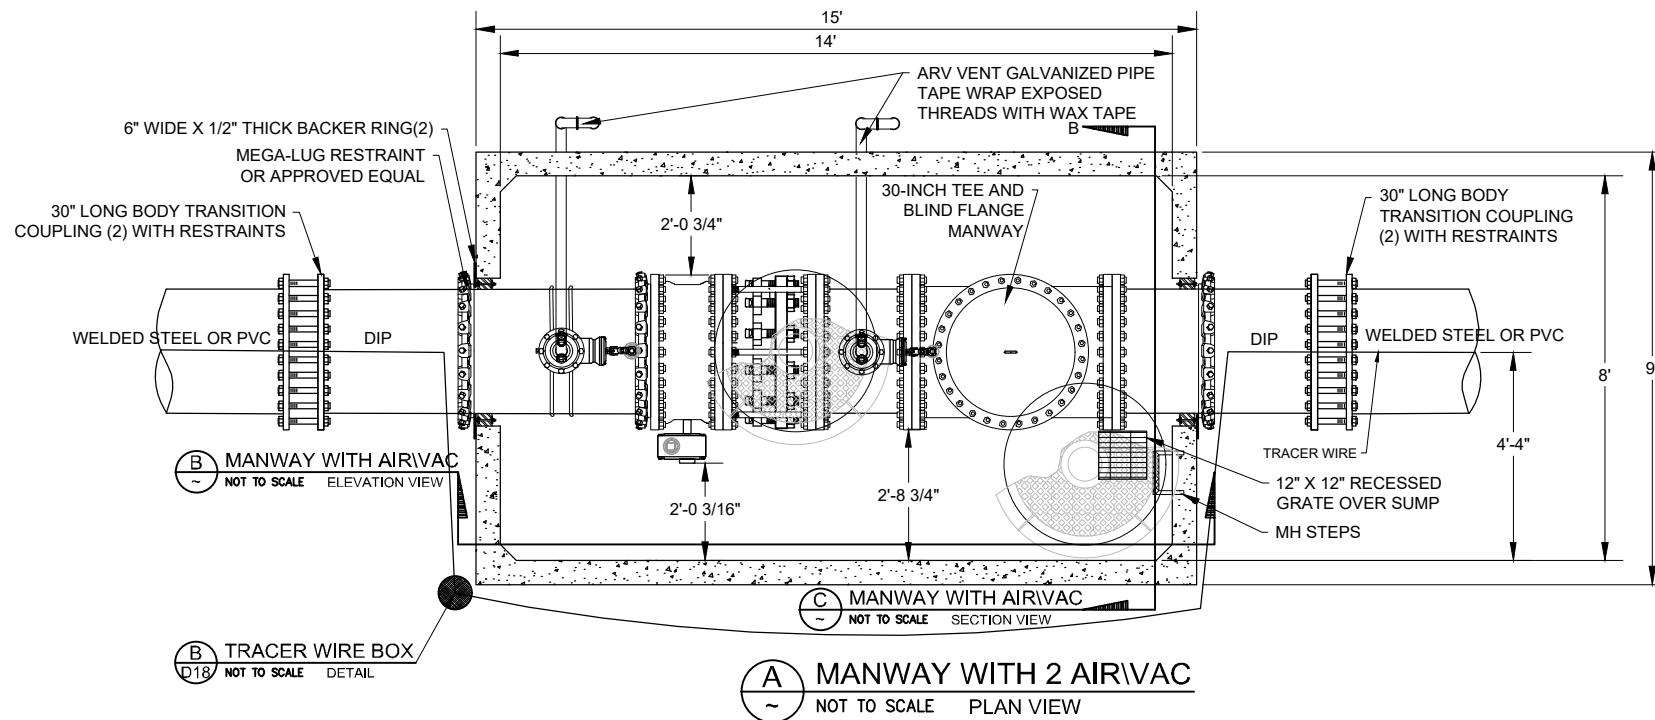

NOTE:
1. HOT DIP GALVANIZE ALL PARTS EXCEPT SCREEN & BOLTS AFTER WELDING COMPLETED.

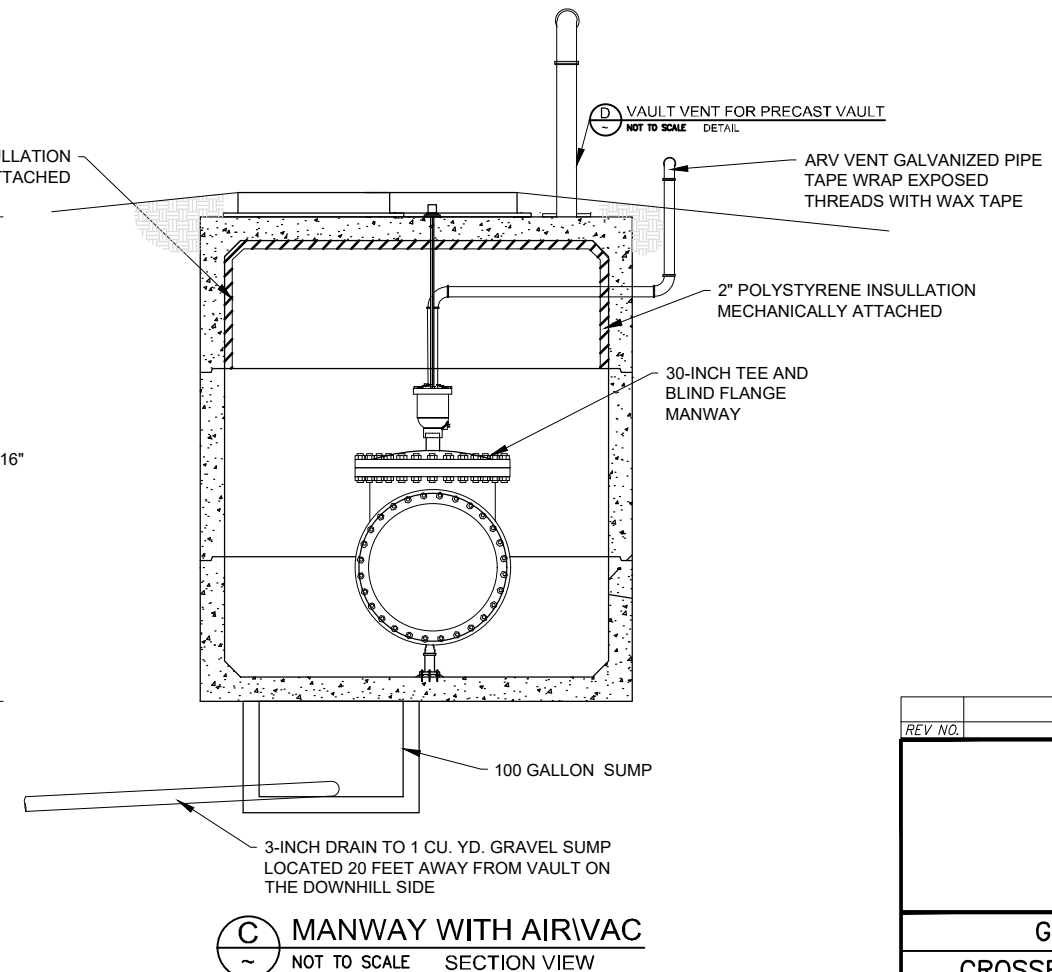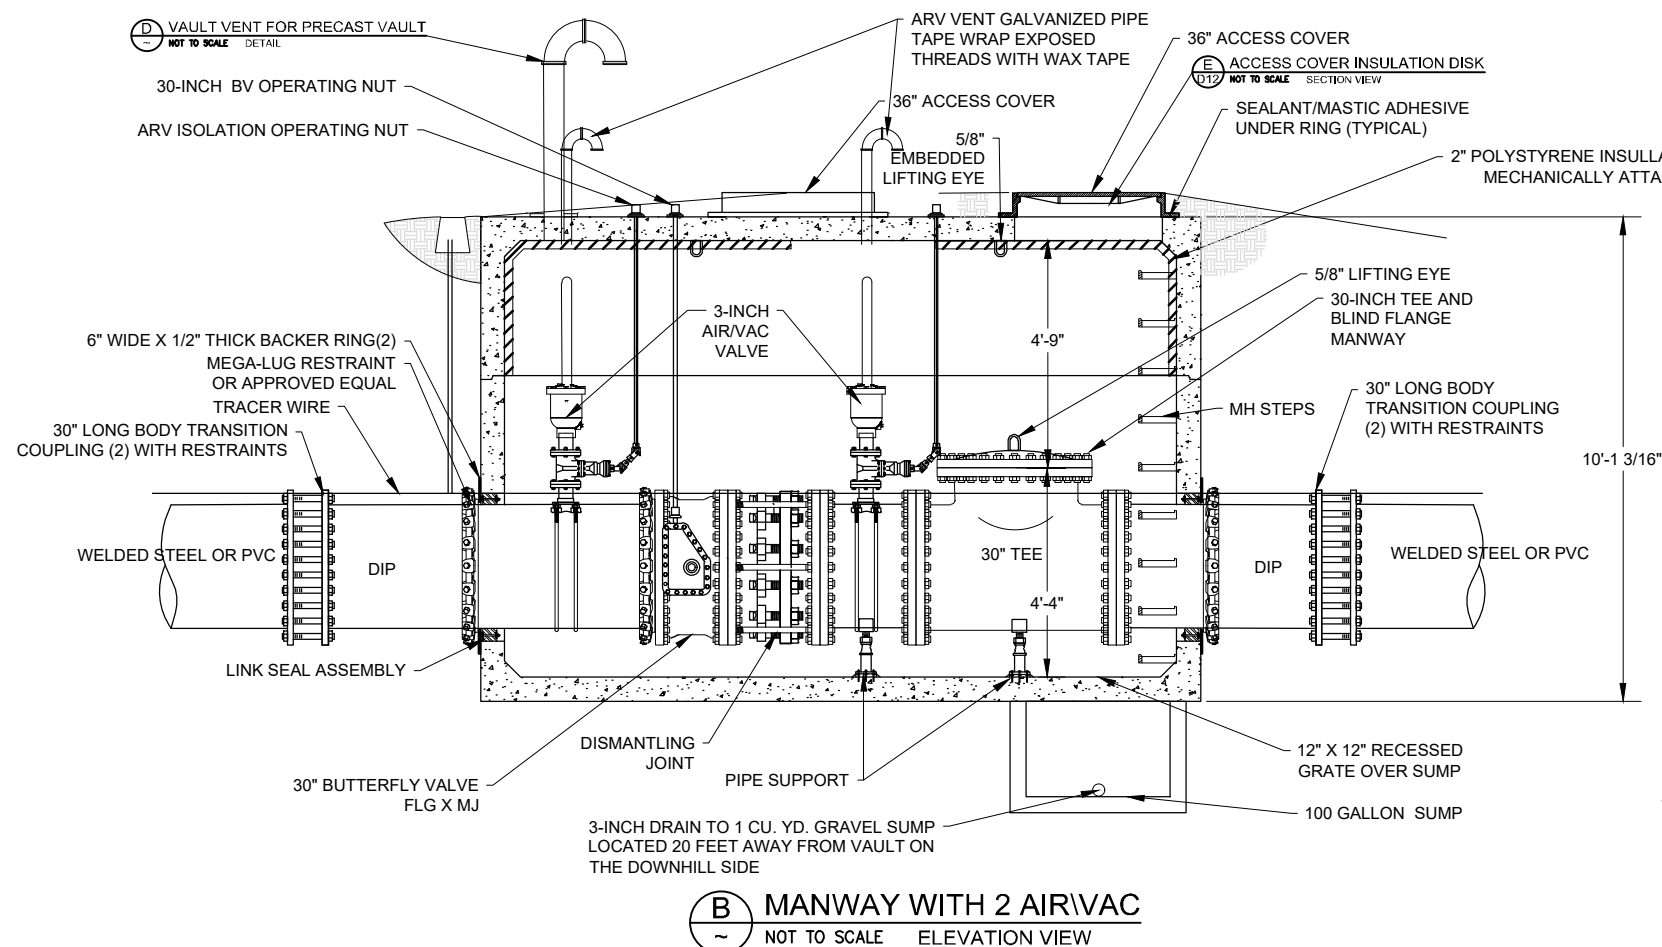

REV. NO.	COMMENT	DATE
SUNRISE ENGINEERING 770 S WASHINGTON ST. AFTON, WYOMING 83110 TEL 307.885.8500 • FAX 307.885.8501 www.sunrise-eng.com		
GR-RS-SC JPWB		
CROSSROADS PUMP STATION MANWAY WITH ISOLATION VALVE DETAILS		
SEI NO. 07265	DESIGNED FDK	DRAWN BJ
CHECKED JUL	SHEET NO. 87 of 99	D9

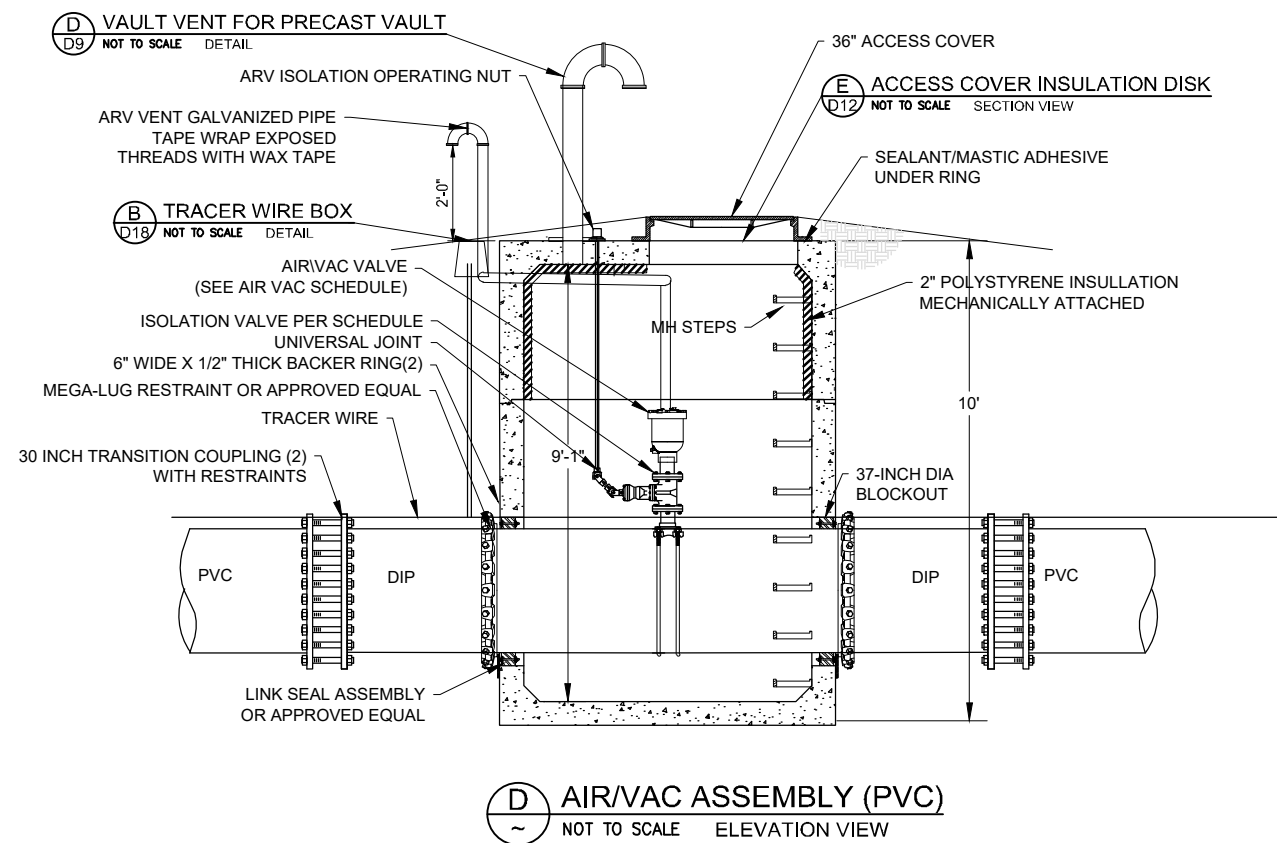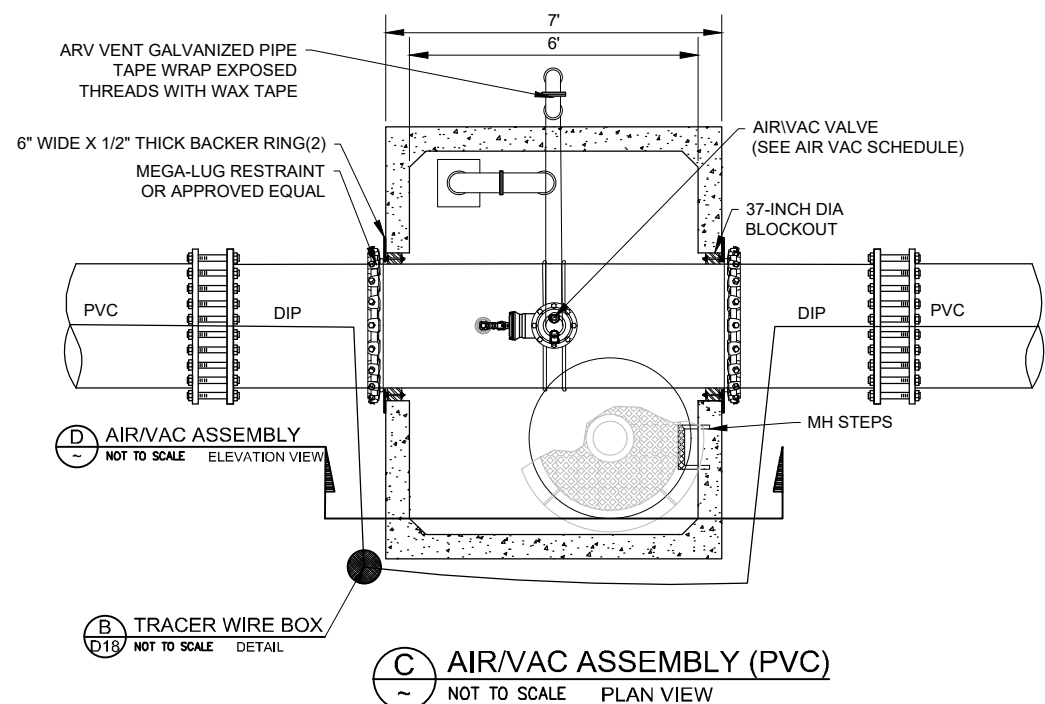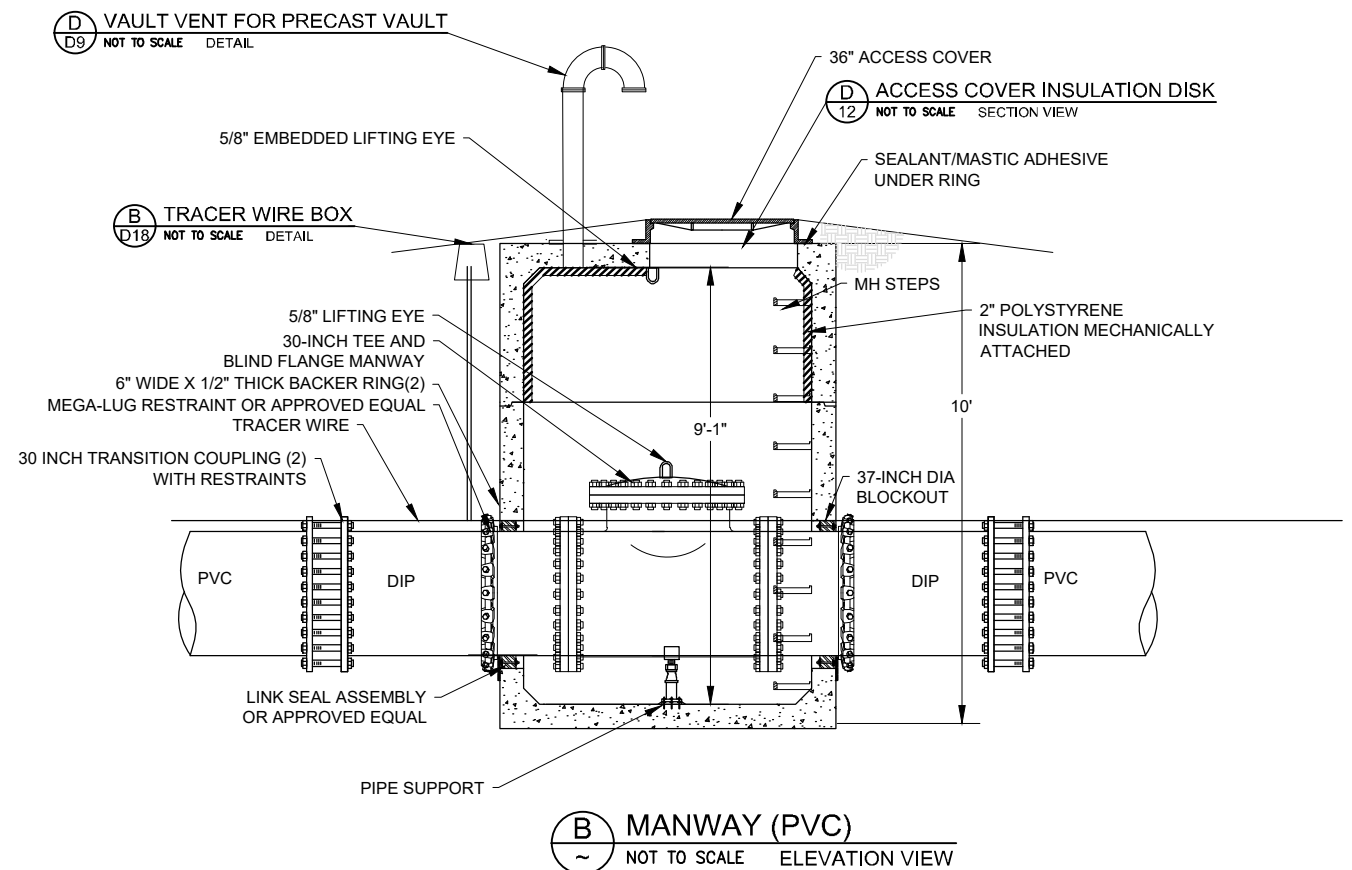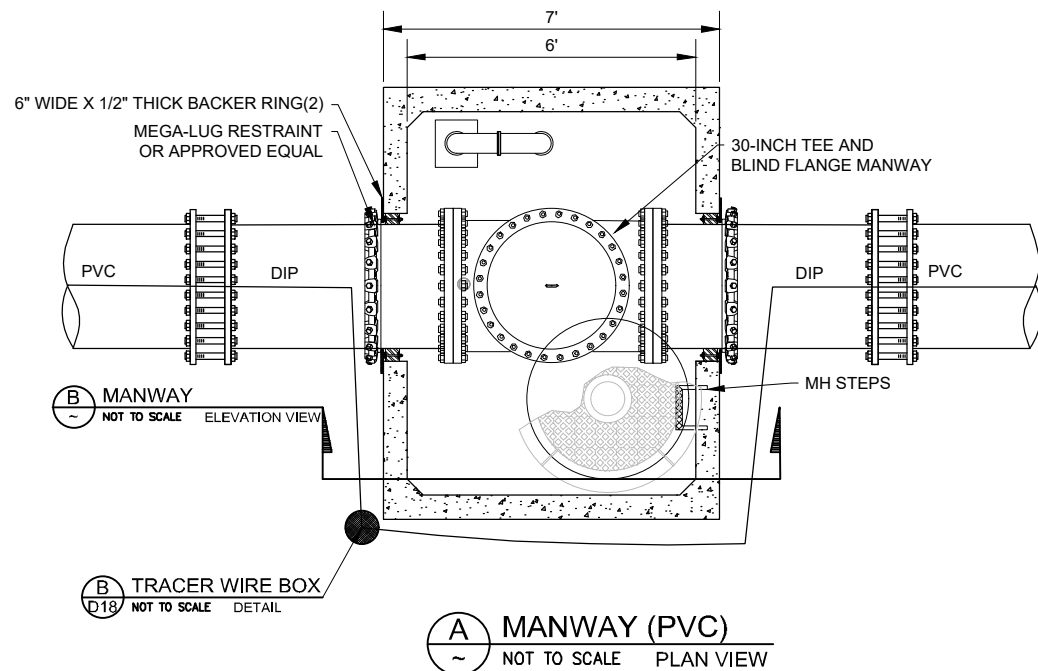


AIR RELIEF VALVE SCHEDULE	
STATION	VALVE SIZE
18+40	4"
62+50	4"
77+00	4"
84+30	3"
106+90	3"
113+90	3"
124+00	3"
145+50	3"
147+50	3"

REV. NO.	COMMENT	DATE



SUNRISE ENGINEERING

770 S WASHINGTON ST.
AFTON, WYOMING 83110
TEL 307.885.8500 • FAX 307.885.8501
www.sunrise-eng.com


GR-RS-SC JPWB					
CROSSROADS PUMP STATION MANWAY/AIR VACUUM DETAILS					
SEI NO. 07265	DESIGNED FDK	DRAWN BJ	CHECKED JUL	SHEET NO. 88 of 99	D10

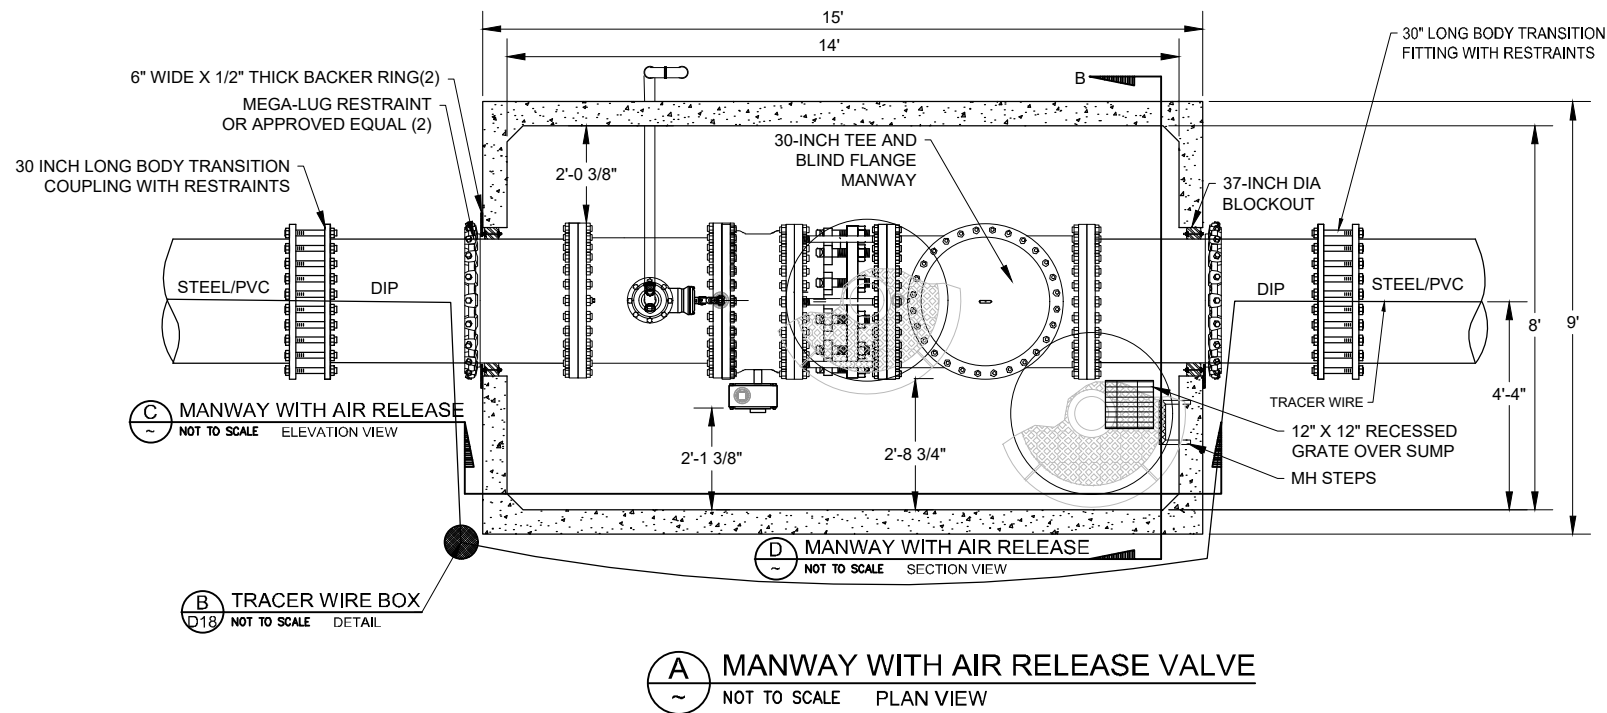






NOTE: ON STEEL PIPE SECTIONS, THE STEEL PIPE MAY BE EXTENDED TO THE TEE INSIDE THE VAULT TO A WELDED FLANGE SHIPPED LOOSE.

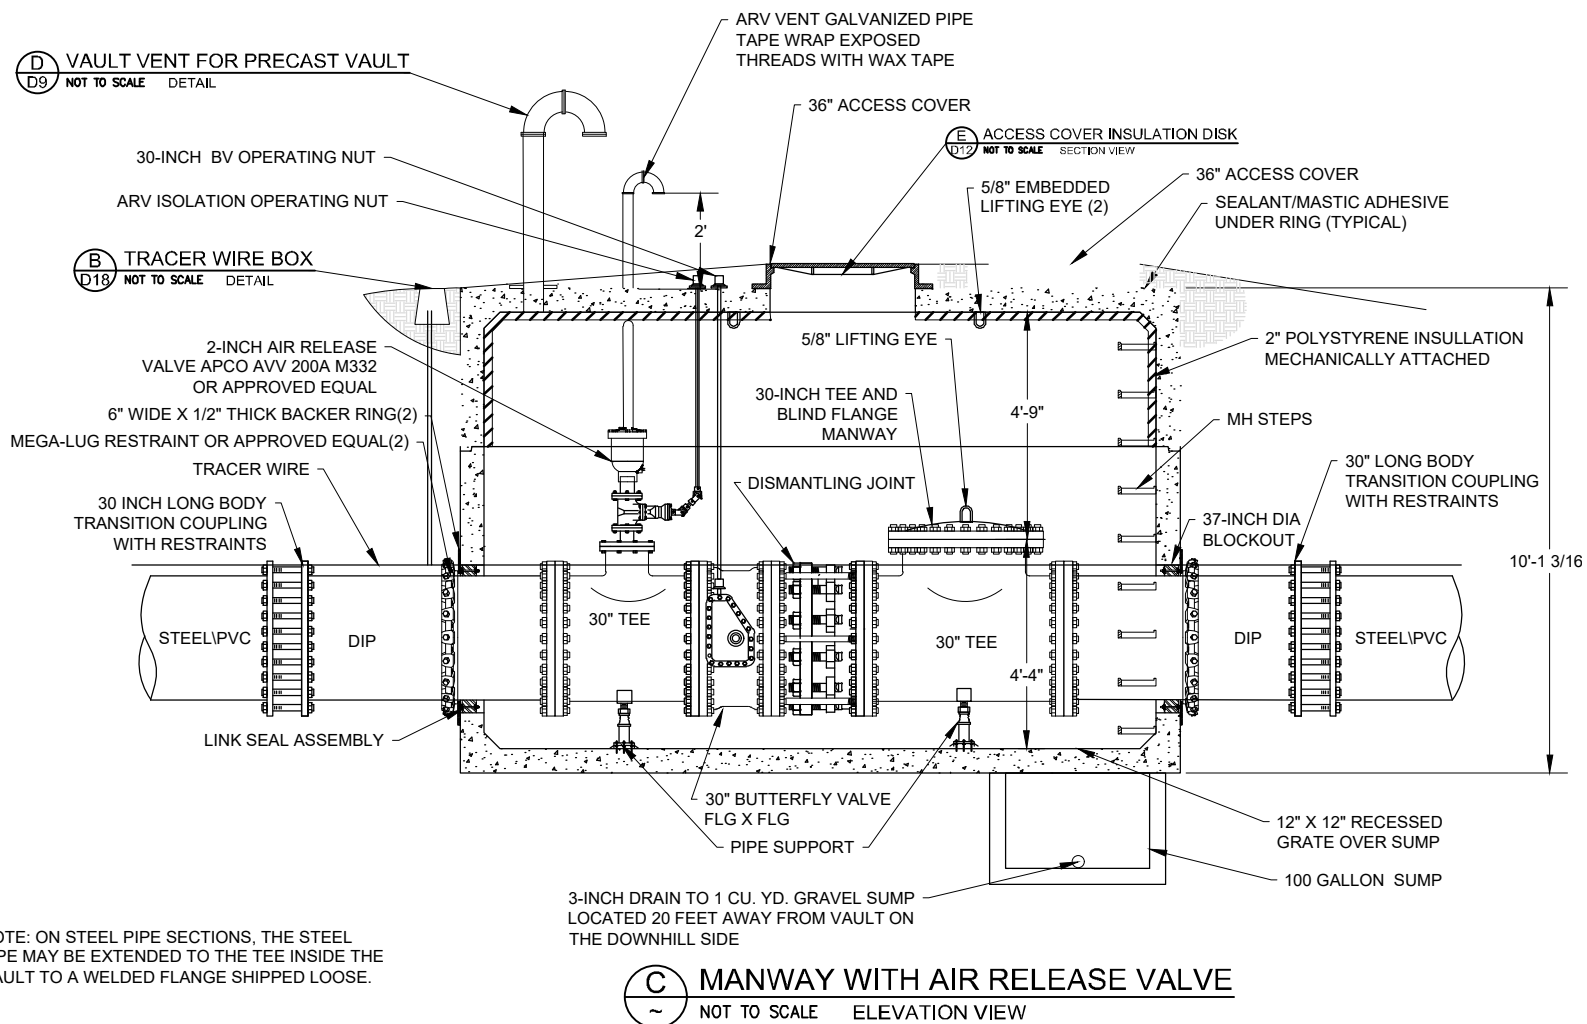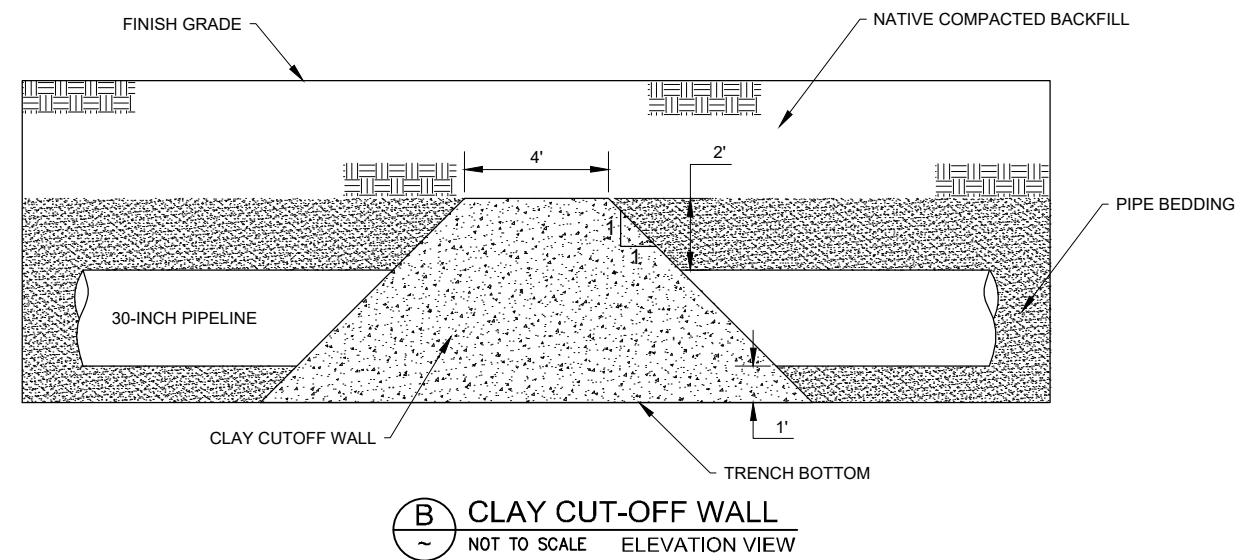





NOTE: ON STEEL PIPE SECTIONS, THE STEEL PIPE MAY BE EXTENDED TO THE TEE INSIDE THE VAULT TO A WELDED FLANGE SHIPPED LOOSE.

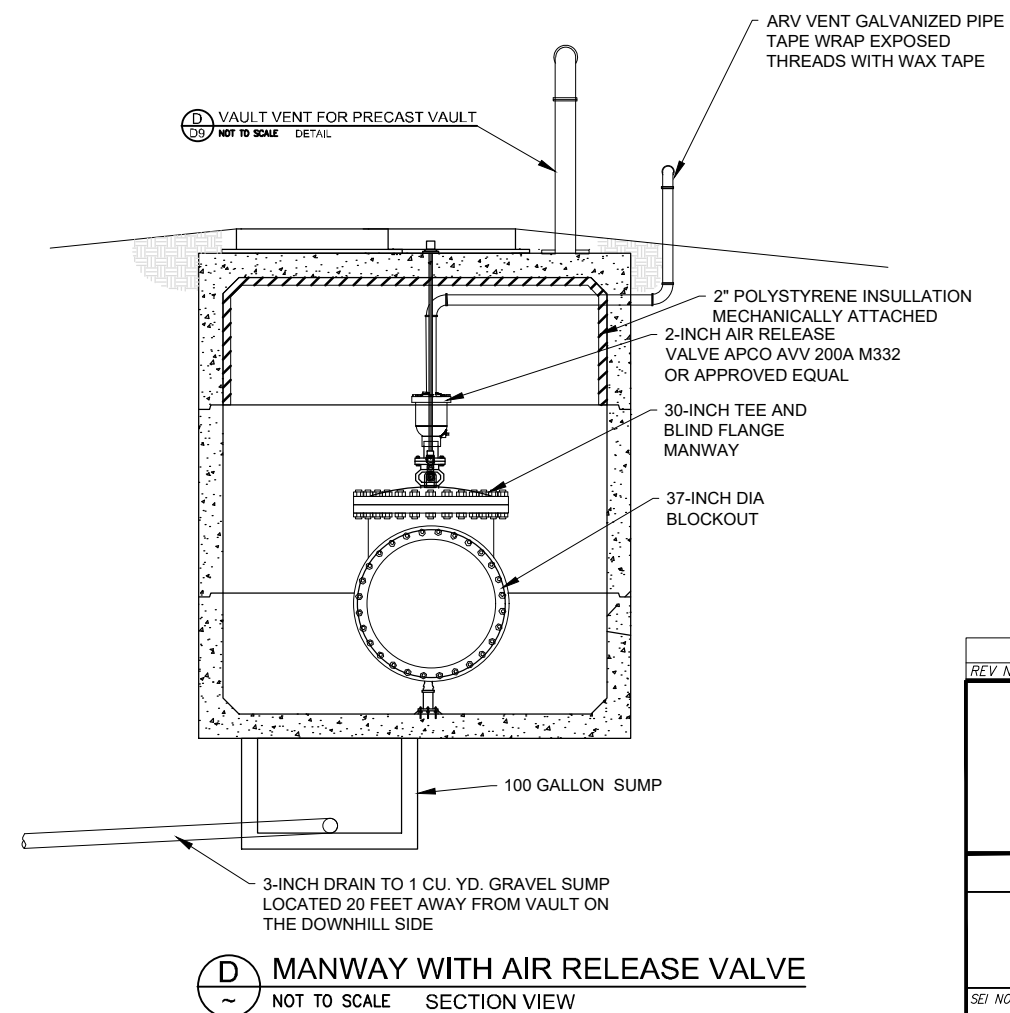


REV. NO.	COMMENT	DATE
 SUNRISE ENGINEERING 770 S WASHINGTON ST. AFTON, WYOMING 83110 TEL 307.885.8500 • FAX 307.885.8501 www.sunrise-eng.com		
GR-RS-SC JPWB		
CROSSROADS PUMP STATION MANWAY WITH ISOLATION VALVE DETAILS		
SEI NO. 07265	DESIGNED FDK	DRAWN BJ
CHECKED JUL	SHEET NO. 89 of 99	D11

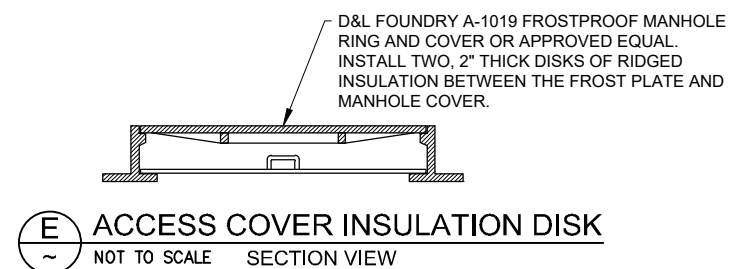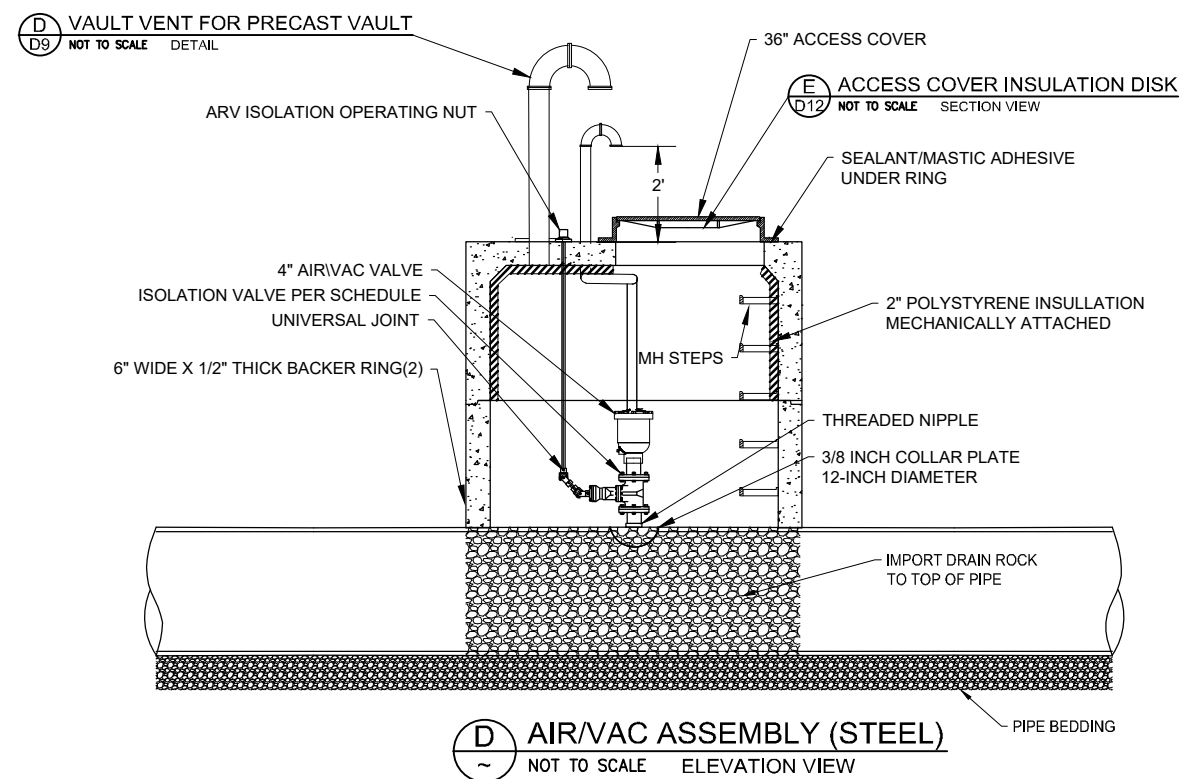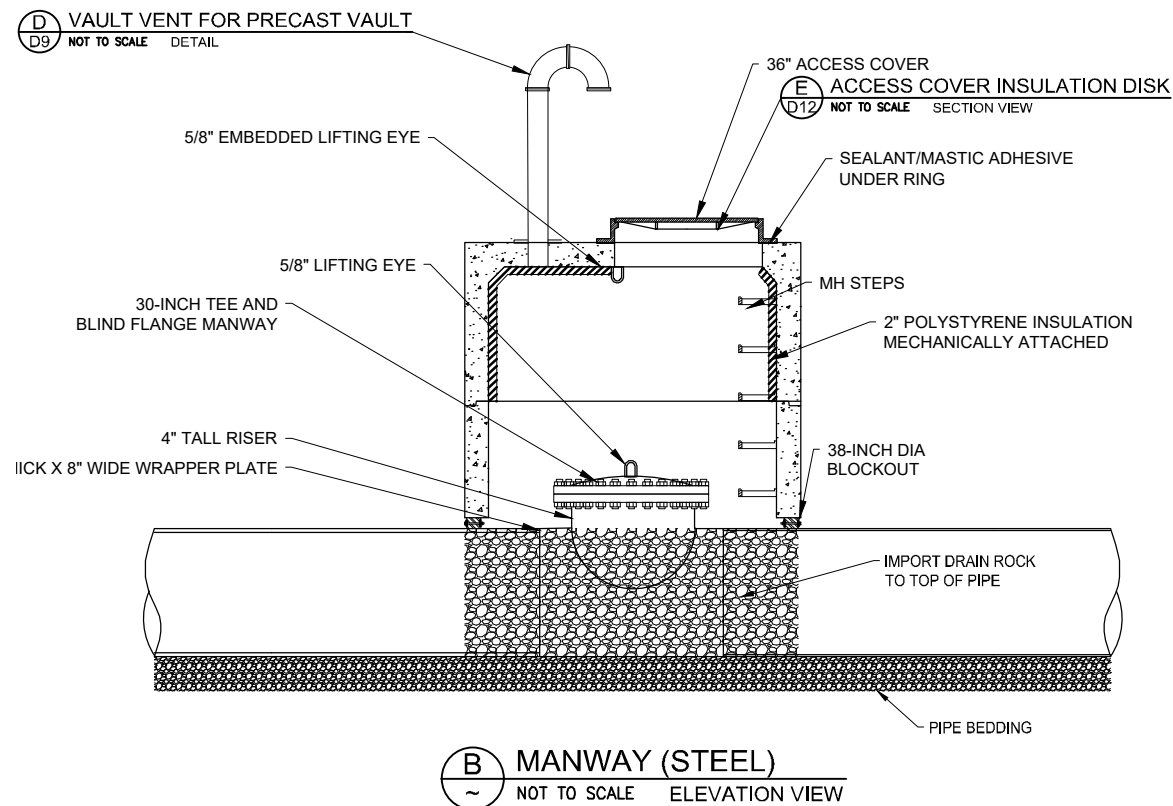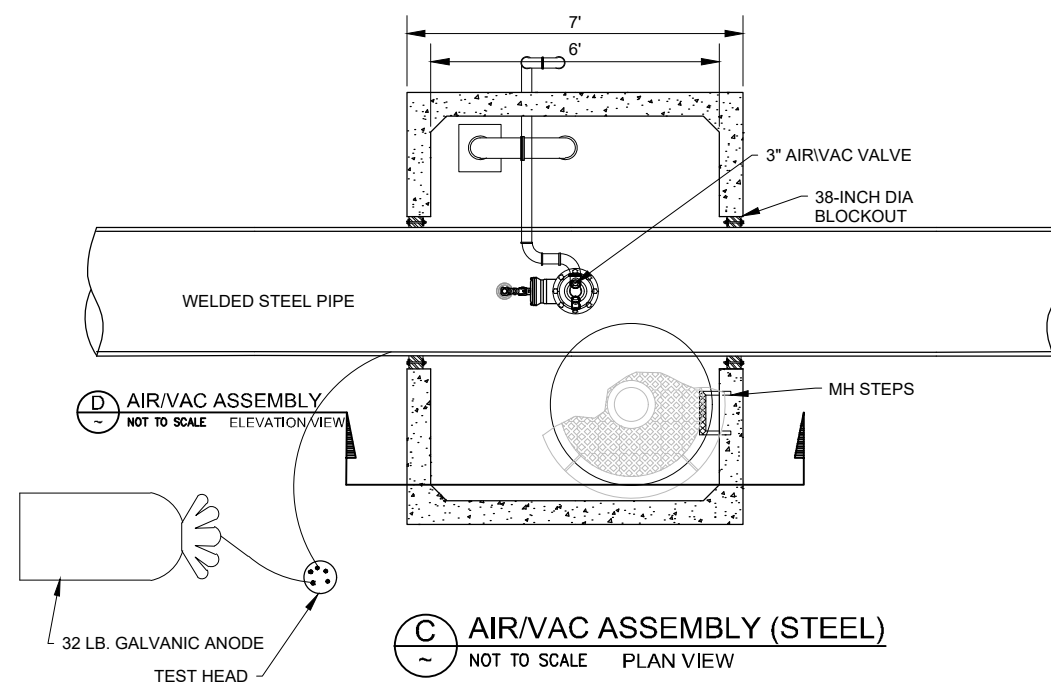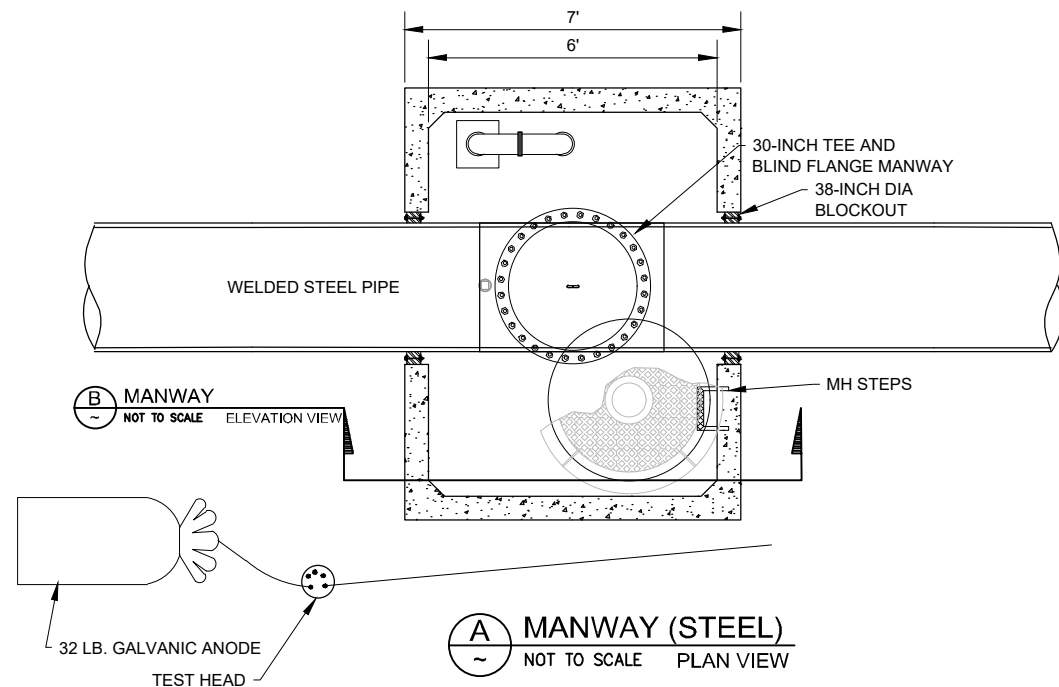


REV. NO.	COMMENT	DATE
SUNRISE ENGINEERING 770 S WASHINGTON ST. AFTON, WYOMING 83110 TEL 307.885.8500 • FAX 307.885.8501 www.sunrise-eng.com		
GR-RS-SC JPWB		
CROSSROADS PUMP STATION		
MANWAY AIR VAC DETAILS		
SEI NO. 07265	DESIGNED FDK	DRAWN BJ
CHECKED JUL	SHEET NO. 90 of 99	D12

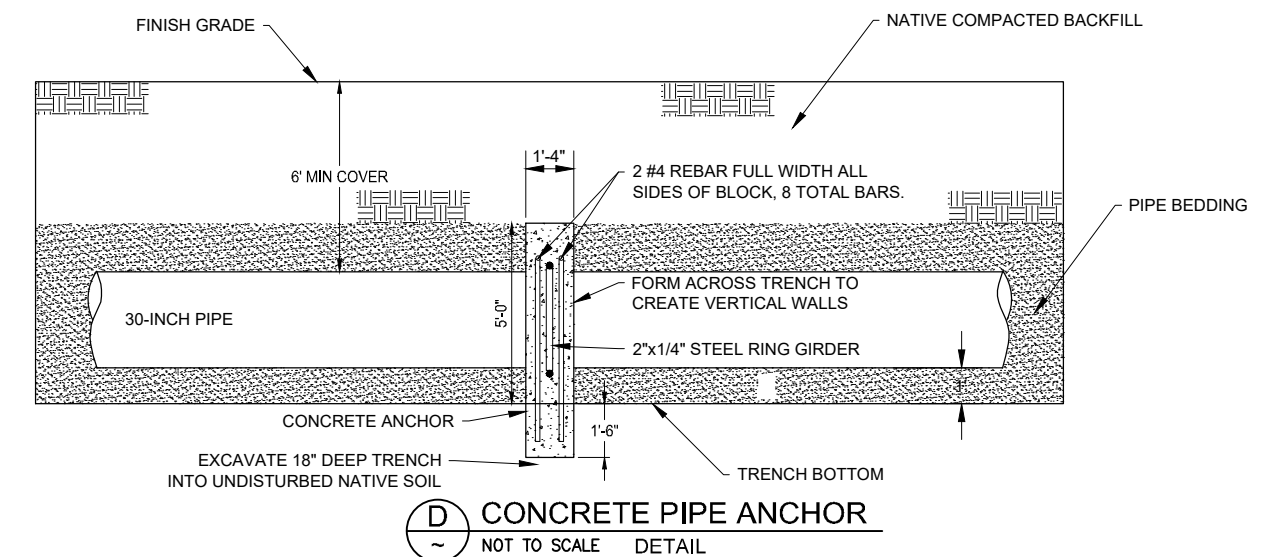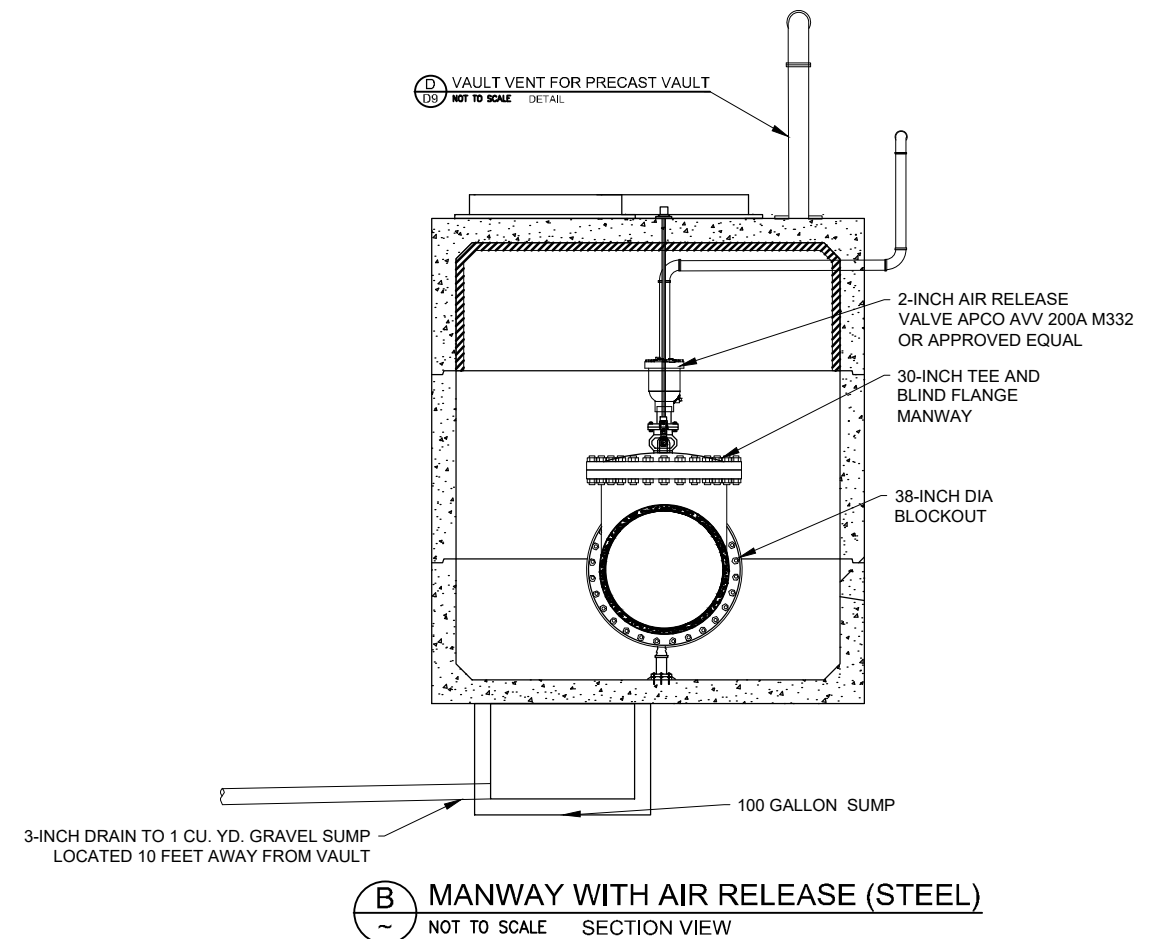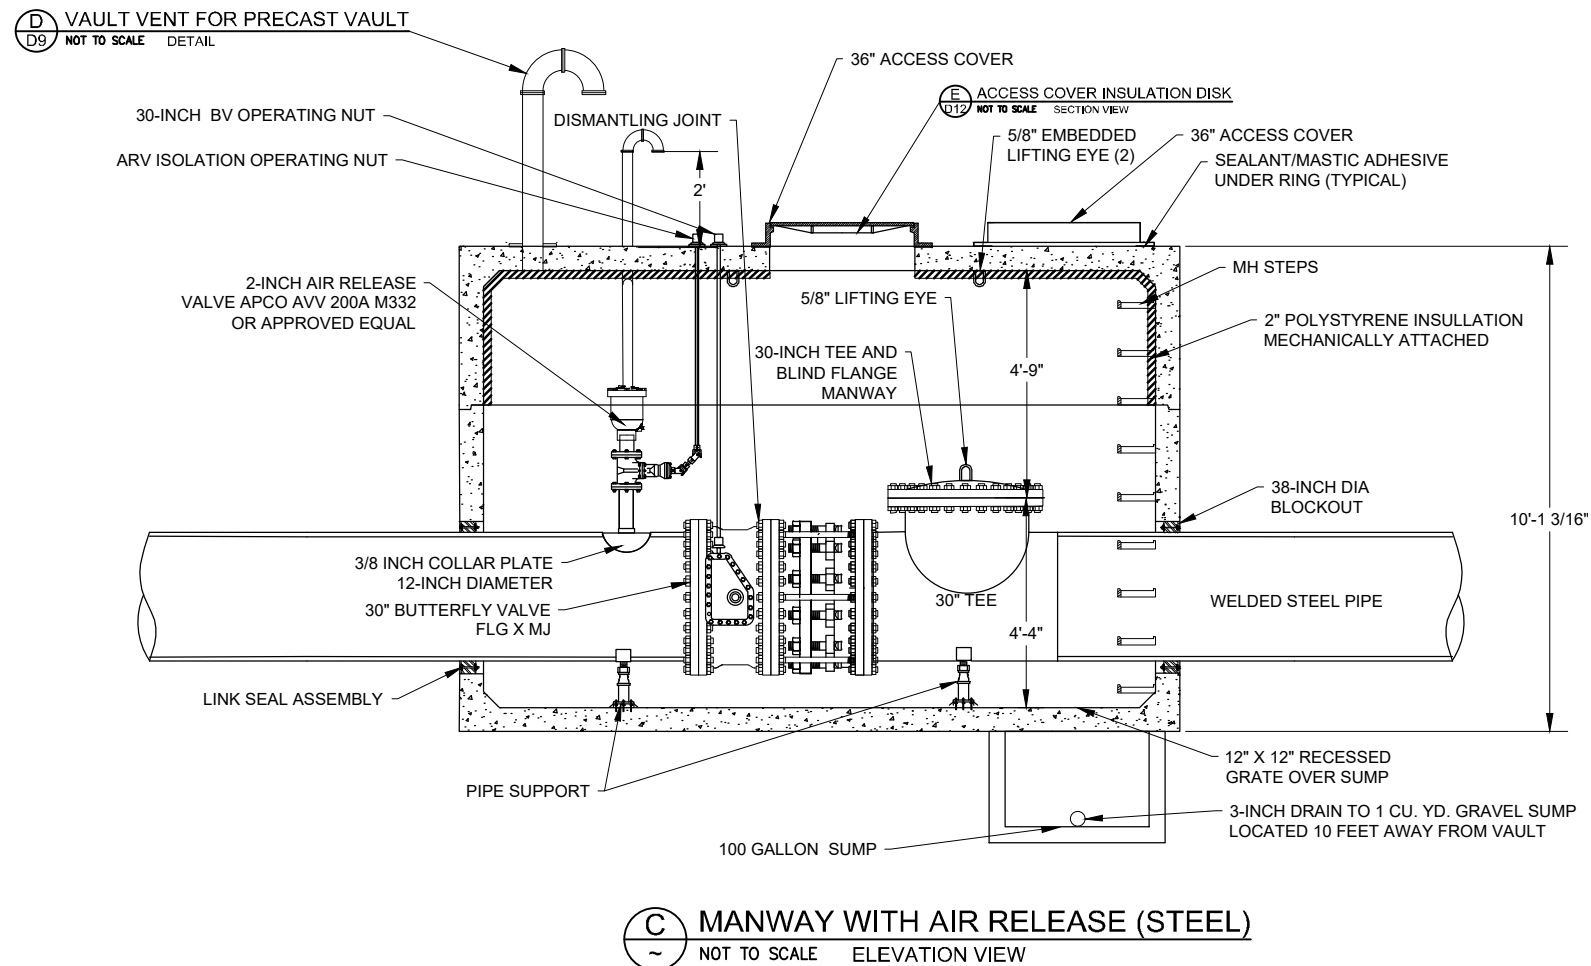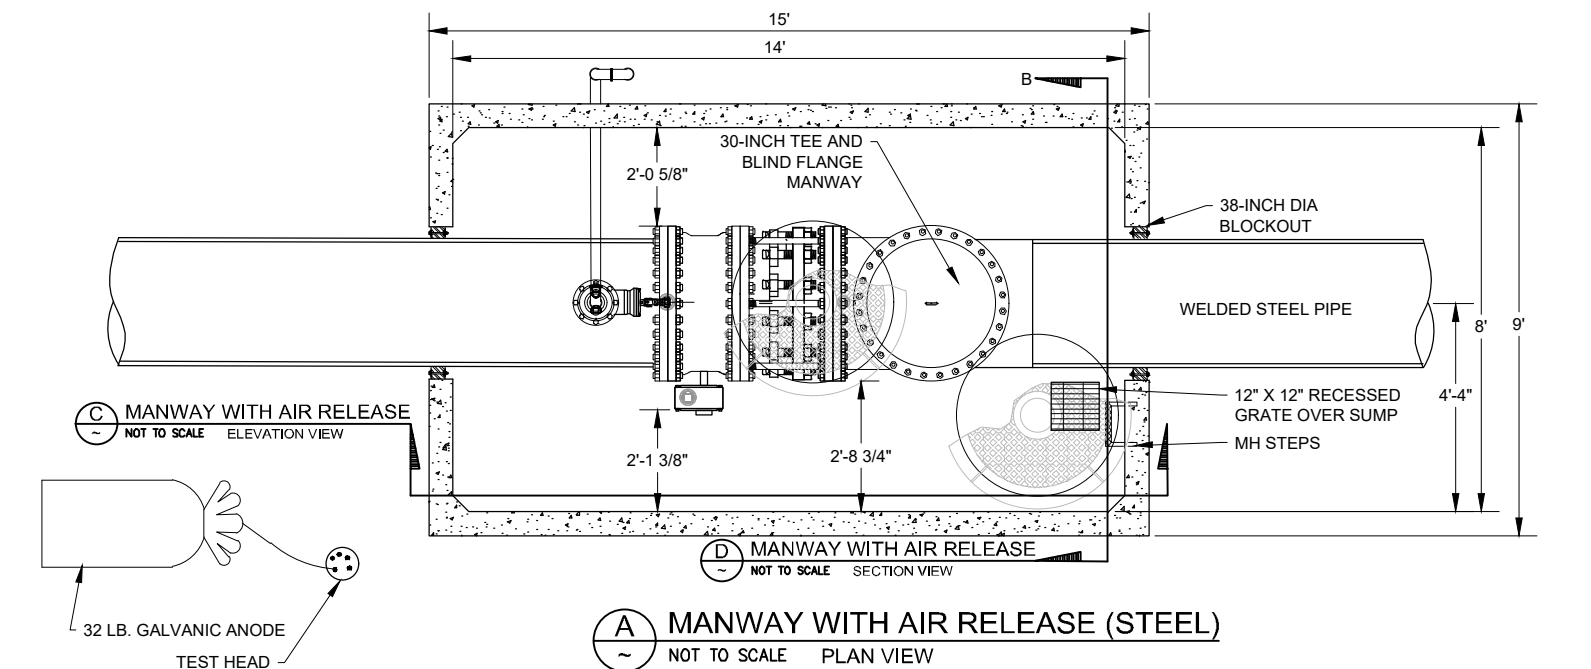


REV. NO.	COMMENT	DATE
SUNRISE ENGINEERING 770 S WASHINGTON ST. AFTON, WYOMING 83110 TEL 307.885.8500 • FAX 307.885.8501 www.sunrise-eng.com		
GR-RS-SC JPWB		
CROSSROADS PUMP STATION		
MANYWAY AIR VAC DETAILS		
SEI NO. 07265	DESIGNED FDK	DRAWN BJ
CHECKED JUL	SHEET NO. 91 of 99	D13

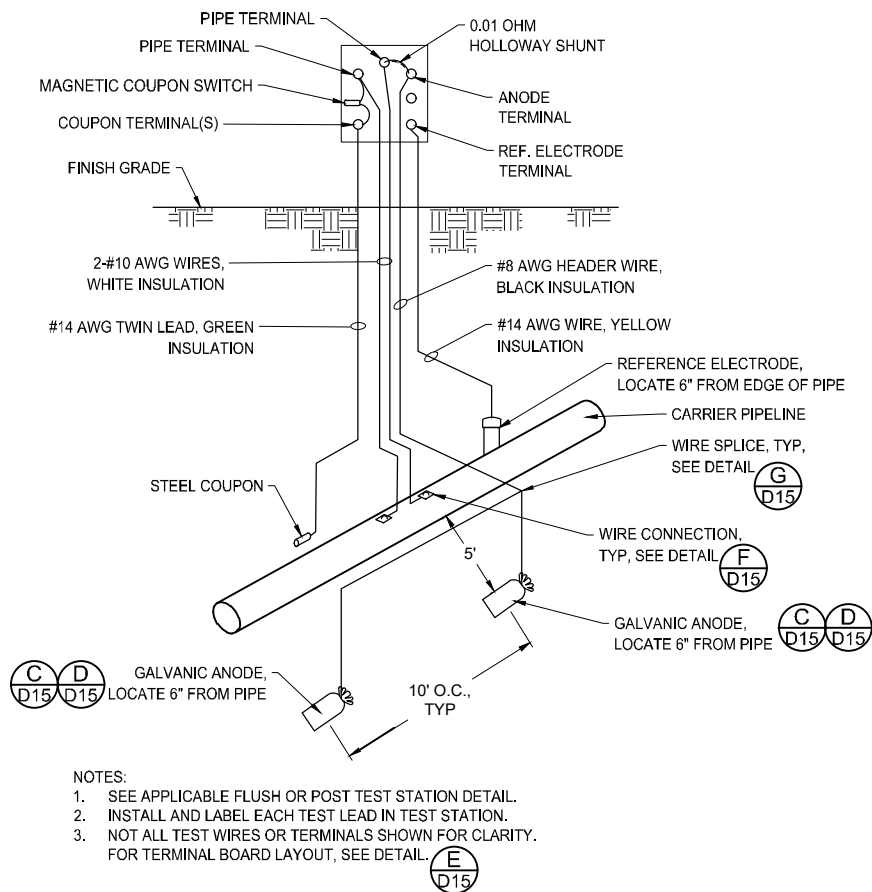


(A) TEST STATION
NOT TO SCALE DETAIL

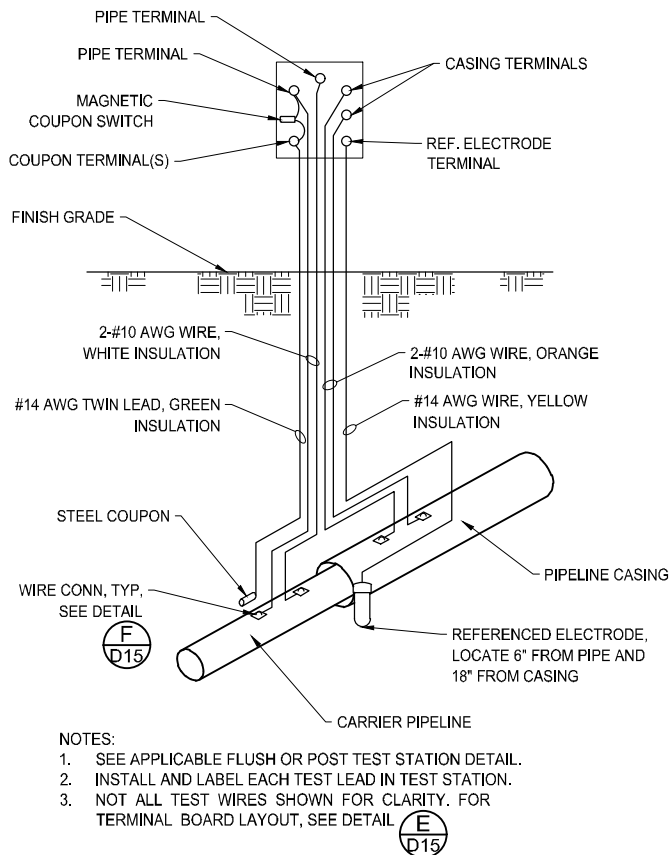

(B) TEST STATION
NOT TO SCALE DETAIL

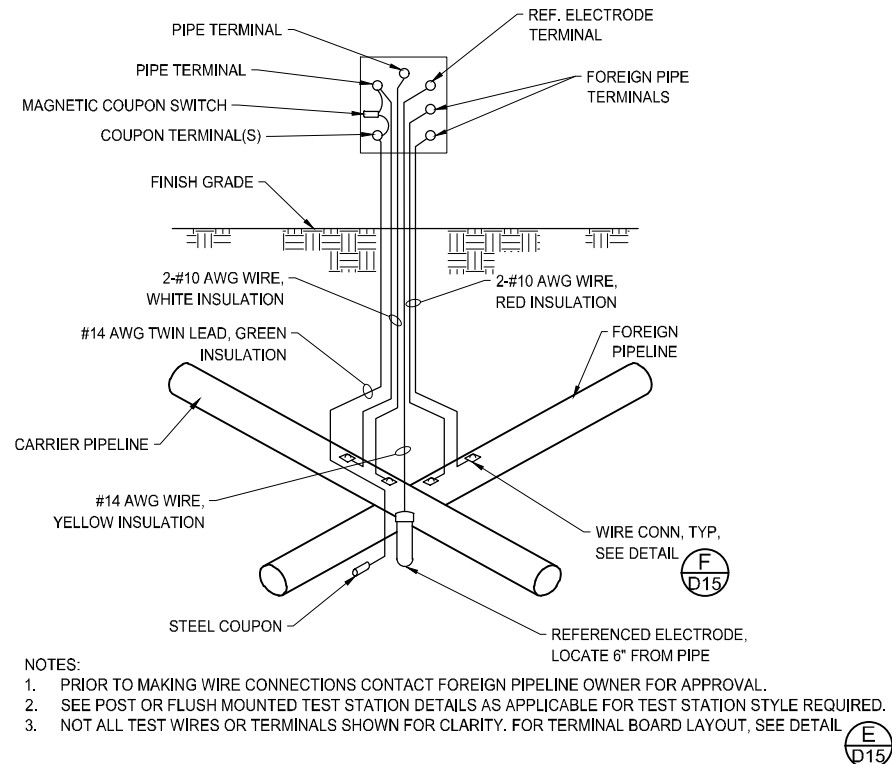


(C) TEST STATION
NOT TO SCALE DETAIL

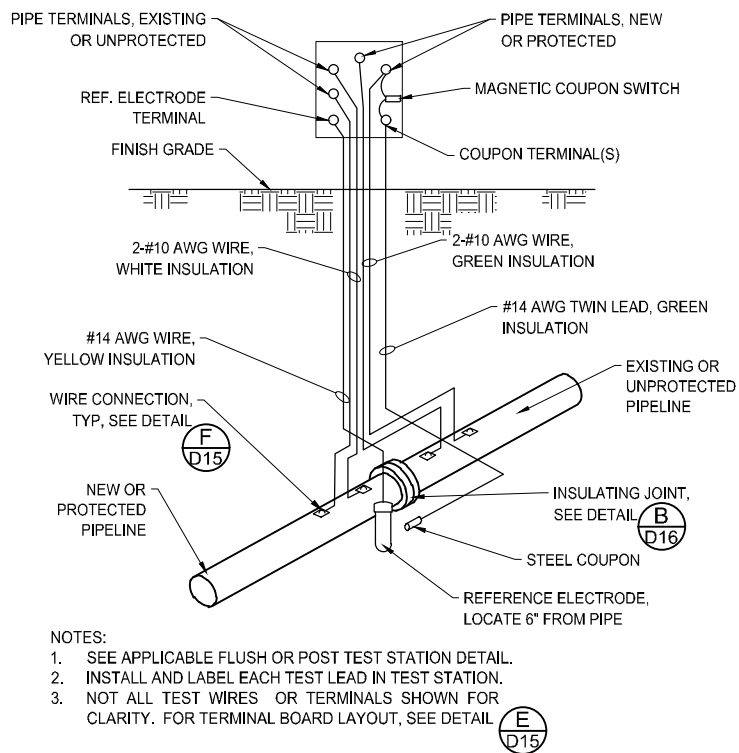

(D) TEST STATION
NOT TO SCALE DETAIL


CATHODIC PROTECTION TEST STATION SCHEDULE					
CTS#	STATION	TYPE	STYLE	NUMBER AND BARE WEIGHT OF HIGH POTENTIAL MAGNESIUM ANODES	REMARKS
1	0+00	DETAIL A	FLUSH	4 - 60 LB.	INSTALL TEST STATION AT NEW 30' STEEL TEE
2	18+00	DETAIL A	FLUSH	4 - 60 LB.	INSTALL TEST STATION AT BEND
3	24+00	DETAIL B	FLUSH	4 - 60 LB.	INSTALL TEST STATION AT SOUTH END OF CASING
4	25+40	DETAIL B	FLUSH	4 - 60 LB.	INSTALL TEST STATION AT SOUTH END OF CASING
5	28+50	DETAIL B	FLUSH	4 - 60 LB.	INSTALL TEST STATION AT SOUTH END OF CASING
6	29+10	DETAIL C	FLUSH	2 - 60 LB.	INSTALL TEST STATION AT GAS PIPELINE CROSSING
7	32+60	DETAIL C	FLUSH	2 - 60 LB.	INSTALL TEST STATION AT
8	36+55	DETAIL A	FLUSH	2 - 60 LB.	INSTALL TEST STATION AT END OF STEEL
9	37+40	DETAIL A	FLUSH	2 - 60 LB.	INSTALL TEST STATION AT
10	42+65	DETAIL C	FLUSH	2 - 60 LB.	INSTALL TEST STATION AT GAS PIPELINE CROSSING
11	49+00	DETAIL A	FLUSH	2 - 60 LB.	INSTALL TEST STATION AT CENTER OF STEEL
12	60+00 TO 146+00	DETAIL A	FLUSH	1 - 60 LB.	INSTALL TEST STATION AT ALL DUCTILE FITTINGS
13	111+37	DETAIL C	FLUSH	2 - 60 LB.	INSTALL TEST STATION AT WATER PIPELINE CROSSING
14	0+00 TO 146+00	DETAIL A	FLUSH	1 - 60 LB.	INSTALL TEST STATION AT EACH MANWAY

REV. NO.	COMMENT	DATE
 SUNRISE ENGINEERING 770 S WASHINGTON ST. AFTON, WYOMING 83110 TEL 307.885.8500 · FAX 307.885.8501 www.sunrise-eng.com		
GR-RS-SC JPWB		
CROSSROADS PUMP STATION		
CATHODIC PROTECTION DETAILS		
SEI NO. 07265	DESIGNED FDK	DRAWN BJ
CHECKED JUL	SHEET NO. 92 of 99	D14

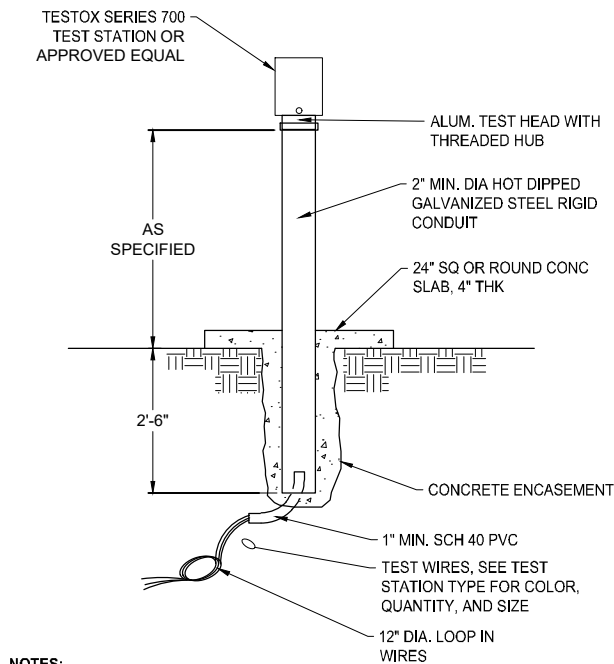


- NOTES:**
1. QUANTITY OF TERMINALS AND WIRING CONNECTIONS VARIES, SEE APPLICABLE TEST STATION DETAILS FOR TYPE OF TEST STATION.
 2. PROVIDE WIRE LOOP AT BASE OF POST MOUNTED TEST STATION.
 3. TO MINIMIZE SETTLEMENT STRESSES ON WIRE.
 4. INSTALL TESTOX SERIES 700 TEST STATION OR APPROVED EQUAL UNLESS SPECIFIED OTHERWISE.
 5. CORROSION RESISTANT TAPE WRAP TO BE APPLIED TO BURIED SECTION OF GALVANIZED STEEL POST. EXTEND TAPE TO 6" ABOVE GROUND.

A GALVANIZED STEEL POST
NOT TO SCALE DETAIL

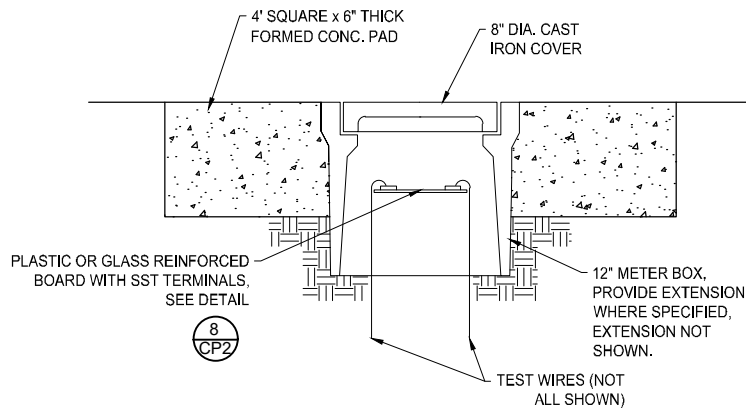


- NOTES:**
1. COLOR CODE WIRE INSULATION AS SHOWN IN APPLICABLE TEST STATION DETAILS, CONNECT EACH TEST WIRE TO SEPARATE TERMINAL.
 2. WIRE CONFIGURATION FOR FLUSH MOUNTED TEST STATIONS SIMILAR TO POST MOUNTED TEST STATIONS.
 3. PROVIDE 18 INCHES SLACK IN TEST WIRES, MINIMUM

B FLUSH MOUNT TEST STATION BOX
NOT TO SCALE DETAIL

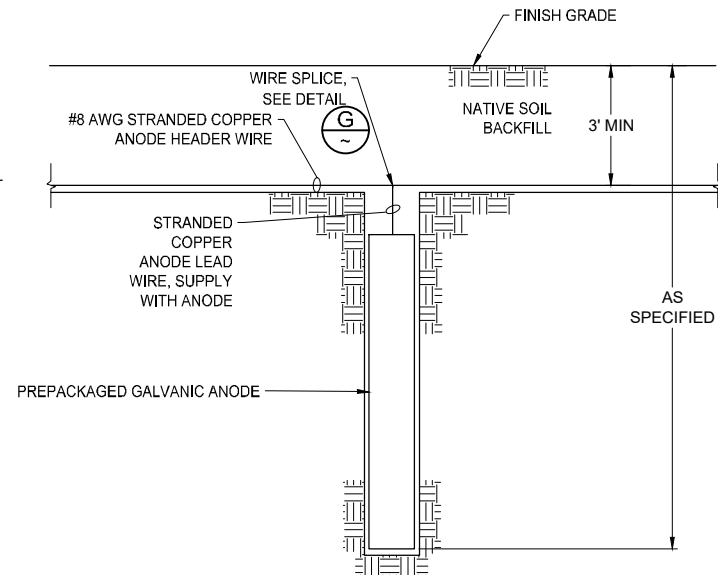


C GALVANIC ANODE VERTICAL INSTALLATION
NOT TO SCALE DETAIL

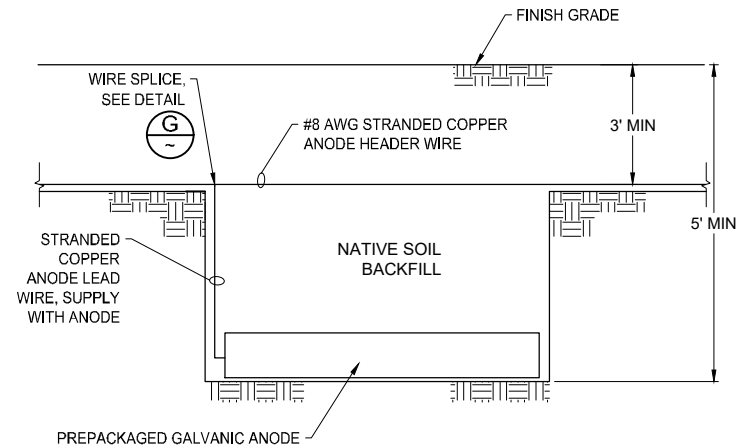


- NOTES:**
1. ANODES TO BE INSTALLED HORIZONTALLY UNLESS SPECIFIED OTHERWISE.
 2. ANODES INCLUDE AN ATTACHED LEAD WIRE FOR INSTALLATION.
 3. REMOVE ANODE FROM PLASTIC BEFORE INSTALLATION.
 4. ENSURE ANODES ARE NOT IN CONTACT WITH ANY OTHER BELOW GRADE STRUCTURES. AFTER ANODE INSTALLATION, BACKFILL TO 1-FOOT OVER THE ANODES, WATER ANODES WITH 5 GALLONS OF WATER PER ANODE, IF SOILS ARE DRY AS DETERMINED BY THE ENGINEER.
 5. WHEN POSSIBLE, PLACE ANODES WITHIN MOIST LOAM AND CLAY SOIL. AVOID PLACEMENT OF ANODES WITHIN DRY SAND AND DO NOT PLACE WITHIN GRAVEL.

D GALVANIC ANODE HORIZONTAL INSTALLATION
NOT TO SCALE DETAIL

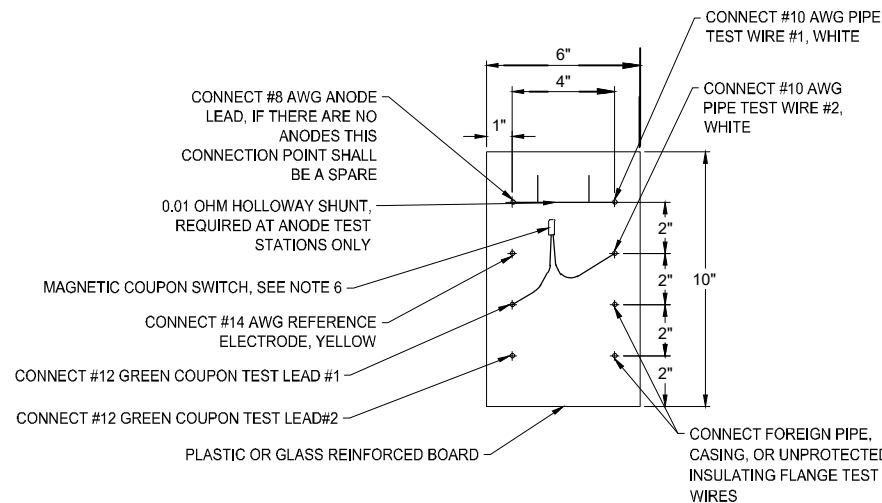


- NOTES:**
1. TERMINAL BOARD LAYOUT FOR REFERENCE ONLY AND MAY BE DIFFERENT ON PHYSICAL BOARD.
 2. TERMINALS SHALL BE 1/4" STAINLESS STEEL WITH LOCKING WASHER, TWO FLAT WASHERS, AND DOUBLE NUTS.
 3. ALL WIRE CONNECTIONS TO BE WITH RING TONGUE COMPRESSION TERMINALS.
 4. INSTALL AND LABEL EACH TEST LEAD IN TEST STATION.
 5. TEST WIRES NOT SHOWN FOR CLARITY.
 6. ONE (1) COUPON TO BE INSTALLED, OR AS SPECIFIED BY ENGINEER, WITH MAGNETIC COUPON. SWITCH INSTALLED BETWEEN ONE (1) COUPON TEST LEAD AND ONE (1) PIPE TEST LEAD.

E TERMINAL BOARD LAYOUT
NOT TO SCALE DETAIL

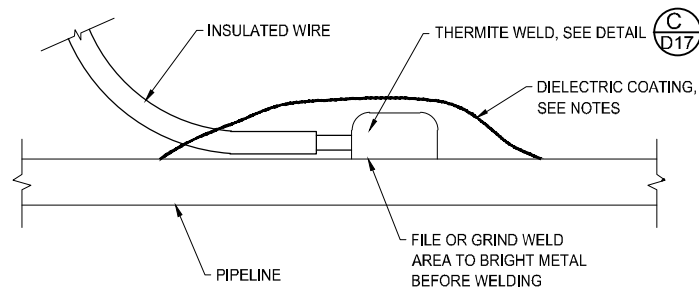

- NOTES:**
1. COPPER SLEEVE REQUIRED FOR #2 AWG JOINT BONDS OR FOR #12 AWG OR SMALLER TEST WIRES.
 2. WELDER AND CARTRIDGE SIZE VARIES ACCORDING TO PIPE SIZE AND PIPE MATERIAL, CONSULT WELDER MANUFACTURER FOR RECOMMENDED WELDER AND CARTRIDGE.
 3. COAT ALL THERMITE WELDS, PIPE, AND EXPOSED COPPER WIRE WITH DENSO PROTAL (7125, 7200, 7300) OR APPROVED EQUAL OR COATING SYSTEM AS SPECIFIED.
 4. PIPELINE COATING NOT SHOWN FOR CLARITY.


F STEEL & DUCTILE IRON PIPE WIRE CONNECTION
NOT TO SCALE DETAIL

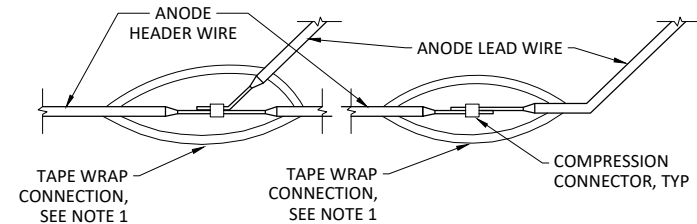

- NOTES:**
1. SCOTCHCAST 90-B1 SPICE KIT OR APPROVED EQUAL TO BE USED FOR ANODE LEAD WIRE TO ANODE HEADER WIRE SPLICE.
 2. FILL VOIDS AND IRREGULARITIES WITH INSULATING PUTTY, WRAP CONNECTION WITH TWO LAYERS OF SCOTCH 130C SELF VULCANIZING RUBBER TAPE OR APPROVED EQUAL AND TWO LAYERS OF SCOTCH 88 VINYL ELECTRICAL TAPE, OR APPROVED EQUAL.
 3. DETAIL SIMILAR FOR ANODE HEADER WIRE SPLICES, SIZE COMPRESSION CONNECTORS AS REQUIRED.


G GALVANIC ANODE WIRE SPLICES
NOT TO SCALE DETAIL

REV. NO.	COMMENT	DATE
 SUNRISE ENGINEERING		
770 S WASHINGTON ST. AFTON, WYOMING 83110 TEL 307.885.8500 · FAX 307.885.8501 www.sunrise-eng.com		
GR-RS-SC JPWB		
CROSSROADS PUMP STATION		
CATHODIC PROTECTION DETAILS		
SEI NO. 07265	DESIGNED FDK	DRAWN BJ
CHECKED JUL	SHEET NO. 93 of 99	D15

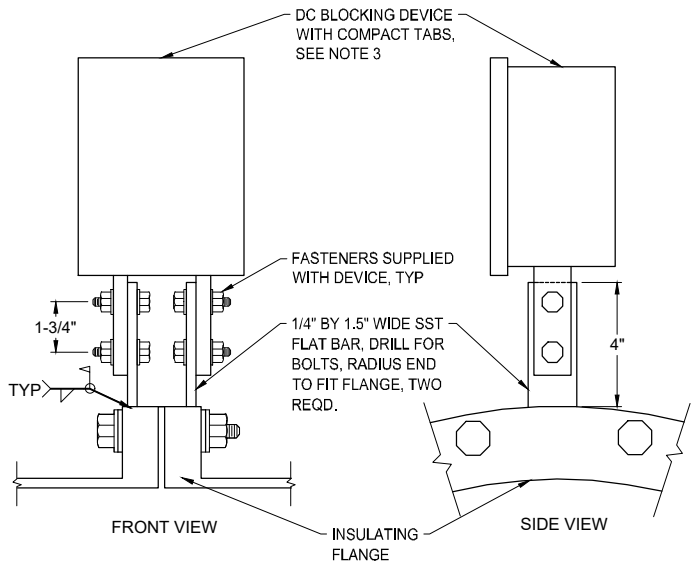


- NOTES:
- DO NOT COAT MOUNTING PLATES, FASTENERS, OR DEVICE TABS AFTER ASSEMBLY, CLEAN AND COAT WELD ONLY.
 - NEGATIVE TAB OF DC BLOCKING DEVICE TO BE ON CATHODICALLY PROTECTED SIDE OF INSULATING FLANGE.
 - COMPACT TABS ON BLOCKING DEVICE SHOWN FOR TOP MOUNTING, USE STANDARD TABS FOR MOUNTING AT PIPE SPRINGLINE.

(A) DC BLOCKING DEVICE FLANGE MOUNT
NOT TO SCALE DETAIL

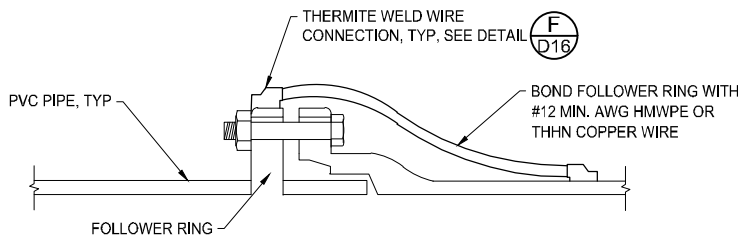


(D) MECHANICAL JOINT BOND WITH FOLLOWER RING
NOT TO SCALE DETAIL

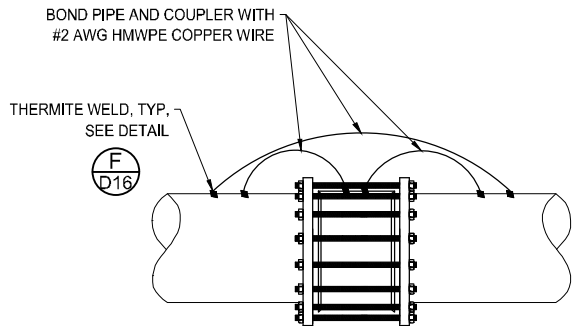


(H) COUPLER BOND
NOT TO SCALE DETAIL

- NOTES:
- INSTALL TWO (2) BOND WIRES PER JOINT OR AS SPECIFIED FOR PIPE DIAMETER AND MATERIAL.
 - COAT ALL THERMITE WELDS, PIPE, AND EXPOSED COPPER WIRE WITH DENSO PROTAL (7125, 7200, 7300) OR COATING SYSTEM AS SPECIFIED.
 - PIPELINE COATING NOT SHOWN FOR CLARITY.

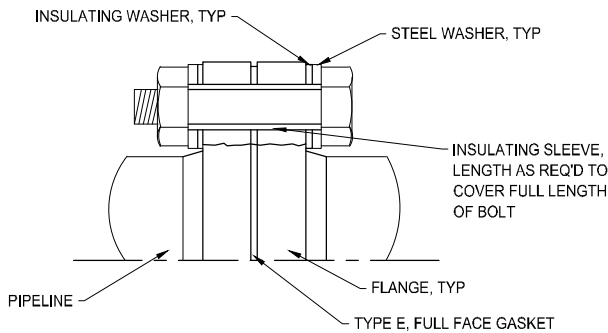


- NOTES:
- DOUBLE INSULATING WASHERS SHOWN FOR NON-BURIED INSULATING FLANGE INSTALLATIONS.
 - FOR BURIED OR SUBMERGED INSULATING FLANGE INSTALLATION USE SINGLE INSULATING WASHER ON UNPROTECTED SIDE OF INSULATING FLANGE.
 - COAT INTERIOR OF MORTAR LINED PIPE FOR TWO PIPE DIAMETERS WITH NSF APPROVED EPOXY AT 20 MILS DFT.
 - COAT BURIED OR IMMERSED INSULATING FLANGES WITH SPECIFIED PIPELINE DIELECTRIC JOINT COATING OR HEAT SHRINK SLEEVE WITH MORTAR OVERCOAT ON MLC STEEL PIPE.
 - TEST COMPLETED JOINT FOR ELECTRICAL ISOLATION AND REPAIR AS REQUIRED.

(B) EXOTHERMIC WELD PROCEDURE
NOT TO SCALE DETAIL

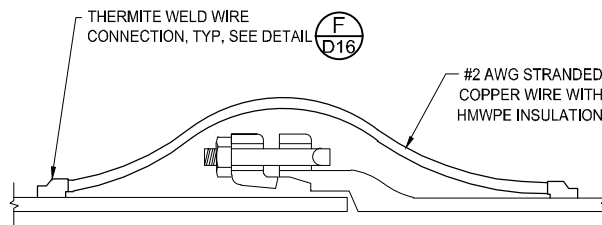


(E) MECHANICAL JOINT BOND
NOT TO SCALE DETAIL

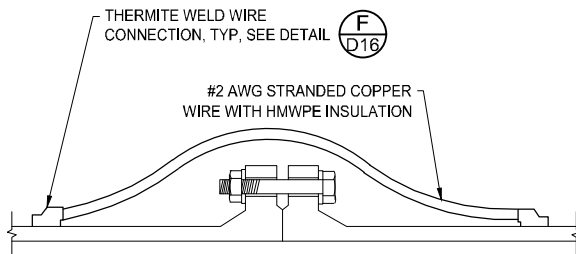


- NOTES:
- INSTALL TWO (2) BOND WIRES PER JOINT OR AS SPECIFIED FOR PIPE DIAMETER AND MATERIAL.
 - COAT ALL THERMITE WELDS, PIPE, AND EXPOSED COPPER WIRE WITH DENSO PROTAL (7125, 7200, 7300) OR APPROVED EQUAL OR COATING SYSTEM AS SPECIFIED.
 - PIPELINE COATING NOT SHOWN FOR CLARITY.

(I) FLANGED JOINT BOND
NOT TO SCALE DETAIL

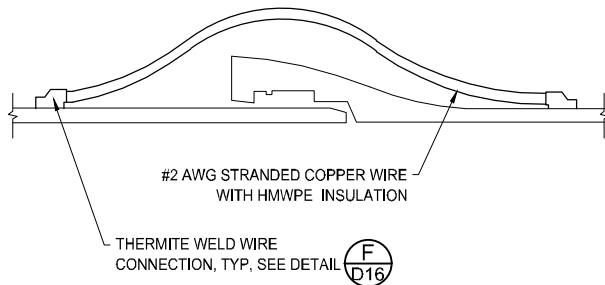


- NOTES:
- PUSH ON DUCTILE IRON BOND SHOWN, SIMILAR FOR DUCTILE MECHANICAL AND RESTRAINED JOINTS, AND STEEL CARNEGIE JOINTS.
 - INSTALL TWO (2) BOND WIRES PER JOINT OR AS SPECIFIED FOR PIPE DIAMETER AND MATERIAL.
 - COAT ALL THERMITE WELDS, PIPE, AND EXPOSED COPPER WIRE WITH DENSO 3. PROTAL (7125, 7200, 7300) OR APPROVED EQUAL OR COATING SYSTEM AS SPECIFIED.
 - PIPELINE COATING NOT SHOWN FOR CLARITY.

(C) DUCTILE IRON JOINT BOND
NOT TO SCALE DETAIL

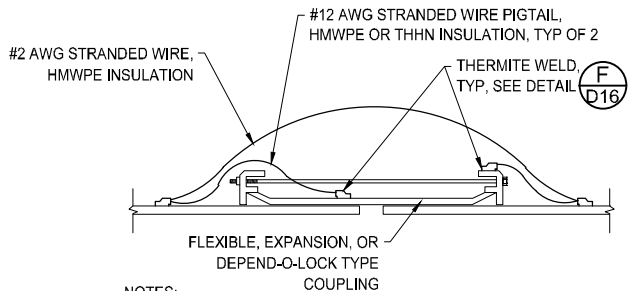

- NOTES:
- INSTALL TWO (2) BOND WIRES PER JOINT OR AS SPECIFIED FOR PIPE DIAMETER AND MATERIAL.
 - COAT ALL THERMITE WELDS, PIPE, AND EXPOSED COPPER WIRE WITH DENSO PROTAL (7125, 7200, 7300) OR APPROVED EQUAL OR COATING SYSTEM AS SPECIFIED.
 - PIPELINE COATING NOT SHOWN FOR CLARITY.

(F) FLEXIBLE JOINT BOND
NOT TO SCALE DETAIL


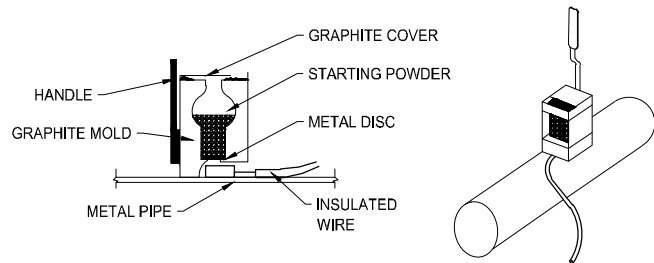


- STEP 1** FILE STRUCTURE CONNECTION AREA (3IN X 3IN) TO BARE SHINY METAL AND CLEAN.
- STEP 2** STRIP INSULATION FROM WIRE.
- STEP 3** HOLD MOLD FIRMLY WITH OPENING AWAY FROM OPERATOR AND IGNITE WITH STRIKER.
- STEP 4** REMOVE SLAG FROM CONNECTION AND PEEN WELD FOR SOUNDNESS.
- STEP 5** COVER CONNECTION AND EXPOSED STRUCTURE SURFACE WITH A WITH DIELECTRIC COATING AS SPECIFIED.

- EXOTHERMIC WELD NOTES:
- ONE WELD SHALL BE USED FOR EACH.
 - CLEAN OILY OR GREASY CABLE WITH A RAPID-DRYING SOLVENT. REMOVE ONLY ENOUGH INSULATION FROM THE CABLE TO ALLOW THE EXOTHERMIC WELD CONNECTION TO BE MADE.
 - REMOVE ALL COATING, DIRT, GRIME, AND GREASE FROM THE METAL AT WELD LOCATIONS BY WIRE BRUSHING AND/OR USE OF SOLVENTS. CLEAN THE BASE METAL TO A BRIGHT, SHINY SURFACE. THE AREA OF THE BASE METAL WHERE THE ATTACHMENT IS TO BE MADE MUST BE DRY.
 - OPEN WELD MOLD AND PLACE METAL DISC INSIDE AT BOTTOM OF MOLD, POUR METAL WELDING POWDER INTO MOLD AND ON TOP OF METAL DISC. STARTING POWDER IS CAKED AT THE BOTTOM OF THE WELD CHARGE CONTAINER. TAP WELD CHARGE CONTAINER AND POUR HALF OF STARTING POWDER INTO WELD MOLD. CLOSE THE TOP OF WELD MOLD AND POUR THE REMAINING STARTING POWDER IN STRIKING HOLE. THE WELD MOLD IS NOW LOADED AND READY FOR USE.
 - PROVIDE PREFABRICATED FACTORY SLEEVES WHERE REQUIRED BY THERMITE 5. WELDING MANUFACTURER.
 - THE LEAD WIRE IS TO BE HELD AT AN ANGLE TO THE SURFACE WHEN WELDING. ONLY ONE WIRE SHALL BE ATTACHED WITH EACH WELD. HOLD LOADED WELD MOLD FIRMLY ON PIPE AND WIRE. IGNITE STARTING POWDER IN STRIKING HOLE USING A STRIKER. HOLD WELD MOLD FIRMLY AGAINST PIPE FOR 5 SECONDS TO ALLOW FOR WELD PROCESS.
 - WELDS SHALL BE TESTED BY STRIKING THE WELD NUGGET WITH A TWO POUND HAMMER WHILE PULLING FIRMLY ON THE WIRE. ALL UNSOUND WELDS SHALL BE REMOVED, THE SURFACES RECLEANED, REWELDED, AND RETESTED. WELD SLAG SHALL BE REMOVED.
 - APPLY DIELECTRIC COATING AS SHOWN AND SPECIFIED TO WELD AND ALL EXPOSED AREAS SURROUNDING WELD.

(G) EXOTHERMIC WELD PROCEDURE
NOT TO SCALE DETAIL

REV. NO.	COMMENT	DATE
SUNRISE ENGINEERING 770 S WASHINGTON ST. AFTON, WYOMING 83110 TEL 307.885.8500 · FAX 307.885.8501 www.sunrise-eng.com		
GR-RS-SC JPWB		
CROSSROADS PUMP STATION		
CATHODIC PROTECTION DETAILS		
SEI NO. 07265	DESIGNED FDK	DRAWN BJ
CHECKED JUL	SHEET NO. 94 of 99	D16

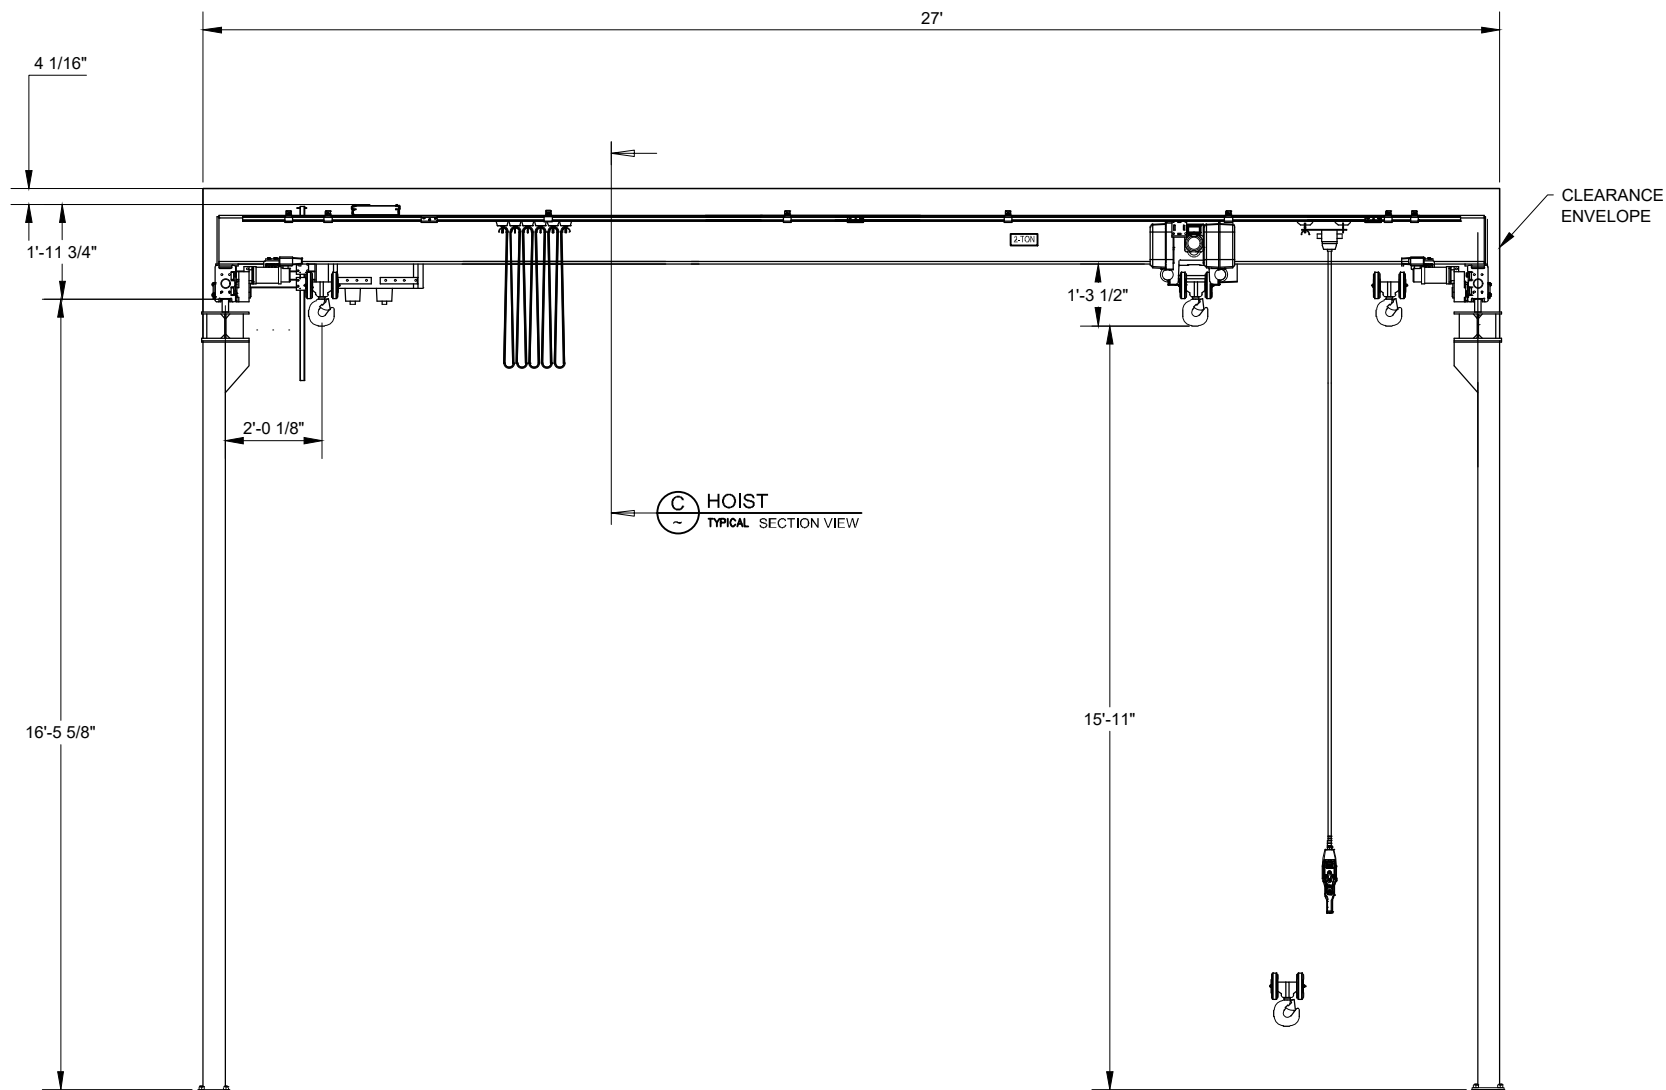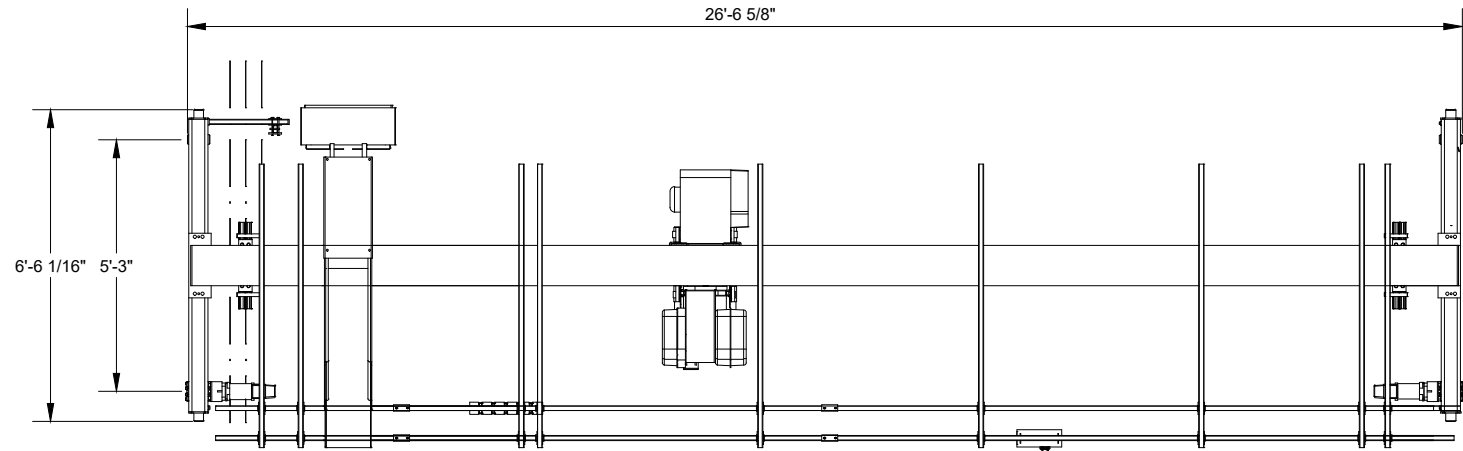

A HOIST
~ TYPICAL ELEVATION VIEW

TECHNICAL DATA


SPAN: 27'-0"
LOAD: 2-TON
LIFTING HEIGHT: 16'-0"
HOISTING SPEED: 20.0/3.2 ft/min 2-Speed
TRAVERSING SPEED: 65 ft/min Stepless
TRAVELING SPEED: 100 ft/min Stepless
WEIGHT OF TROLLEY: 480 lbs.
WEIGHT OF BRIDGE: 2870lbs.
CRANE CLASSIFICATION: CMAA Class C
HOIST GROUP: ASME H4
CRANE DRIVE GROUP: CMAA C
MAIN/CONTROL VOLTAGE: 460/ 115 V; 60Hz
SUPPLY POWER: 4.11 Hp
LENGTH OF RUNWAY: 45'

SURFACE TREATMENT OF CRANE

BRIDGE COLOR : Safety Yellow
PAINT : A/127 μ m


CUSTOMER ORGANIZES SAFE
PLATFORM FOR CRANE SERVICE

Indoor Use crane

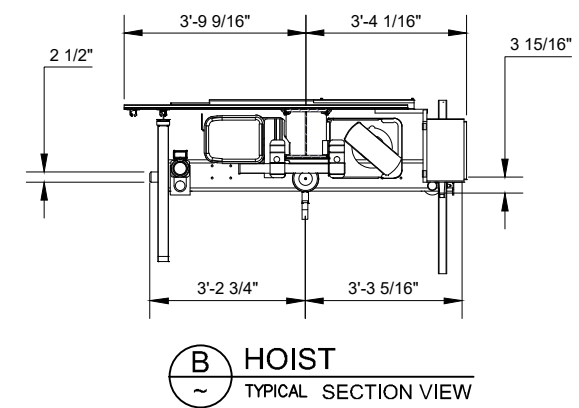


B HOIST
~ TYPICAL SECTION VIEW

REV. NO.	COMMENT	DATE
 SUNRISE ENGINEERING 770 S WASHINGTON ST. AFTON, WYOMING 83110 TEL 307.885.8500 • FAX 307.885.8501 www.sunrise-eng.com		
GR-RS-SC JPWB		
CROSSROADS PUMP STATION		
PUMP STATION HOIST DETAILS		
SEI NO. 07265	DESIGNED FDK	DRAWN BJ
CHECKED JUL	SHEET NO. 95 of 99	D17

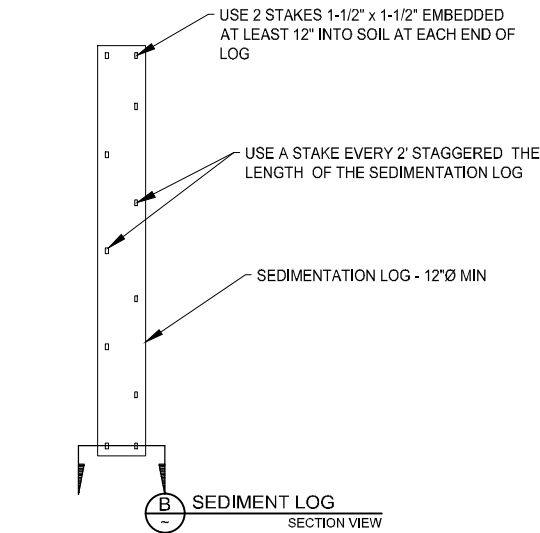


A SEDIMENT LOG
NOT TO SCALE PLAN VIEW

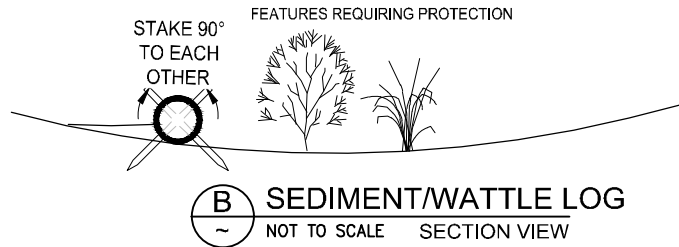

SEDIMENT CONTROL LOG INSTALLATION NOTES:


1. SEE PLAN VIEW FOR LOCATION AND LENGTH OF SEDIMENT CONTROL LOG.
2. SEDIMENT CONTROL LOGS INDICATED ON INITIAL SWMP PLAN SHALL BE INSTALLED PRIOR TO ANY LAND DISTURBING ACTIVITIES.
3. SEDIMENT CONTROL LOGS SHALL CONSIST OF STRAW, COMPOST, EXCELSIOR, OR COCONUT FIBER.
4. NOT FOR USE IN CONCENTRATED FLOW AREAS.
5. THE SEDIMENT CONTROL LOG SHALL BE TRENCHED INTO THE GROUND A MINIMUM OF 2".

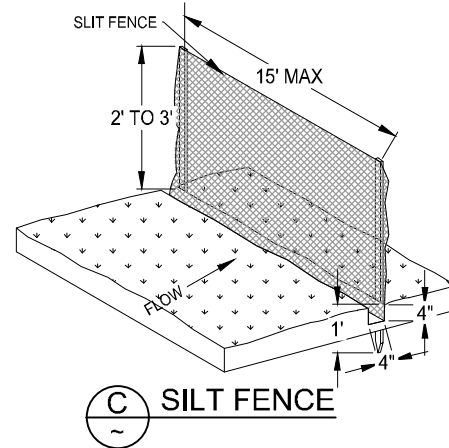

C SILT FENCE
NOT TO SCALE SECTION VIEW


SEDIMENT CONTROL LOG MAINTENANCE NOTES:

1. THE SWMP MANAGER SHALL INSPECT SEDIMENT CONTROL LOGS DAILY, DURING AND AFTER ANY STORM.
2. SEDIMENT ACCUMULATED UPSTREAM OF SEDIMENT CONTROL LOGS SHALL BE REMOVED WHEN THE UPSTREAM SEDIMENT DEPTH IS WITHIN 1/2 THE HEIGHT OF THE CREST OF LOG.

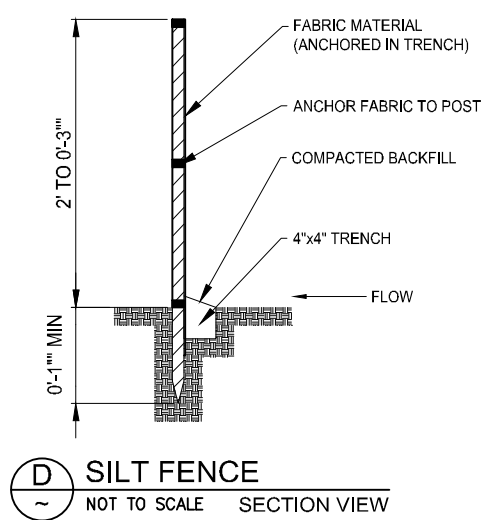


D SILT FENCE
NOT TO SCALE SECTION VIEW


NOTE: EROSION CONTROL MEASURES SHALL BE MAINTAINED UNTIL LANDSCAPING IS COMPLETED, OR AS DIRECTED BY LOCAL JURISDICTION

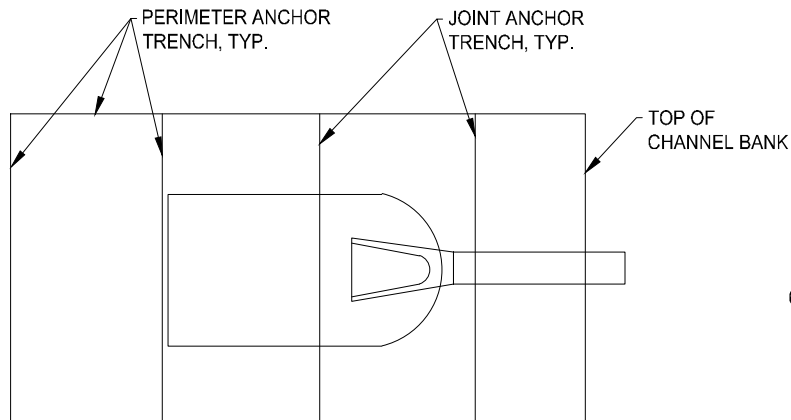

E EROSION BLANKET AT PIPE OUTLET
NOT TO SCALE PLAN VIEW

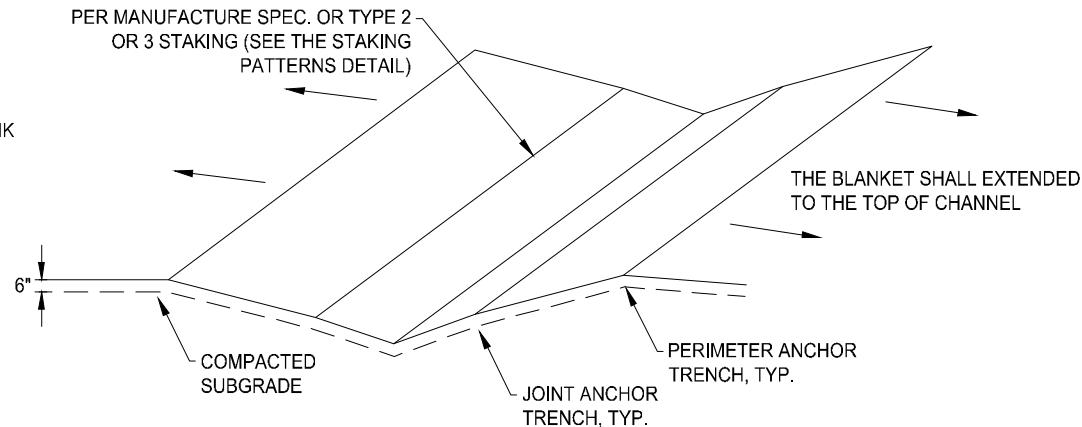


F EROSION BLANKET INSIDE SMALL DRAINAGE WAY
NOT TO SCALE DETAIL

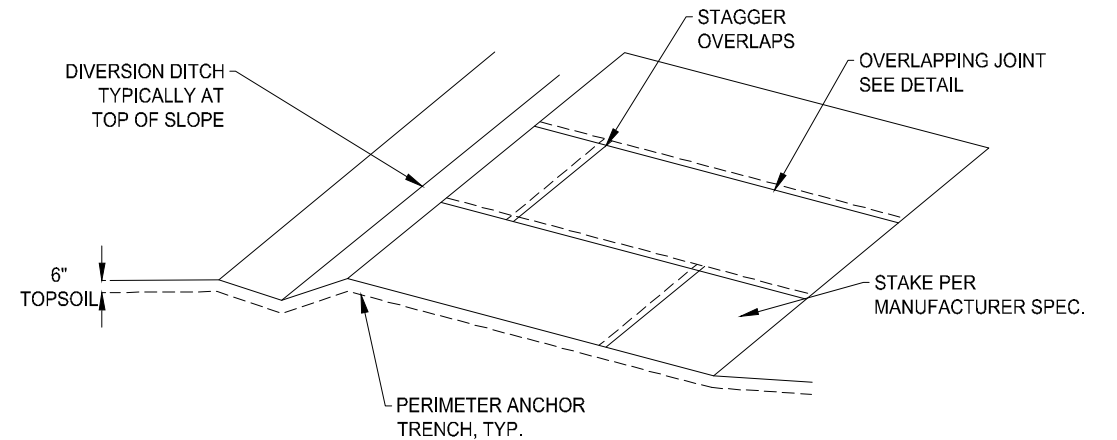


G EROSION BLANKET OUTSIDE OF DRAINAGE CHANNELS
NOT TO SCALE DETAIL

EROSION CONTROL BLANKET MAINTENANCE NOTES:


1. THE SWMP MANAGER SHALL INSPECT EROSION CONTROL BLANKET WEEKLY, DURING AND AFTER ANY STORM EVENT AND MAKE REPAIRS AS NEEDED.
2. EROSION CONTROL BLANKET IS TO BE LEFT IN PLACE UNLESS REQUESTED TO BE REMOVED BY LOCAL JURISDICTION.
3. IF FOR ANY REASON CONTROL BLANKET PULLED OUT, TORN, OR OTHERWISE DAMAGED SHALL BE RE-INSTALLED. ANY SUBGRADE AREAS BELOW THE BLANKET THAT HAVE ERODED TO CREATE A VOID UNDER THE BLANKET, OR THAT REMAIN DEVOID OF GRASS SHALL BE REPAIRED, RESEEDED AND MULCHED AND THE EROSION CONTROL BLANKET REINSTALLED.

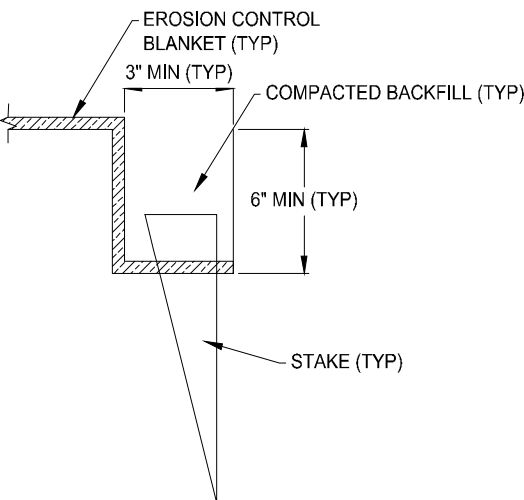


H PERIMETER TRENCH ANCHOR
NOT TO SCALE DETAIL

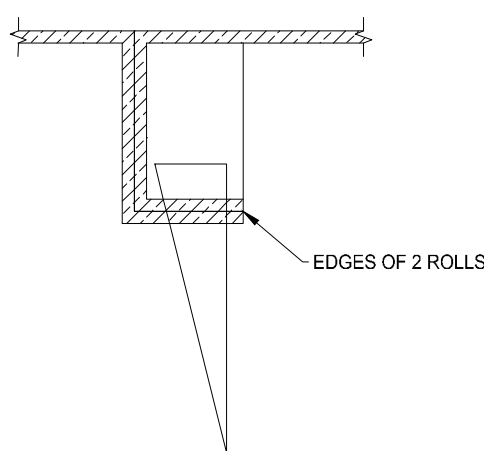

I JOINT TRENCH ANCHOR
NOT TO SCALE DETAIL

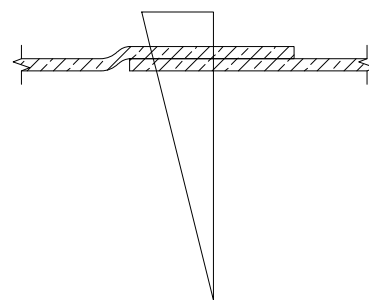


J OVERLAPPING JOINT
NOT TO SCALE DETAIL

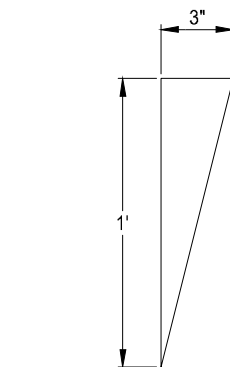

K WOOD STAKE
NOT TO SCALE DETAIL

NOTE: USE 2x4 MATERIAL FOR STAKES

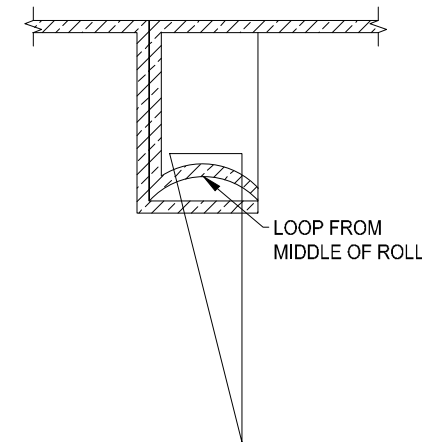

L INTERMEDIATE TRENCH ANCHOR
NOT TO SCALE DETAIL


EROSION CONTROL BLANKET INSTALLATION NOTES:

1. SEE PLAN VIEW FOR LOCATION OF EROSION CONTROL BLANKET.
2. ALL EROSION CONTROL BLANKETS SHALL BE MADE OF 100% NATURAL AND BIODEGRADABLE MATERIAL; NO PLASTIC OR OTHER SYNTHETIC MATERIAL, EVEN SHALL BE ALLOWED.
3. IN AREAS WHERE EROSION CONTROL BLANKET IS SHOWN ON THE PLANS, THE PERMITTEE SHALL PLACE TOPSOIL AND PERFORM FINAL GRADING, SURFACE

- PREPARATION, AND SEEDING BELOW THE SEEDING AND MULCHING. SUBGRADE SHALL BE SMOOTH AND MOIST PRIOR TO BLANKET INSTALLATION AND THE BLANKET SHALL BE IN FULL CONTACT WITH THE SUBGRADE.
4. PERIMETER ANCHOR TRENCH SHALL BE USED AT OUTSIDE PERIMETER OF ALL BLANKET AREAS.
5. JOINT TRENCH ANCHOR SHALL BE USED TO JOIN ROLLS OF BLANKETS TOGETHER.
6. INTERMEDIATE TRENCH ANCHOR SHALL BE USED AT SPACING OF 1/2 THE ROLL LENGTH.

7. THE OVERLAPPING JOINT DETAIL SHALL BE USED TO JOIN ROLLS OF BLANKETS TOGETHER FOR BLANKETS ON SLOPES.
8. ANY AREAS OF SEEDING AND MULCHING DISTURBED IN THE PROCESS OF INSTALLING EROSION CONTROL BLANKET SHALL BE RESEEDED AND MULCHED.
9. DETAILS ON DESIGN PLANS FOR MAJOR DRAINAGE WAY STABILIZATION WILL GOVERN IF DIFFERENT FROM ONES SHOWN HERE.

REV. NO.	COMMENT	DATE
SUNRISE ENGINEERING 770 S WASHINGTON ST. AFTON, WYOMING 83110 TEL 307.885.8500 · FAX 307.885.8501 www.sunrise-eng.com		
GR-RS-SC JPWB		
CROSSROADS PUMP STATION EROSION CONTROL DETAILS		
SEI NO. 07265	DESIGNED FDK	DRAWN BJ
CHECKED JUL	SHEET NO. 96 of 99	D18

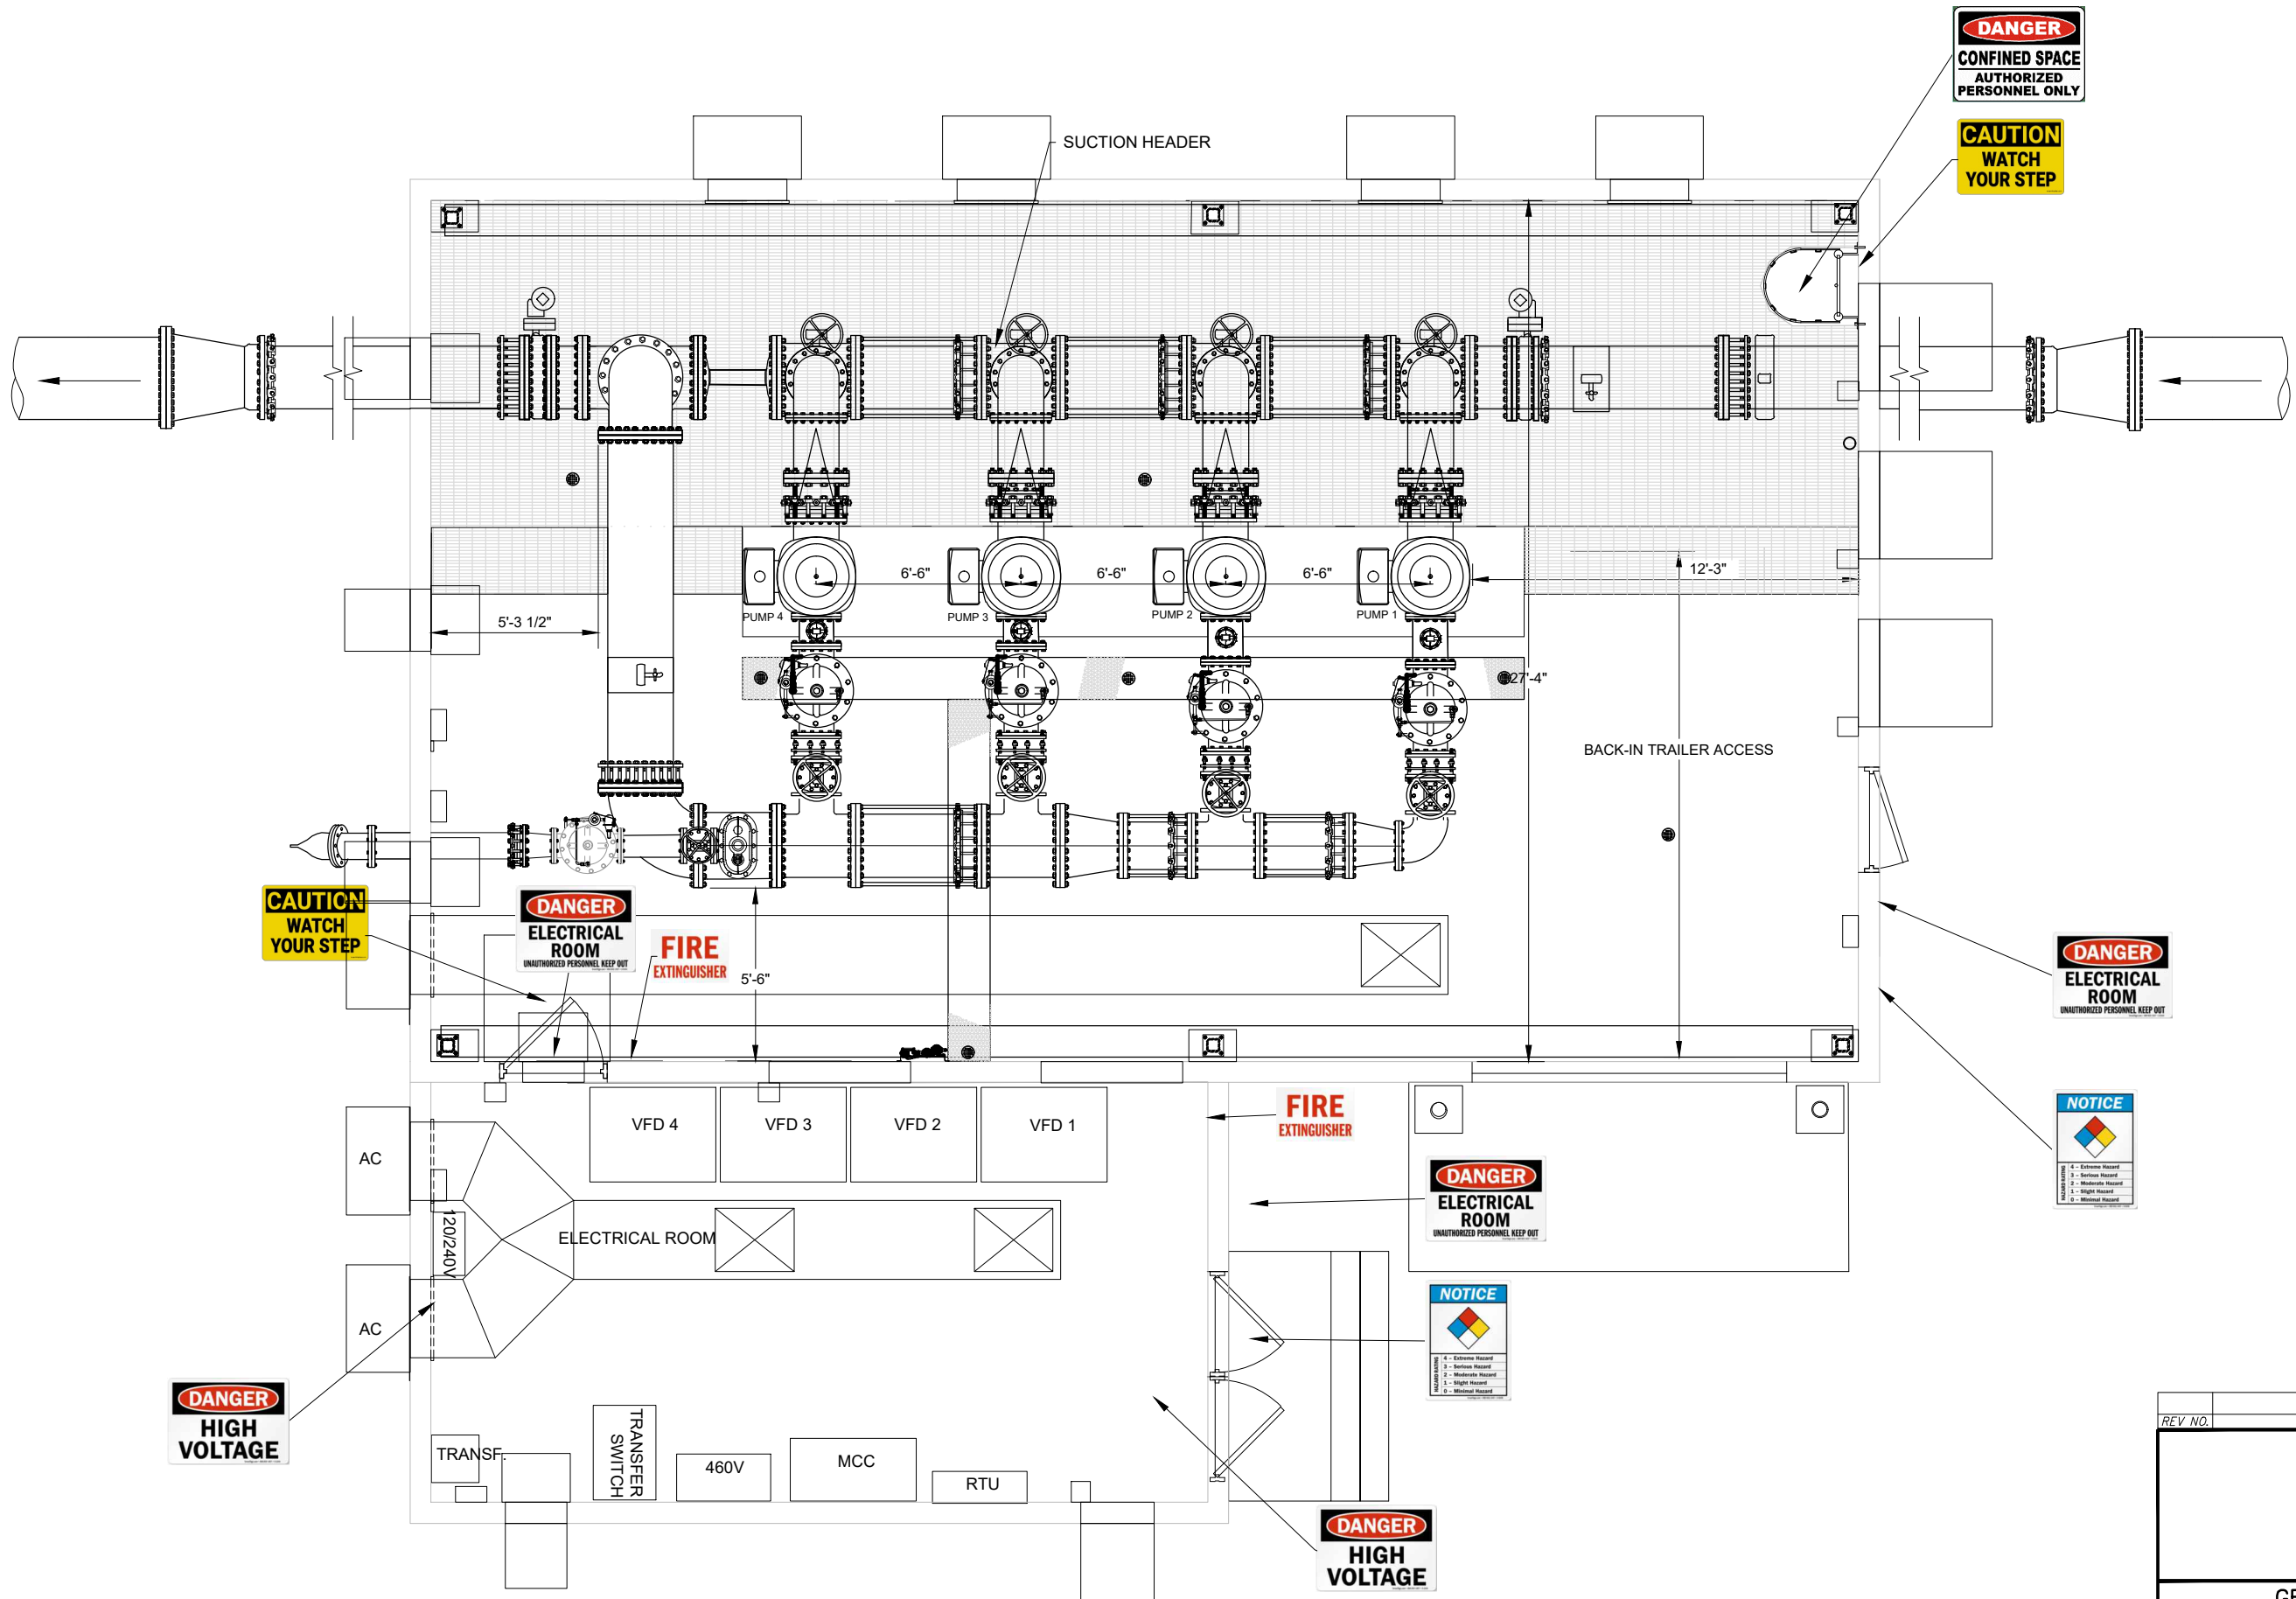

A PIPING
SCALE: 3/8"=1' PLAN VIEW

REV. NO.	COMMENT	DATE
SUNRISE ENGINEERING 770 S WASHINGTON ST. AFTON, WYOMING 83110 TEL 307.885.8500 • FAX 307.885.8501 www.sunrise-eng.com		
GR-RS-SC JPWB		
CROSSROADS PUMP STATION		
MECHANICAL PIPING SIGNS		
SEI NO. 07265	DESIGNED FDK	DRAWN BJ
CHECKED JUL	SHEET NO. 97 of 99	D19

P:\WDC GR-RS-SC JPWB Cross Roads Pump Station Level III (S07265)\Dwg CSD\Pump Station Details\Pump Station Layout.dwg Feb 13, 2026 9:42am bjenkins



STRUCTURE

3'

3'


7' MAX

PLACE CORNER BOLLARDS 3' OFF OF STRUCTURE CORNERS


PLACE INTERMEDIATE BOLLARDS AT A MAXIMUM OF 7' SPACING FROM CORNER BOLLARDS. ADD ADDITIONAL INTERMEDIATE BOLLARDS TO KEEP SPACING TO LESS THAN 7'.



REV NO.	COMMENT	DATE
 SUNRISE ENGINEERING 770 S WASHINGTON ST. AFTON, WYOMING 83110 TEL 307.885.8500 • FAX 307.885.8501 www.sunrise-eng.com		
GR-RS-SC JPWB		
CROSSROADS PUMP STATION		
PIPELINE DETAILS		
SEI NO. 07265	DESIGNED FDK	DRAWN BJ
CHECKED JUL	SHEET NO. 98 of 99	D20

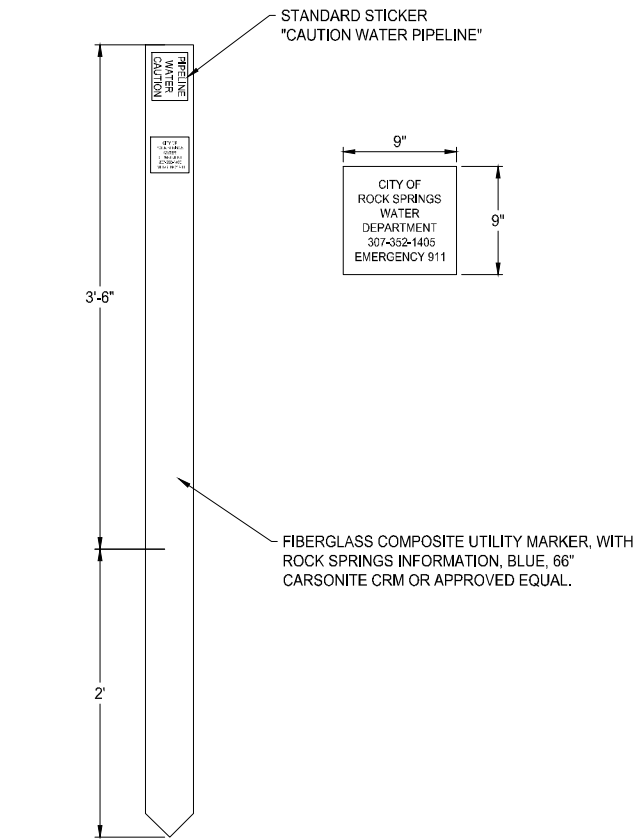


A FIBERGLASS MARKER POST
~ NOT TO SCALE DETAIL

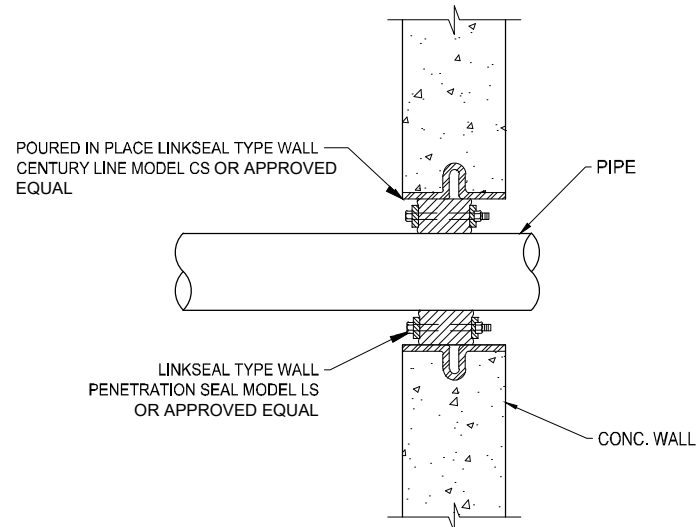

NOTES: CENTURY LINE SLEEVE OR APPROVED EQUAL TO BE SIZED FOR EACH PIPE AND WALL THICKNESS ACCORDING TO MANUFACTURES RECOMMENDATIONS CENTURY LINE SLEEVE END CAPS AS SUPPLIED BY MANUFACTURER, SHALL BE USED IN PLACING THE SLEEVE IN CONCRETE FORMS.

B PIPE PENETRATION CONCRETE WALL
~ NOT TO SCALE DETAIL

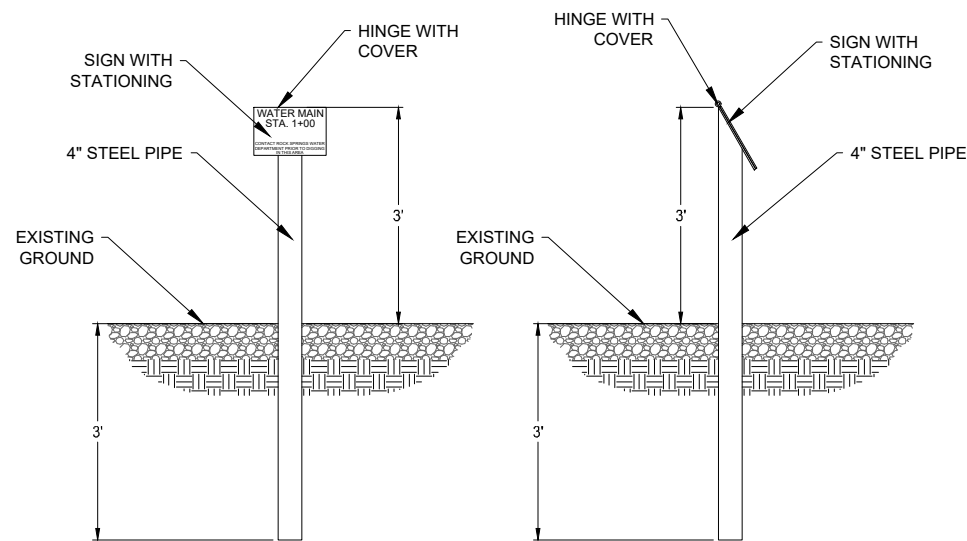

C WATERLINE SIGN
~ NOT TO SCALE DETAIL

NOTE: PAINT SIGN POST DARK BLUE

WATERLINE SIGN / MARKER POST LOCATIONS	
STATION	TYPE
4+95 @ BEND	WATERLINE SIGN - DETAIL E D20
14+10 @ BEND	WATERLINE SIGN - DETAIL E D20
16+42 @ BEND	WATERLINE SIGN - DETAIL E D20
18+40 @ BEND	WATERLINE SIGN - DETAIL E D20
23+60 @ BEND	WATERLINE SIGN - DETAIL E D20
31+40 @ BEND	WATERLINE SIGN - DETAIL E D20
32+40 @ BEND	WATERLINE SIGN - DETAIL E D20
35+48 @ BEND	WATERLINE SIGN - DETAIL E D20
37+55 @ BEND	WATERLINE SIGN - DETAIL E D20
41+57 @ BEND	WATERLINE SIGN - DETAIL E D20
43+30 @ BEND	WATERLINE SIGN - DETAIL E D20
49+10	FIBERGLASS MARKER POST DETAIL A D21
52+40	FIBERGLASS MARKER POST DETAIL A D21
58+00	FIBERGLASS MARKER POST DETAIL A D21
62+10	FIBERGLASS MARKER POST DETAIL A D21
74+00	FIBERGLASS MARKER POST DETAIL A D21
84+00	FIBERGLASS MARKER POST DETAIL A D21
94+00	FIBERGLASS MARKER POST DETAIL A D21
105+58 @ BEND	WATERLINE SIGN - DETAIL E D20
110+60 @ BEND	WATERLINE SIGN - DETAIL E D20
111+90 @ BEND	WATERLINE SIGN - DETAIL E D20
121+40	FIBERGLASS MARKER POST DETAIL A D21
131+40	FIBERGLASS MARKER POST DETAIL A D21
135+50 @ BEND	WATERLINE SIGN - DETAIL E D20

NOTE: FIVE ADDITIONAL FIBERGLASS MARKER POSTS ARE TO BE PROVIDED WITH LOCATION TO BE DETERMINED IN FIELD.

REV. NO.	COMMENT	DATE
SUNRISE ENGINEERING 770 S WASHINGTON ST. AFTON, WYOMING 83110 TEL 307.885.8500 · FAX 307.885.8501 www.sunrise-eng.com		
GR-RS-SC JPWB		
CROSSROADS PUMP STATION		
PIPELINE DETAILS		
SEI NO. 07265	DESIGNED FDK	DRAWN BJ
CHECKED JUL	SHEET NO. 99 of 99	D21